




Notes:
 1. This Drawing is only to be used for the Design Element identified in the title box. All other information shown on the drawing is to be considered indicative only.
 2. These drawings are to be used in conjunction with all other relevant design drawings, TII SRW and Appendices to series 500 of the Specification.
 3. Refer to GCOB-500 Series 500 Drawings for drainage layout details.

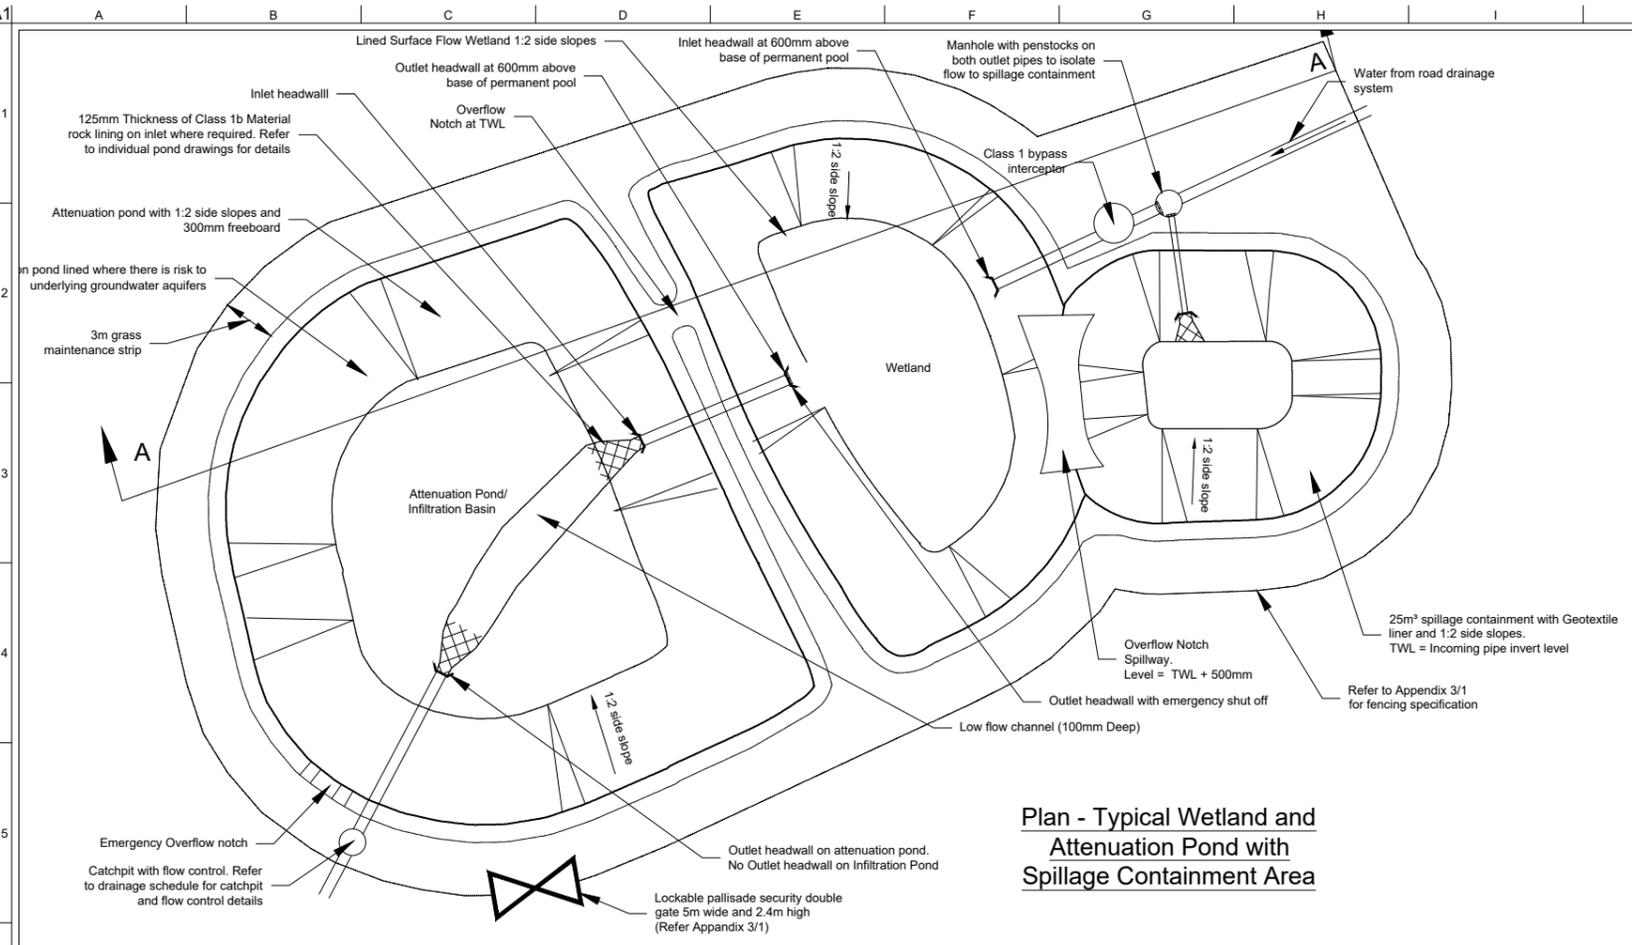


Plan - Typical Wetland and Attenuation Pond with Spillage Containment Area

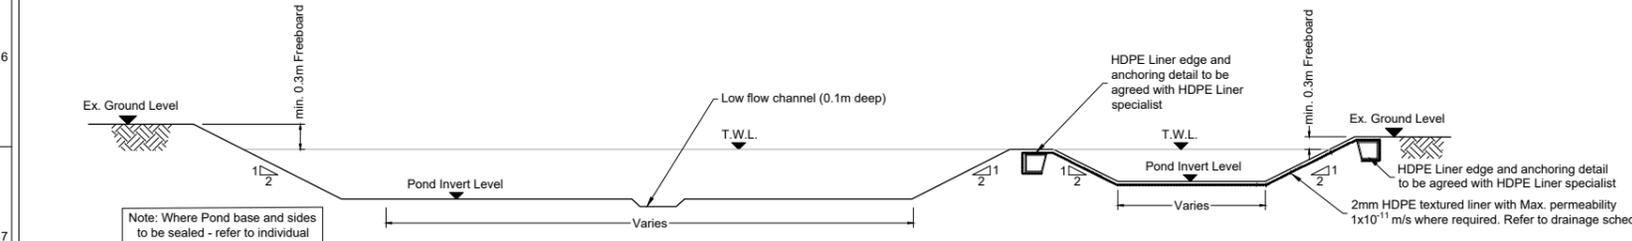


Section A-A

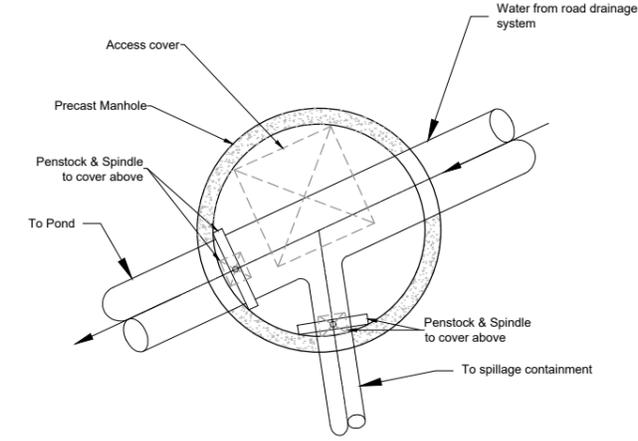


Typical Penstock detail - Plan

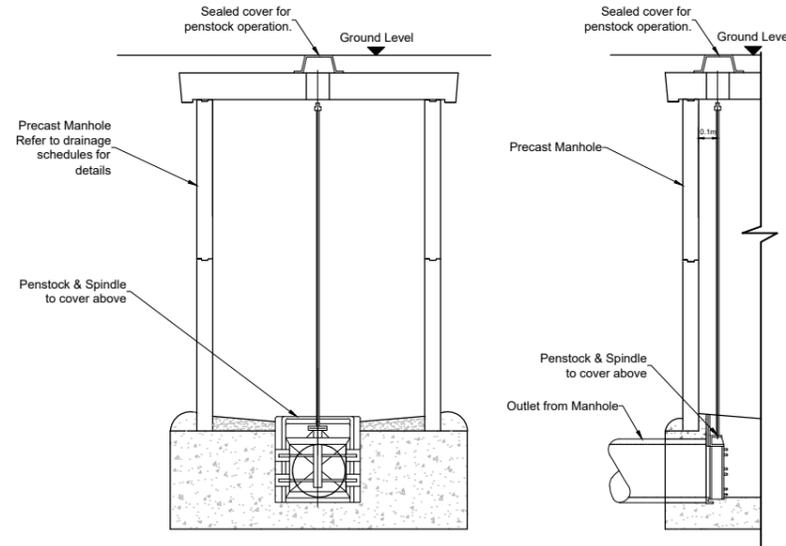

Typical Penstock detail - Sections

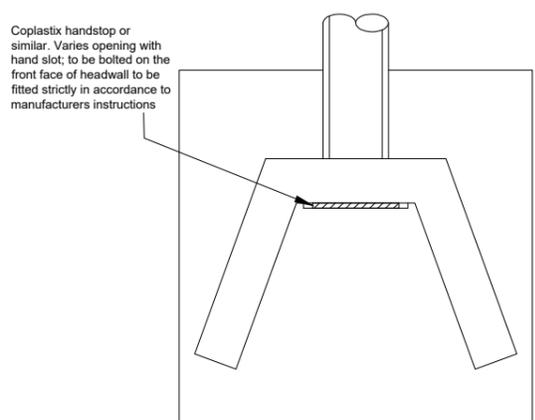


Plan

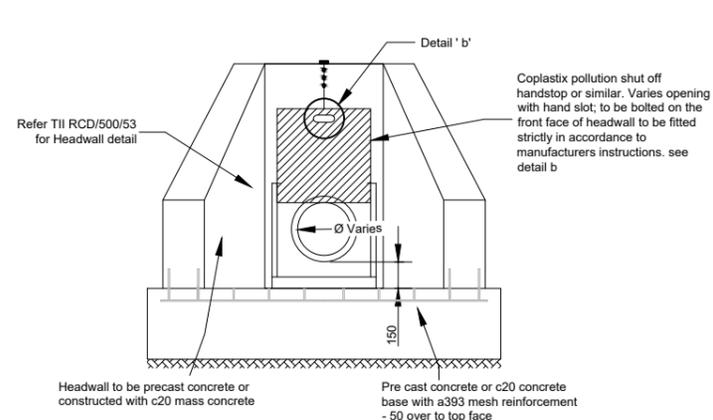

Elevation

Headwall with Emergency Shut off

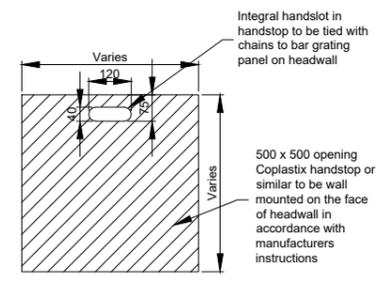

Detail 'b' Pollution shut off handstop

<p>Clients</p>	<p>Consultant</p> <p>Corporate House City East Business Park Ballybrit, Galway, Ireland.</p> <p>Tel +353 (0)91 460675 www.N6GalwayCity.ie www.arup.ie</p>	<p>Job Title</p> <p>N6 Galway City Ring Road</p> <p>Scale N.T.S</p> <p>Date: February 2018</p>	<p>Drawing Title</p> <p>General Arrangement Ponds and Pollution Control Sheet 1 of 1</p> <p>Drawing Status</p> <p>For Information</p> <table border="1"> <tr> <td>Job No</td> <td>Drawing No</td> <td>Issue</td> </tr> <tr> <td>233985</td> <td>GCOB-500-D-301</td> <td>11</td> </tr> </table>	Job No	Drawing No	Issue	233985	GCOB-500-D-301	11
Job No	Drawing No	Issue							
233985	GCOB-500-D-301	11							