

**Status Key**

SL	Survey
SK	Sketch Design
INFO	Information
PL	Planning Part - 8
DD	Detailed Design
FSC	Fire Safety Cert.
DAC	Dis. Acc. Cert
T	Tender
C	Construction
CPO	CPO
SF	Safety File
O	Other

**Rev: Date: Description: Issued by:**

Project Title:  
Downings Facility Centre for Water Sports Activities

Location:  
Croknamurleog, Na Dúnaibh, Co. Donegal

Drawing Title:  
Proposed Ground Floor Plans & Sections


Scale: 1 : 100 @A3  
Drawn By: John Kelly

Checked By: Checker  
Approved By: Approver


First Issue Date: Dec 2025  
Status: PL

Drawing No. A.3.1.101  
Revision:


Project No.  
24-03

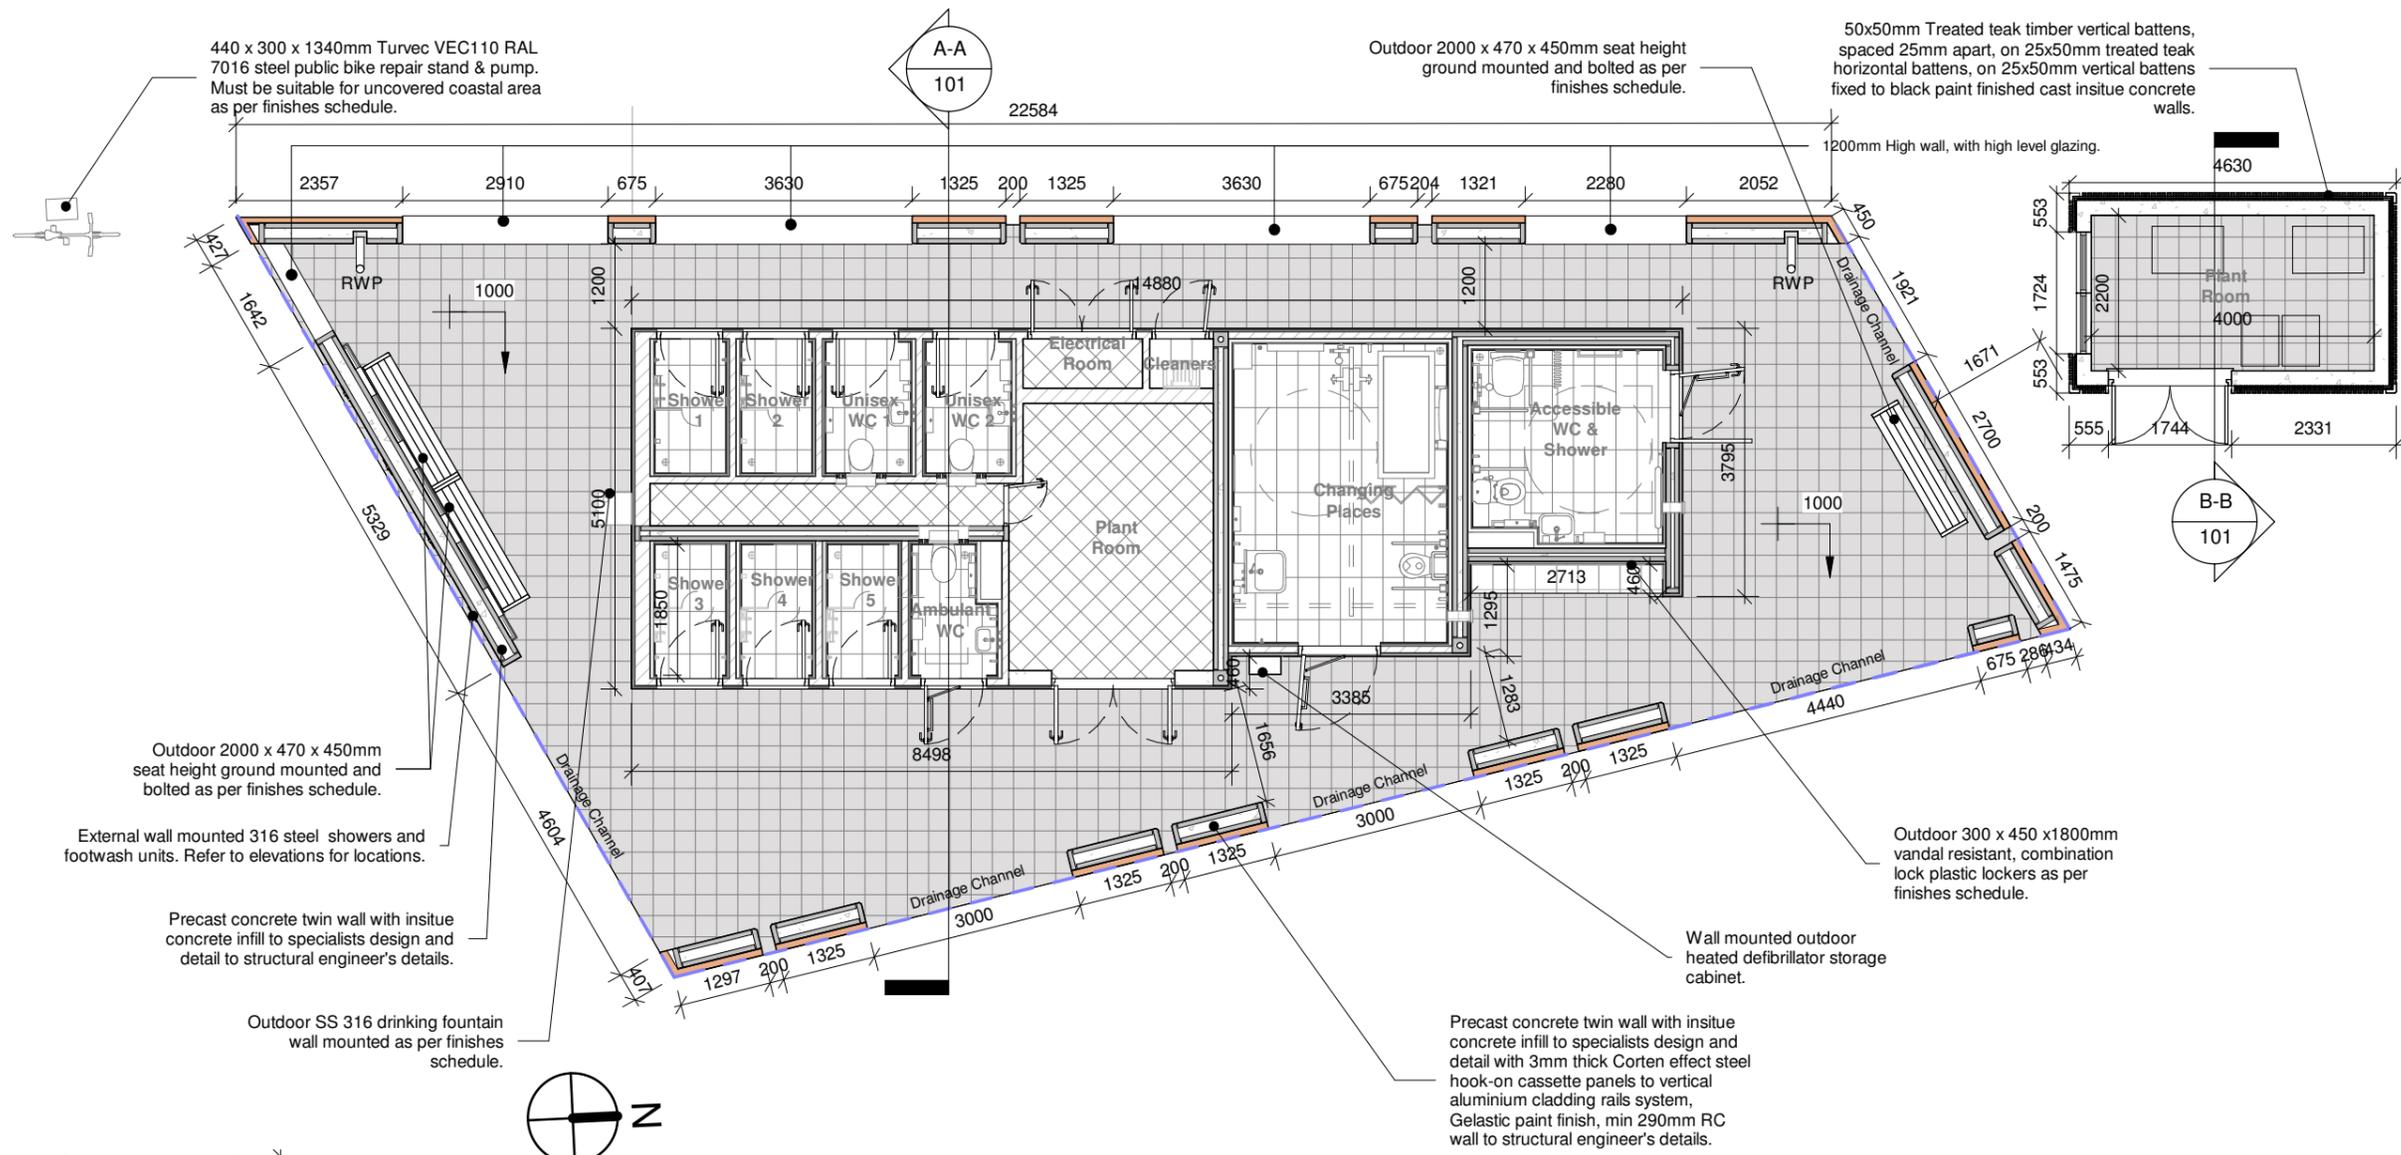

**1.0 - Ground Floor Plan**  
1 : 100

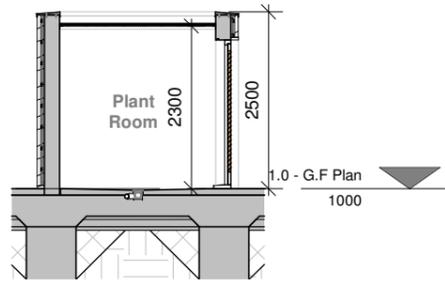

**Section B-B**  
1 : 100

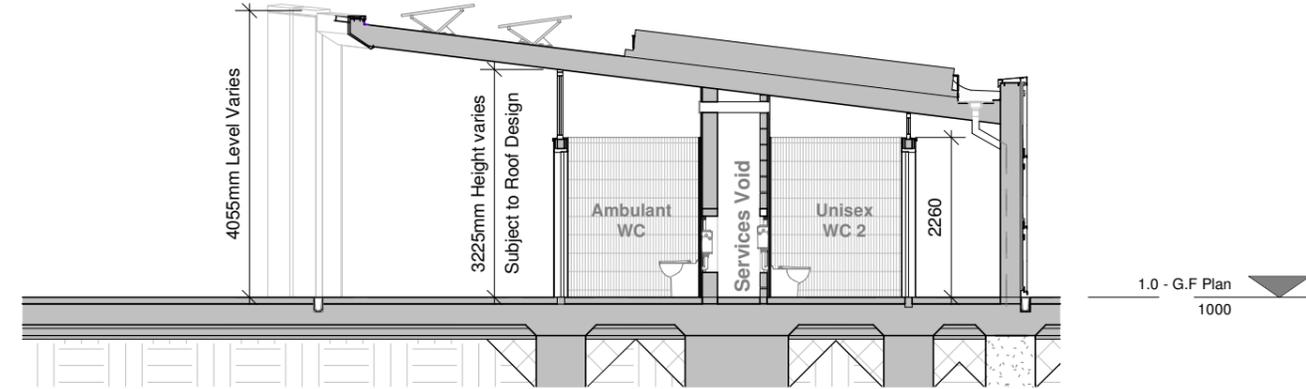

**Section A-A**  
1 : 100



**Proposed 3D Site Image No.1**