



Notes:
1. ALL DIMENSIONS ARE IN METRES AND ALL LEVELS ARE IN METRES AOD MALIN HEAD UNLESS OTHERWISE STATED
2. THIS DRAWING IS FOR PLANNING PURPOSES ONLY.

OSI Sheet No(s):
4447-C, 4447-D

- LEGEND
- PLANNING APPLICATION BOUNDARY
 - INDICATIVE PERMANENT WAYLEAVE
 - 2.4m HIGH PALADIN SITE SECURITY FENCE
 - COUNTY BOUNDARY

F01	FINAL FOR PLANNING	EM	BG	BG	DEC 25
A01	FOR PLANNING	JM	BG	BG	FEB 25
Rev	Description	Drawn	Chk'd	App'd	Date

This drawing is the property of Irish Water and must not be copied or used for any purpose other than that for which it is supplied without the written consent of Irish Water.

UISCE ÉIREANN
COLVILL HOUSE,
TALBOT STREET,
DUBLIN 1,
IRELAND

Call 1890 278 278
Int: 00 353 1 707 2828

Tionscadal
Soláthair Uisce
Water Supply
Project

Jacobs TOBIN

Originated By DC	Drawn By JM	Checked By BG	Approved By BG
Date 07.02.25	Date 01.12.25	Date 01.12.25	Date 01.12.25

 


Scale
1:2500 @ A1

Project Title
**WATER SUPPLY PROJECT
EASTERN AND MIDLANDS REGION**

Drawing Title
**RAW WATER INTAKE
AND PUMPING STATION
SITE LOCATION PLAN**

Drawing Status: FINAL FOR PLANNING
Jacobs Tobin No. 32105801 Client No. 9318

Drawing No.
32105801-850-01000

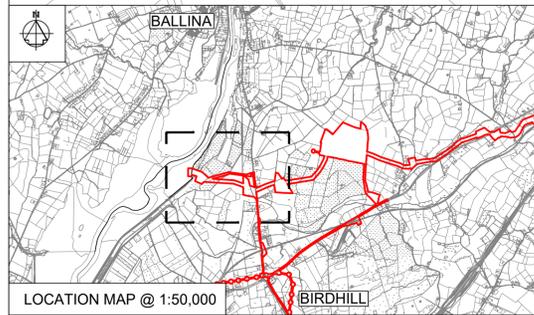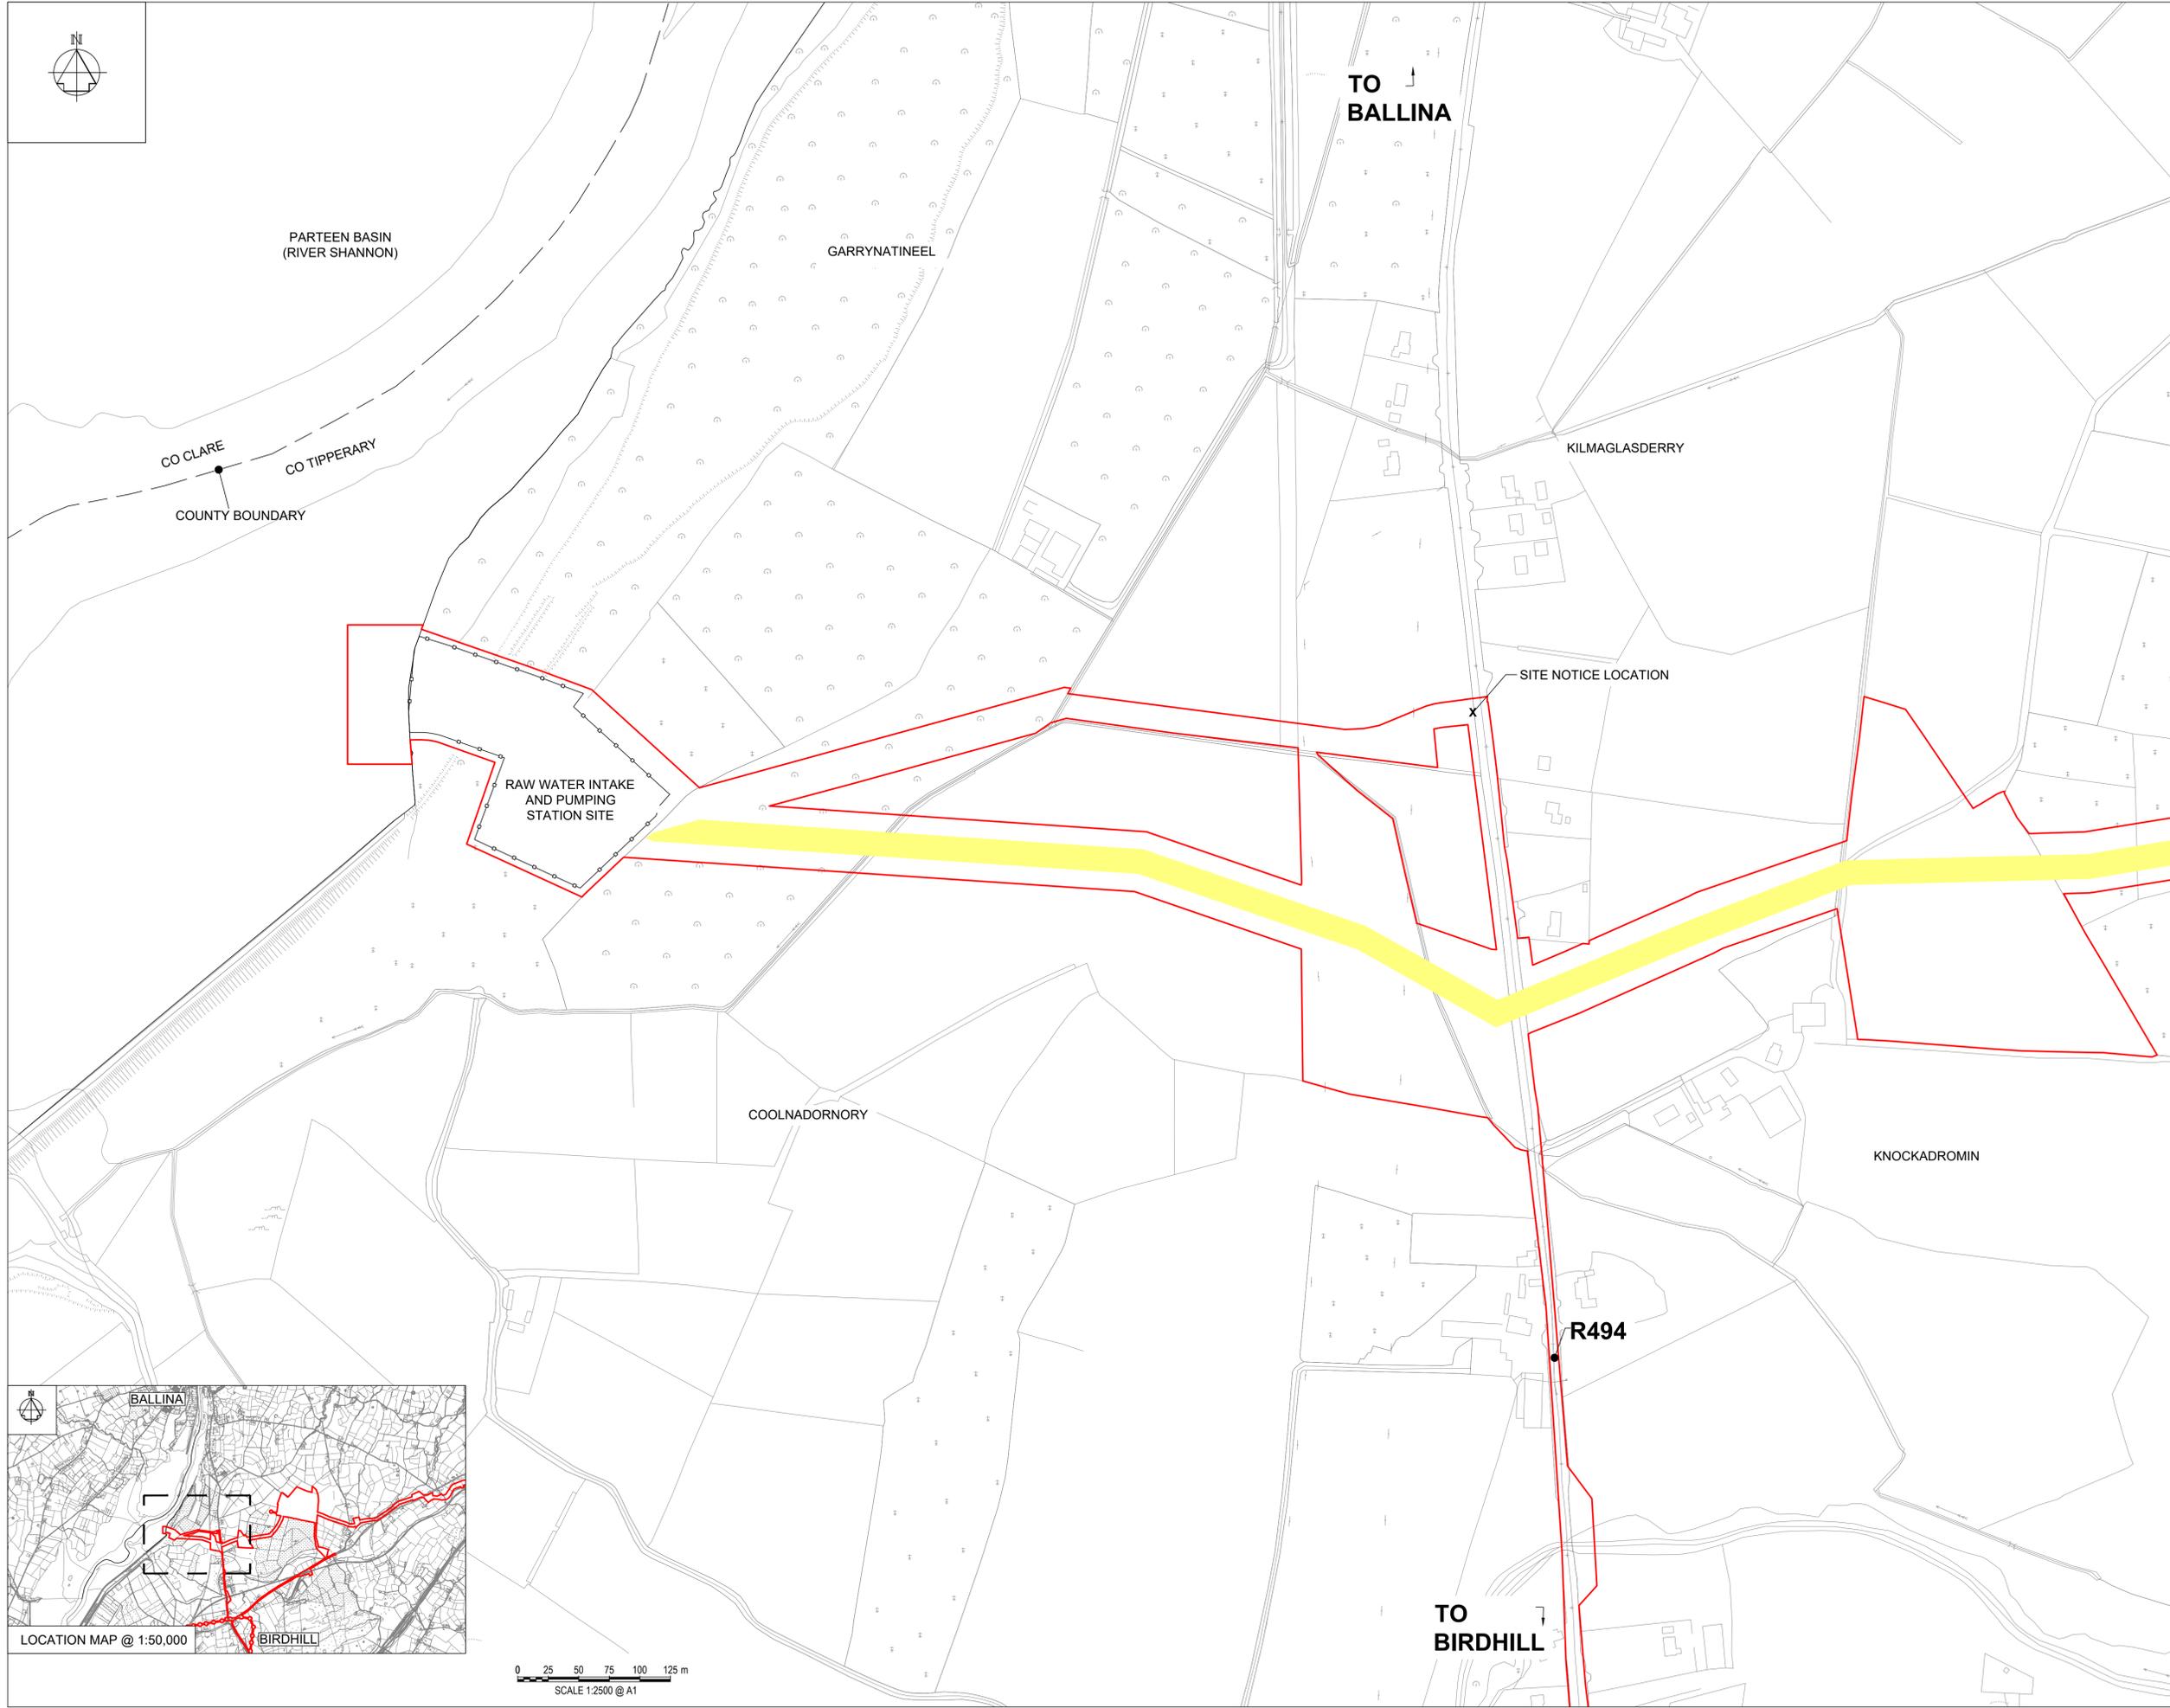




- Notes
1. ALL DIMENSIONS ARE IN METRES AND ALL LEVELS ARE IN METRES AOD MALIN HEAD UNLESS OTHERWISE STATED.
 2. THIS DRAWING IS FOR PLANNING PURPOSES ONLY.

OSI Sheet No(s):
4447-C, 4447-D

LEGEND

 PLANNING APPLICATION BOUNDARY

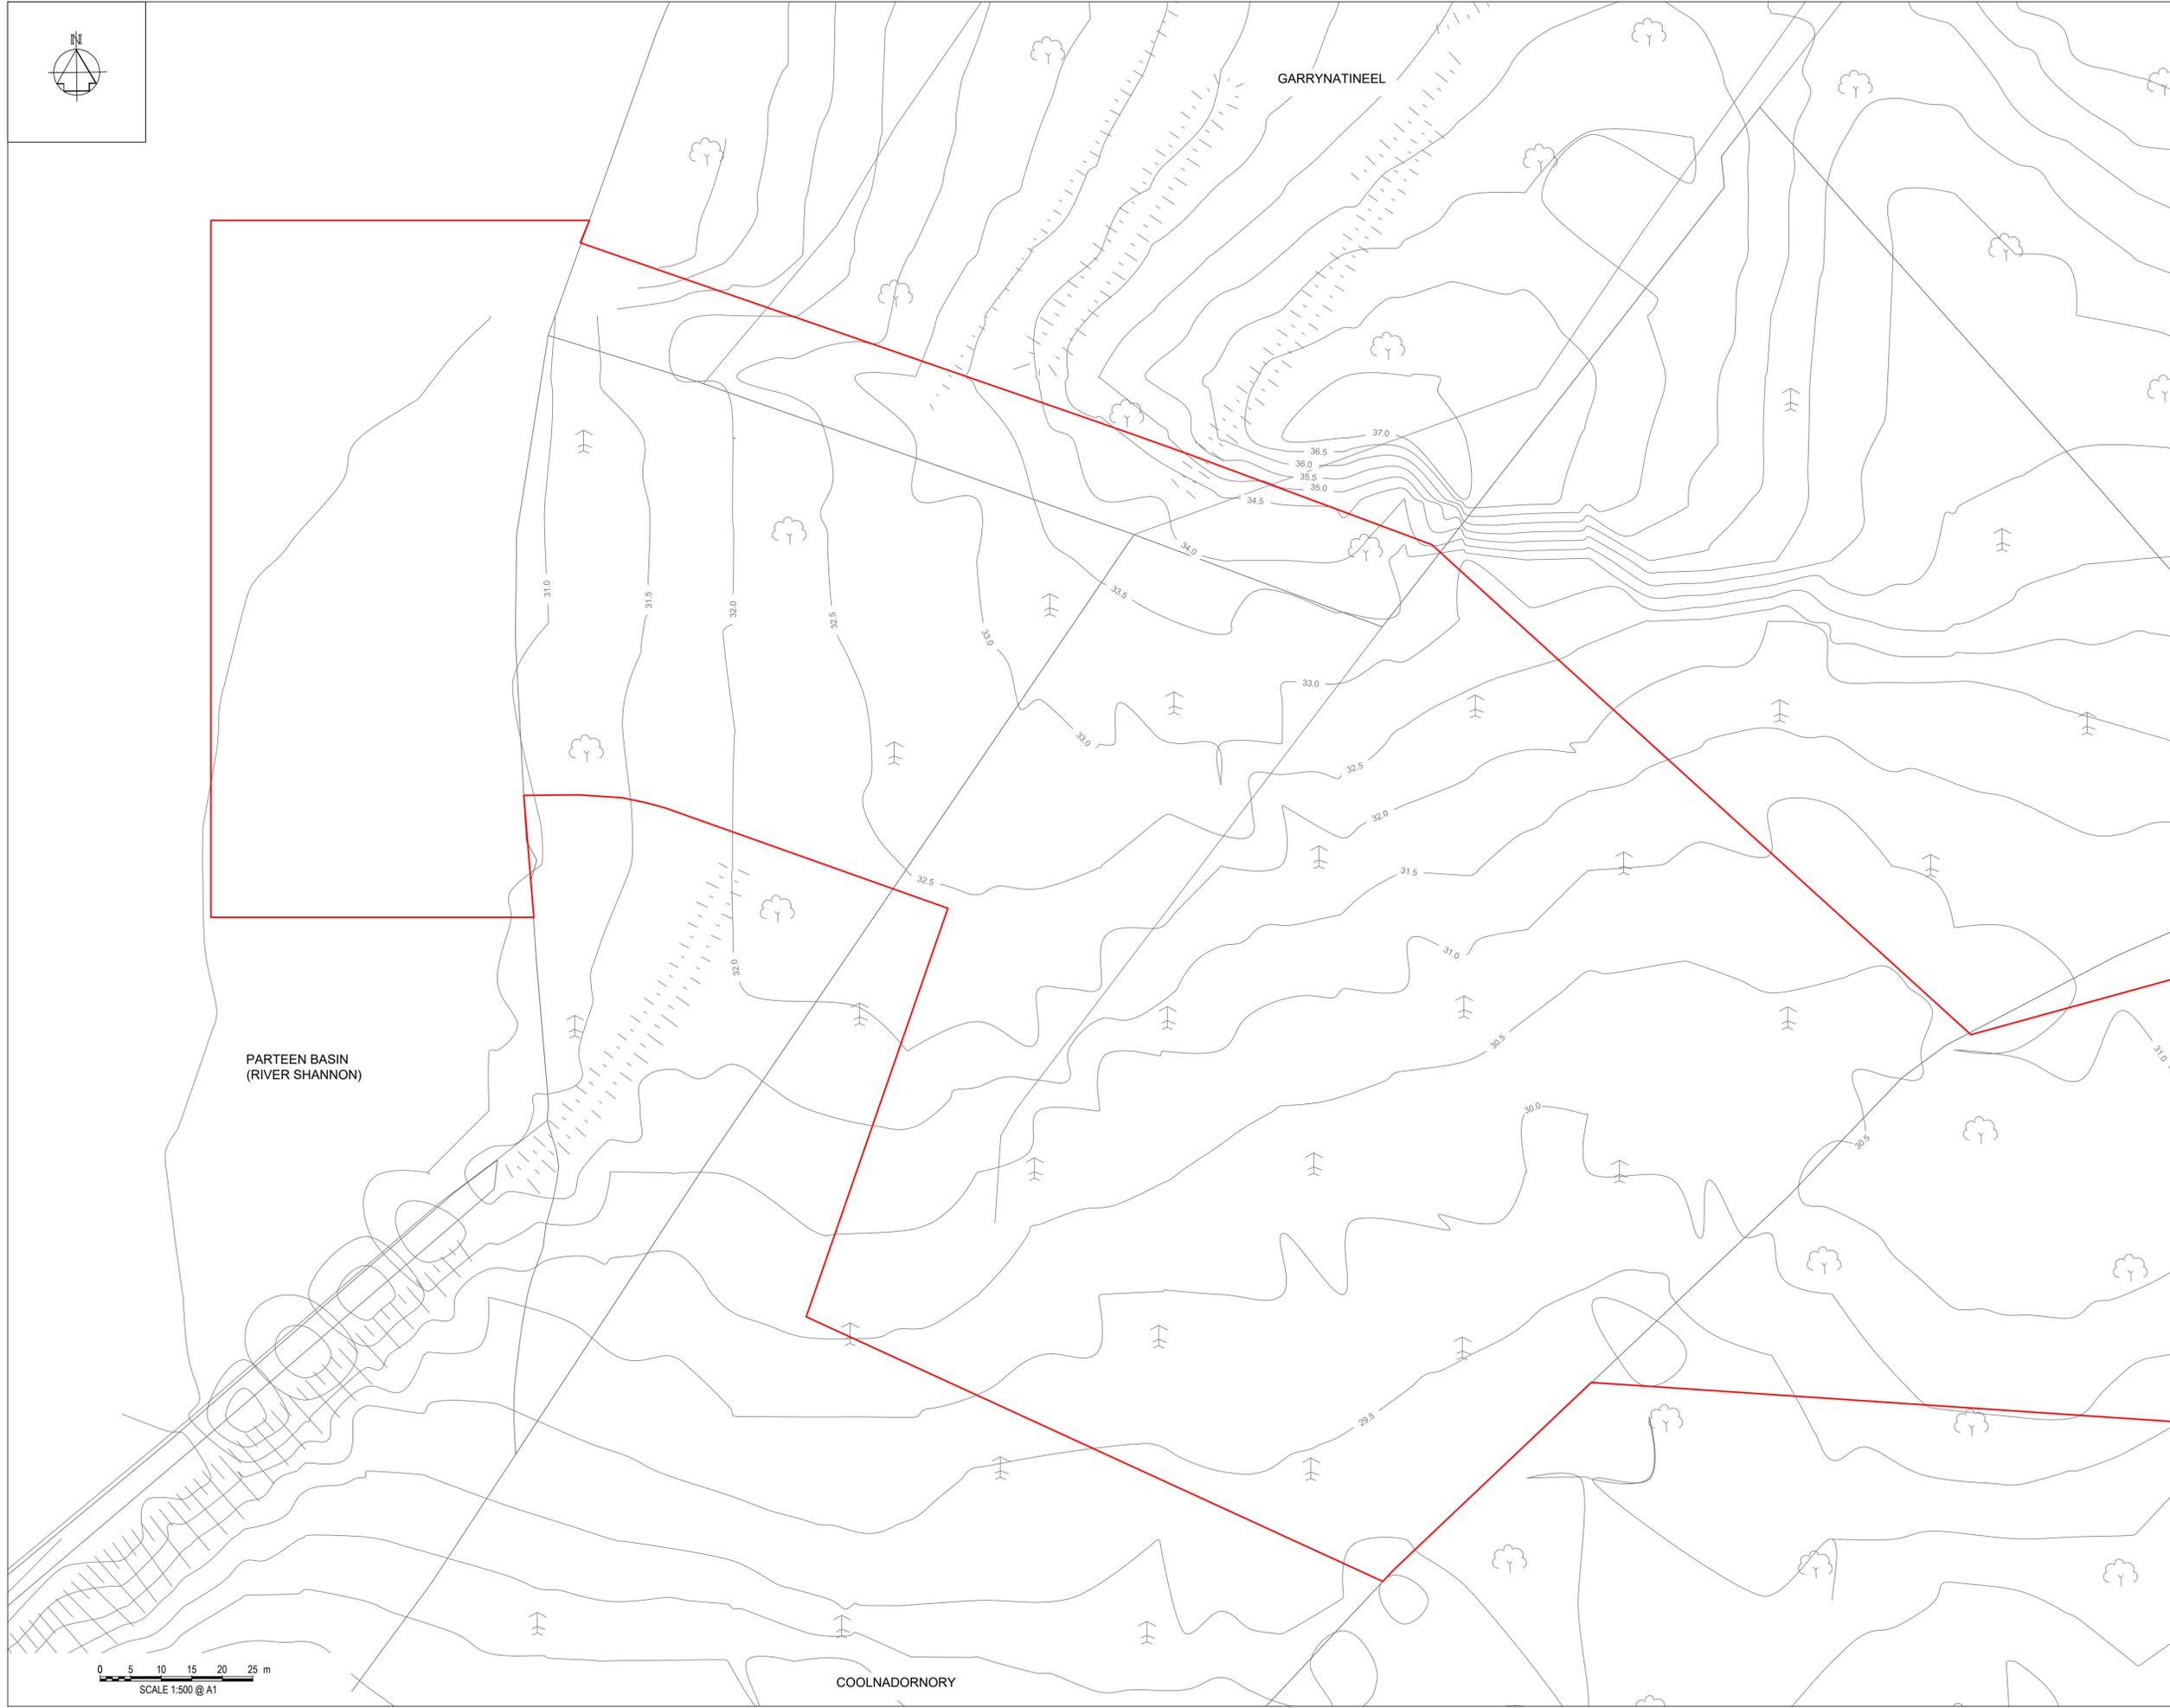

PARTEEN BASIN
(RIVER SHANNON)

GARRYNATINEEL

COOLNADORNORY



F01	FINAL FOR PLANNING	EM	BG	BG	DEC 25
A01	FOR PLANNING	JM	BG	BG	FEB 25
Rev	Description	Drawn	Chk'd	App'd	Date

This drawing is the property of Irish Water and must not be copied or used for any purpose other than that for which it is supplied without the written consent of Irish Water.

Uisce Éireann
Irish Water

UISCE ÉIREANN,
COLVILL HOUSE,
TALBOT STREET,
DUBLIN 1,
IRELAND

Tionscadal Soláthair Uisce
Water Supply Project

Call 1890 278 278
Int: 00 353 1 707 2828

Jacobs TOBIN

Originated By DC	Drawn By JM	Checked By BG	Approved By BG
Date 07.02.25	Date 01.12.25	Date 01.12.25	Date 01.12.25

Scale
1:500 @ A1

Project Title
WATER SUPPLY PROJECT
EASTERN AND MIDLANDS REGION

Drawing Title
RAW WATER INTAKE
AND PUMPING STATION

EXISTING SITE PLAN

Drawing Status: FINAL FOR PLANNING
Jacobs Tobin No. 32105801 | Client No. 9318

Drawing No.
32105801-850-01001



Notes:
1. ALL DIMENSIONS ARE IN METRES AND ALL LEVELS ARE IN METRES AOD MALIN HEAD UNLESS OTHERWISE STATED.
2. THIS DRAWING IS FOR PLANNING PURPOSES ONLY.

OSI Sheet No(s):
4447-C, 4447-D

- LEGEND**
-  PLANNING APPLICATION BOUNDARY
 -  1.2m HIGH POST AND RAIL FENCE
 -  2.4m HIGH PALADIN SITE SECURITY FENCE
 -  INDICATIVE PERMANENT WAYLEAVE
 -  BUILDING
 -  ROAD / PAVED SURFACE
 -  BELOW GROUND STRUCTURES /TANKS
 -  COUNTY BOUNDARY

F01	FINAL FOR PLANNING	EM	BG	BG	DEC 25
A01	FOR PLANNING	JM	BG	BG	FEB 25
Rev	Description	Drawn	Chk'd	App'd	Date

This drawing is the property of Irish Water and must not be copied or used for any purpose other than that for which it is supplied without the written consent of Irish Water.



UISCE ÉIREANN,
COLVILL HOUSE,
TALBOT STREET,
DUBLIN 1,
IRELAND



Call 1890 278 278
Int: 00 353 1 707 2828

JACOBS TOBIN


Originated By DC	Drawn By JM	Checked By BG	Approved By BG
Date 07.02.25	Date 01.12.25	Date 01.12.25	Date 01.12.25

Scale: 1:2500 @ A1 **DO NOT SCALE**

Project Title
**WATER SUPPLY PROJECT
EASTERN AND MIDLANDS REGION**

Drawing Title
**RAW WATER INTAKE AND
PUMPING STATION
PROPOSED SITE PLAN**

Drawing Status: FINAL FOR PLANNING
Drawing No. 32105801 Client No. 9318
Drawing No. **32105801-850-01002**

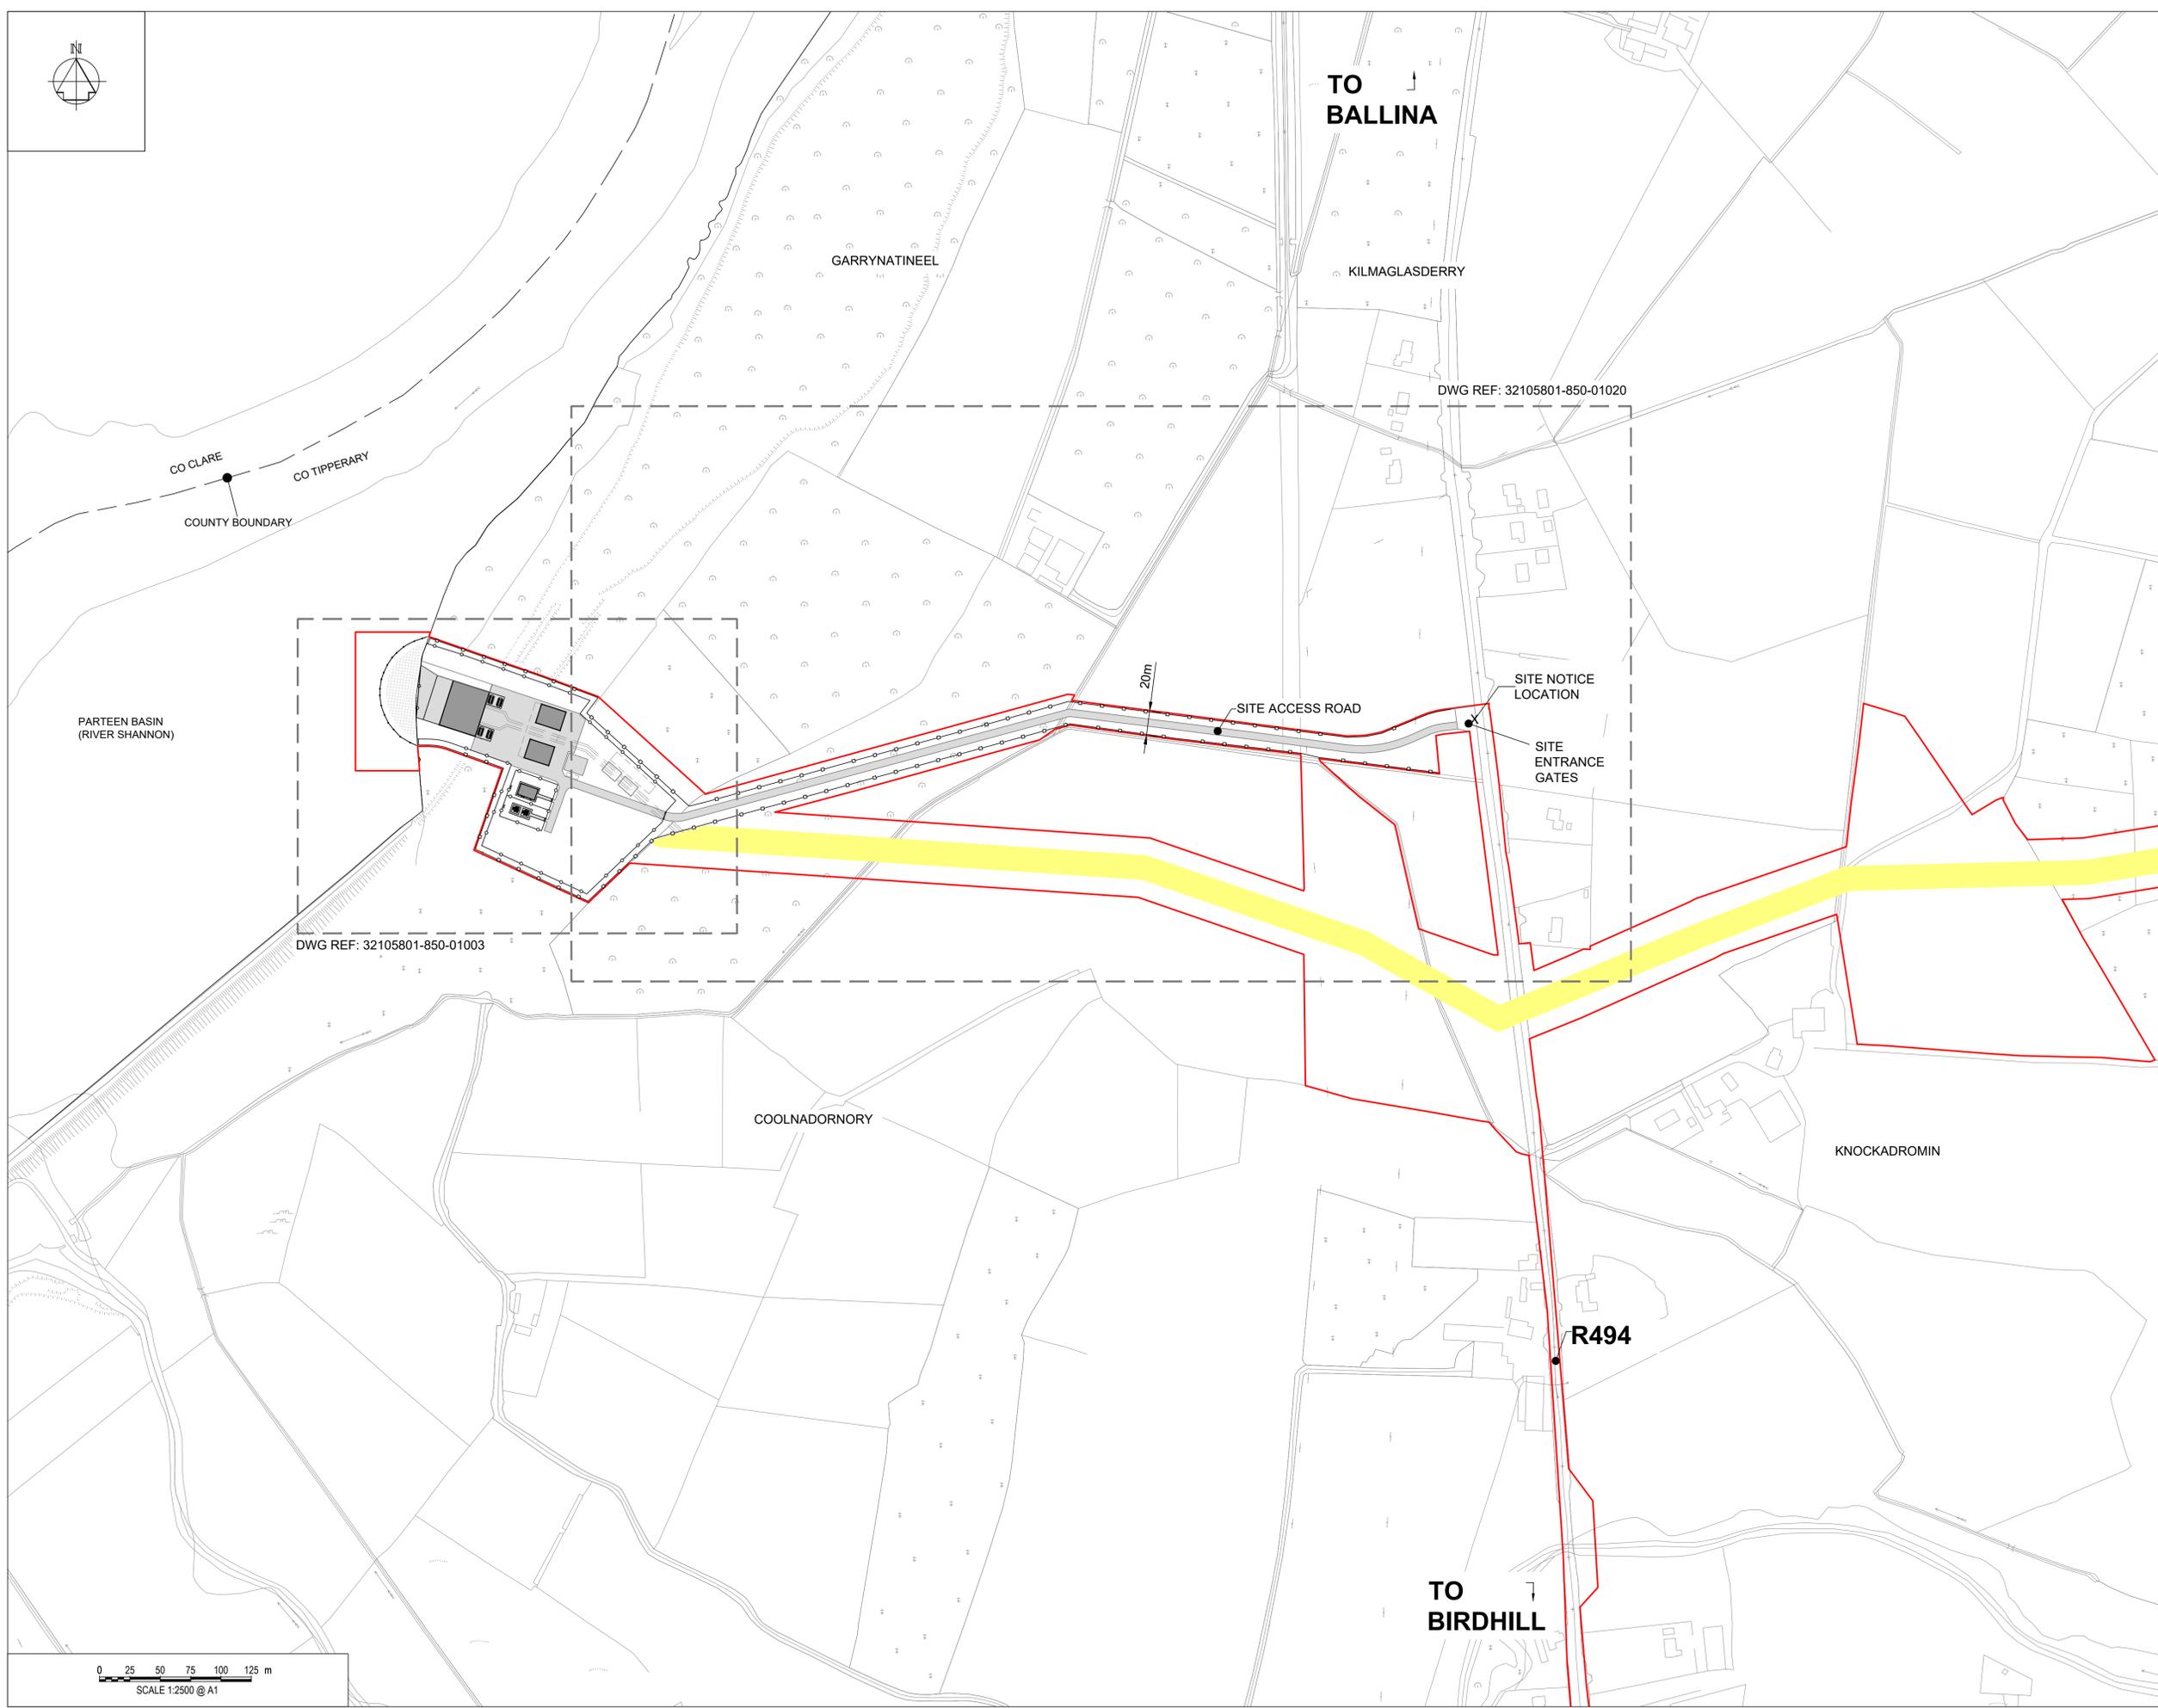

0 25 50 75 100 125 m
SCALE 1:2500 @ A1



GARRYNATINEEL

RETAINING WALL

REPROFILED BED OVERLAID WITH CONCRETE REVETMENT MATS (DWG 01012)







FLOATING BUOYS AND WARNING SIGNS

RETAINING WALL

1m WIDE OTTER RUN

EXISTING SHORE LINE
PARTEEN BASIN
(RIVER SHANNON)

FORT HENRY EMBANKMENT

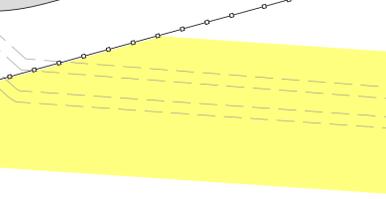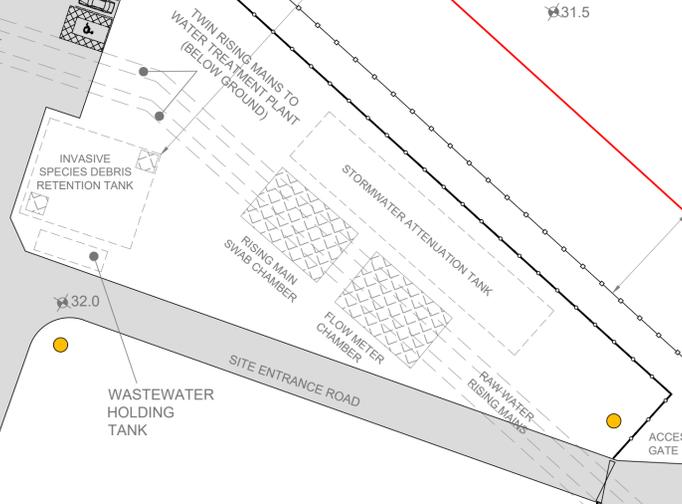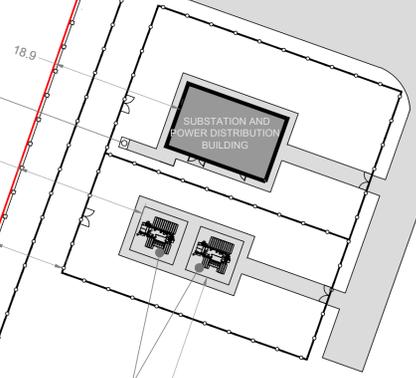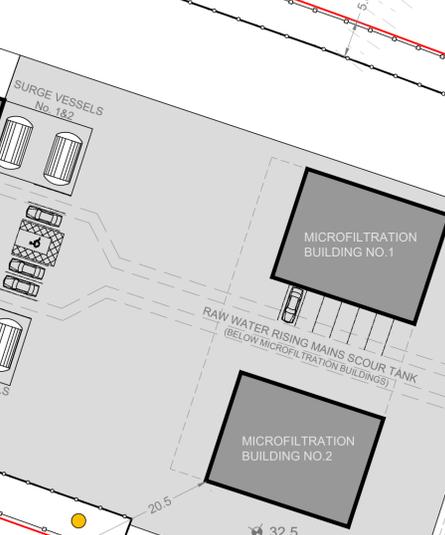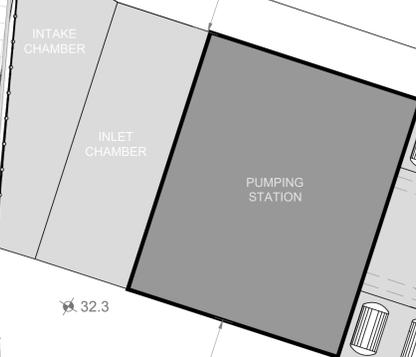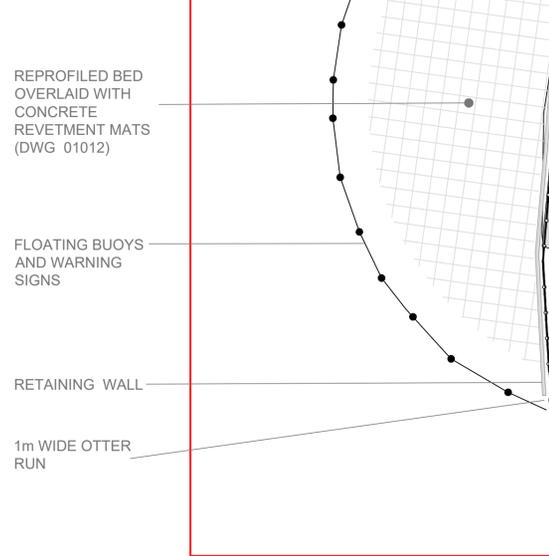

Notes:
1. ALL DIMENSIONS ARE IN METRES AND ALL LEVELS ARE IN METRES AOD **MALIN HEAD** UNLESS OTHERWISE STATED
2. THIS DRAWING IS FOR PLANNING PURPOSES ONLY.

OSI Sheet No(s):
4447-C,4447-D

LEGEND

- PLANNING APPLICATION BOUNDARY
- 1.2m HIGH POST AND RAIL FENCE
- 2.4m HIGH PALADIN SITE SECURITY FENCE
- INDICATIVE PERMANENT WAYLEAVE
- ROAD SURFACE
- BUILDINGS / ABOVE GROUND STRUCTURES
- ACCESS COVERS
- UNDERGROUND STRUCTURES
- REVETMENT MATS
- EV CHARGING POINT
- CCTV POLE

FO1	FINAL FOR PLANNING	EM	BG	BG	DEC' 25
A01	FOR PLANNING	JM	BG	BG	FEB' 25
Rev	Description	Drawn	Chk'd	App'd.	Date

This drawing is the property of Irish Water and must not be copied or used for any purpose other than that for which it is supplied without the written consent of Irish Water.



UISCE ÉIREANN
COLVILL HOUSE,
TALBOT STREET,
DUBLIN 1,
IRELAND



Call 1890 278 278
Int: 00 353 1 707 2828

JACOBS TOBIN

Originated By DC	Drawn By JM	Checked By BG	Approved By BG
Date 07.02.25	Date 01.12.25	Date 01.12.25	Date 01.12.25

Scale: 1:500 @ A1


Project Title
**WATER SUPPLY PROJECT
EASTERN AND MIDLANDS REGION**

Drawing Title
**RAW WATER INTAKE
AND PUMPING STATION
PROPOSED SITE LAYOUT PLAN**


Drawing Status: FINAL FOR PLANNING
Jacobs Tobin No. 32105801 Client No. 9318

Drawing No.
32105801-850-01003




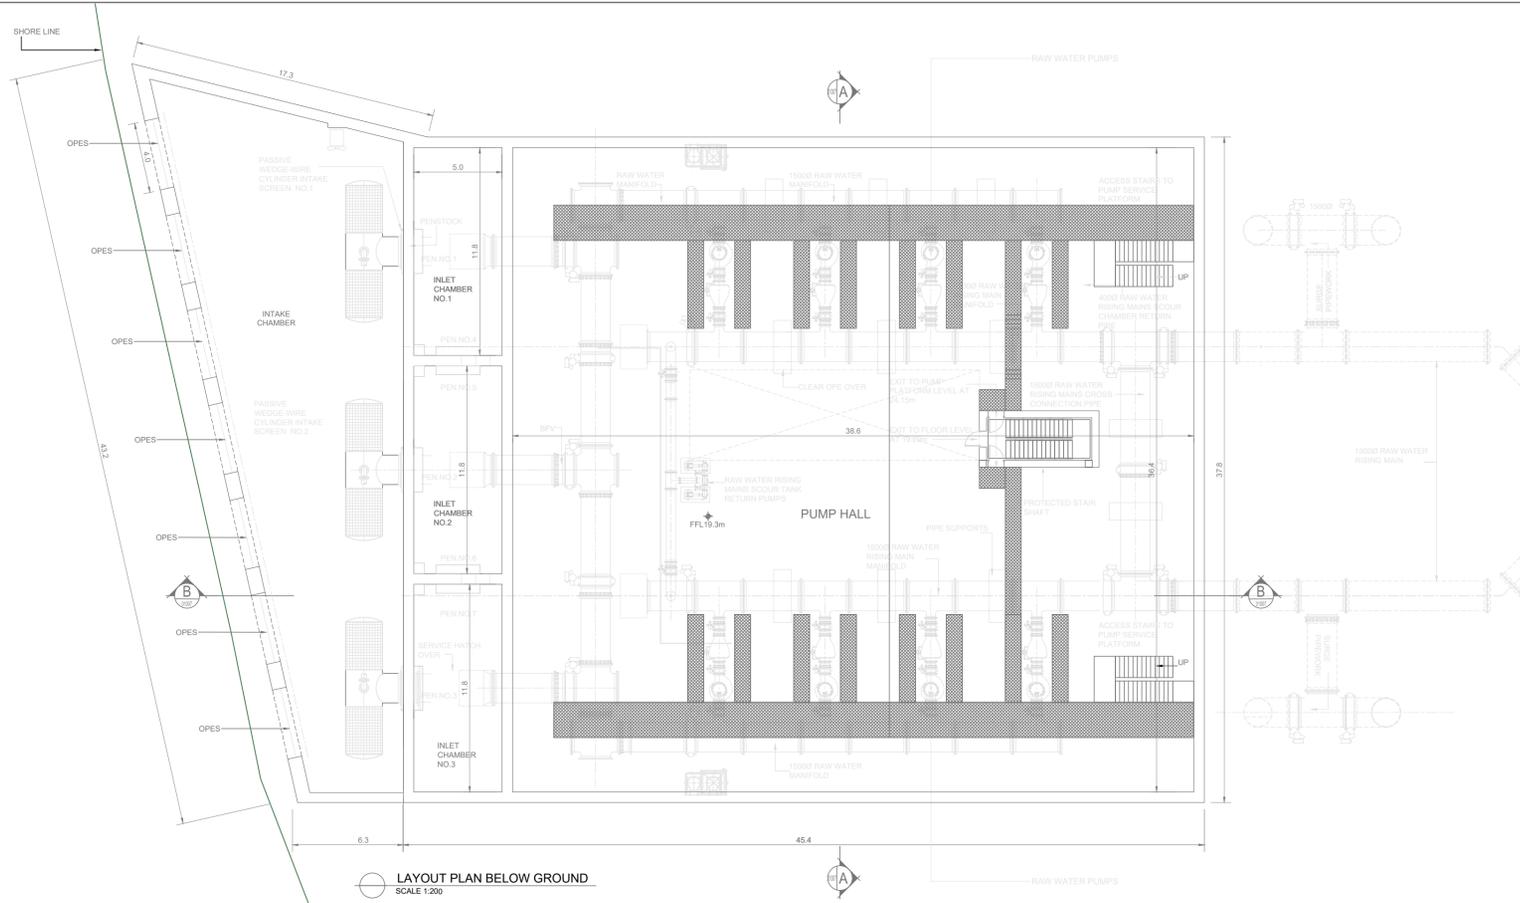

LAYOUT PLAN BELOW GROUND
SCALE 1:200

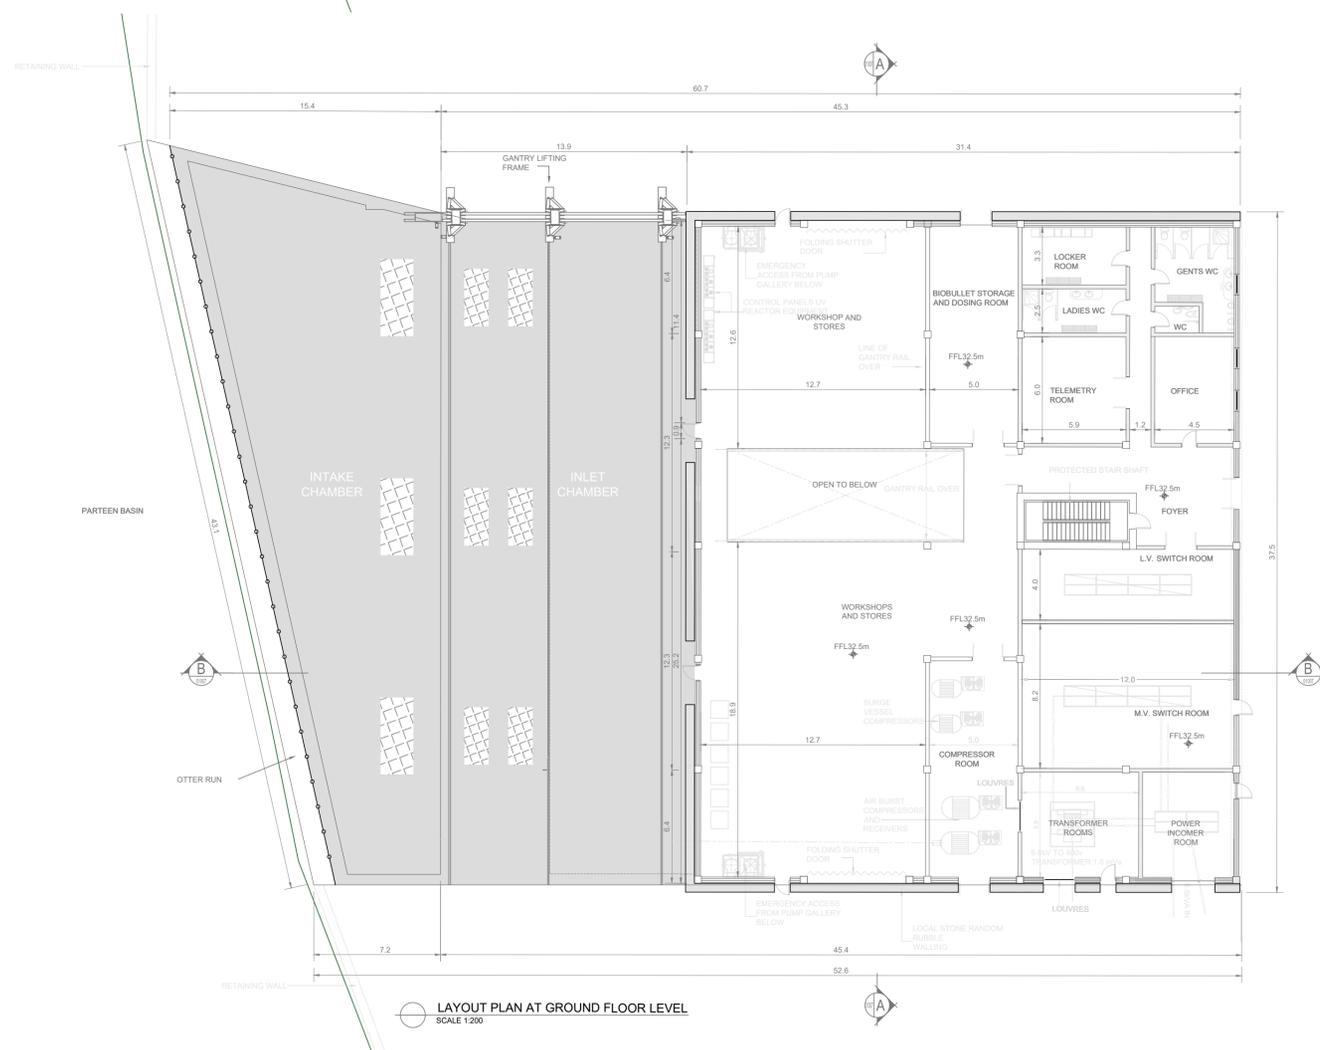

LAYOUT PLAN AT GROUND FLOOR LEVEL
SCALE 1:200

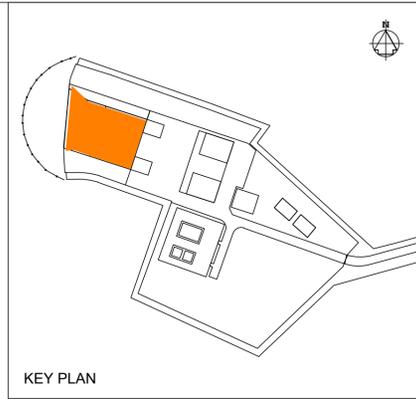

KEY PLAN

Notes:
1. ALL DIMENSIONS ARE IN METRES AND ALL LEVELS ARE IN METRES AOD MALIN HEAD UNLESS OTHERWISE STATED
2. THIS DRAWING IS FOR PLANNING PURPOSES ONLY.

- LEGEND
-  LOCATION OF DETAIL ON KEY PLAN
 -  ACCESS COVER
 -  WALKWAY / DECKING
 -  PAVED SURFACE
 -  2.4m HIGH PALADIN SITE SECURITY FENCE
 -  FFL FINISHED FLOOR LEVEL

F01	FINAL FOR PLANNING	EM	BG	BG	DEC 25
A01	FOR PLANNING	JM	BG	BG	FEB 25
Rev	Description	Drawn	Chk'd	App'd	Date

This drawing is the property of Irish Water and must not be copied or used for any purpose other than that for which it is supplied without the written consent of Irish Water.



Uisce Éireann
Irish Water

Tionscadal Soláthair Uisce
Water Supply Project

Uisce ÉIREANN
COLVILL HOUSE,
TALBOT STREET,
DUBLIN 1,
IRELAND

Call 1890 278 278
Int: 00 353 1 707 2828

Jacobs TOBIN

Originated By DC	Drawn By JM	Checked By BG	Approved By BG
Date 07.02.25	Date 01.12.25	Date 01.12.25	Date 01.12.25

Scale
1:200 @ A1

Project Title
WATER SUPPLY PROJECT
EASTERN AND MIDLANDS REGION

Drawing Title
RAW WATER INTAKE
AND PUMPING STATION
PUMPING STATION BUILDING FLOOR PLANS


Drawing Status
FINAL FOR PLANNING
Jacobs Tobin No. 32105801 Client No. 9318

Drawing No.
32105801-850-01004






- Notes:
- ALL DIMENSIONS ARE IN METRES AND ALL LEVELS ARE IN METRES AOD **MALIN HEAD** UNLESS OTHERWISE STATED
 - THIS DRAWING IS FOR PLANNING PURPOSES ONLY.

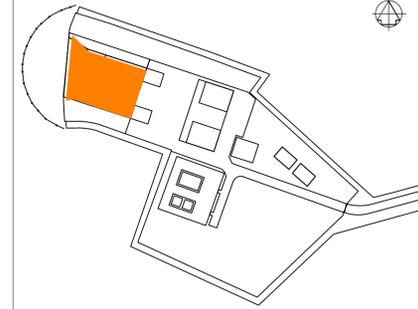

KEY PLAN

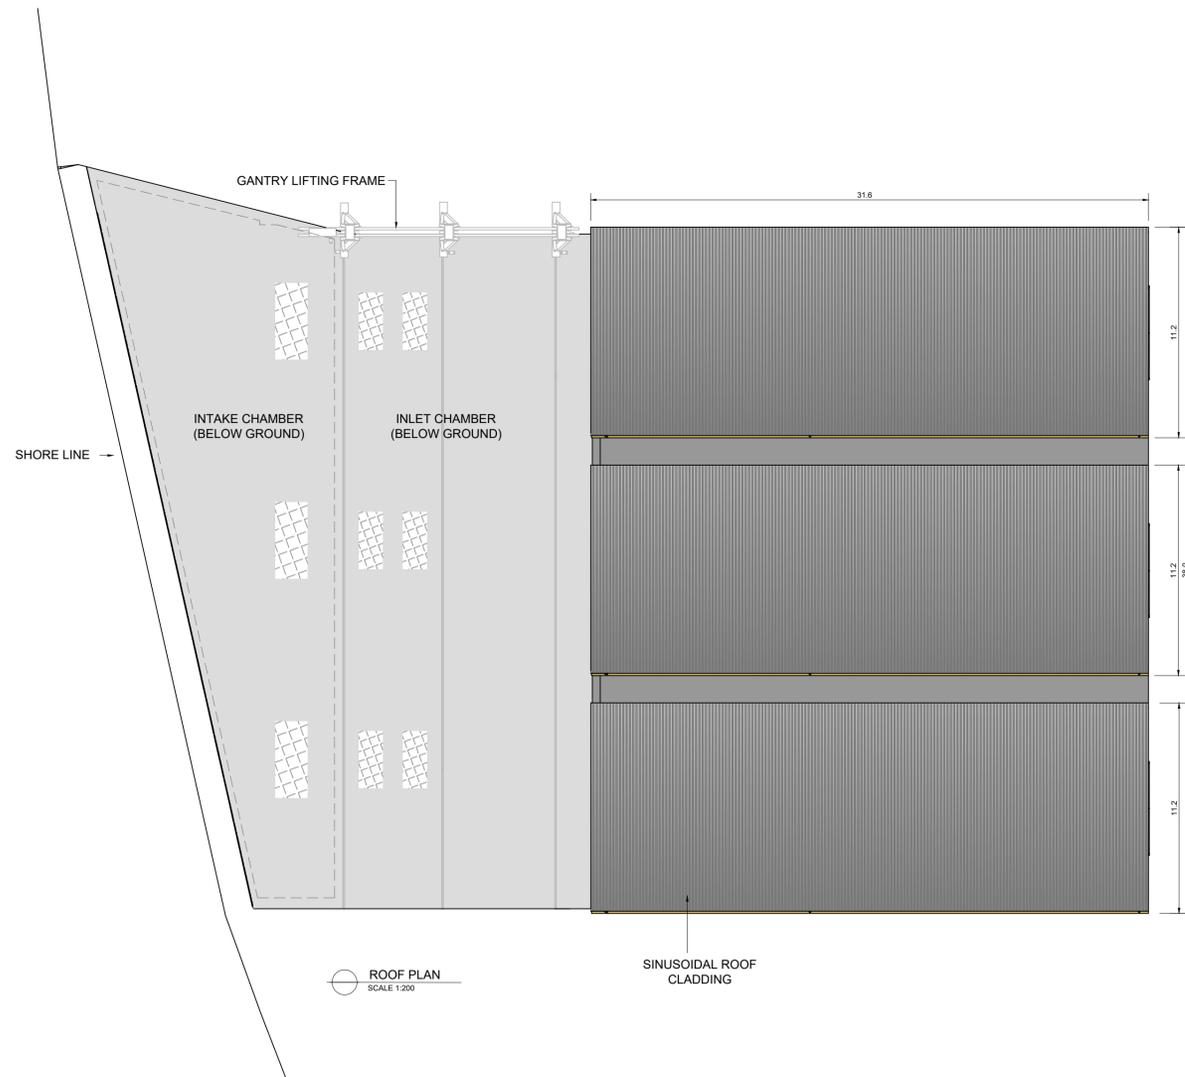

LEGEND

- LOCATION OF DETAIL ON KEY PLAN
- ACCESS COVER
- ROOF
- PAVED SURFACE

F01	FINAL FOR PLANNING	EM	BG	BG	DEC 25
A01	FOR PLANNING	JM	BG	BG	FEB 25
Rev	Description	Drawn	Chk'd	App'd	Date

This drawing is the property of Irish Water and must not be copied or used for any purpose other than that for which it is supplied without the written consent of Irish Water.

Uisce Éireann
Irish Water

UISCE ÉIREANN
COLVILL HOUSE,
TALBOT STREET,
DUBLIN 1,
IRELAND

Tionscadal Soláthair Uisce
Water Supply Project

Call 1890 278 278
Int: 00 353 1 707 2828

JACOBS TOBIN

Originated By DC	Drawn By JM	Checked By BG	Approved By BG
Date 07.02.25	Date 01.12.25	Date 01.12.25	Date 01.12.25

Scale
1:200 @ A1


Project Title
WATER SUPPLY PROJECT
EASTERN AND MIDLANDS REGION

Drawing Title
RAW WATER INTAKE
AND PUMPING STATION
PUMPING STATION BUILDING ROOF PLAN

Drawing Status
FINAL FOR PLANNING

Jacobs Tobin No. 32105801 Client No. 9318
Drawing No.
32105801-850-01005


- Notes:
- ALL DIMENSIONS ARE IN METRES AND ALL LEVELS ARE IN METRES AOD MALIN HEAD UNLESS OTHERWISE STATED
 - THIS DRAWING IS FOR PLANNING PURPOSES ONLY.

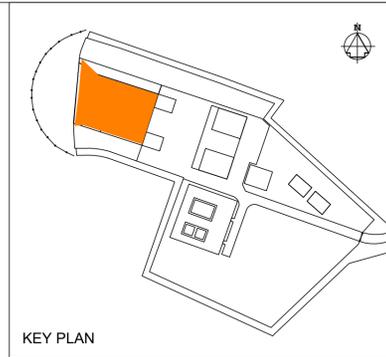


LEGEND

LOCATION OF DETAIL ON KEY PLAN


FGL FINISHED GROUND LEVEL

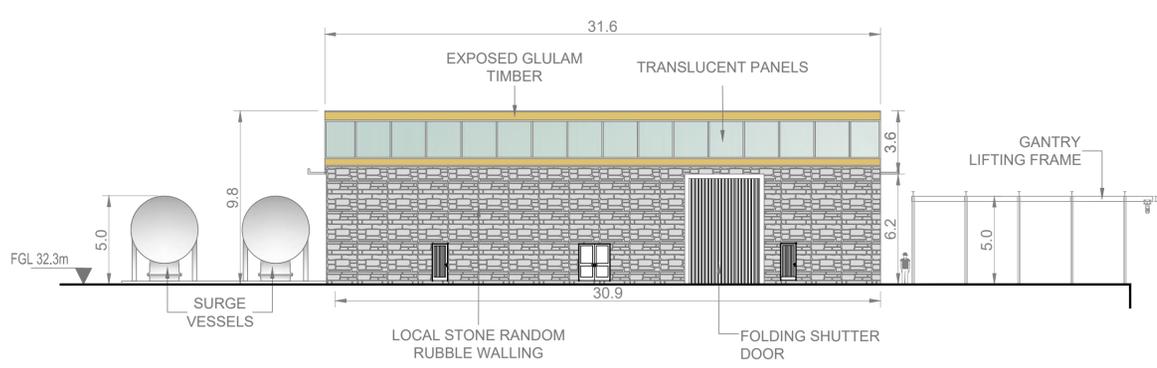


01004 NORTH ELEVATION
SCALE 1:200

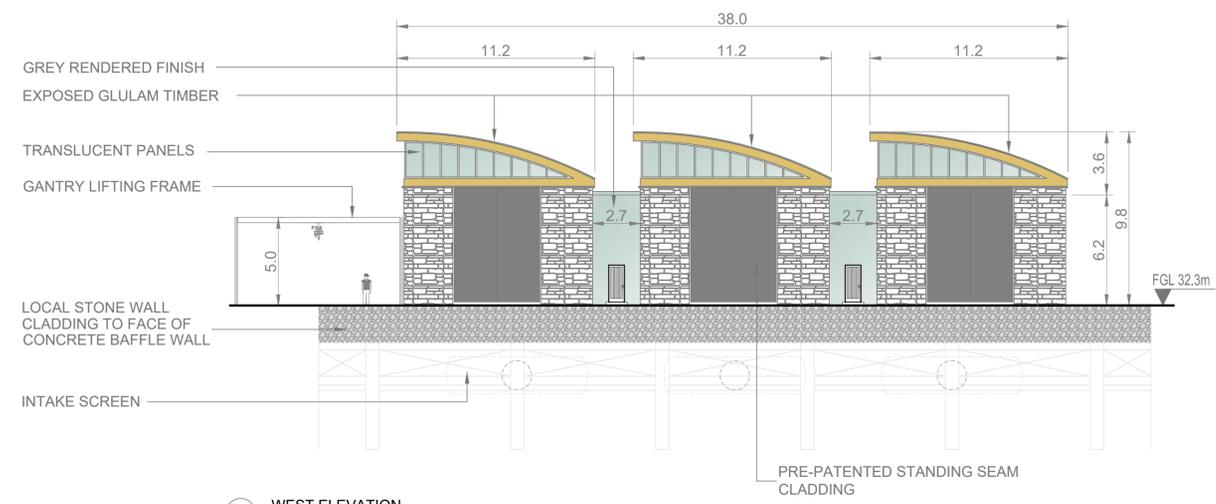

01004 WEST ELEVATION
SCALE 1:200

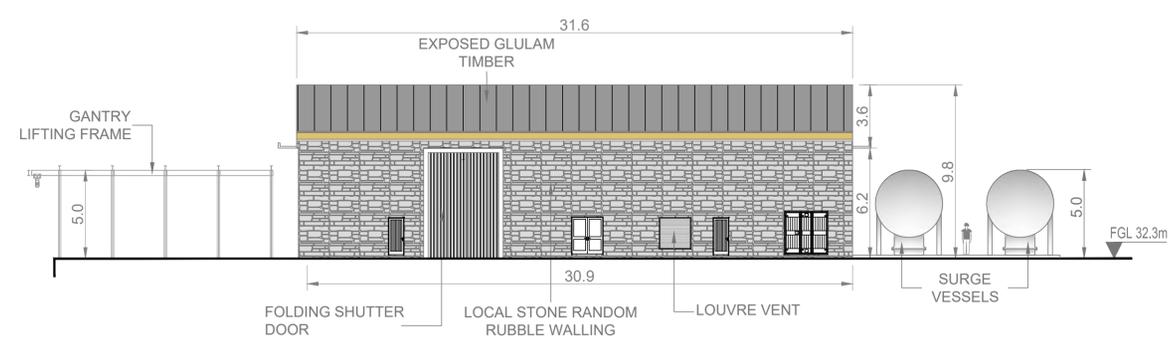

01004 SOUTH ELEVATION
SCALE 1:200

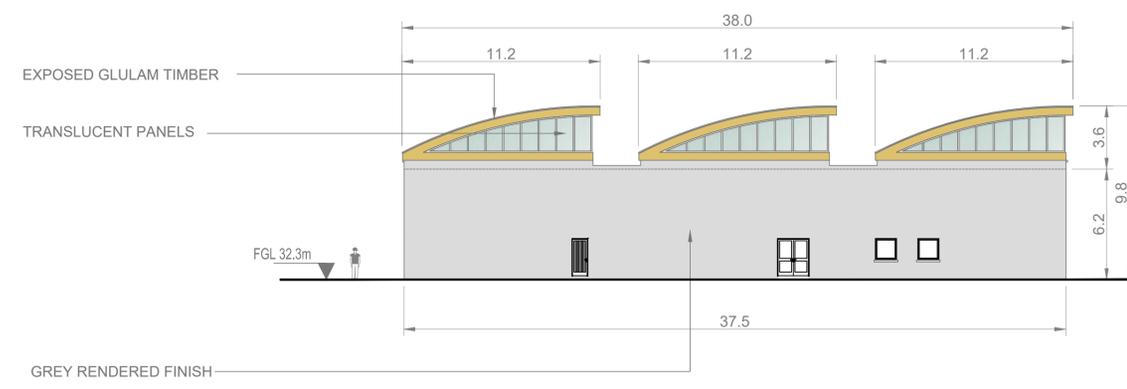

01004 EAST ELEVATION
SCALE 1:200



F01	FINAL FOR PLANNING	EM	BG	BG	DEC' 25
A01	FOR PLANNING	JM	BG	BG	FEB' 25
Rev	Description	Drawn	Chk'd	App'd	Date

This drawing is the property of Irish Water and must not be copied or used for any purpose other than that for which it is supplied without the written consent of Irish Water.

Uisce Éireann
Irish Water

Tionscadal Soláthair Uisce
Water Supply Project

UISCE ÉIREANN
COLVILL HOUSE,
TALBOT STREET,
DUBLIN 1,
IRELAND

Call 1890 278 278
Int: 00 353 1 707 2828

JACOBS TOBIN

Originated By DC	Drawn By JM	Checked By BG	Approved By BG
Date 07.02.25	Date 01.12.25	Date 01.12.25	Date 01.12.25

Scale
1:200 @ A1

Project Title
WATER SUPPLY PROJECT
EASTERN AND MIDLANDS REGION

Drawing Title
RAW WATER INTAKE
AND PUMPING STATION

PUMPING STATION BUILDING ELEVATIONS

Drawing Status: FINAL FOR PLANNING
Jacobs Tobin No. 32105801 Client No. 9318




Drawing No.
32105801-850-01006

Notes:
 1. ALL DIMENSIONS ARE IN METRES AND ALL LEVELS ARE IN METRES AOD MALIN HEAD UNLESS OTHERWISE STATED
 2. THIS DRAWING IS FOR PLANNING PURPOSES ONLY.

LEGEND

 LOCATION OF DETAIL ON KEY PLAN

FGL FINISHED GROUND LEVEL
 FFL FINISHED FLOOR LEVEL
 IL INVERT LEVEL
 LWL LOW WATER LEVEL

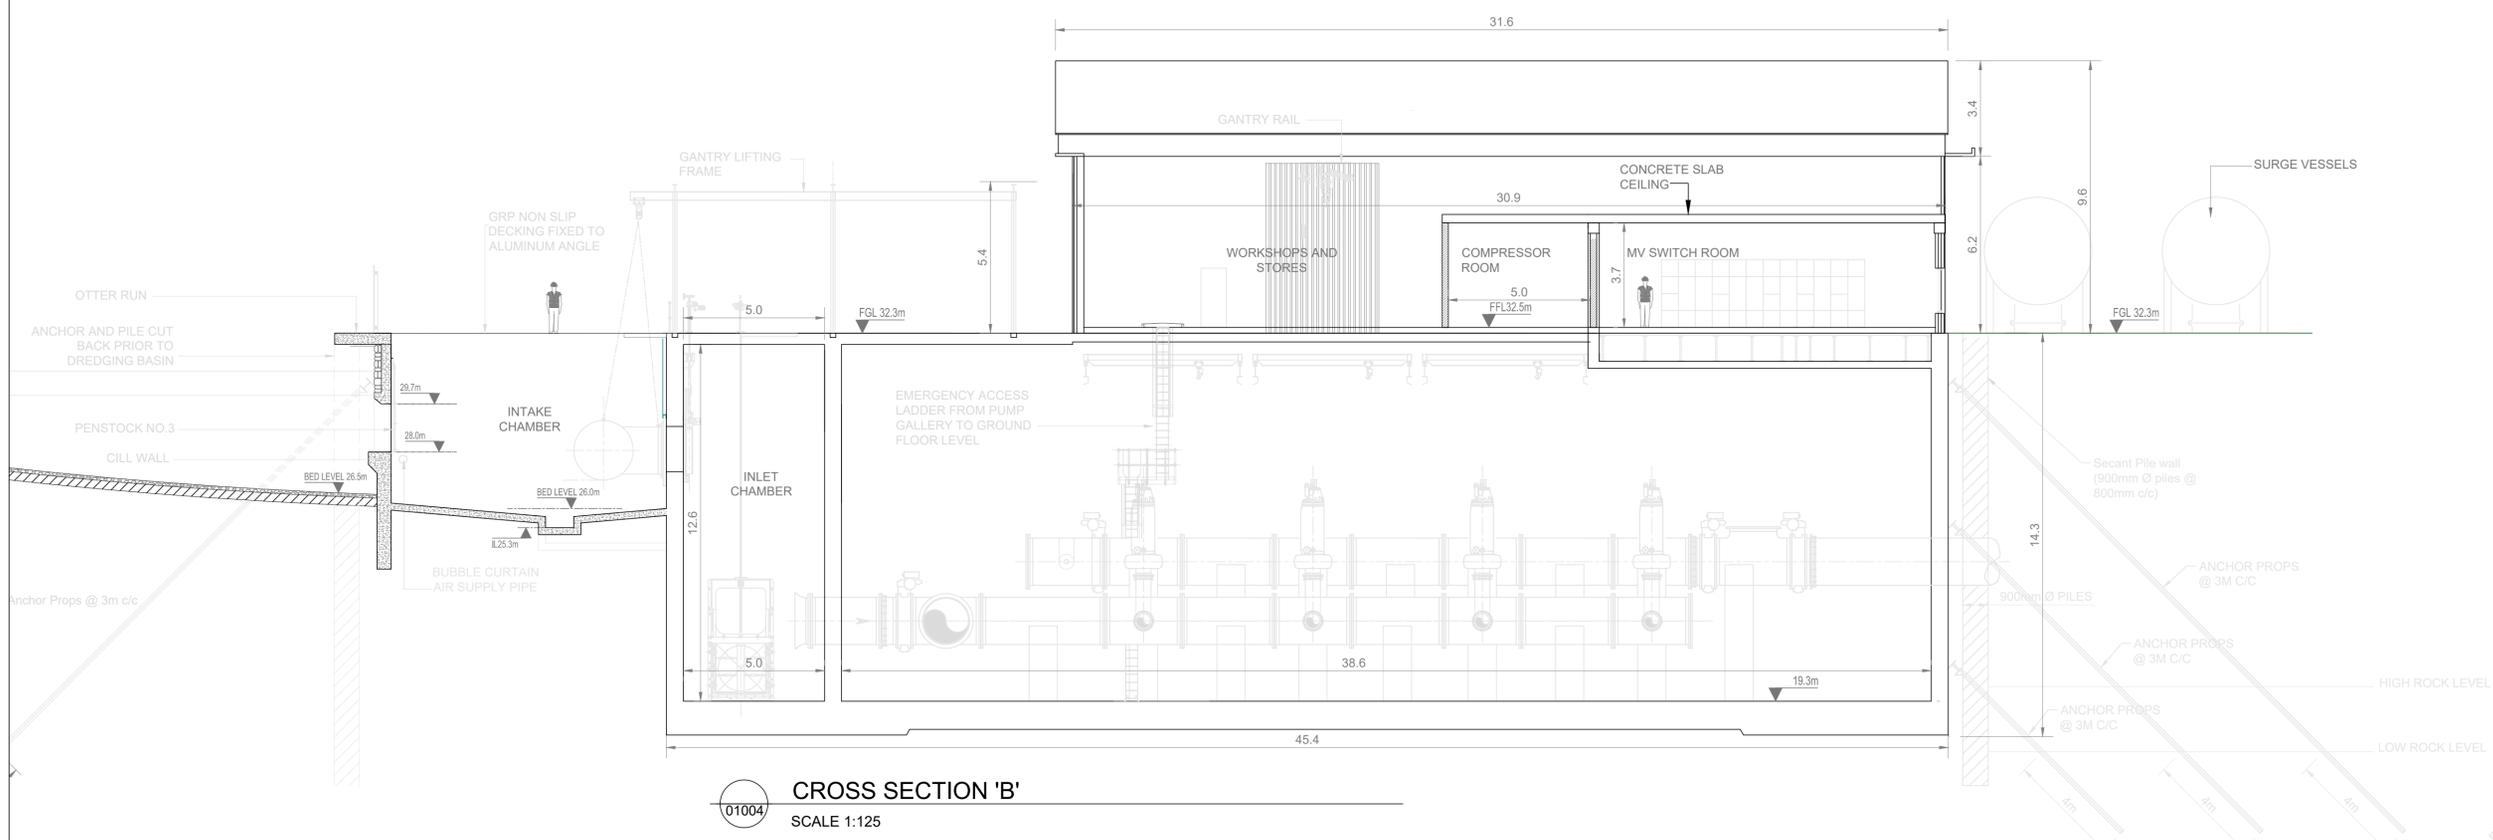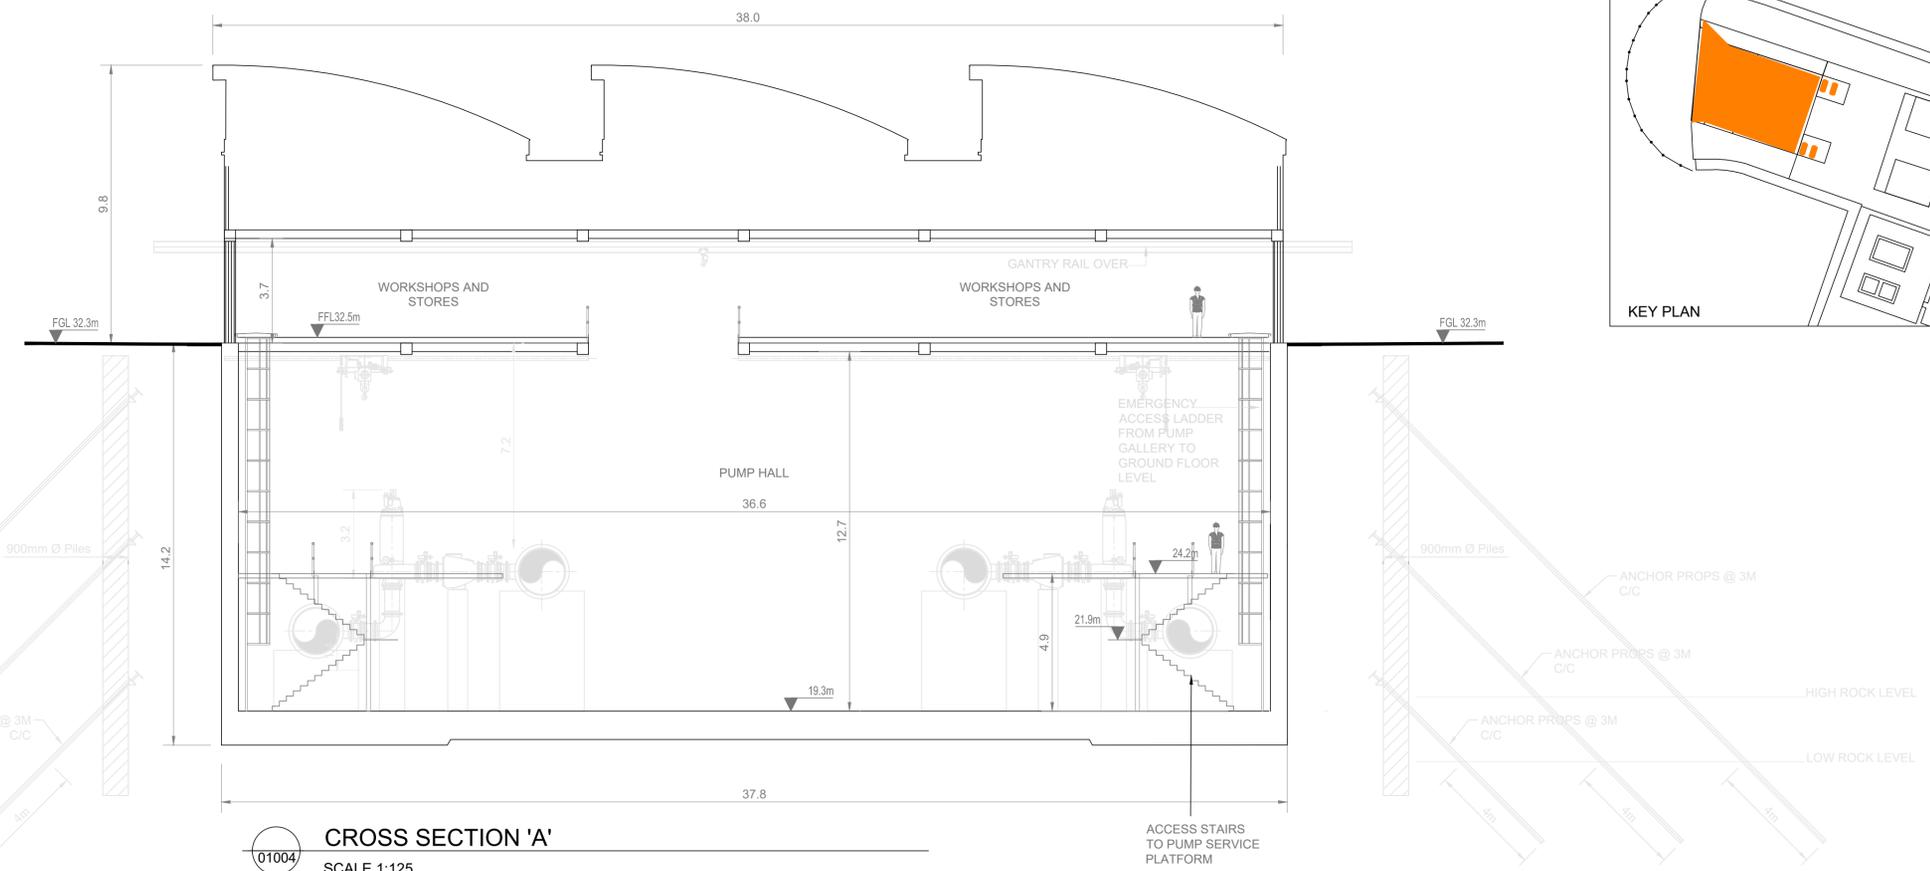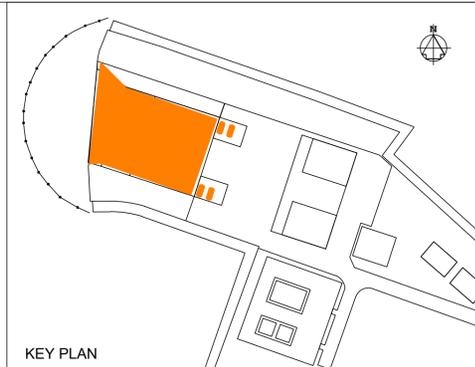

F01	FINAL FOR PLANNING	EM	BG	BG	DEC 25
A01	FOR PLANNING	JM	BG	BG	FEB 25
Rev	Description	Drawn	Chk'd	App'd	Date

This drawing is the property of Irish Water and must not be copied or used for any purpose other than that for which it is supplied without the written consent of Irish Water.

Uisce Éireann
 Irish Water

Tionscadal Soláthair Uisce
 Water Supply Project

UISCE ÉIREANN
 COLVILL HOUSE,
 TALBOT STREET,
 DUBLIN 1,
 IRELAND

Call 1890 278 278
 Int: 00 353 1 707 2828

JACOBS TOBIN

Originated By DC	Drawn By JM	Checked By BG	Approved By BG
Date 07.02.25	Date 01.12.25	Date 01.12.25	Date 01.12.25

Scale
 1:125 @ A1

Project Title
 WATER SUPPLY PROJECT
 EASTERN AND MIDLANDS REGION

Drawing Title
 RAW WATER INTAKE
 AND PUMPING STATION

CROSS SECTIONS

Drawing Status
 FINAL FOR PLANNING

Jacobs Tobin No. 32105801 Client No. 9318

Drawing No.
 32105801-850-01007







- Notes:
- ALL DIMENSIONS ARE IN METRES AND ALL LEVELS ARE IN METRES AOD **MALIN HEAD** UNLESS OTHERWISE STATED
 - THIS DRAWING IS FOR PLANNING PURPOSES ONLY.

KEY PLAN

- LEGEND
-  LOCATION OF DETAIL ON KEY PLAN
 - FFL FINISHED FLOOR LEVEL

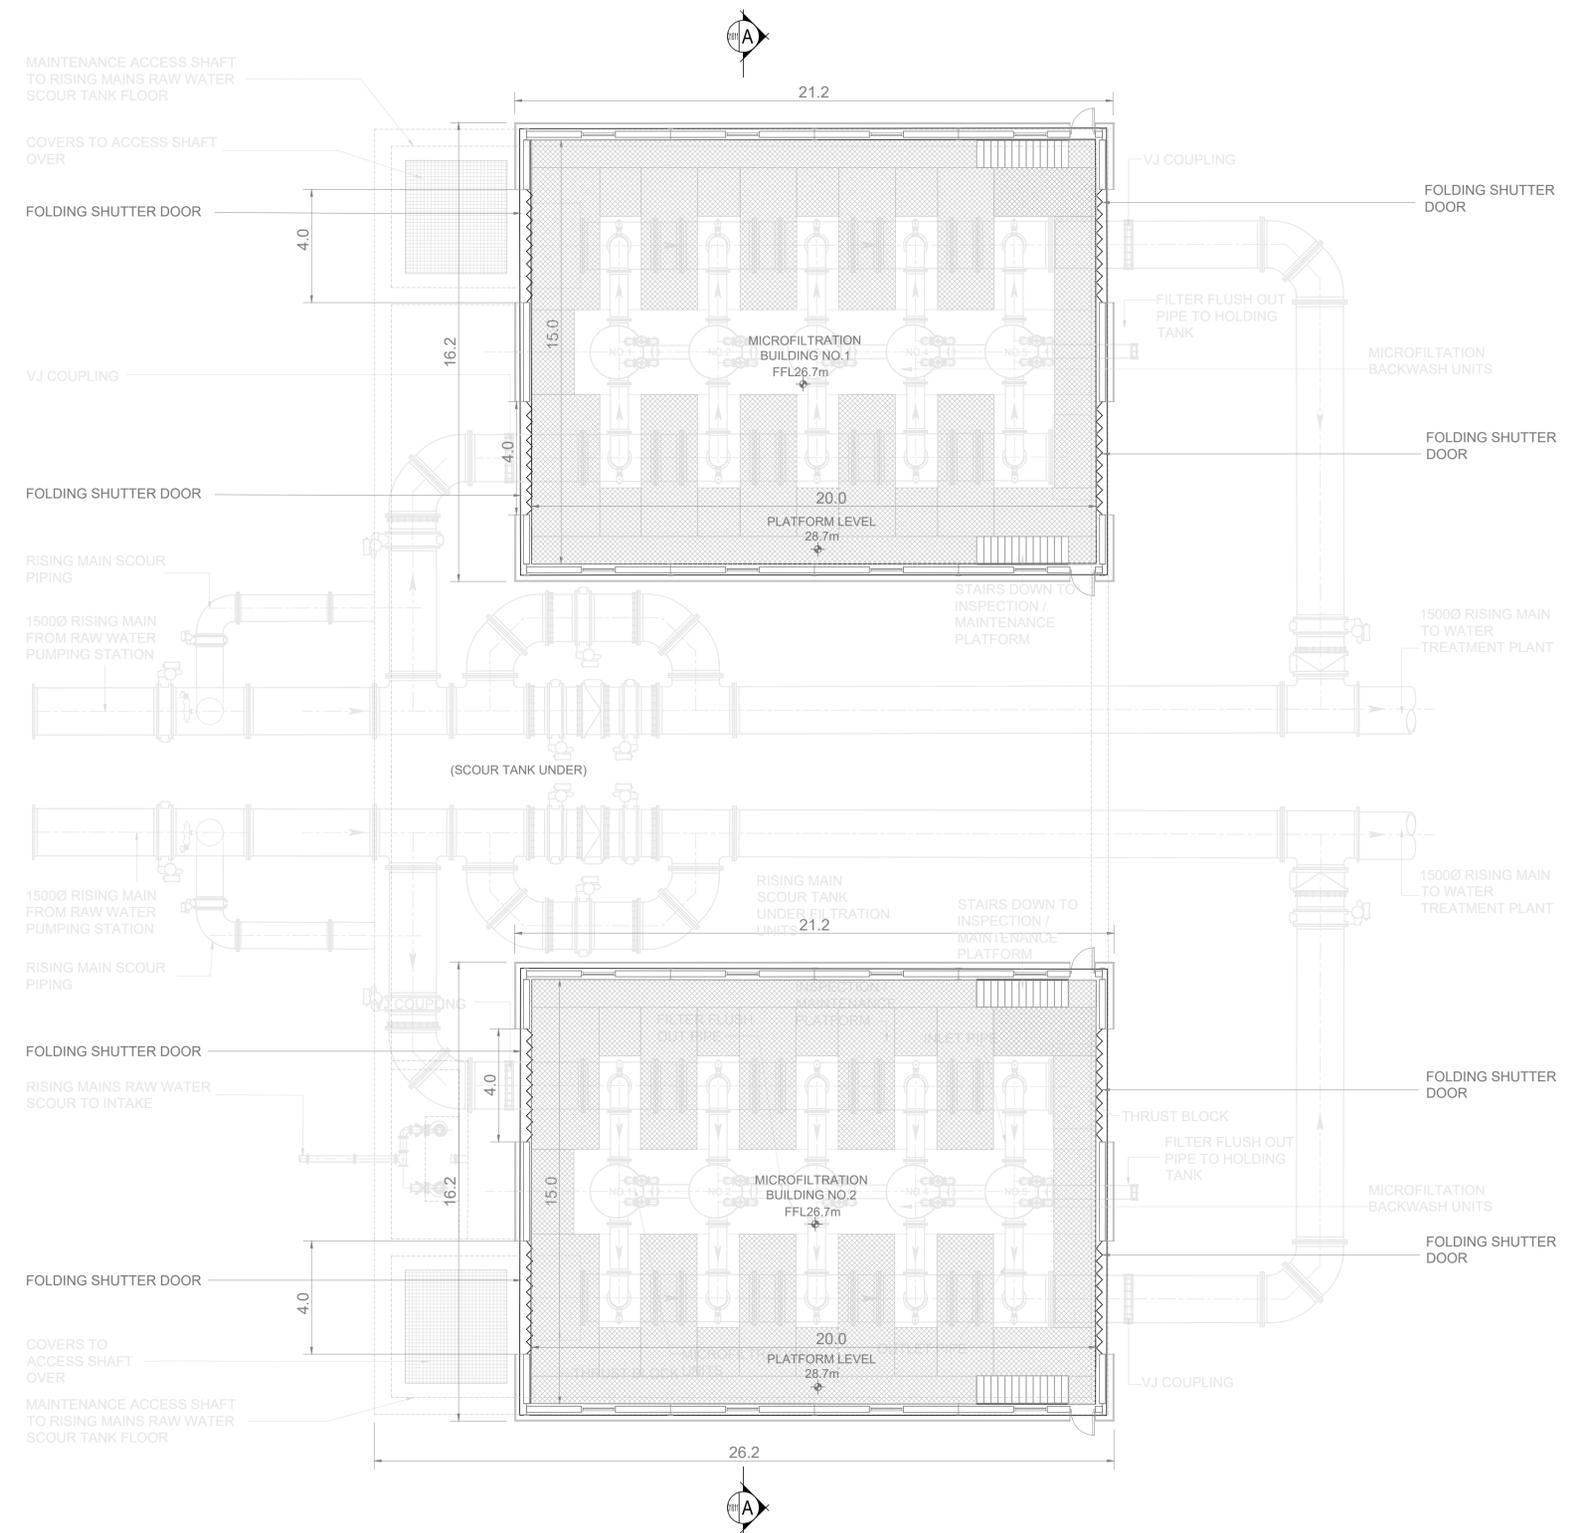

 **GROUND FLOOR PLAN**
SCALE 1:125

 

F01	FINAL FOR PLANNING	EM	BG	BG	DEC 25
A01	FOR PLANNING	JM	BG	BG	FEB 25
Rev	Description	Drawn	Chk'd	App'd	Date

This drawing is the property of Irish Water and must not be copied or used for any purpose other than that for which it is supplied without the written consent of Irish Water.

Uisce Éireann
Irish Water

Tionscald Soláthair Uisce
Water Supply Project

Uisce ÉIREANN
COLVILL HOUSE,
TALBOT STREET,
DUBLIN 1,
IRELAND

Call 1890 278 278
Int: 00 353 1 707 2828

Jacobs TOBIN

Originated By	Drawn By	Checked By	Approved By
DC	JM	BG	BG
Date	Date	Date	Date
07.02.25	01.12.25	01.12.25	01.12.25


Scale
1:125 @ A1

Project Title
WATER SUPPLY PROJECT
EASTERN AND MIDLANDS REGION

Drawing Title
RAW WATER INTAKE AND
PUMPING STATION
MICROFILTRATION BUILDING GROUND FLOOR PLAN

Drawing Status: FINAL FOR PLANNING
Jacobs Tobin No. 32105801 Client No. 9318

Drawing No.
32105801-850-01008

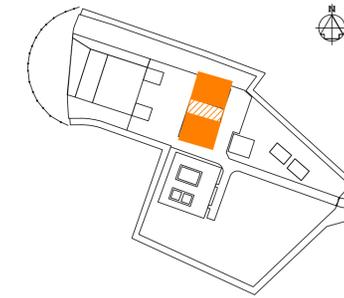


KEY PLAN

Notes:

1. ALL DIMENSIONS ARE IN METRES AND ALL LEVELS ARE IN METRES AOD **MALIN HEAD** UNLESS OTHERWISE STATED
2. THIS DRAWING IS FOR PLANNING PURPOSES ONLY.

LEGEND

-  LOCATION OF DETAIL ON KEY PLAN
-  PAVED SURFACE

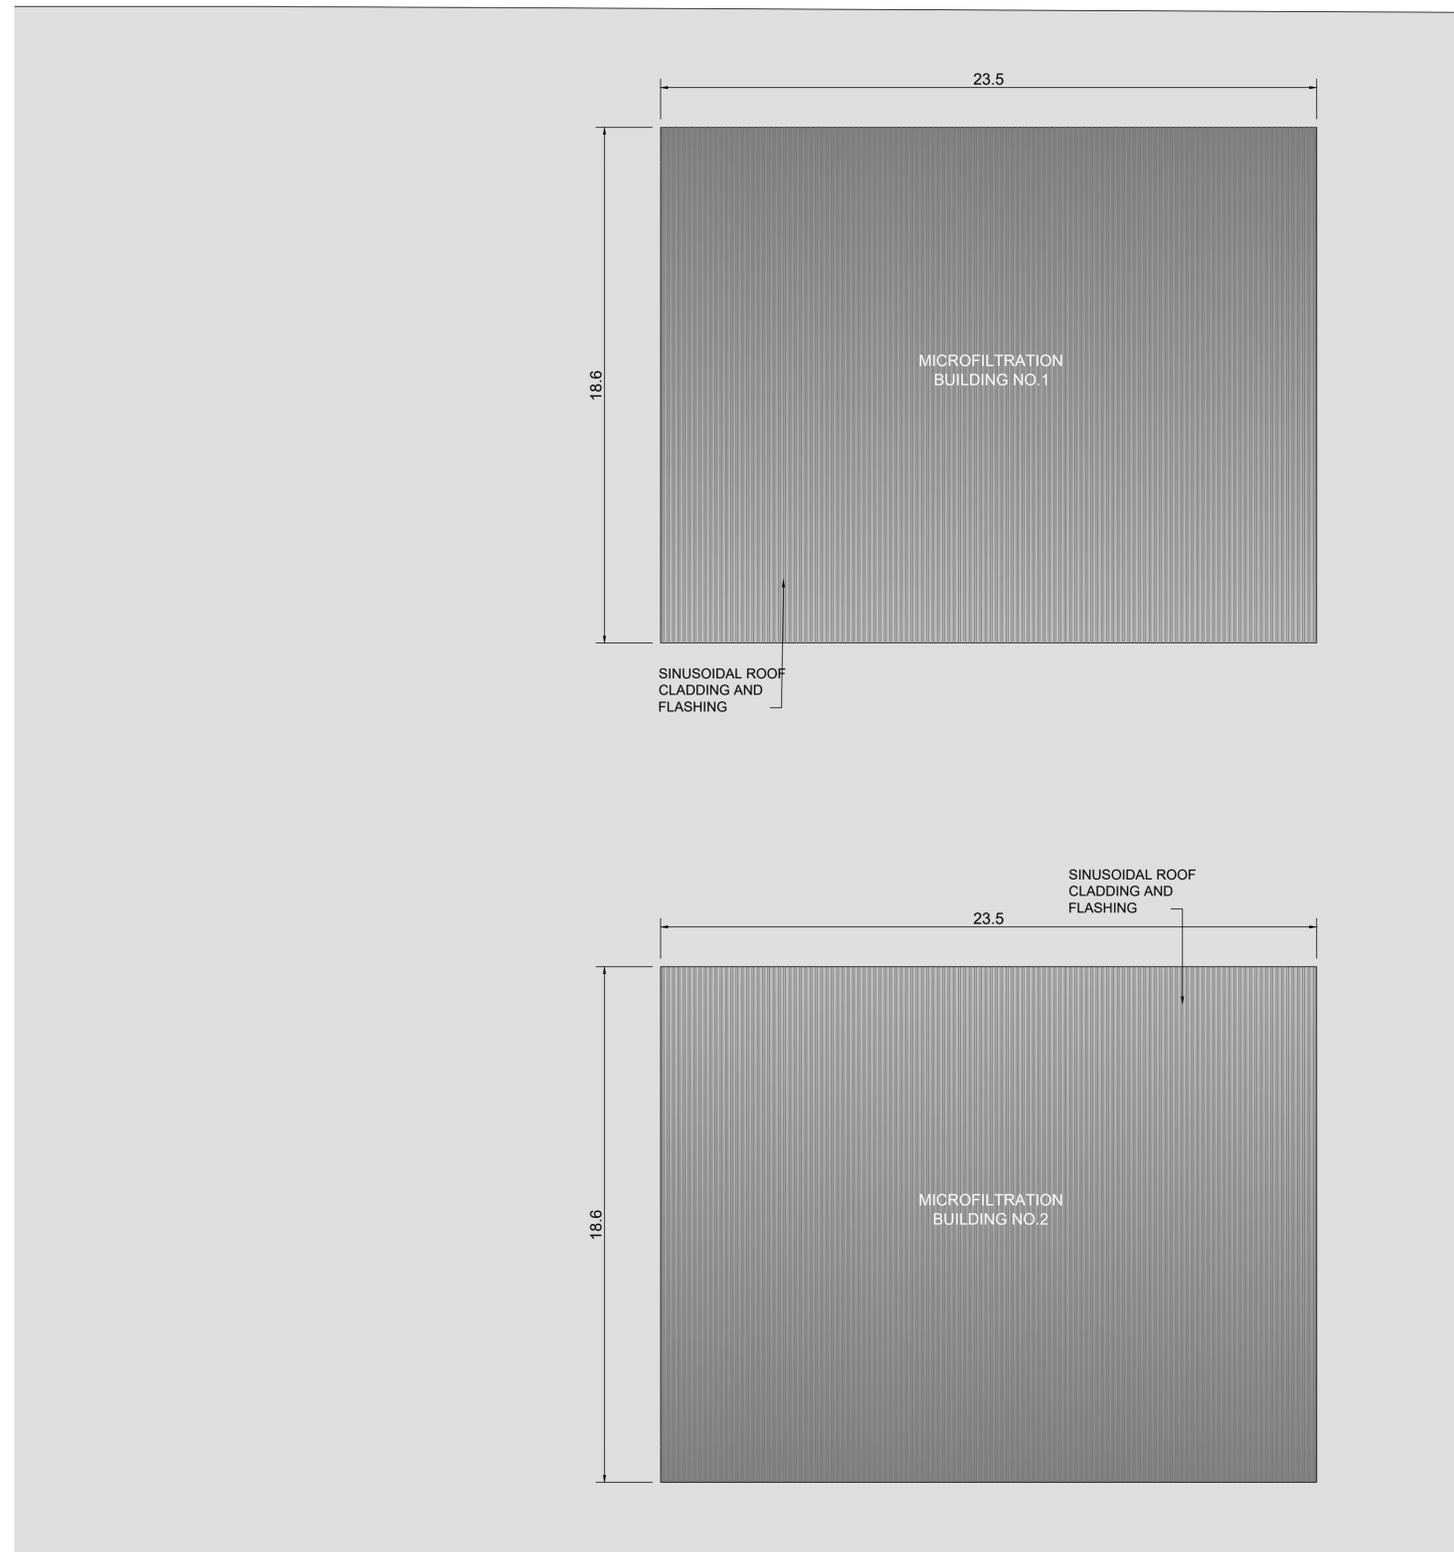

 **ROOF PLAN**
SCALE 1:125

F01	FINAL FOR PLANNING	EM	BG	BG	DEC 25
A01	FOR PLANNING	JM	BG	BG	FEB 25
Rev	Description	Drawn	Chk'd	App'd	Date

This drawing is the property of Irish Water and must not be copied or used for any purpose other than that for which it is supplied without the written consent of Irish Water.

Uisce Éireann
Irish Water

UISCE ÉIREANN
COLVILL HOUSE,
TALBOT STREET,
DUBLIN 1,
IRELAND

Tionscadal Soláthair Uisce
Water Supply Project

Call 1890 278 278
Int: 00 353 1 707 2828

Jacobs TOBIN

Originated By DC	Drawn By JM	Checked By BG	Approved By BG
Date 07.02.25	Date 01.12.25	Date 01.12.25	Date 01.12.25

Scale
1:125 @ A1


Project Title
WATER SUPPLY PROJECT
EASTERN AND MIDLANDS REGION

Drawing Title
RAW WATER INTAKE AND
PUMPING STATION
MICROFILTRATION BUILDING ROOF PLAN






Drawing Status: FINAL FOR PLANNING
Jacobs Tobin No. 32105801 Client No. 9318

Drawing No.
32105801-850-01009

- Notes:
- ALL DIMENSIONS ARE IN METRES AND ALL LEVELS ARE IN METRES AOD MALIN HEAD UNLESS OTHERWISE STATED
 - THIS DRAWING IS FOR PLANNING PURPOSES ONLY.

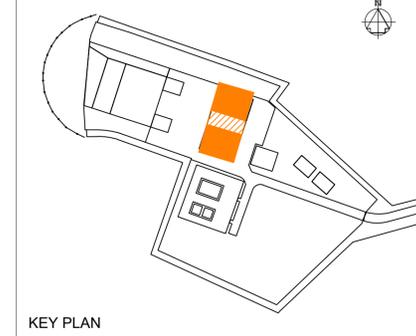

 - LEGEND
- LOCATION OF DETAIL ON KEY PLAN
 - FGL FINISHED FLOOR LEVEL

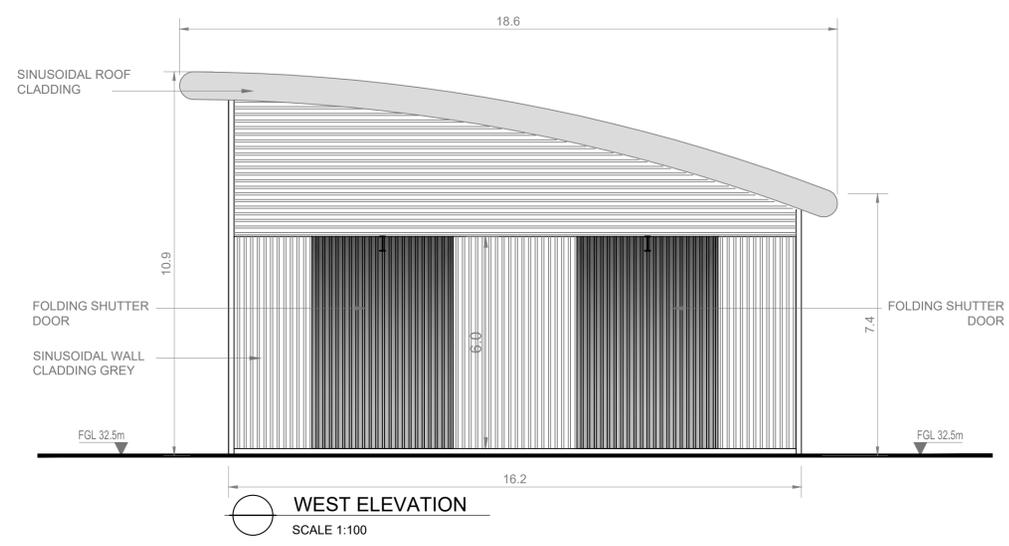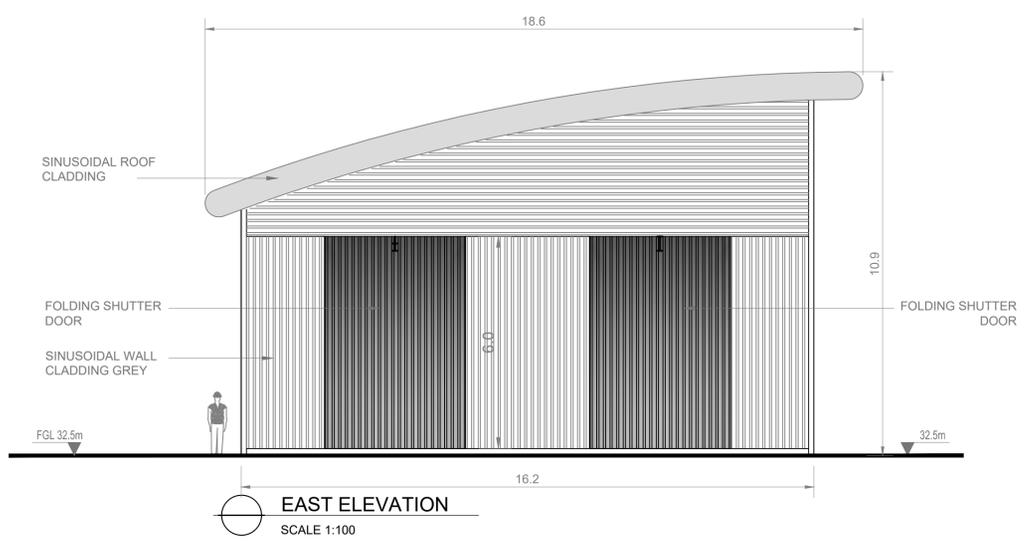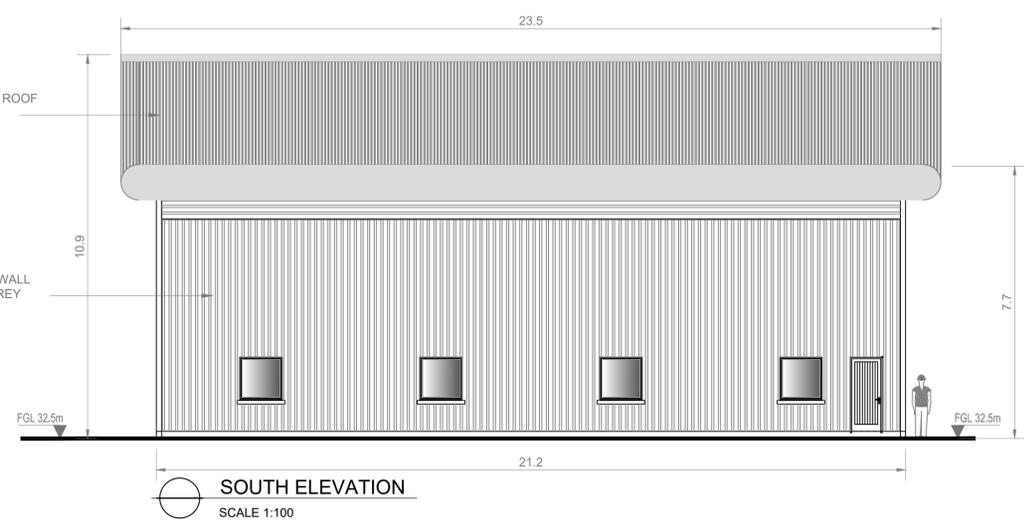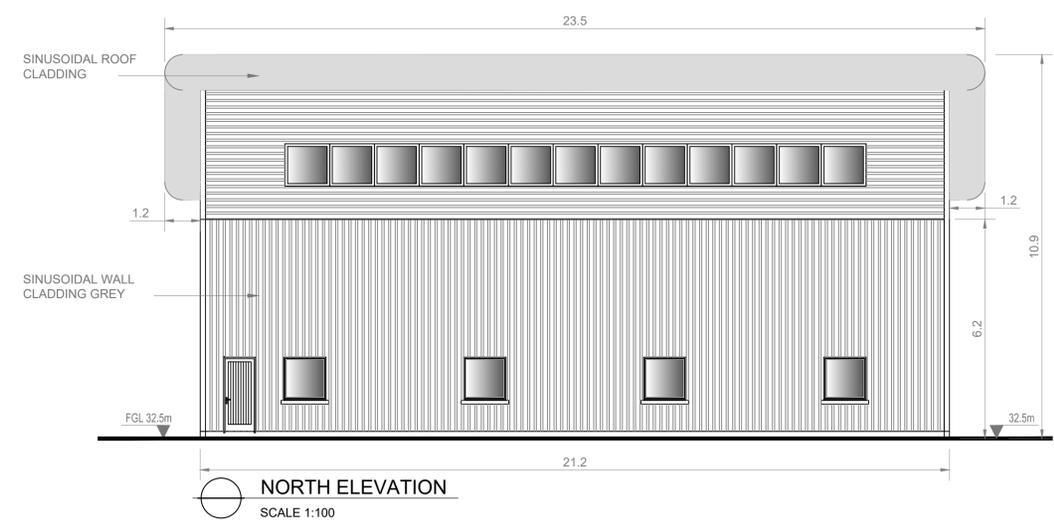

Notes:
 THIS DRAWING SHOWS ELEVATIONS FOR MICROFILTRATION BUILDING NO.2 ELEVATIONS FOR MICROFILTRATION BUILDING NO. 1 ARE THE REVERSE OF THOSE SHOWN HERE.

F01	FINAL OR PLANNING	EM	BG	BG	DEC 25
A01	FOR PLANNING	JM	BG	BG	FEB 25
Rev	Description	Drawn	Chk'd	App'd	Date

Uisce Éireann
 Irish Water

Tionscadal Soláthair Uisce
 Water Supply Project

UISCE ÉIREANN COLVILL HOUSE,
 TALBOT STREET,
 DUBLIN 1,
 IRELAND

Call 1890 278 278
 Int: 00 353 1 707 2828

JACOBS TOBIN

Originated By DC	Drawn By JM	Checked By BG	Approved By BG
Date 07.02.25	Date 01.12.25	Date 01.12.25	Date 01.12.25

Scale
 1:100 @ A1

Project Title
 WATER SUPPLY PROJECT
 EASTERN AND MIDLANDS REGION


Drawing Title
 RAW WATER INTAKE AND
 PUMPING STATION
 MICROFILTRATION BUILDING ELEVATIONS

Drawing Status
 FINAL FOR PLANNING

Jacobs Tobin No. 32105801 Client No. 9318

Drawing No.
32105801-850-01010


- Notes:
- ALL DIMENSIONS ARE IN METRES AND ALL LEVELS ARE IN METRES AOD **MALIN HEAD** UNLESS OTHERWISE STATED
 - THIS DRAWING IS FOR PLANNING PURPOSES ONLY.

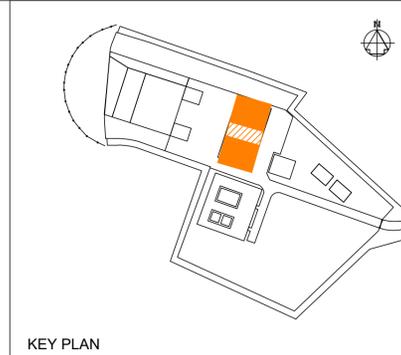

KEY PLAN

LEGEND

- LOCATION OF DETAIL ON KEY PLAN
- FFL FINISHED FLOOR LEVEL
- FGL FINISHED GROUND LEVEL

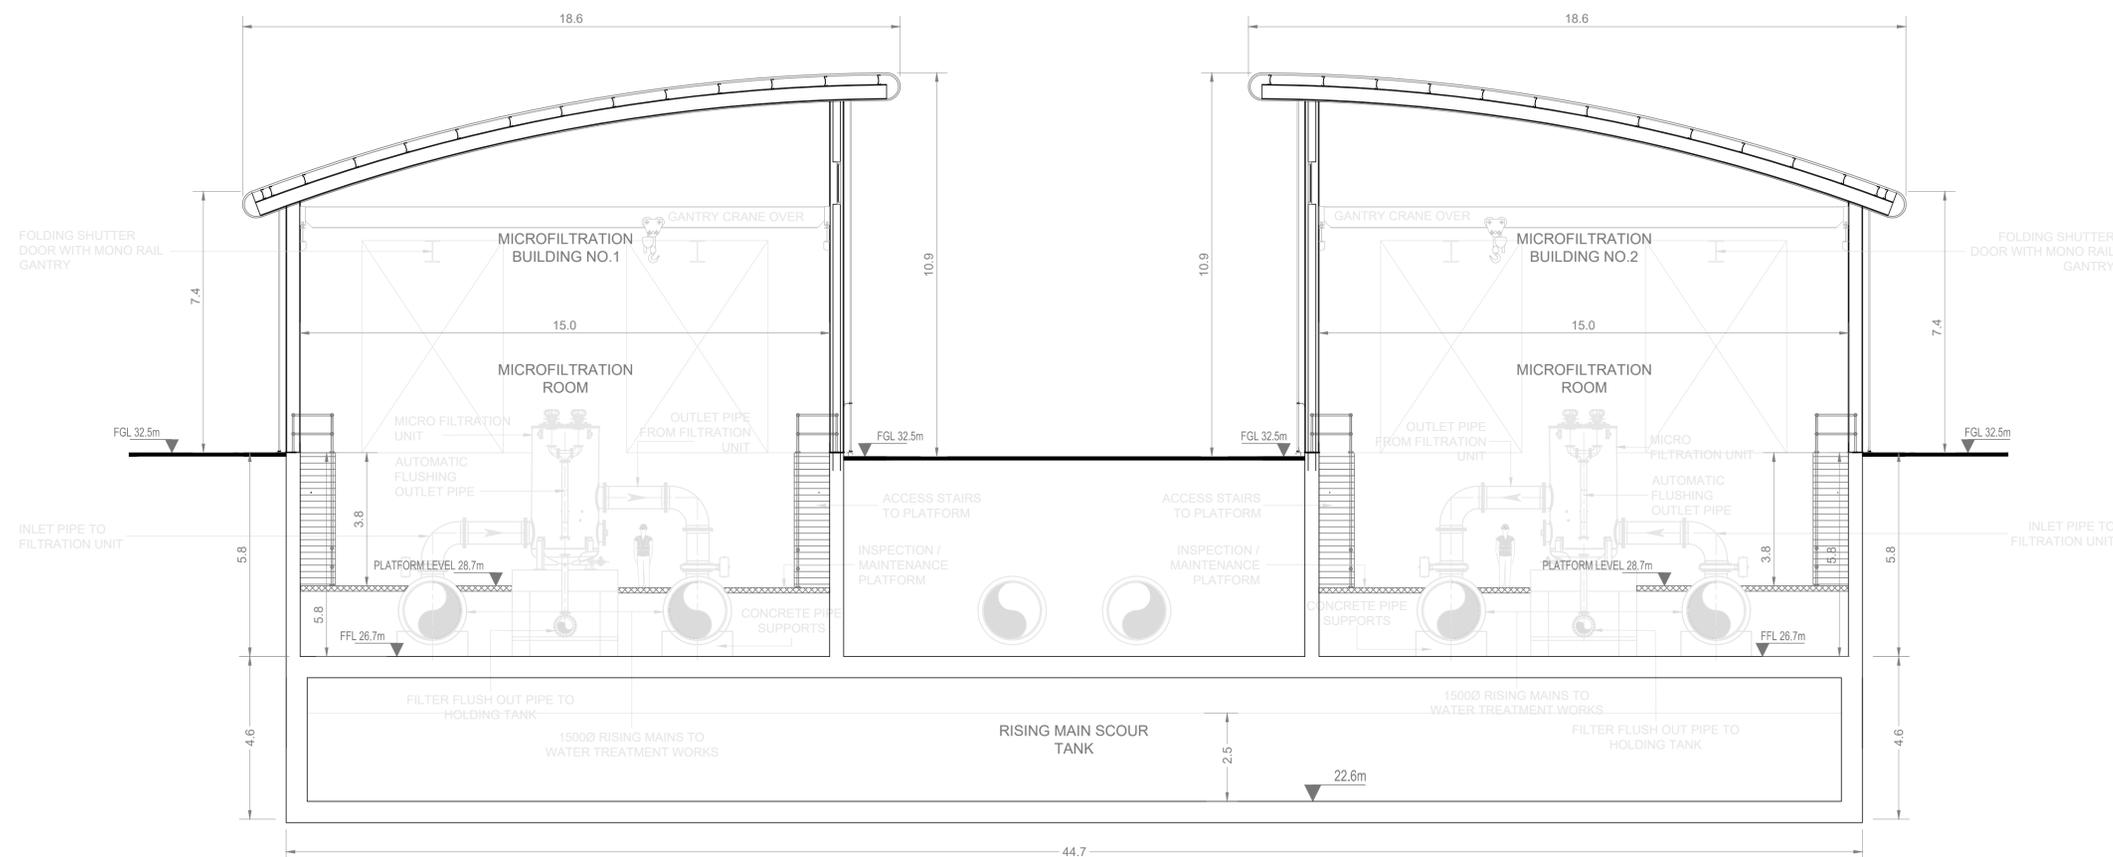

CROSS SECTION 'A'
SCALE 1:100

F01	FINAL FOR PLANNING	EM	BG	BG	DEC 25
A01	FOR PLANNING	JM	BG	BG	FEB 25

Rev	Description	Drawn	Chk'd	App'd	Date

This drawing is the property of Irish Water and must not be copied or used for any purpose other than that for which it is supplied without the written consent of Irish Water.

UISCE ÉIREANN
COLVILL HOUSE,
TALBOT STREET,
DUBLIN 1,
IRELAND

Call 1890 278 278
Int: 00 353 1 707 2828

JACOBS TOBIN

Originated By DC	Drawn By JM	Checked By BG	Approved By BG
Date 07.02.25	Date 01.12.25	Date 01.12.25	Date 01.12.25

Scale
1:100 @ A1

Project Title
WATER SUPPLY PROJECT
EASTERN AND MIDLANDS REGION

Drawing Title
RAW WATER INTAKE AND
PUMPING STATION
MICROFILTRATION BUILDINGS CROSS SECTION


Drawing Status
FINAL FOR PLANNING
Jacobs Tobin No. 32105801 Client No. 9318

Drawing No.
32105801-850-01011






- Notes:
1. ALL DIMENSIONS ARE IN METRES AND ALL LEVELS ARE IN METRES AOD MALIN HEAD UNLESS OTHERWISE STATED
 2. THIS DRAWING IS FOR PLANNING PURPOSES ONLY.

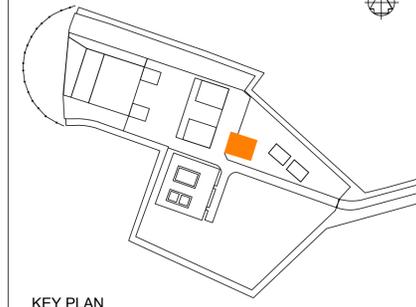


KEY PLAN


- LEGEND
- LOCATION OF DETAIL ON KEY PLAN
 - PAVED SURFACE
 - ACCESS COVERS
 - FGL FINISHED GROUND LEVEL

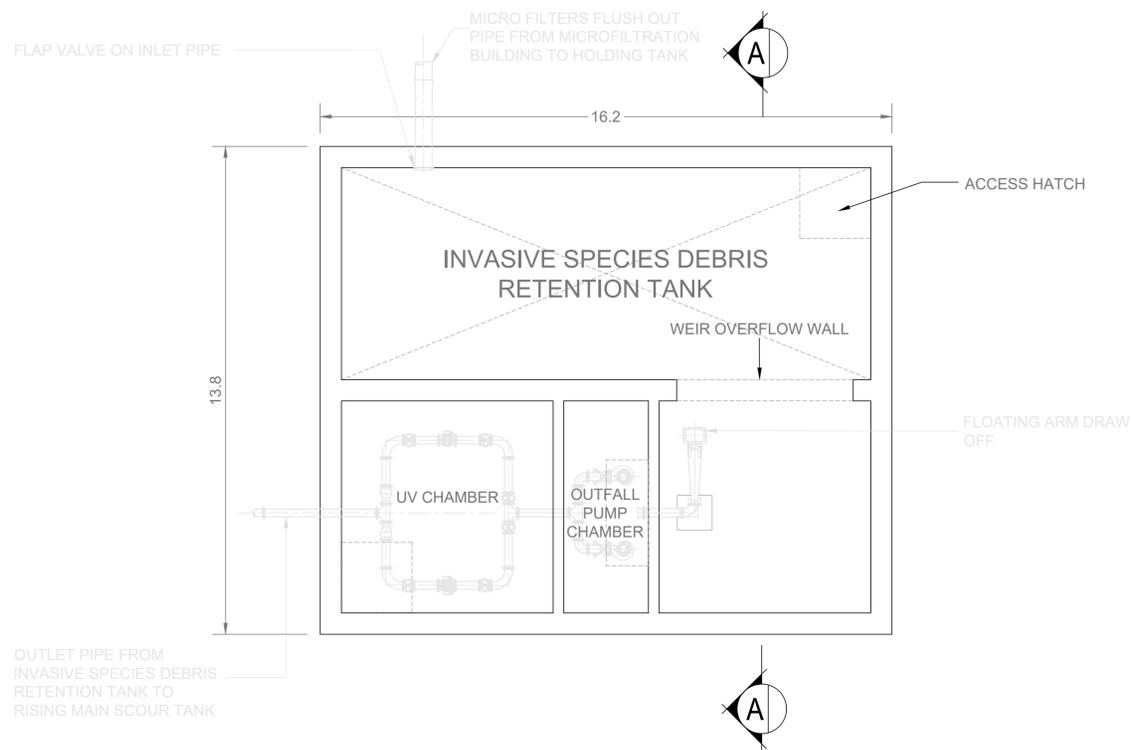

BELOW GROUND PLAN
SCALE 1:100

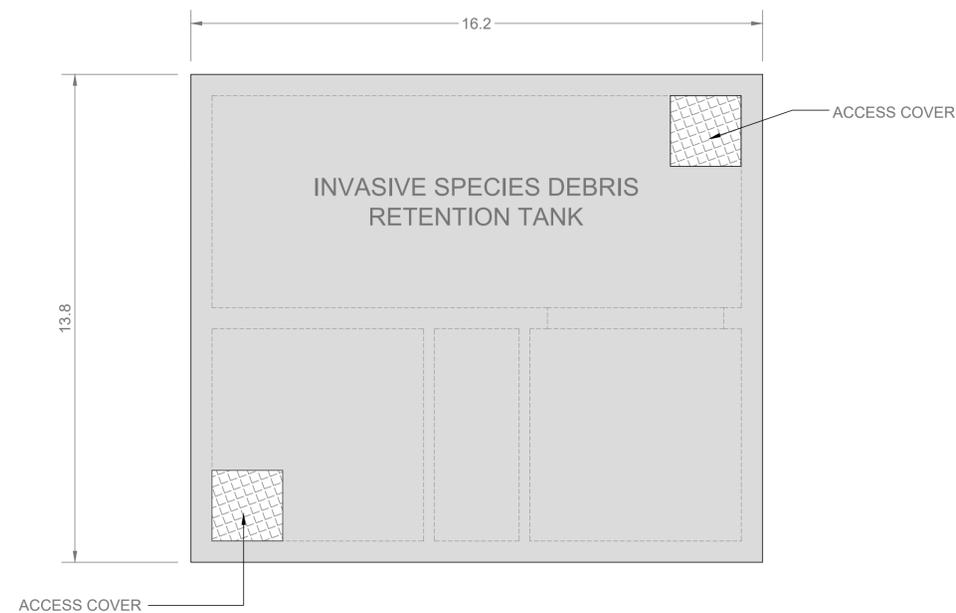

GROUND LEVEL PLAN
SCALE 1:100

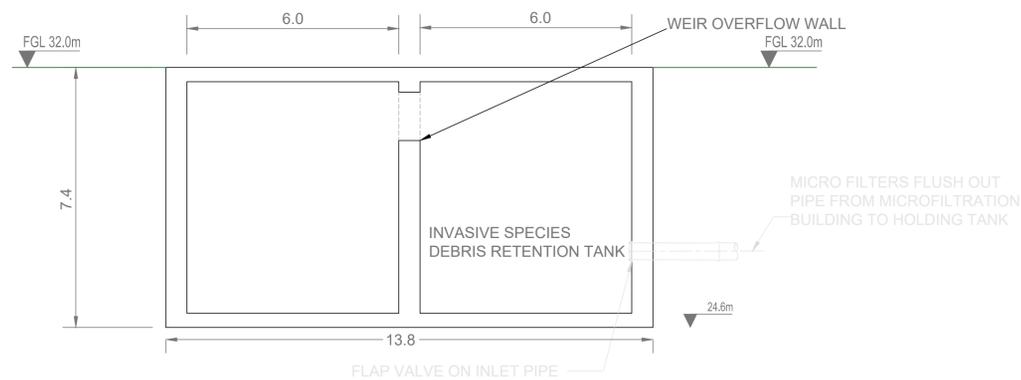

CROSS SECTION 'A-A'
SCALE 1:100



F01	FINAL FOR PLANNING	EM	BG	BG	DEC 25
A01	FOR PLANNING	JM	BG	BG	FEB 25
Rev	Description	Drawn	Chk'd	App'd	Date

This drawing is the property of Irish Water and must not be copied or used for any purpose other than that for which it is supplied without the written consent of Irish Water.

Uisce Éireann
Irish Water

UISCE ÉIREANN
COLVILL HOUSE,
TALBOT STREET,
DUBLIN 1,
IRELAND

Tionscatal
Soláthair Uisce
Water Supply
Project

Call 1890 278 278
Int: 00 353 1 707 2828

Jacobs TOBIN

Originated By DC	Drawn By JM	Checked By BG	Approved By BG
Date 07.02.25	Date 01.12.25	Date 01.12.25	Date 01.12.25



Scale
1:100 @ A1

Project Title
WATER SUPPLY PROJECT
EASTERN AND MIDLANDS REGION

Drawing Title
RAW WATER INTAKE AND PUMPING STATION
INVASIVE SPECIES DEBRIS RETENTION TANK
PLAN AND CROSS SECTION

Drawing Status: FINAL FOR PLANNING
Jacobs Tobin No. 32105801 Client No. 9318

Drawing No.
32105801-850-01012

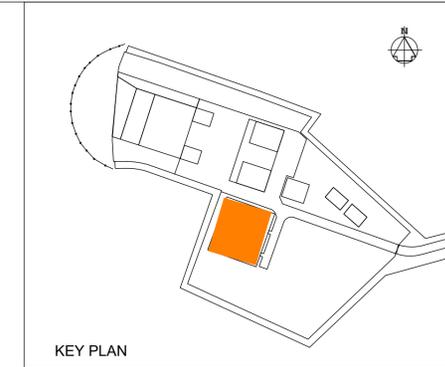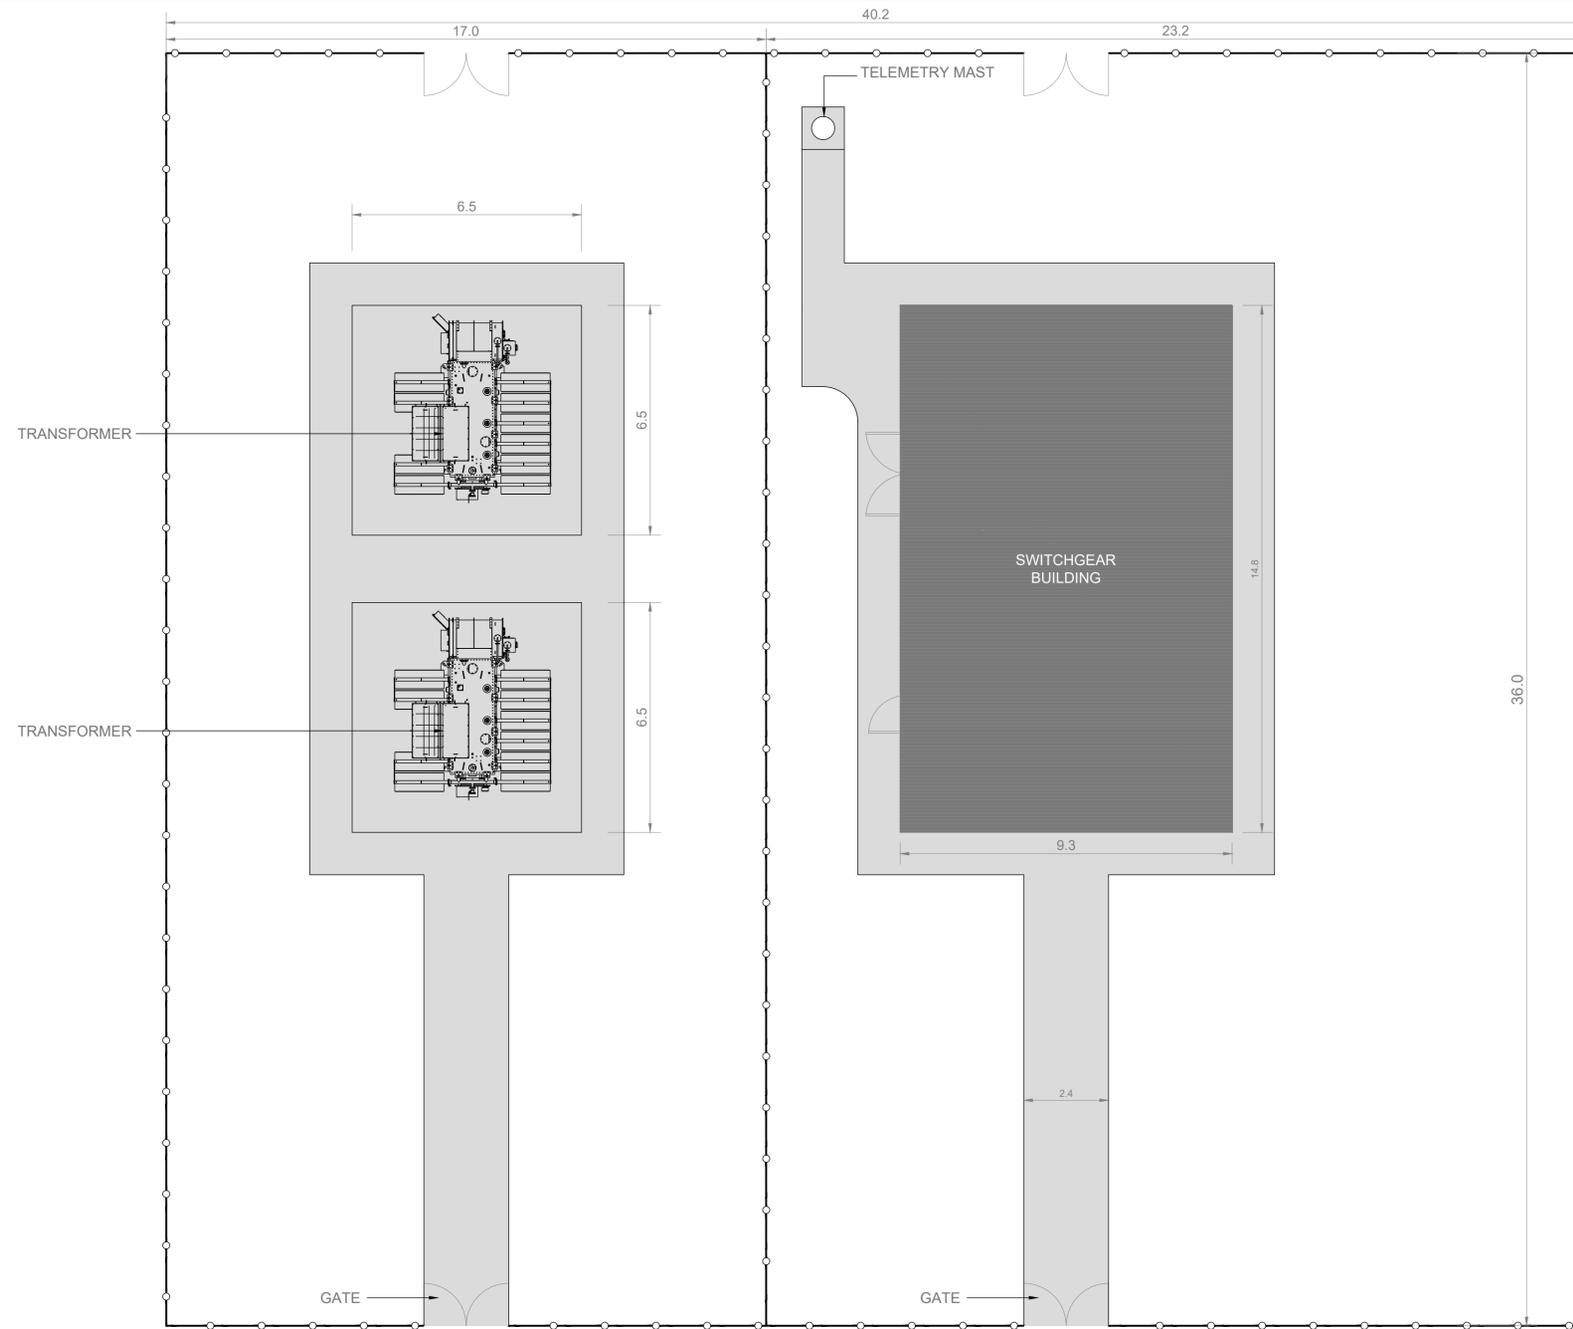

Copyright © Ordnance Survey Ireland.
Licence number 3/3/34/Irish Water.
Survey Ireland and Government of Ireland.

Original Size
A1

- Notes:
1. ALL DIMENSIONS ARE IN METRES AND ALL LEVELS ARE IN METRES AOD MALIN HEAD UNLESS OTHERWISE STATED.
 2. THIS DRAWING IS FOR PLANNING PURPOSES ONLY.

- LEGEND
- 2.4m HIGH PALADIN SITE SECURITY FENCE
 - LOCATION OF DETAIL ON KEY PLAN
 - PAVED SURFACE

F01	FINAL FOR PLANNING	EM	BG	BG	DEC' 25
A01	FOR PLANNING	JM	BG	BG	FEB' 25
Rev	Description	Drawn	Chk'd	App'd	Date

This drawing is the property of Irish Water and must not be copied or used for any purpose other than that for which it is supplied without the written consent of Irish Water.

Uisce Éireann
Irish Water

Tionscadal Soláthair Uisce
Water Supply Project

UISCE ÉIREANN
COLVILL HOUSE,
TALBOT STREET,
DUBLIN 1,
IRELAND

Call 1890 278 278
Int: 00 353 1 707 2828

Jacobs TOBIN

Originated By DC	Drawn By JM	Checked By BG	Approved By BG
Date 07.02.25	Date 01.12.25	Date 01.12.25	Date 01.12.25

 

Scale
1:100 @ A1

Project Title
WATER SUPPLY PROJECT
EASTERN AND MIDLANDS REGION

Drawing Title
RAW WATER INTAKE AND PUMPING STATION
SUBSTATION
SITE PLAN AND ELEVATION








Drawing Status FINAL FOR PLANNING
Jacobs Tobin No. 32105801 Client No. 9318

Drawing No.
32105801-850-01015

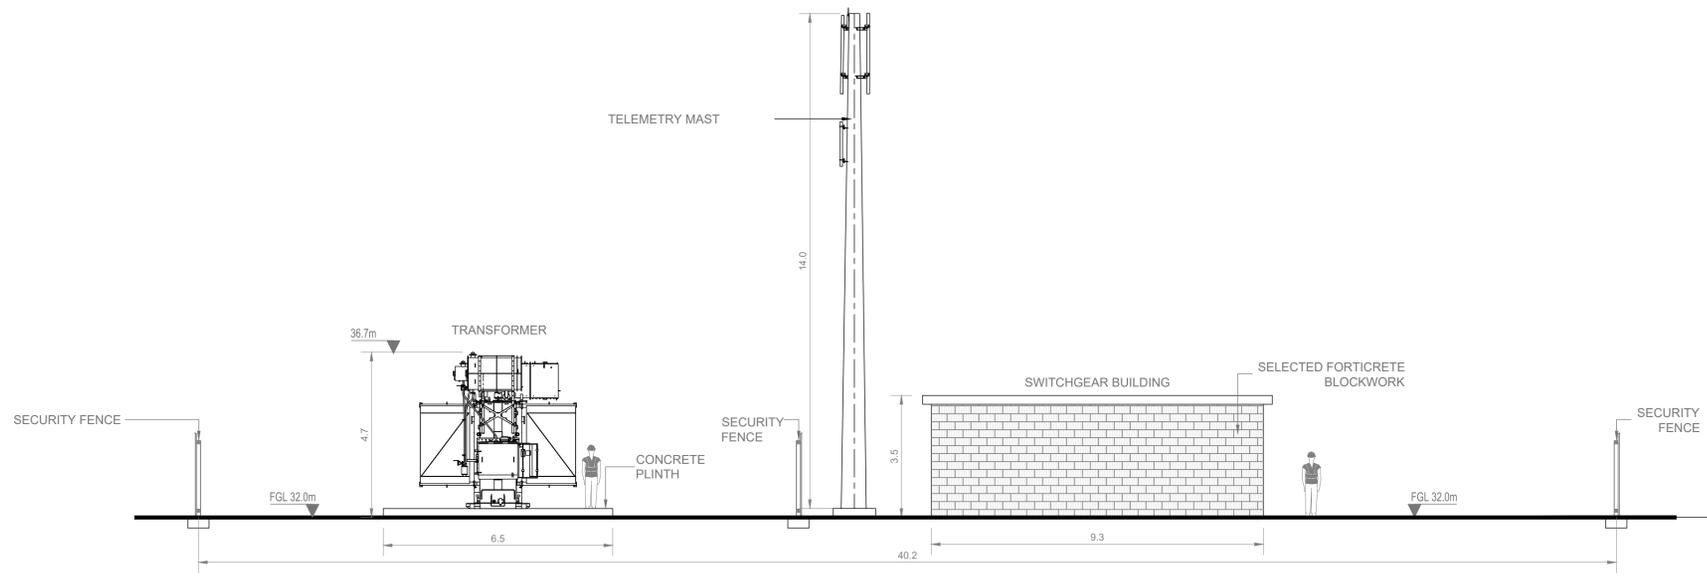

CROSS SECTION 'A' EAST ELEVATION
SCALE 1:100

Notes:
1. ALL DIMENSIONS ARE IN METRES AND ALL LEVELS ARE IN METRES AOD MALIN HEAD UNLESS OTHERWISE STATED
2. THIS DRAWING IS FOR PLANNING PURPOSES ONLY.

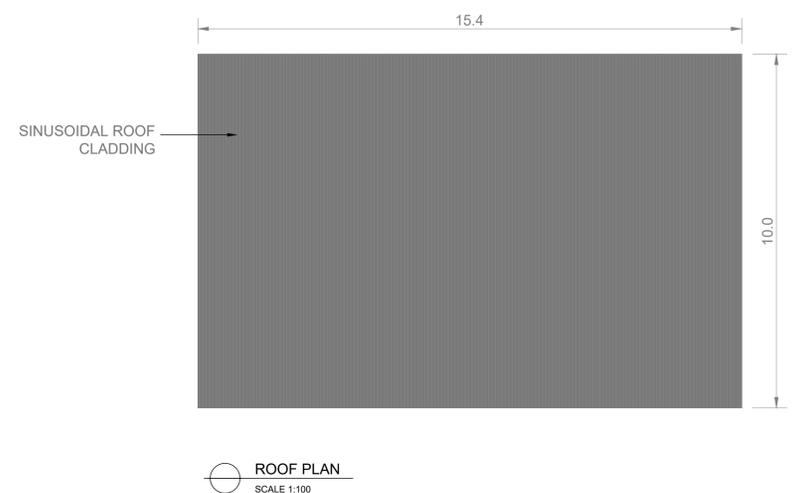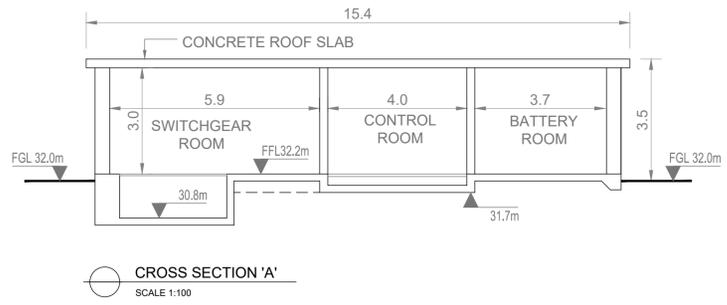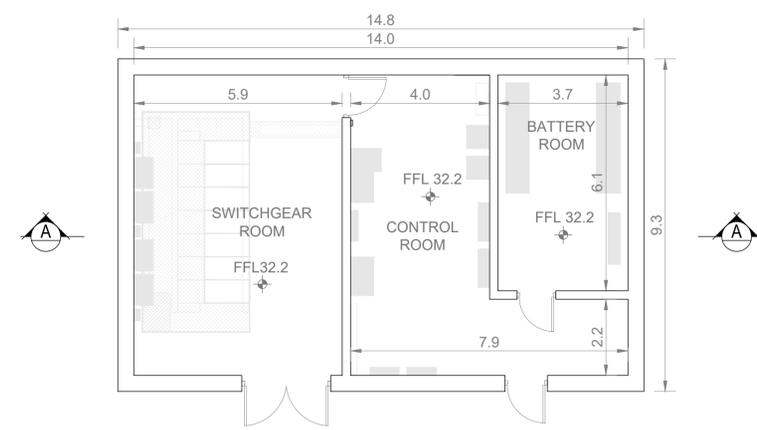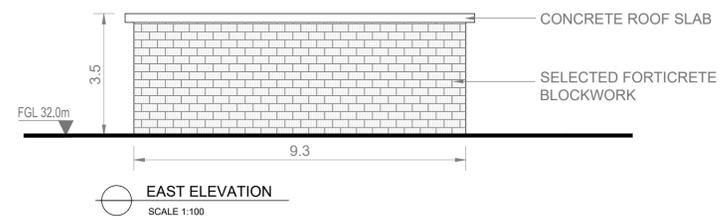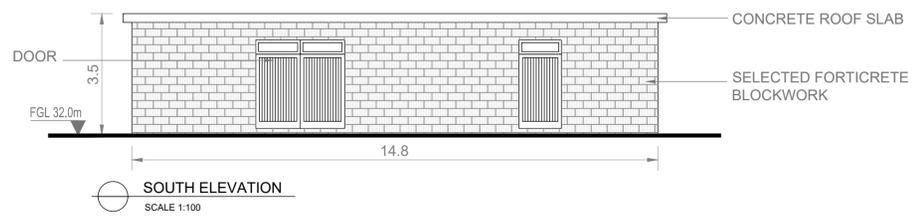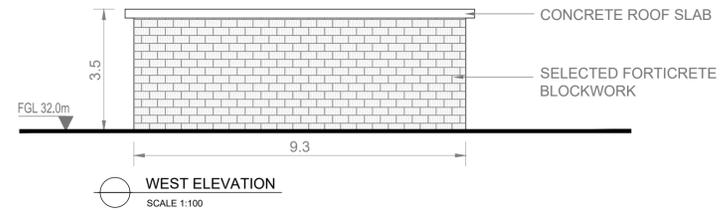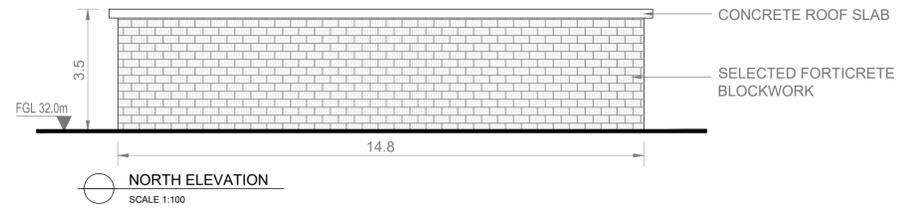

LEGEND

LOCATION OF DETAIL ON KEY PLAN

FGL FINISHED GROUND LEVEL
FFL FINISHED FLOOR LEVEL

F01	FINAL FOR PLANNING	EM	BG	BG	DEC 25
A01	FOR PLANNING	JM	BG	BG	FEB 25
Rev	Description	Drawn	Chkd	App'd	Date

This drawing is the property of Irish Water and must not be copied or used for any purpose other than that for which it is supplied without the written consent of Irish Water.

Uisce Éireann Irish Water

UISCE ÉIREANN
COLVILL HOUSE,
TALBOT STREET,
DUBLIN 1,
IRELAND

Tionscadal Soláthair Uisce Water Supply Project

Call 1890 278 278
Int: 00 353 1 707 2828

JACOBS TOBIN

Originated By DC	Drawn By JM	Checked By BG	Approved By BG
Date 07.02.25	Date 01.12.25	Date 01.12.25	Date 01.12.25

Scale
1:100 @ A1

 
 

Project Title
WATER SUPPLY PROJECT
EASTERN AND MIDLANDS REGION

Drawing Title
RAW WATER INTAKE AND PUMPING STATION
SUBSTATION SWITCHGEAR BUILDING
PLANS, CROSS SECTION AND ELEVATIONS

Drawing Status
FINAL FOR PLANNING

Jacobs Tobin No. 32105801 Client No. 9318

Drawing No.
32105801-850-01016

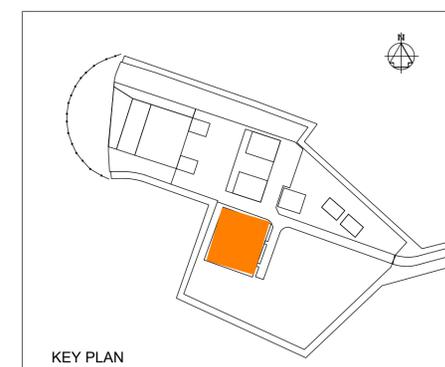



Notes:
1. ALL DIMENSIONS ARE IN METRES AND ALL LEVELS ARE IN METRES AOD MALIN HEAD UNLESS OTHERWISE STATED.
2. THIS DRAWING IS FOR PLANNING PURPOSES ONLY.

OSI Sheet No(s):
4447-C, 4447-D

- LEGEND**
- PLANNING APPLICATION BOUNDARY
 - INDICATIVE PERMANENT WAYLEAVE
 - ROAD / PAVED SURFACE
 - BUILDING
 - UNDERGROUND STRUCTURES
 - ACCESS COVERS
 - 1.2m HIGH POST AND RAIL FENCE
 - 2.4M HIGH PALADIN SITE SECURITY FENCE
 - FOUL DRAINAGE
 - SURFACE WATER DRAINAGE

F01	FINAL FOR PLANNING	EM	BG	BG	DEC 25
A01	FOR PLANNING	JM	BG	BG	FEB 25
Rev	Description	Drawn	Chk'd	App'd	Date

This drawing is the property of Irish Water and must not be copied or used for any purpose other than that for which it is supplied without the written consent of Irish Water.



Uisce Éireann
Irish Water

UISCE ÉIREANN
COLVILL HOUSE,
TALBOT STREET,
DUBLIN 1,
IRELAND

Call 1890 278 278
Int: 00 353 1 707 2828



Tionscadal Soláthair Uisce
Water Supply Project

Jacobs TOBIN

Originated By DC	Drawn By JM	Checked By BG	Approved By BG
Date 07.02.25	Date 01.12.25	Date 01.12.25	Date 01.12.25


Scale
1:500 @ A1

Project Title
WATER SUPPLY PROJECT
EASTERN AND MIDLANDS REGION

Drawing Title
RAW WATER INTAKE AND
PUMPING STATION
PROPOSED DRAINAGE PLAN

Drawing Status: FINAL FOR PLANNING
Jacobs Tobin No. 32105801 | Client No. 9318

Drawing No.
32105801-850-01017

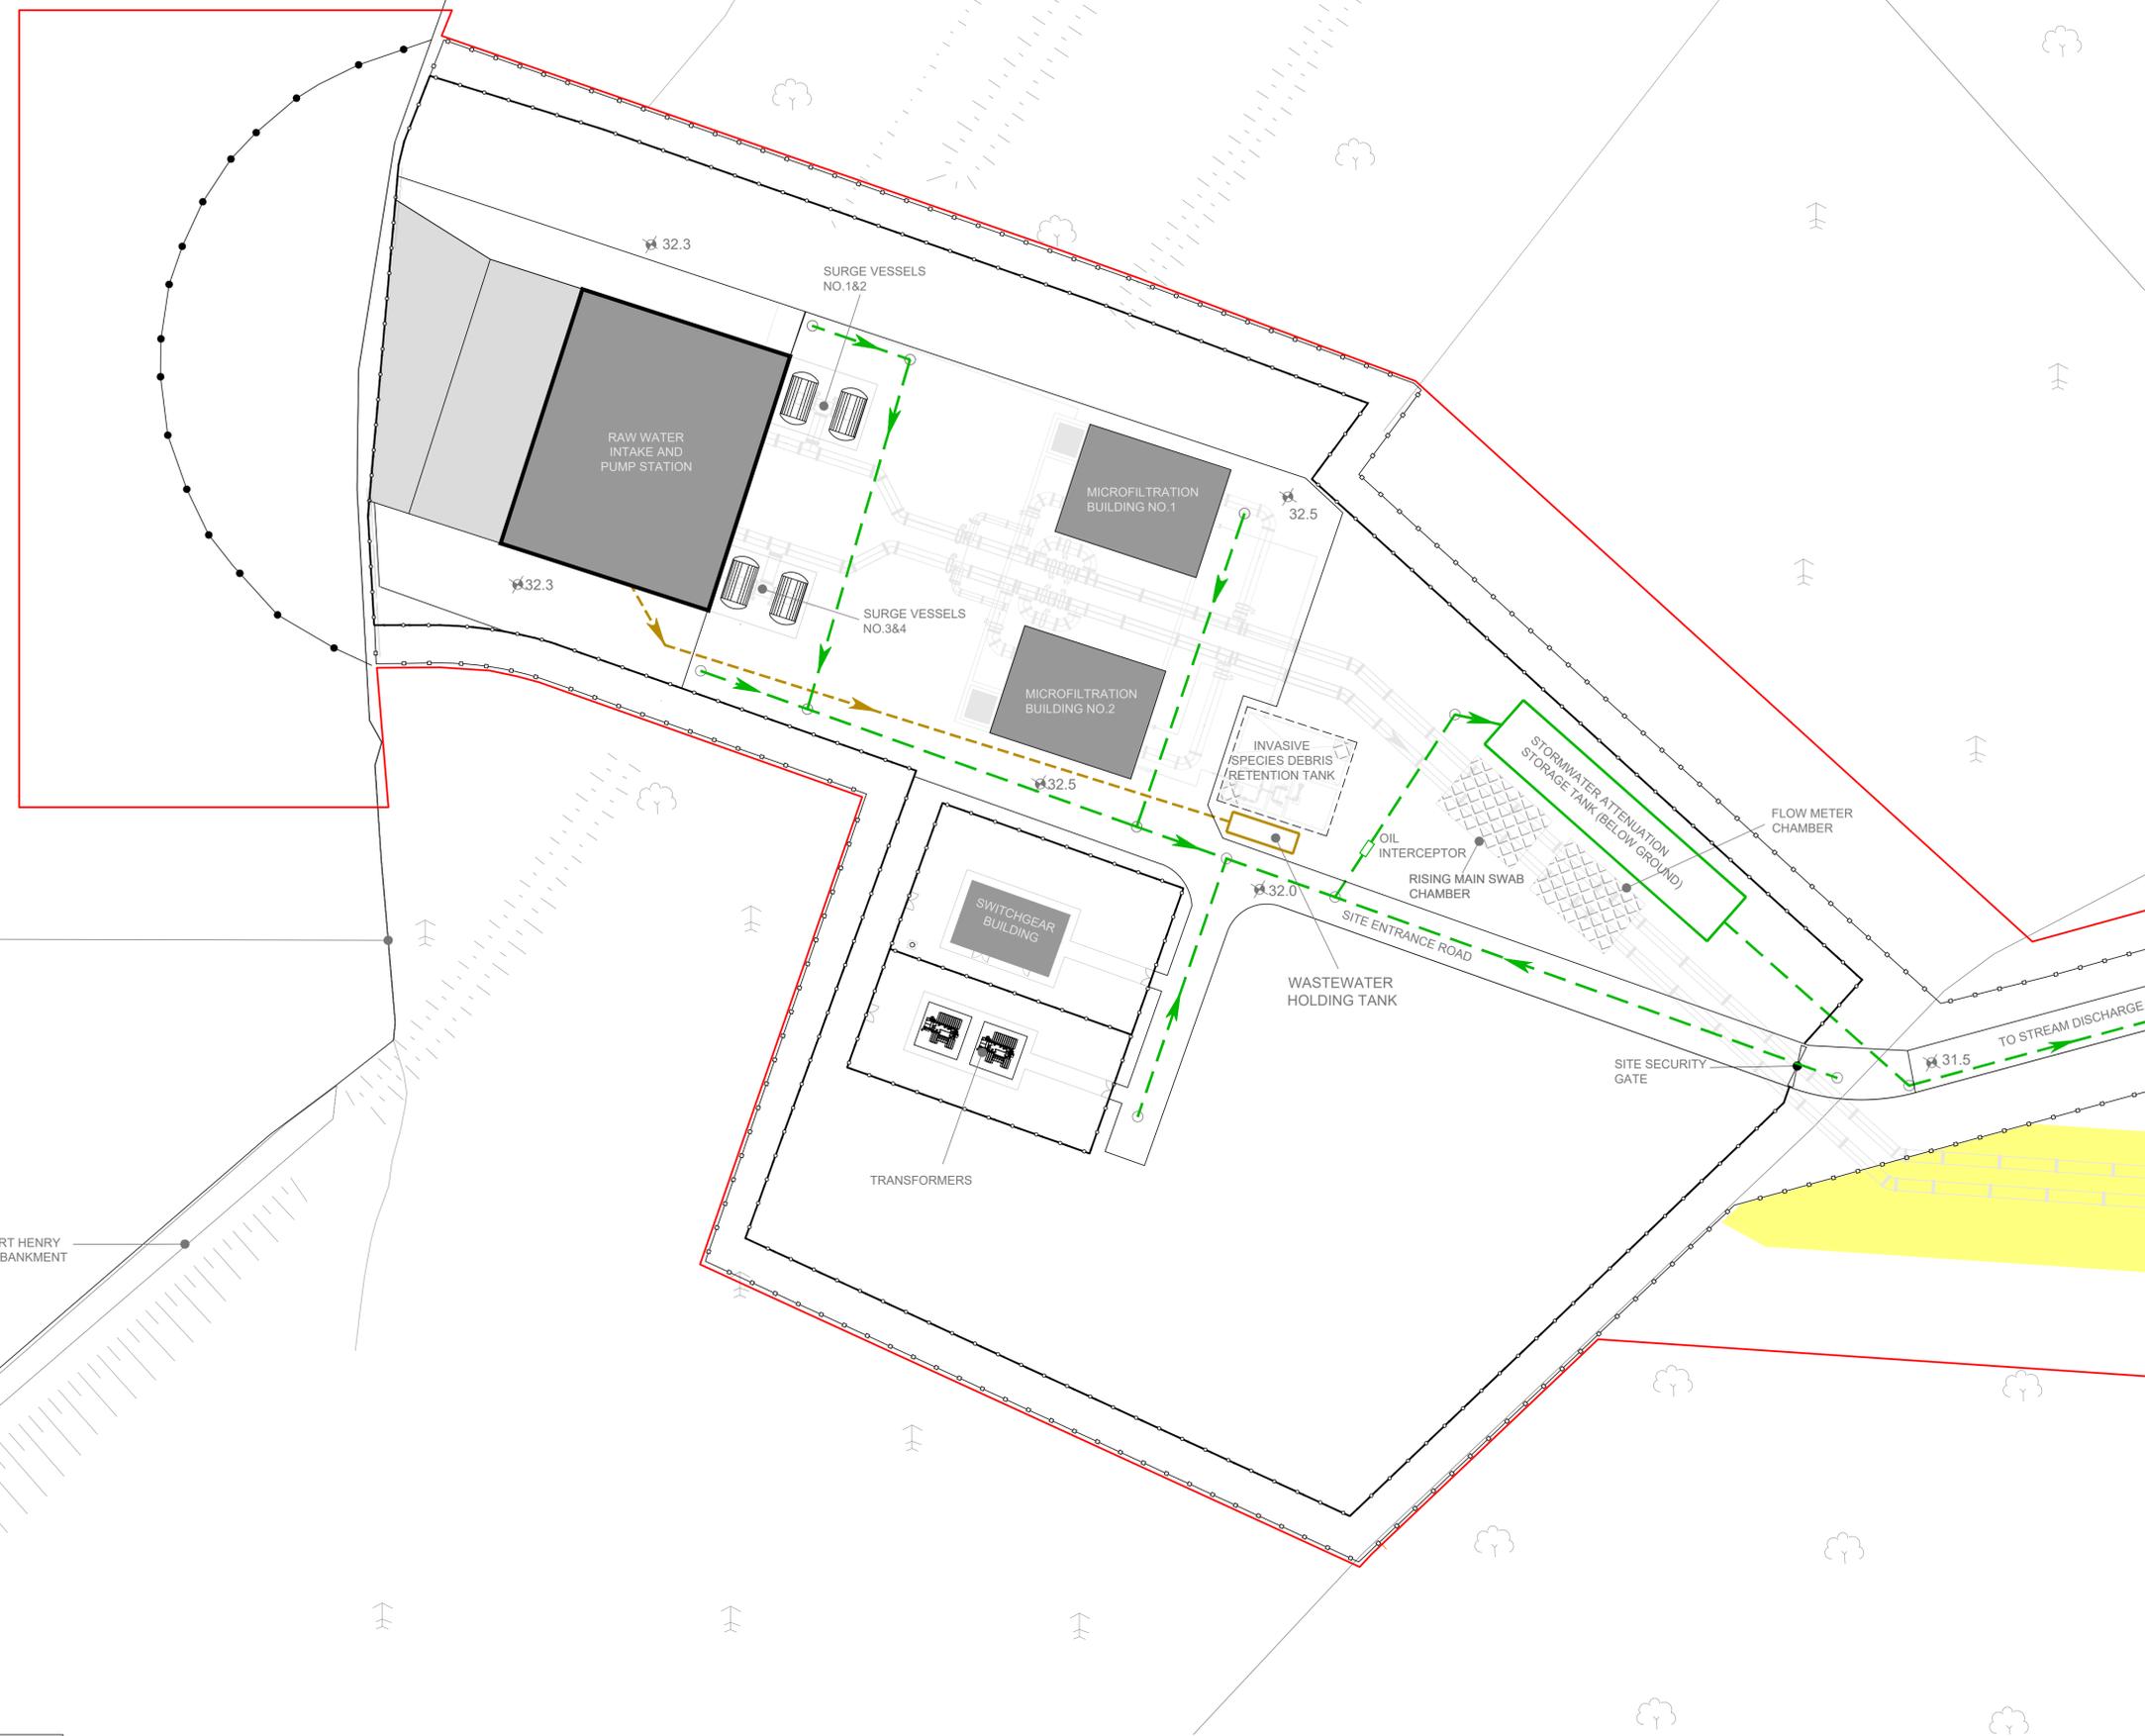

SHORE LINE

FORT HENRY EMBANKMENT





Notes:
1. ALL DIMENSIONS ARE IN METRES AND ALL LEVELS ARE IN METRES AOD MALIN HEAD UNLESS OTHERWISE STATED.
2. THIS DRAWING IS FOR PLANNING PURPOSES ONLY.

OSI Sheet No(s):
4447-C, 4447-D

- LEGEND**
- PLANNING APPLICATION BOUNDARY
 - 1.2m HIGH POST AND RAIL FENCE
 - 2.4m HIGH PALADIN SITE SECURITY FENCE
 - INDICATIVE PERMANENT WAYLEAVE
 - BUILDING
 - ROAD / PAVED SURFACE
 - ACCESS COVERS
 - UNDERGROUND STRUCTURES
 - POWER SUPPLY
 - TELECOMMUNICATIONS SUPPLY
 - WATERMAIN

F01	FINAL FOR PLANNING	EM	BG	BG	DEC 25
A01	FOR PLANNING	JM	BG	BG	FEB 25
Rev	Description	Drawn	Chk'd	App'd	Date

This drawing is the property of Irish Water and must not be copied or used for any purpose other than that for which it is supplied without the written consent of Irish Water.



Uisce Éireann
Irish Water

UISCE ÉIREANN
COLVILL HOUSE,
TALBOT STREET,
DUBLIN 1,
IRELAND

Call 1890 278 278
Int: 00 353 1 707 2828



Tionscadal Soláthair Uisce
Water Supply Project

Jacobs TOBIN

Originated By DC	Drawn By JM	Checked By BG	Approved By BG
Date 07.02.25	Date 01.12.25	Date 01.12.25	Date 01.12.25


Scale
1:500 @ A1

Project Title
**WATER SUPPLY PROJECT
EASTERN AND MIDLANDS REGION**

Drawing Title
**RAW WATER INTAKE AND
PUMPING STATION
PROPOSED SERVICES PLAN**


Drawing Status: FINAL FOR PLANNING
Jacobs Tobin No. 32105801 | Client No. 9318

Drawing No.
32105801-850-01018

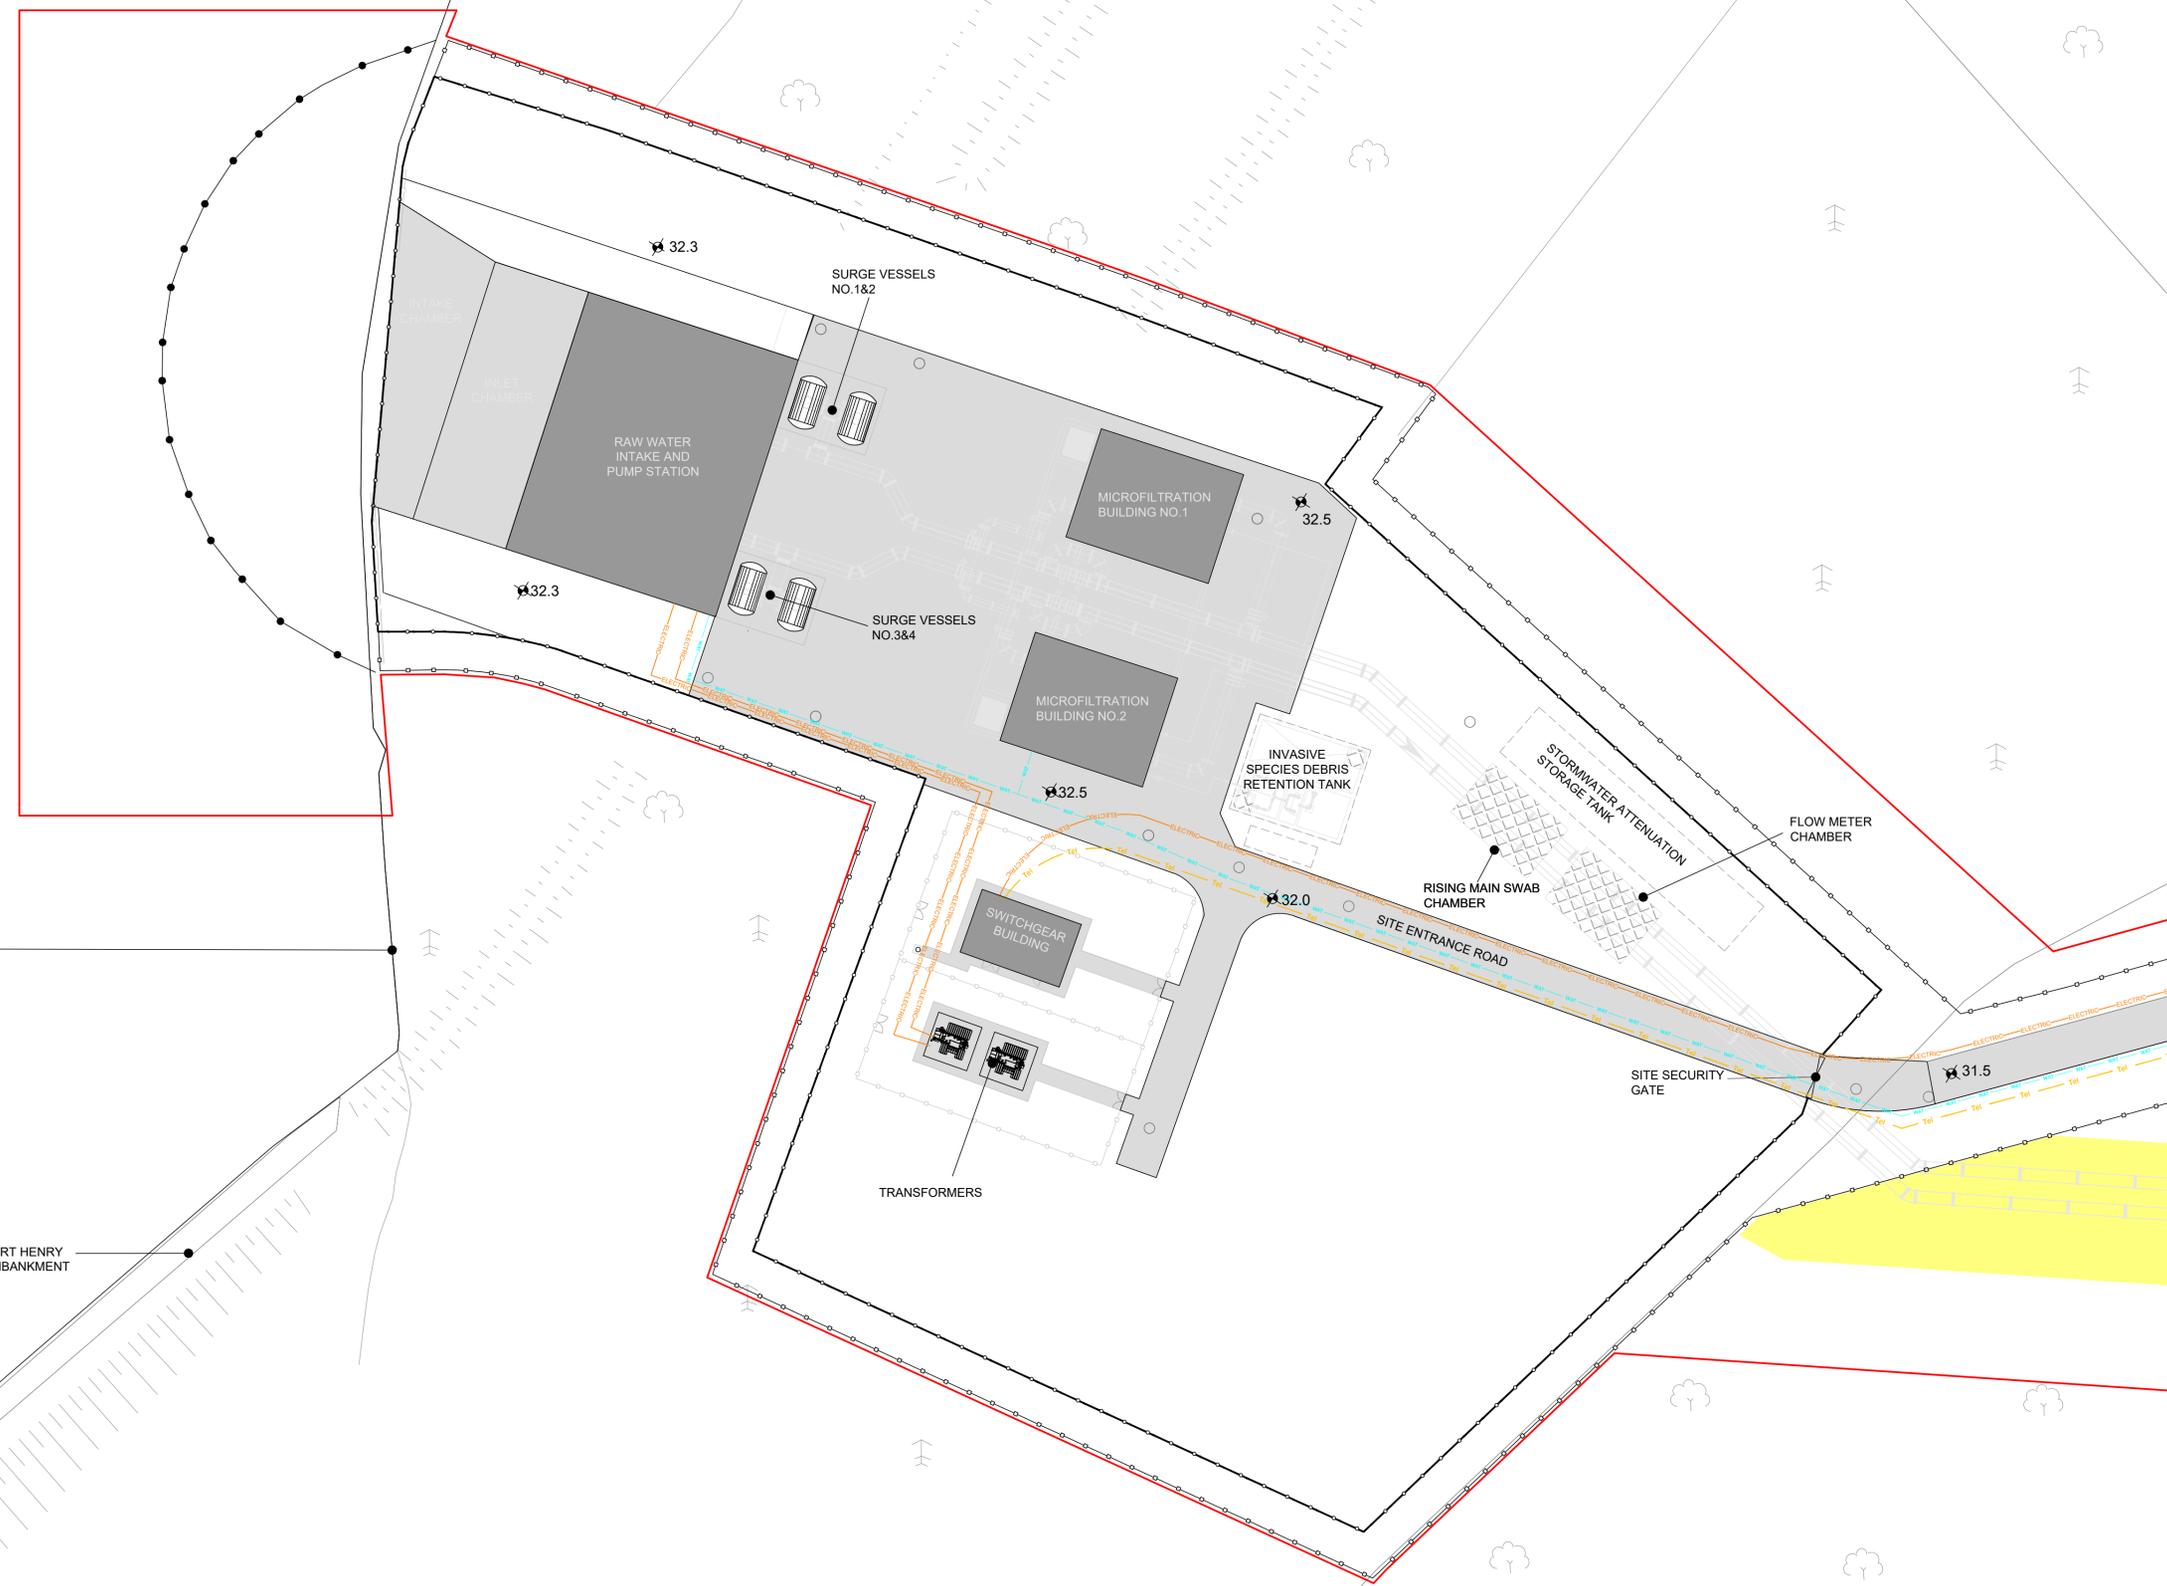




SHORE LINE

 FORT HENRY EMBANKMENT



Notes:
1. ALL DIMENSIONS ARE IN METRES AND ALL LEVELS ARE IN METRES AOD MALIN HEAD UNLESS OTHERWISE STATED
2. THIS DRAWING IS FOR PLANNING PURPOSES ONLY.

OSI Sheet No(s):
4447-D

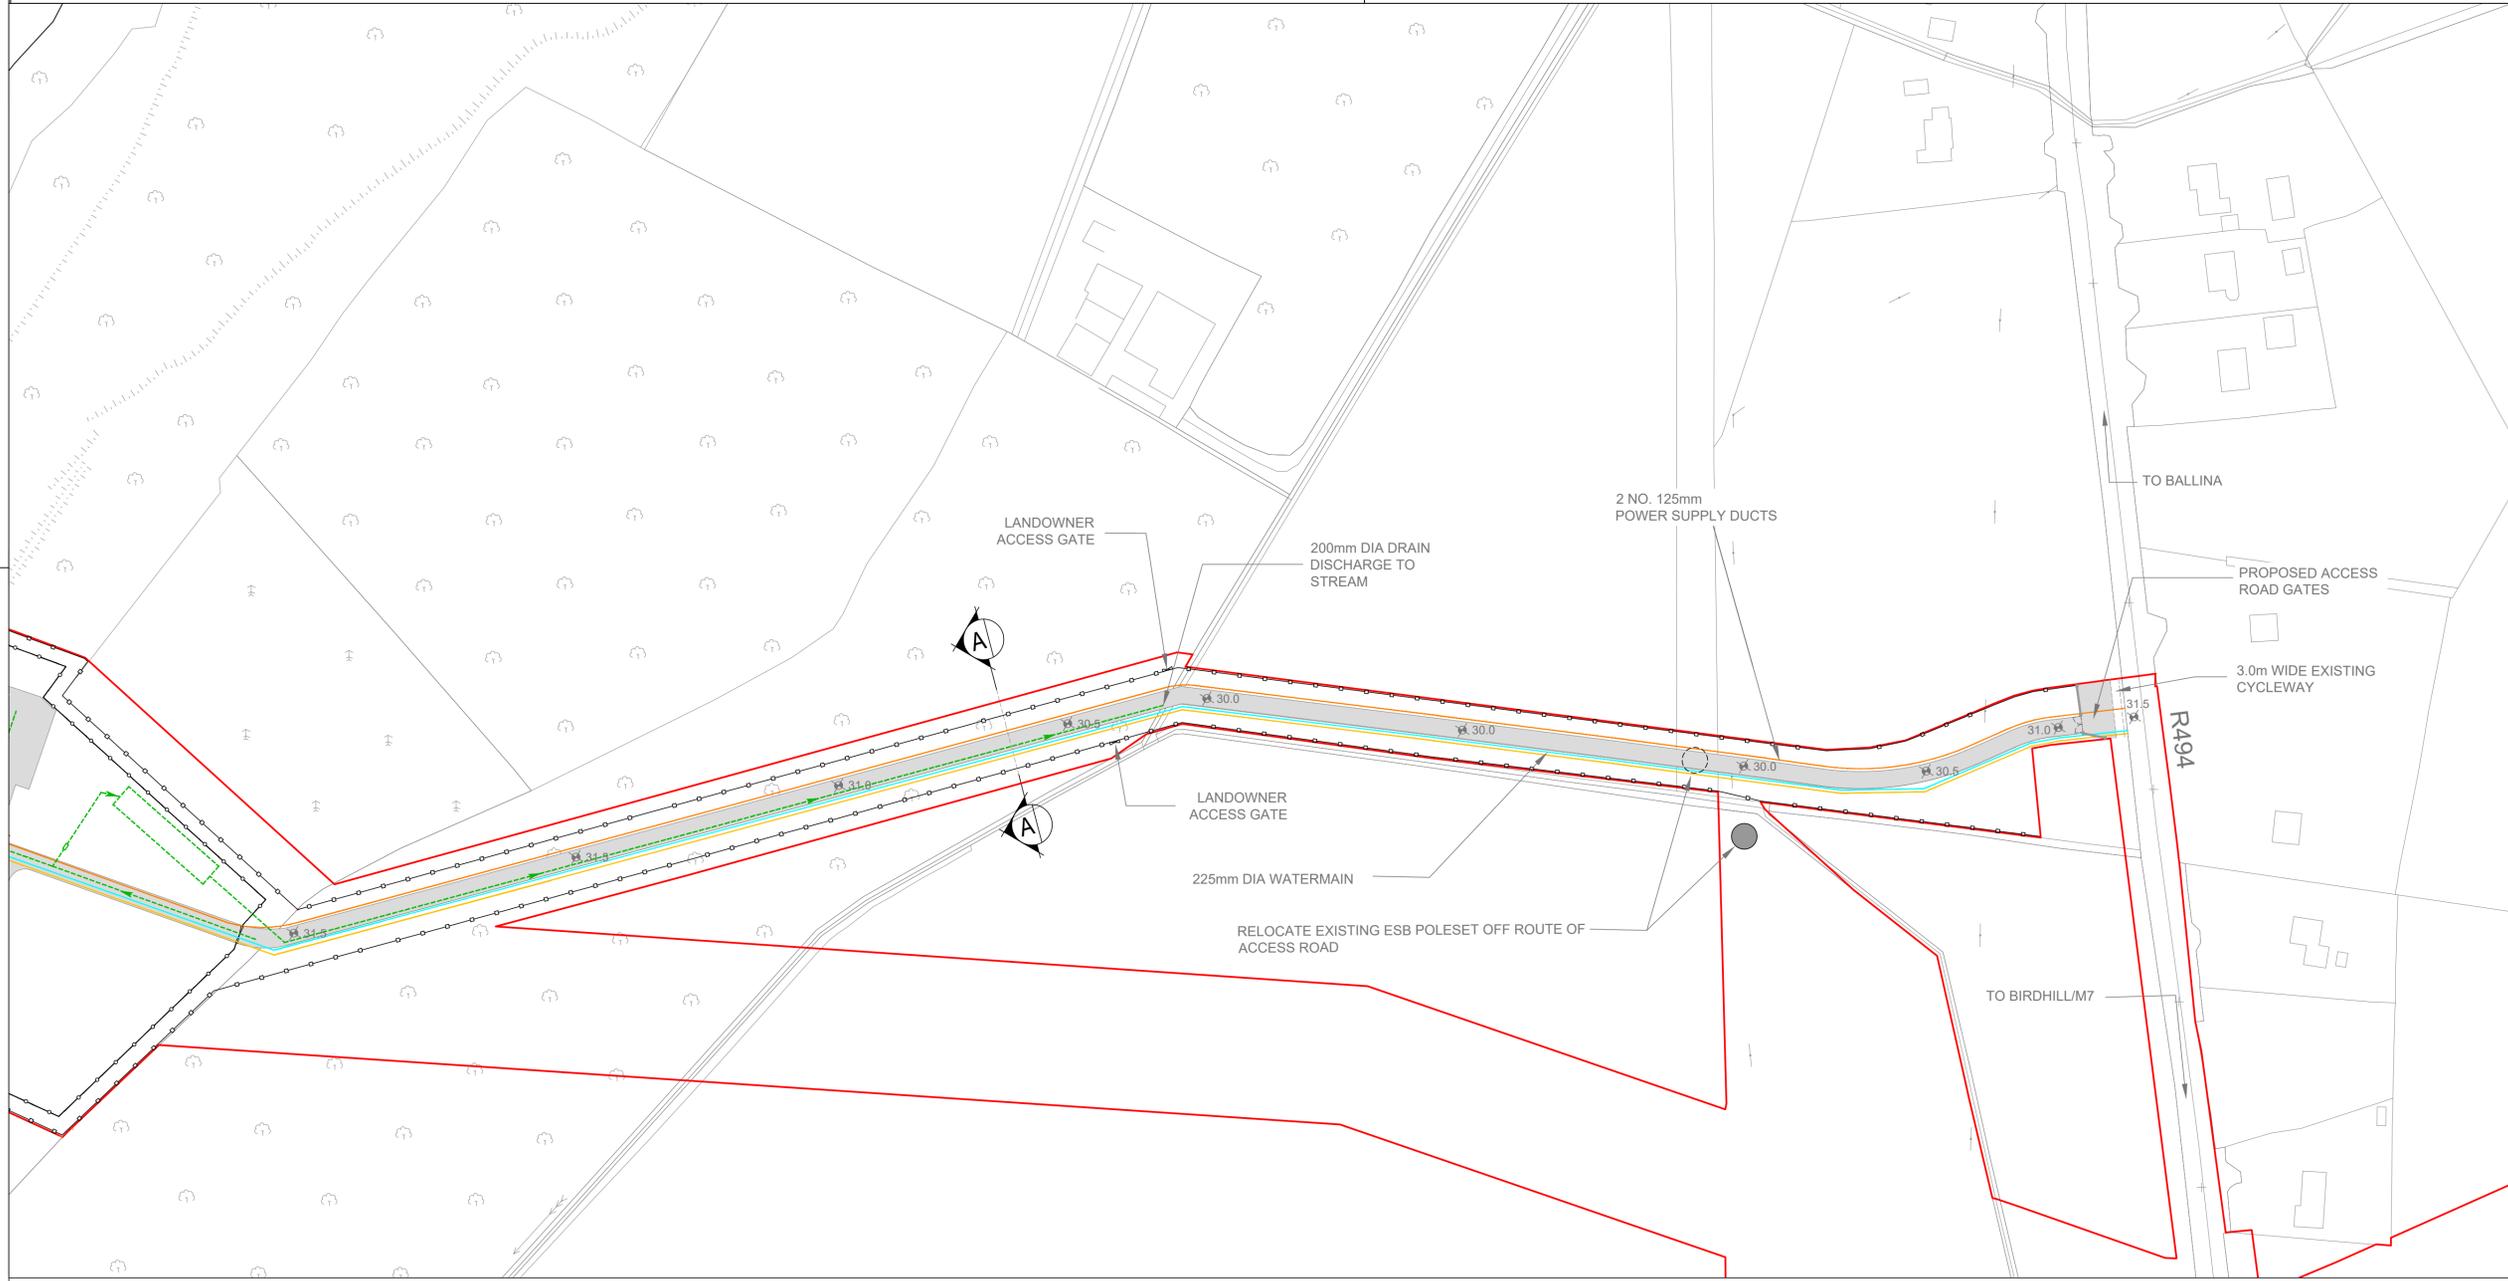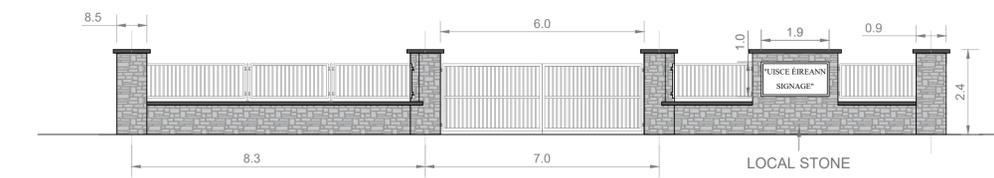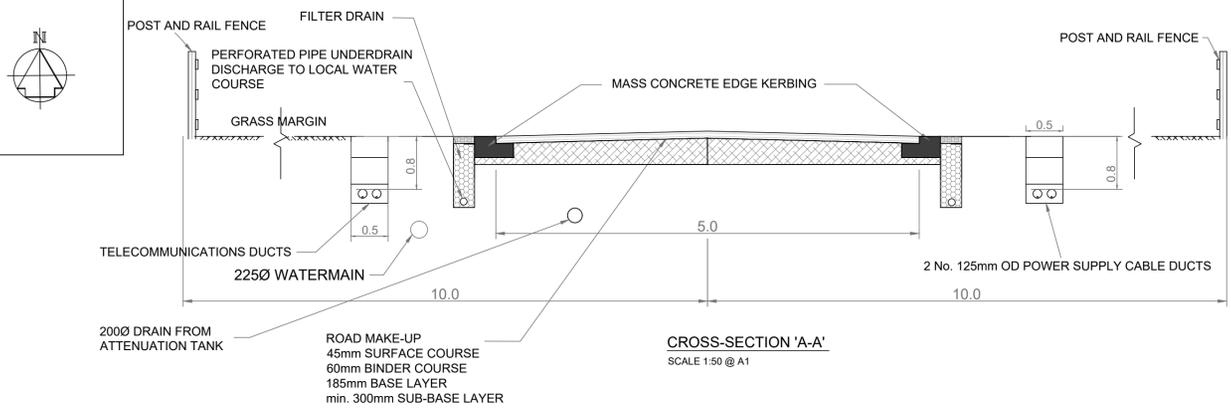

- PLANNING APPLICATION BOUNDARY
- 1.2m HIGH POST AND RAIL FENCE
- 2.4m HIGH PALADIN SITE SECURITY FENCE
- POWER SUPPLY
- TELECOMMUNICATIONS DUCTS
- 225mm Ø WATERMAIN
- 200mm Ø DRAIN FROM ATTENUATION TANK

F01	FINAL FOR PLANNING	EM	BG	BG	DEC 25
A01	FOR PLANNING	JM	BD	BD	FEB 22
Rev	Description	Drawn	Chk'd	App'd	Date

This drawing is the property of Irish Water and must not be copied or used for any purpose other than that for which it is supplied without the written consent of Irish Water.

Uisce Éireann
Irish Water

UISCE ÉIREANN
COLVILL HOUSE,
TALBOT STREET,
DUBLIN 1,
IRELAND

Tionscadal Soláthair Uisce
Water Supply Project

Call 1890 278 278
Int: 00 353 1 707 2828

Jacobs TOBIN

Originated By	Drawn By	Checked By	Approved By
DC	JM	BG	BG
Date	Date	Date	Date
01.12.22	01.12.25	01.12.25	01.12.25

Scale: AS SHOWN DO NOT SCALE

Project Title: WATER SUPPLY PROJECT EASTERN AND MIDLANDS REGION

Drawing Title: RAW WATER INTAKE AND PUMPING STATION AT PARTEEN BASIN ACCESS ROAD

Drawing Status: FINAL FOR PLANNING
Jacobs Tobin No. 32105801 Client No. 9318


Drawing No. 32105801-850-01020





- Notes:
- ALL DIMENSIONS ARE IN METRES AND ALL LEVELS ARE IN METRES AOD MALIN HEAD UNLESS OTHERWISE STATED.
 - THIS DRAWING IS FOR PLANNING PURPOSES ONLY.

 PLANNING APPLICATION BOUNDARY



TWL TOP WATER LEVEL
LWL LOW WATER LEVEL
IL INVERT LEVEL

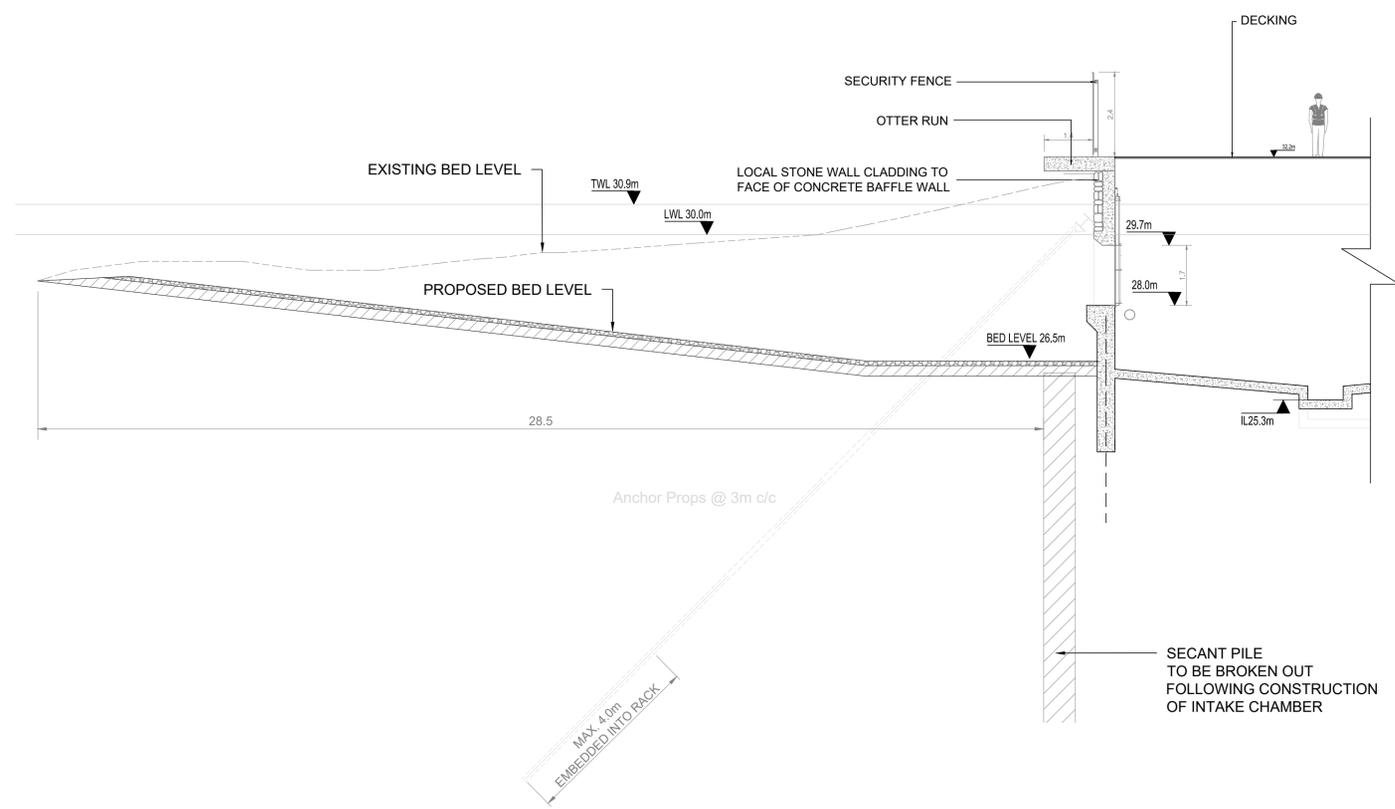


SECTION 'A'-'A'
SCALE 1:100

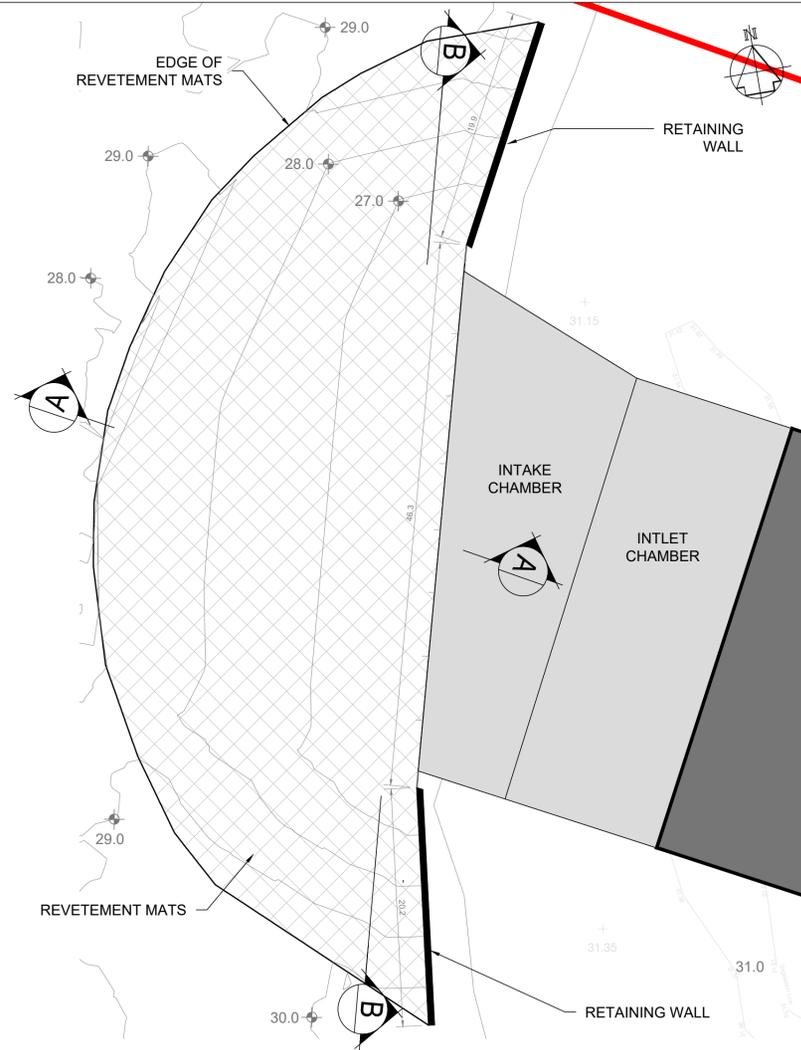 

PROPOSED LAYOUT PLAN
SCALE 1:300

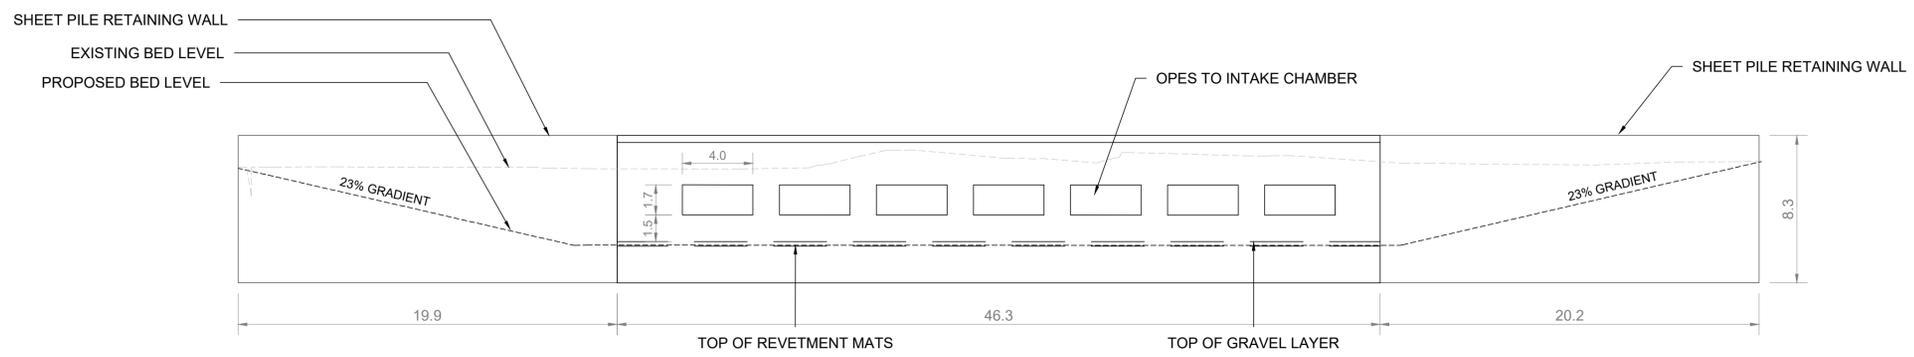 

ELEVATION 'B-B'
SCALE 1:200

 

F01	FINAL FOR PLANNING	EM	BG	BG	DEC 25
A01	FOR PLANNING	JM	BG	BG	FEB 25
Rev	Description	Drawn	Chk'd	App'd	Date

This drawing is the property of Irish Water and must not be copied or used for any purpose other than that for which it is supplied without the written consent of Irish Water.

Uisce Éireann
Irish Water

UISCE ÉIREANN
COLVILL HOUSE,
TALBOT STREET,
DUBLIN 1,
IRELAND

Tionscadal Soláthair Uisce
Water Supply Project

Call 1890 278 278
Int: 00 353 1 707 2828

Jacobs TOBIN

Originated By DC	Drawn By JM	Checked By BG	Approved By BG
Date 30.07.25	Date 01.12.25	Date 01.12.25	Date 01.12.25

Scale
AS SHOWN

Project Title
WATER SUPPLY PROJECT
EASTERN AND MIDLANDS REGION


Drawing Title
RAW WATER INTAKE AND PUMPING STATION
REPROFILING BED OF PARTEEN BASIN

Drawing Status
FINAL FOR PLANNING
Jacobs Tobin No. 32105801 Client No. 9318

Drawing No.
32105801-850-01021

- Notes:
- ALL DIMENSIONS ARE IN METRES AND ALL LEVELS ARE IN METRES AOD **MALIN HEAD** UNLESS OTHERWISE STATED
 - THIS DRAWING IS FOR PLANNING PURPOSES ONLY.

FGL FINISHED GROUND LEVEL
TWL TOP WATER LEVEL

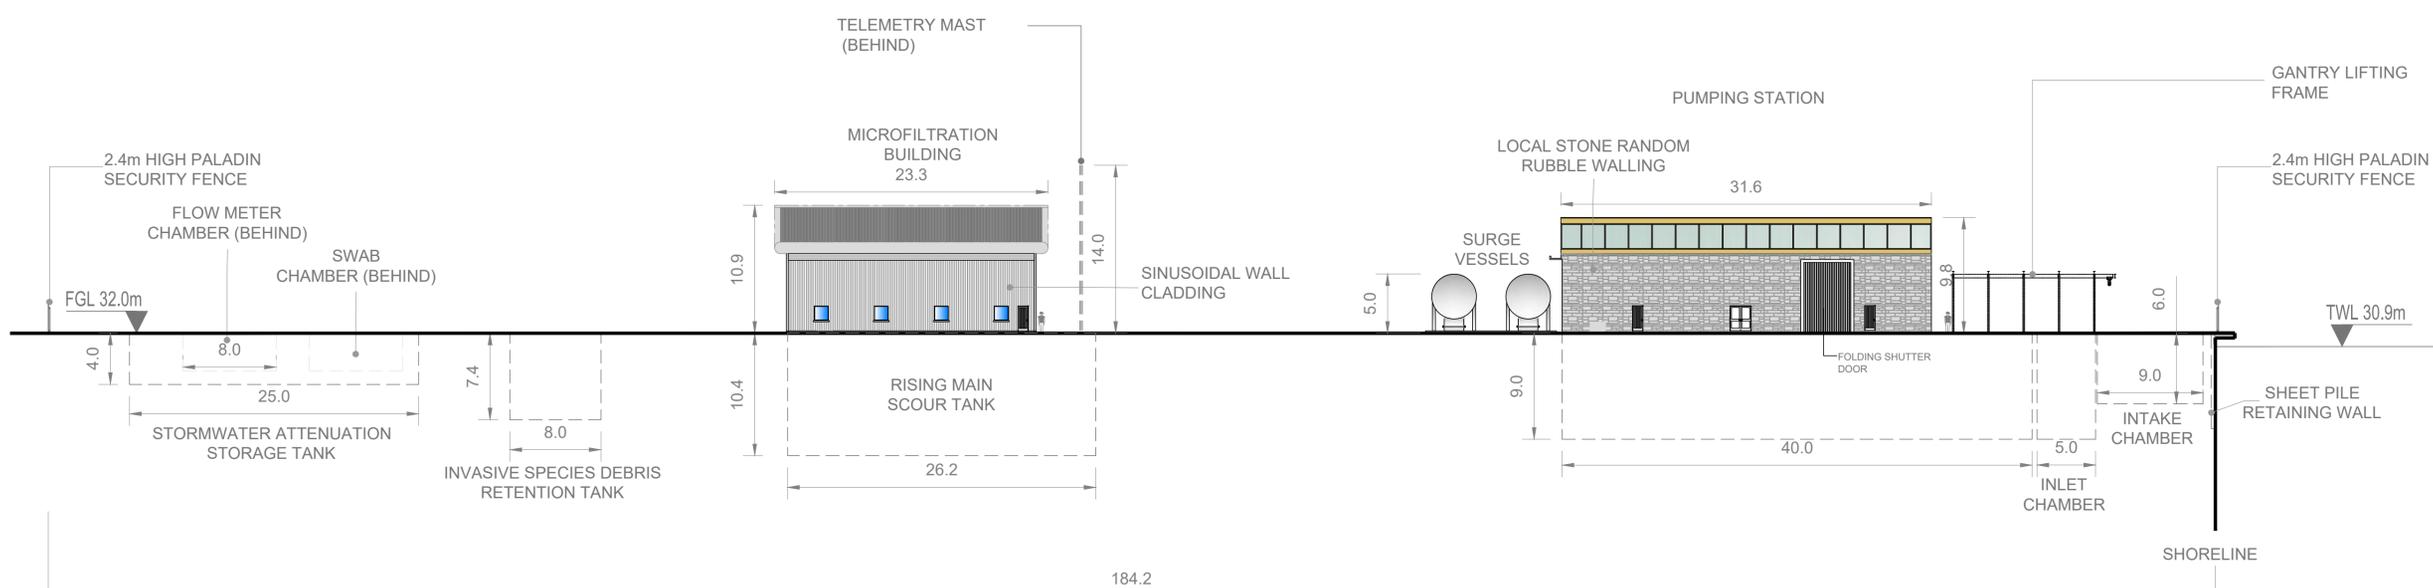

SITE WIDE ELEVATION (EAST TO WEST)
SCALE 1:300

F01	FINAL FOR PLANNING	EM	BG	BG	DEC 25
A01	FOR PLANNING	JM	BD	BD	FEB'22
Rev	Description	Drawn	Chk'd	App'd	Date

This drawing is the property of Irish Water and must not be copied or used for any purpose other than that for which it is supplied without the written consent of Irish Water.

Uisce Éireann
Irish Water

UISCE ÉIREANN
COLVILL HOUSE,
TALBOT STREET,
DUBLIN 1,
IRELAND

Tionscald Soláthair Uisce
Water Supply Project

Call 1890 278 278
Int: 00 353 1 707 2828

Jacobs TOBIN

Originated By	Drawn By	Checked By	Approved By
DC	JM	BG	BG
Date	Date	Date	Date
01.12.22	01.12.25	01.12.25	01.12.25

Scale
1:300 @ A1

Project Title
WATER SUPPLY PROJECT
EASTERN AND MIDLANDS REGION

Drawing Title
RAW WATER INTAKE AND PUMPNG STATION
SITEWIDE ELEVATIONS

Drawing Status: FINAL FOR PLANNING
Jacobs Tobin No. 32105801 Client No. 9318

Drawing No.
32105801-850-01022

