

Notes:

1. THIS DRAWING IS NOT TO BE SCALED. FIGURED DIMENSIONS ONLY TO BE TAKEN.
2. ALL DIMENSIONS ARE IN METRES AND ALL LEVELS ARE IN METRES AOD MALIN HEAD UNLESS OTHERWISE STATED.
3. THIS DRAWING IS FOR PLANNING PURPOSES ONLY.

LEGEND:

- PLANNING APPLICATION BOUNDARY
- INDICATIVE PERMANENT WAYLEAVE

PROPOSED:

- 2.4m HIGH PALISADE SITE SECURITY FENCE

OSI Sheet No's:  
 4046, 4105-A.

F02	FINAL FOR PLANNING	AP	MG	SW	Dec-25
F01	FINAL FOR PLANNING	AP	MG	SW	Dec-25
Rev	Description	Drawn	Chk'd	App'd	Date

This drawing is the property of Uisce Éireann and must not be copied or used for any purpose other than that for which it is supplied without the written consent of Uisce Éireann.



UISCE ÉIREANN  
 COLVILL HOUSE,  
 TALBOT STREET,  
 DUBLIN 1,  
 IRELAND  
 Call 1890 278 278  
 Int: 00 353 1 707 2828



Originated By MON	Drawn By AP	Checked By MG	Approved By SW
Date 21.09.23	Date 01.12.2025	Date 01.12.2025	Date 01.12.2025


Scale 1:2500 @ A1 FINAL



Project Title  
 WATER SUPPLY PROJECT  
 EASTERN AND MIDLANDS REGION

Drawing Title  
 BREAK PRESSURE TANK  
 SITE LOCATION PLAN

Drawing Status FINAL FOR PLANNING  
 Jacobs Tobin No. 32105801 Client No. 9318

 Drawing No.  
**32105801-850-03000**



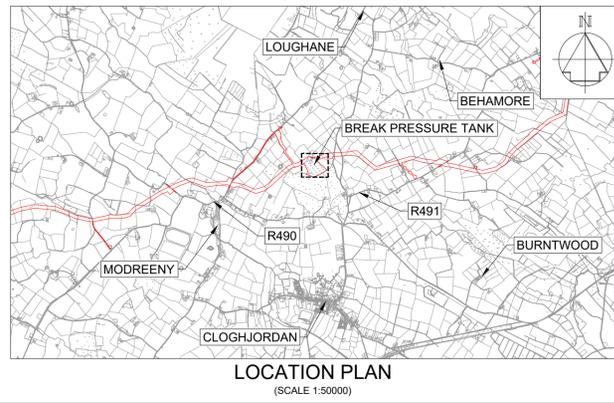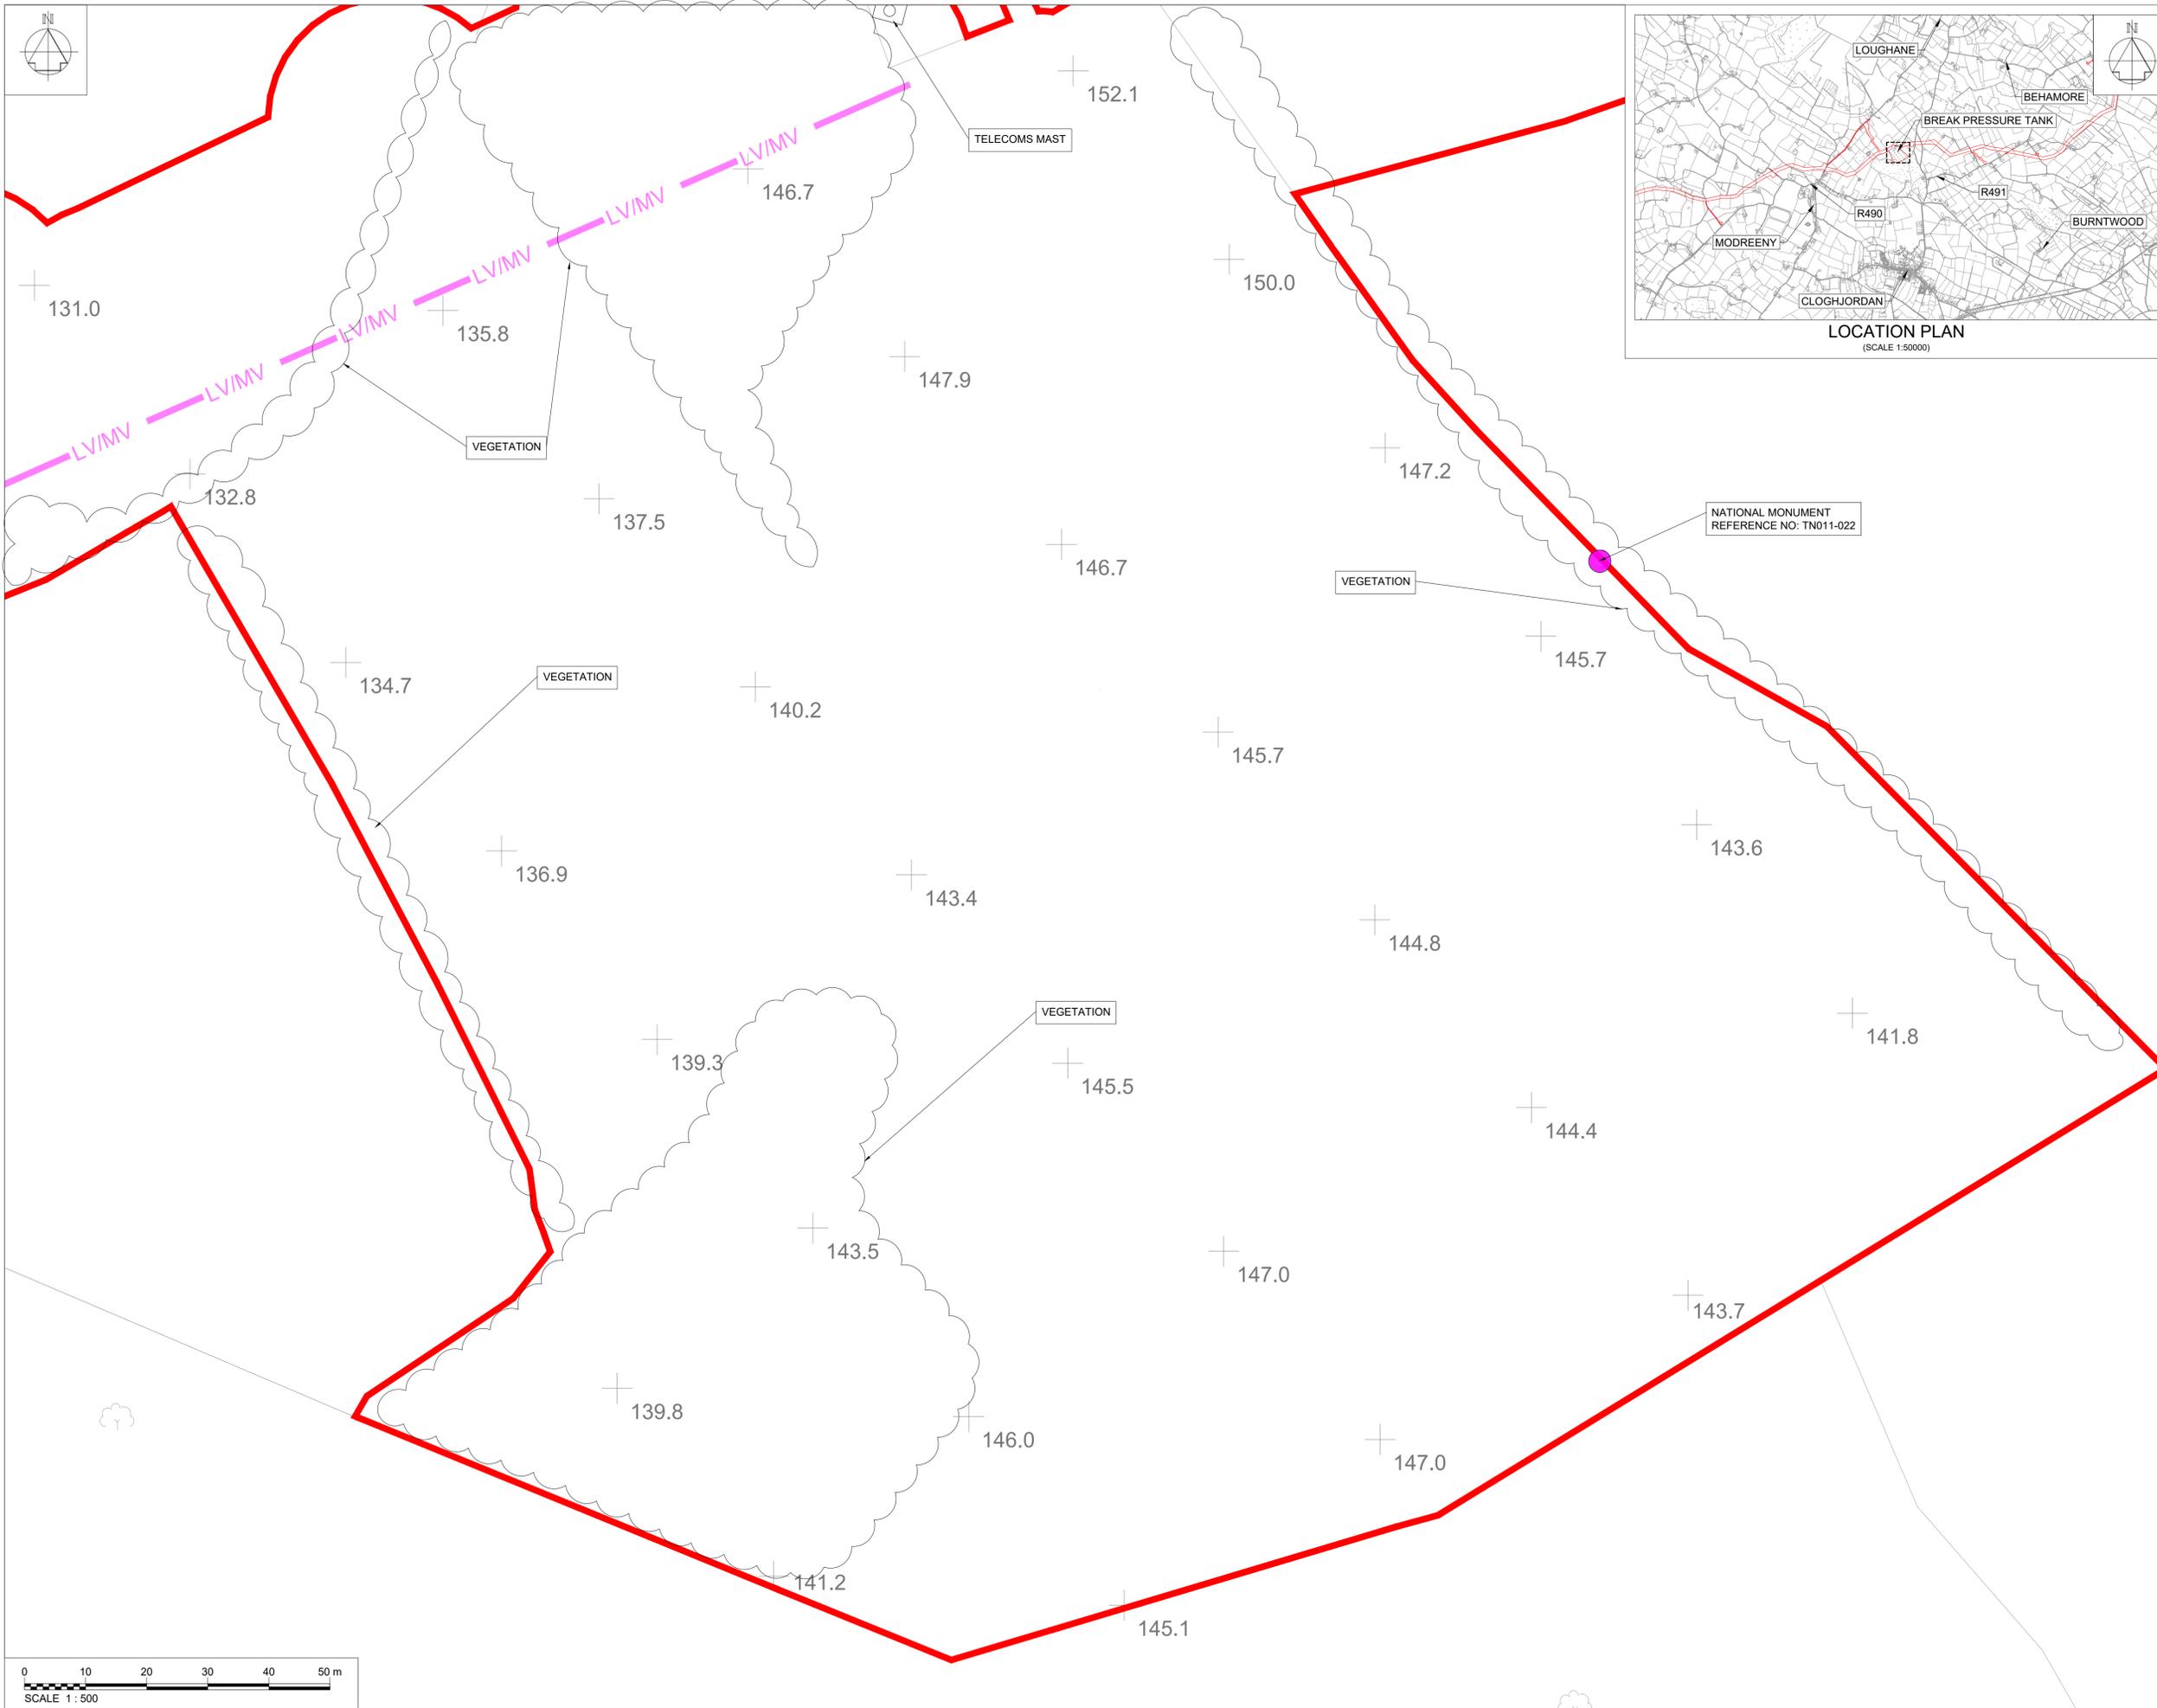

- Notes:
- THIS DRAWING IS NOT TO BE SCALED. FIGURED DIMENSIONS ONLY TO BE TAKEN.
  - ALL DIMENSIONS ARE IN METRES AND ALL LEVELS ARE IN METRES AOD MALIN HEAD UNLESS OTHERWISE STATED.

- LEGEND:
- PLANNING APPLICATION BOUNDARY
  - EXISTING: ELECTRIC OVERHEAD POWERLINE LOW/MEDIUM VOLTAGE
  - NATIONAL MONUMENT

OSI Sheet No's:  
415-A

F02	FINAL FOR PLANNING	AP	MG	SW	Dec 25
F01	FINAL FOR PLANNING	AP	MG	SW	Dec 25
Rev	Description	Drawn	Chk'd	App'd.	Date

This drawing is the property of Uisce Éireann and must not be copied or used for any purpose other than that for which it is supplied without the written consent of Uisce Éireann.

UISCE ÉIREANN  
COLVILL HOUSE,  
TALBOT STREET,  
DUBLIN 1,  
IRELAND  
Call 1890 278 278  
Int: 00 353 1 707 2828

# JACOBS TOBIN

Originated By MCN	Drawn By AP	Checked By MG	Approved By SW
Date 21.09.23	Date 01.12.2025	Date 01.12.2025	Date 01.12.2025

 
Scale: 1:500 @ A1 **FINAL**


Project Title  
**WATER SUPPLY PROJECT  
EASTERN AND MIDLANDS REGION**

Drawing Title  
**BREAK PRESSURE TANK  
EXISTING SITE LAYOUT**

Drawing Status: FINAL FOR PLANNING  
Jacobs Tobin No. 32105801 Client No. 9318

Drawing No.  
**32105801-850-03001**



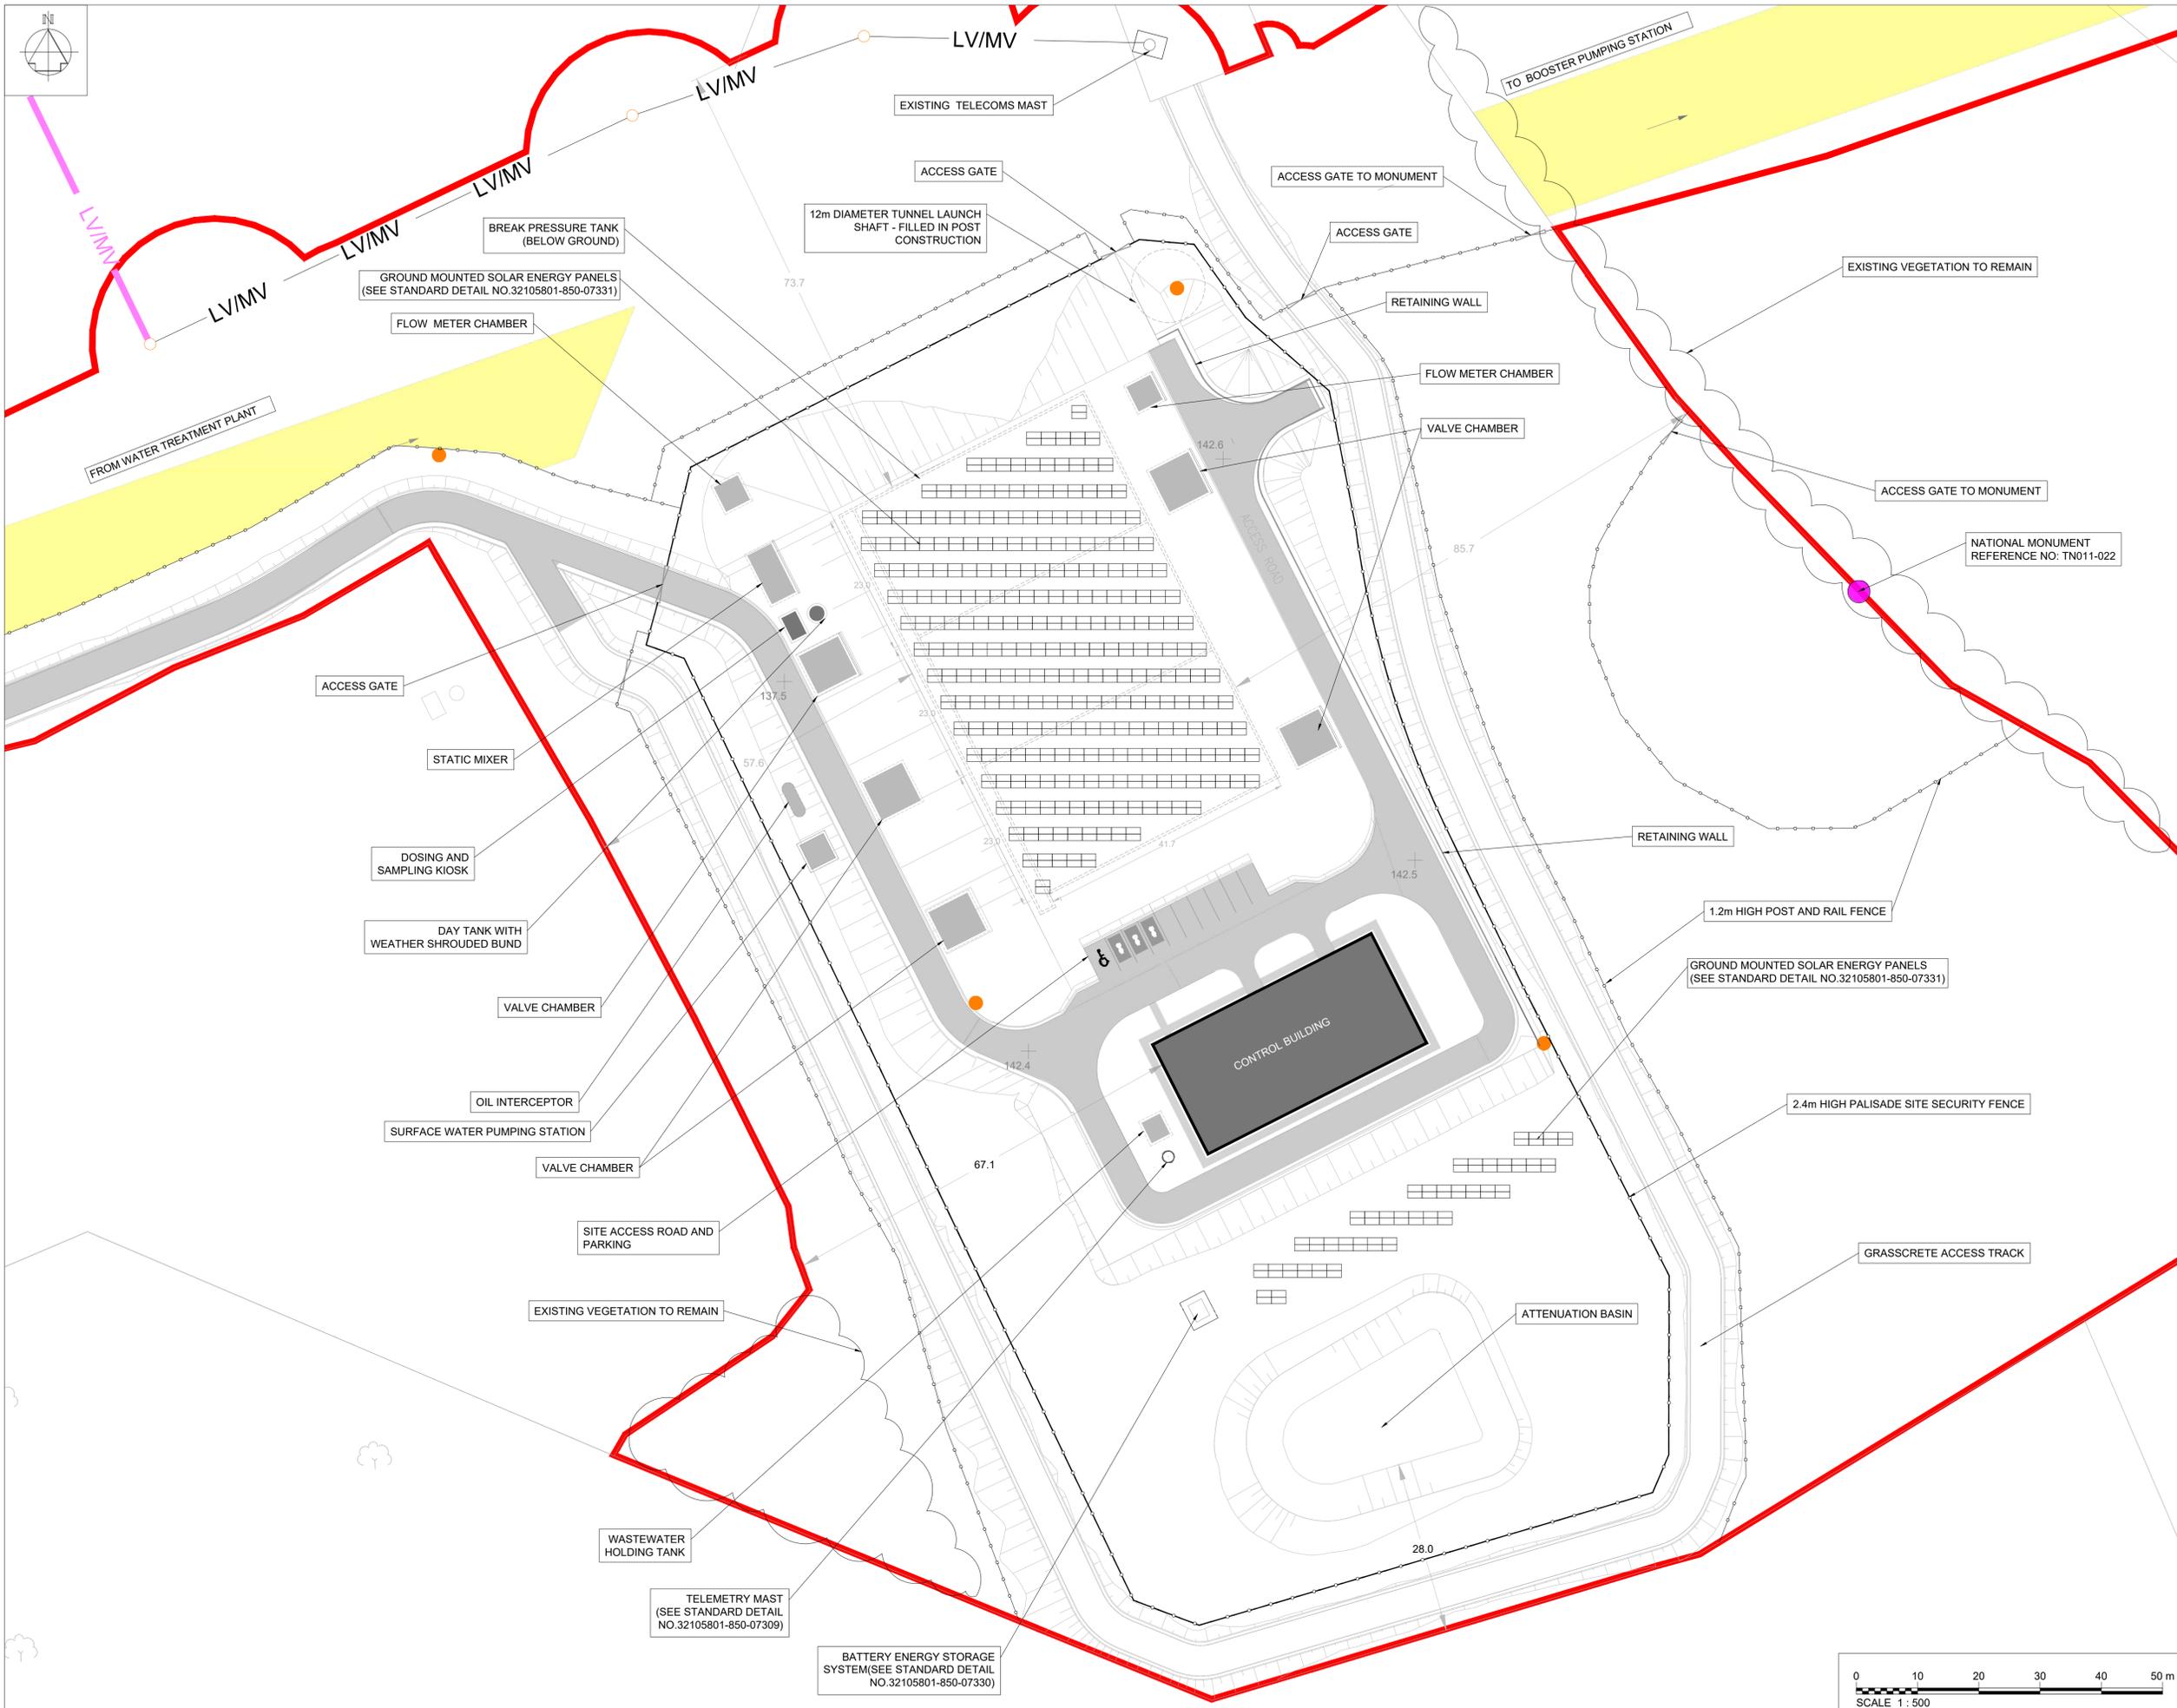

Notes:  
 1. THIS DRAWING IS NOT TO BE SCALED. FIGURED DIMENSIONS ONLY TO BE TAKEN  
 2. ALL DIMENSIONS ARE IN METRES AND ALL LEVELS ARE mAOD MALIN HEAD UNLESS OTHERWISE STATED.  
 3. THE PIPELINE HORIZONTAL AND VERTICAL ALIGNMENTS ARE SUBJECT TO FURTHER DESIGN DEVELOPMENT. ANY CHANGES WILL BE SUBJECT TO THE LIMITS AND CONDITIONS DETAILED IN THE PLANNING SUBMISSION.

- LEGEND:
- PLANNING APPLICATION BOUNDARY
  - INDICATIVE PERMANENT WAYLEAVE
- EXISTING:
- NATIONAL MONUMENT
  - ELECTRIC OVERHEAD POWERLINE. LOW/MEDIUM VOLTAGE
- PROPOSED:
- 1.2m HIGH POST AND RAIL FENCE
  - 2.4m HIGH PALISADE SITE SECURITY FENCE
  - ROAD / HARDSTAND SURFACE
  - BUILDING
  - BELOW GROUND STRUCTURES
  - ➔ EV CHARGING POINT
  - ♿ DISABLED PARKING SPACE
  - SOLAR ENERGY PANELS
  - CCTV DROP DOWN POLE
  - LV/MV ELECTRIC OVERHEAD POWERLINES
  - POWER POLES

OSI Sheet No's:  
415-A

F02	FINAL FOR PLANNING	AP	MG	SW	Dec 25
F01	FINAL FOR PLANNING	AP	MG	SW	Dec 25
Rev	Description	Drawn	Chk'd	App'd.	Date

This drawing is the property of Uisce Éireann and must not be copied or used for any purpose other than that for which it is supplied without the written consent of Uisce Éireann.

**Uisce Éireann**  
Irish Water

**Tionscadal Soláthair Uisce**  
Water Supply Project

UISCE ÉIREANN  
COLVILL HOUSE,  
TALBOT STREET,  
DUBLIN 1,  
IRELAND

Call 1890 278 278  
Int: 00 353 1 707 2828

# JACOBS TOBIN

Originated By DM	Drawn By AP	Checked By MG	Approved By SW
Date 19.07.19	Date 01.12.2025	Date 01.12.2025	Date 01.12.2025
Scale 1:500 @ A1			FINAL

Project Title  
WATER SUPPLY PROJECT  
EASTERN AND MIDLANDS REGION


Drawing Title  
BREAK PRESSURE TANK  
PROPOSED SITE LAYOUT PLAN

Drawing Status  
FINAL FOR PLANNING  
Jacobs Tobin No. 32105801 Client No. 9318


Drawing No.  
32105801-850-03003




- Notes:
1. THIS DRAWING IS NOT TO BE SCALED. FIGURED DIMENSIONS ONLY TO BE TAKEN
  2. ALL DIMENSIONS ARE IN METRES AND ALL LEVELS IN METRES UNLESS OTHERWISE STATED.
  3. THIS DRAWING IS FOR PLANNING PURPOSES ONLY

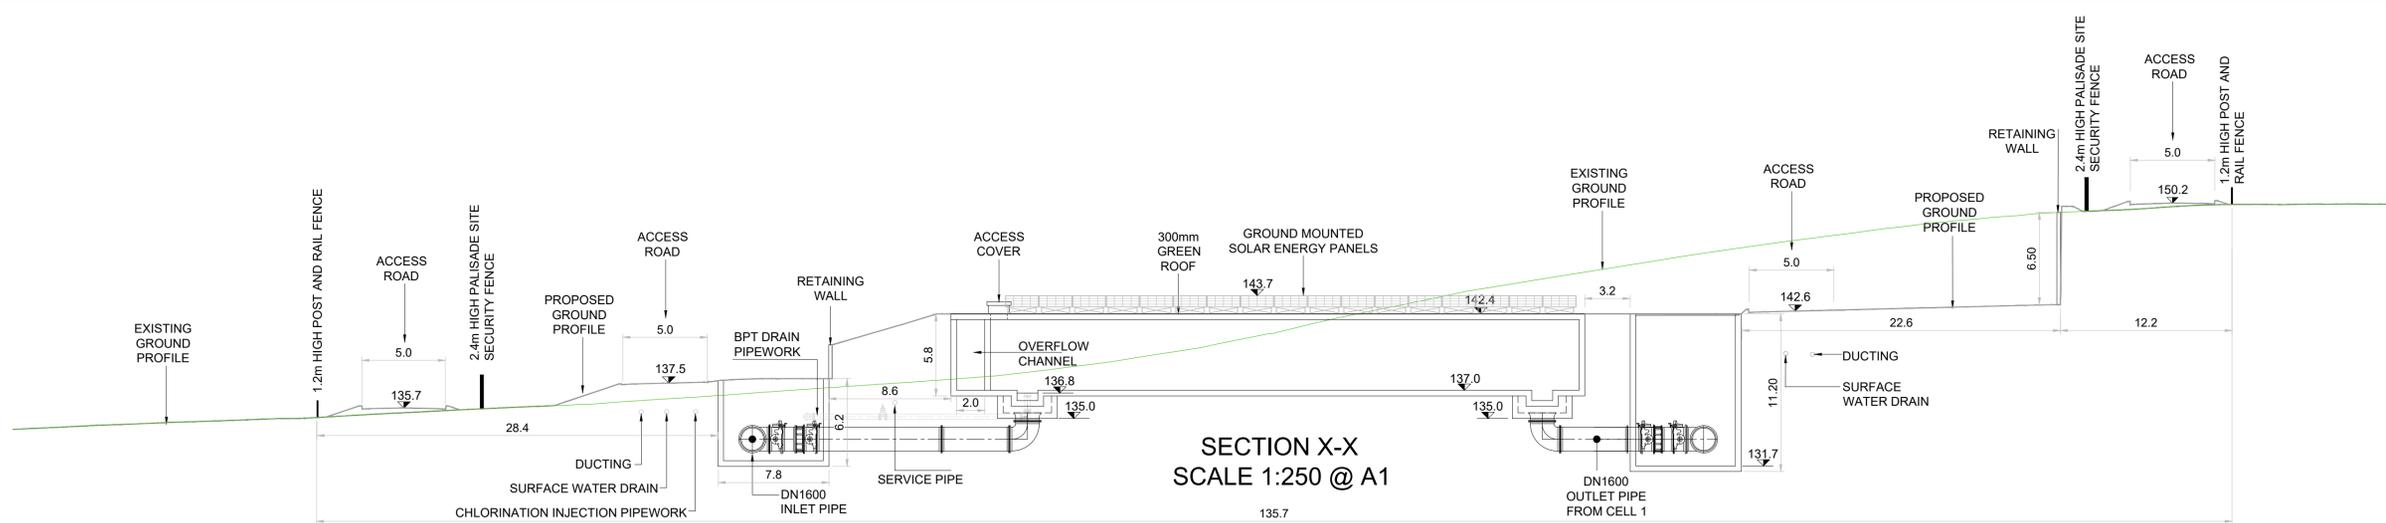


**SECTION X-X**  
SCALE 1:250 @ A1

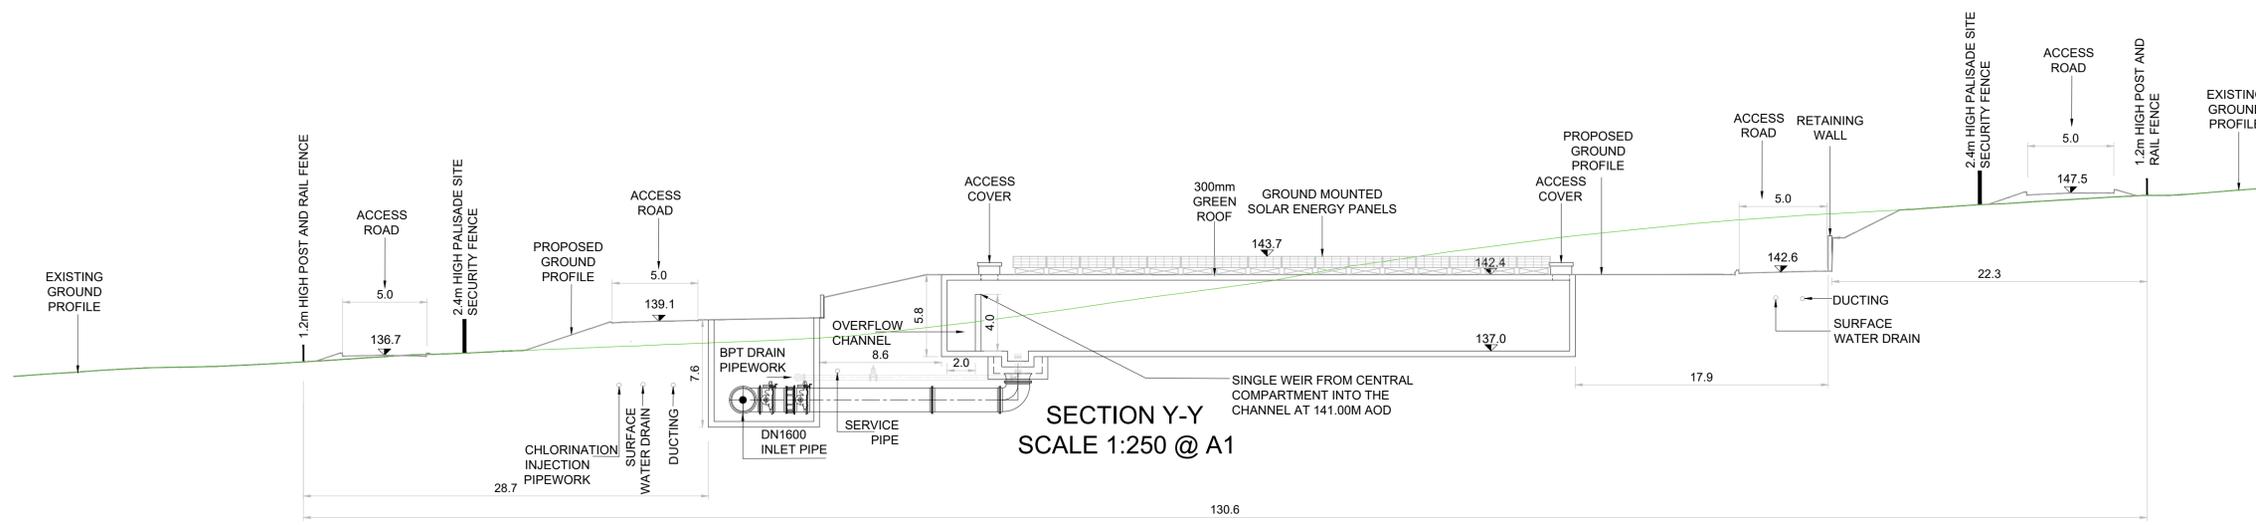


**SECTION Y-Y**  
SCALE 1:250 @ A1

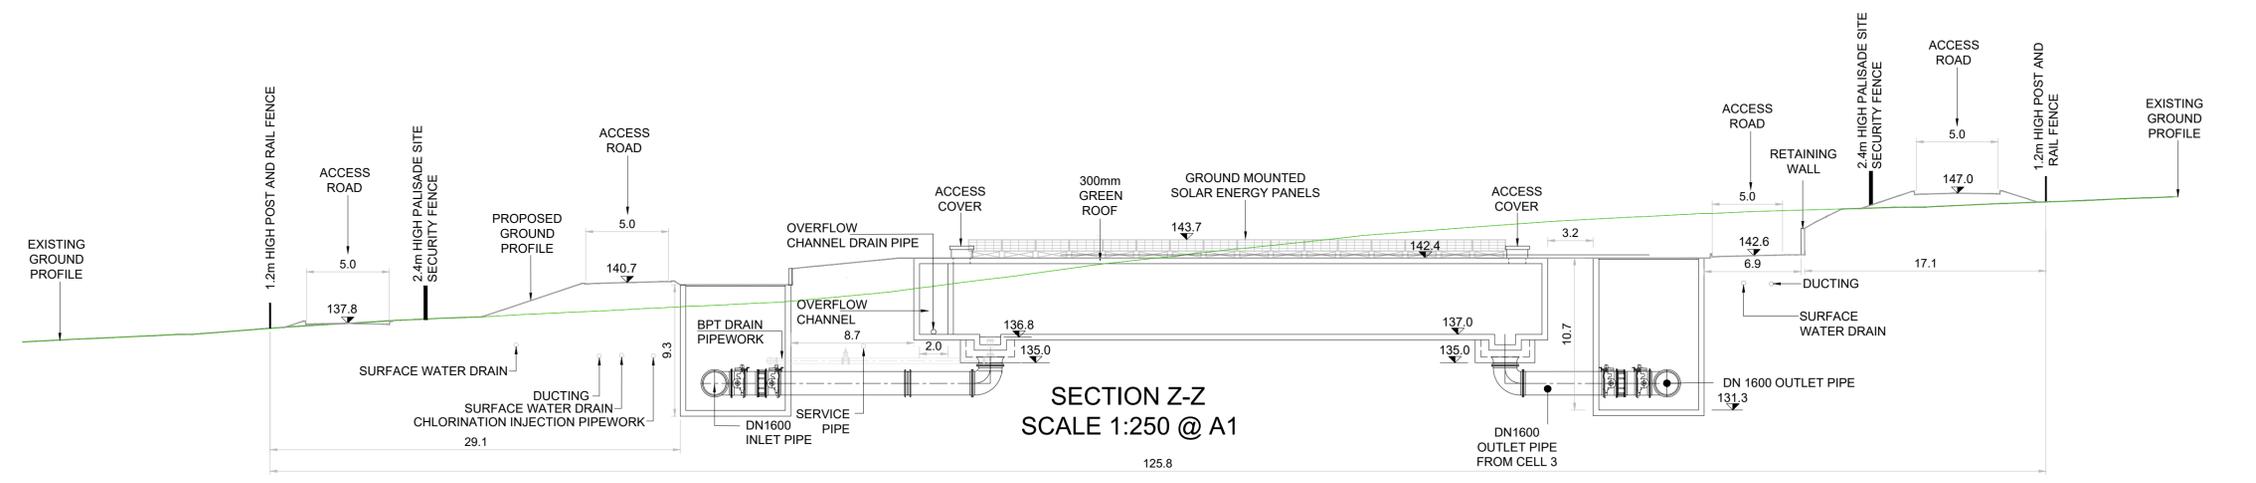

**SECTION Z-Z**  
SCALE 1:250 @ A1

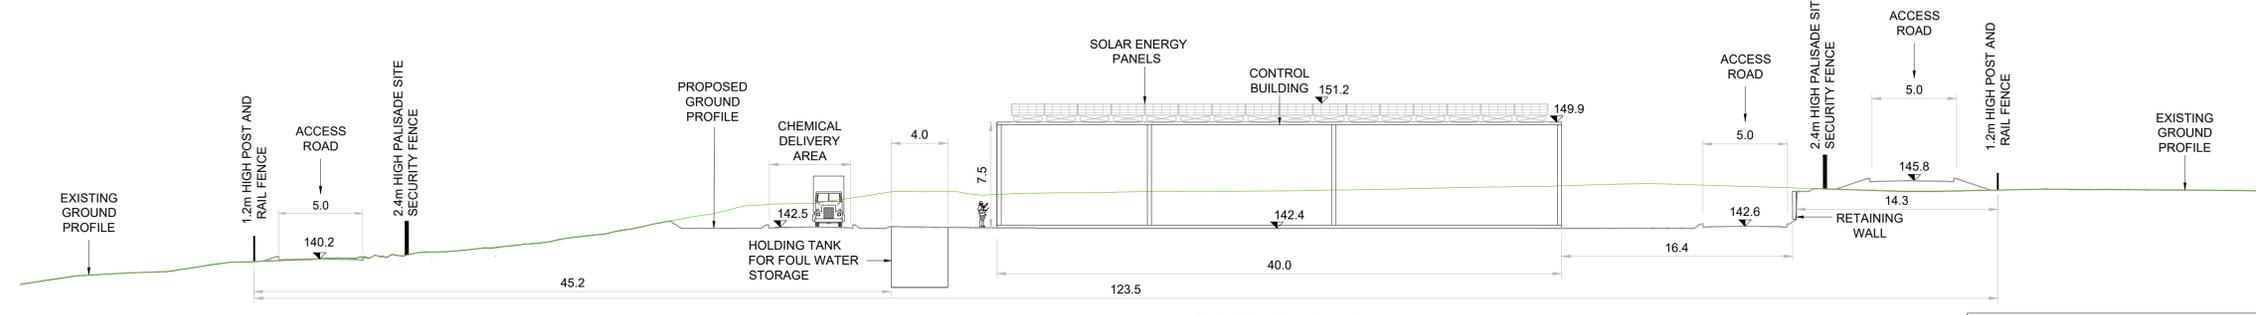

**SECTION Z1-Z1**  
SCALE 1:250 @ A1

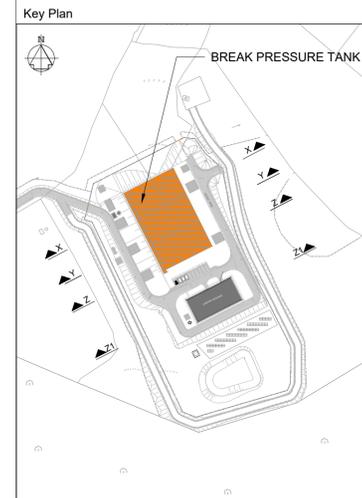

- LEGEND:
- EXISTING: GROUND PROFILE
  - PROPOSED: GROUND PROFILE

F02	FINAL FOR PLANNING	AP	MG	SW	Dec. 25
F01	FINAL FOR PLANNING	AP	MG	SW	Dec. 25
Rev	Description	Drawn	Chk'd	App'd.	Date

This drawing is the property of Uisce Éireann and must not be copied or used for any purpose other than that for which it is supplied without the written consent of Uisce Éireann.

Uisce ÉIREANN  
COLVILL HOUSE,  
TALBOT STREET,  
DUBLIN 1,  
IRELAND

Call 1890 278 278  
Int: 00 353 1 707 2828

**JACOBS TOBIN**

Originated By	Drawn By	Checked By	Approved By
DM	AP	MG	SW
Date	Date	Date	Date
19.07.17	01.12.2025	01.12.2025	01.12.2025

Scale: 1:250 @ A1  
Project Title: **FINAL**

Project Title: WATER SUPPLY PROJECT  
EASTERN AND MIDLANDS REGION

Drawing Title: BREAK PRESSURE TANK  
PROPOSED CROSS SECTIONS  
SHEET 01


Drawing Status: FINAL FOR PLANNING  
Jacobs Tobin No. 32105801 Client No. 9318

Drawing No. 32105801-850-03004



- Notes:
1. THIS DRAWING IS NOT TO BE SCALED. FIGURED DIMENSIONS ONLY TO BE TAKEN
  2. ALL DIMENSIONS ARE IN METRES AND ALL LEVELS IN METRES UNLESS OTHERWISE STATED.
  3. THIS DRAWING IS FOR PLANNING PURPOSES ONLY

Key Plan

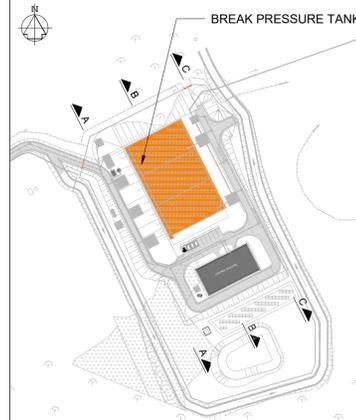

- LEGEND:
- EXISTING: — GROUND PROFILE
  - PROPOSED: — GROUND PROFILE

F02	FINAL FOR PLANNING	AP	MG	SW	Dec.25
F01	FINAL FOR PLANNING	AP	MG	SW	Dec.25
Rev	Description	Drawn	Chk'd	App'd	Date

This drawing is the property of Uisce Éireann and must not be copied or used for any purpose other than that for which it is supplied without the written consent of Uisce Éireann.

**Uisce Éireann**  
Irish Water

**Tionscadal Soláthair Uisce**  
Water Supply Project

UISCE ÉIREANN  
COLVILL HOUSE,  
DUBLIN 1,  
IRELAND

Call 1890 278 278  
Int: 00 353 1 707 2828

**JACOBS TOBIN**

Originated By DM	Drawn By AP	Checked By MG	Approved By SW
Date 19.07.17	Date 01.12.2025	Date 01.12.2025	Date 01.12.2025


Scale: 1:250 @ A1 **FINAL**

Project Title  
**WATER SUPPLY PROJECT  
EASTERN AND MIDLANDS REGION**


Drawing Title  
**BREAK PRESSURE TANK  
PROPOSED CROSS SECTIONS  
SHEET 02**

Drawing Status: FINAL FOR PLANNING  
Jacobs Tobin No. 32105801 Client No. 9318


Drawing No.  
**32105801-850-03006**

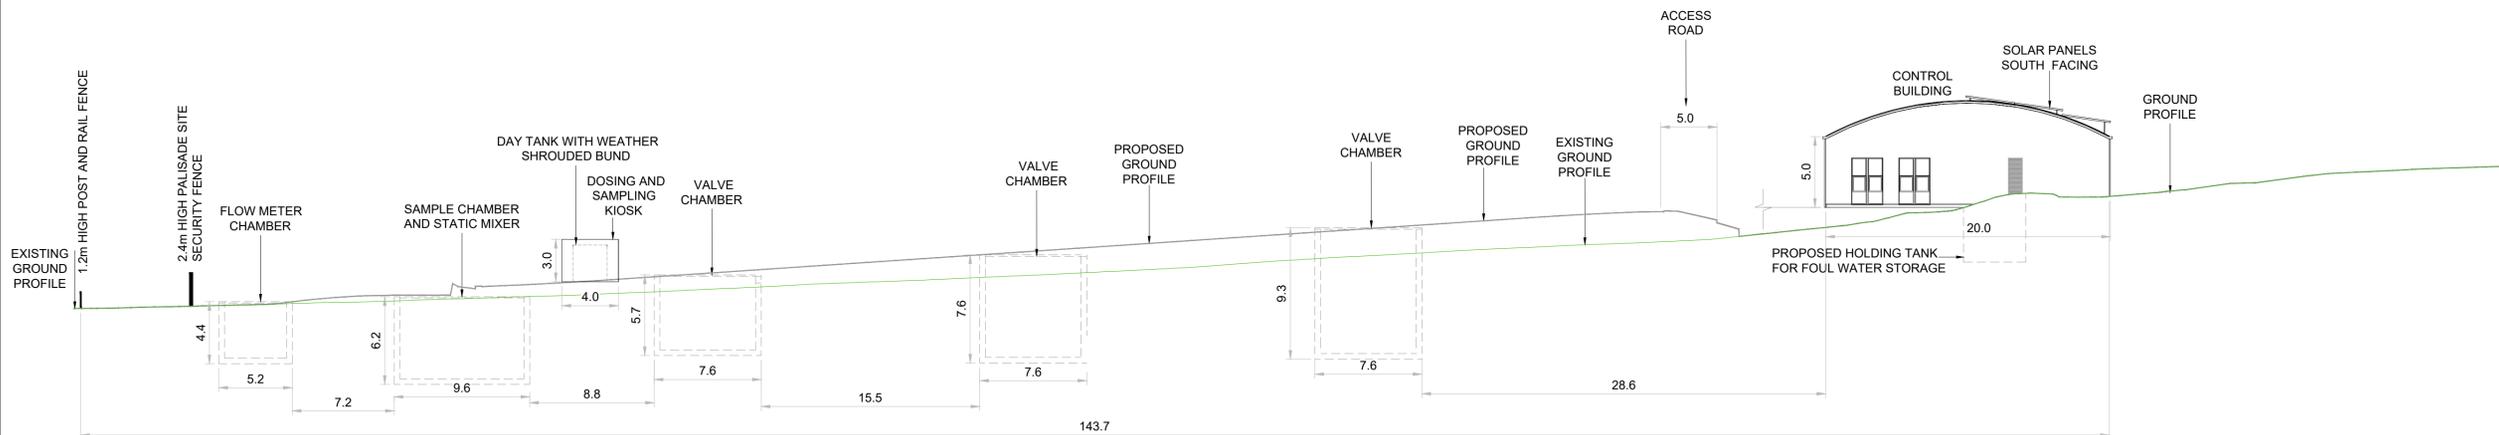

**SECTION A-A**  
SCALE 1:250 @ A1

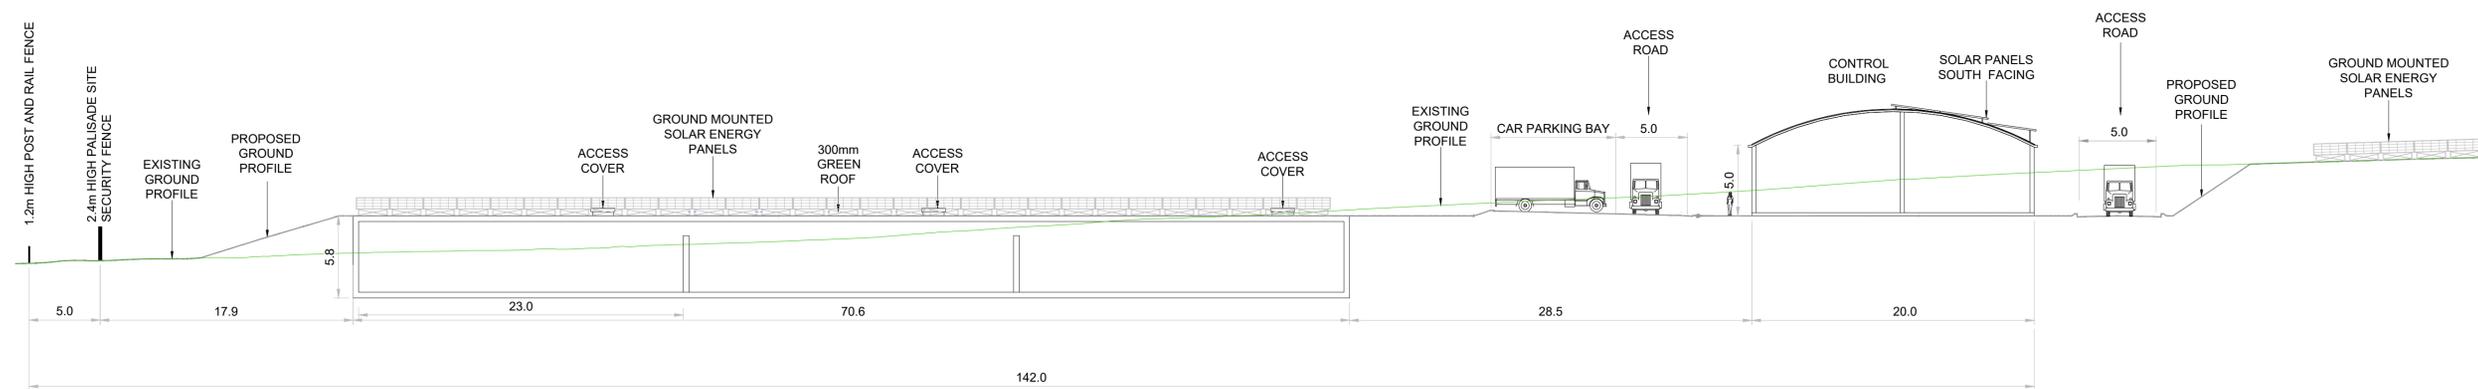

**SECTION B-B**  
SCALE 1:250 @ A1

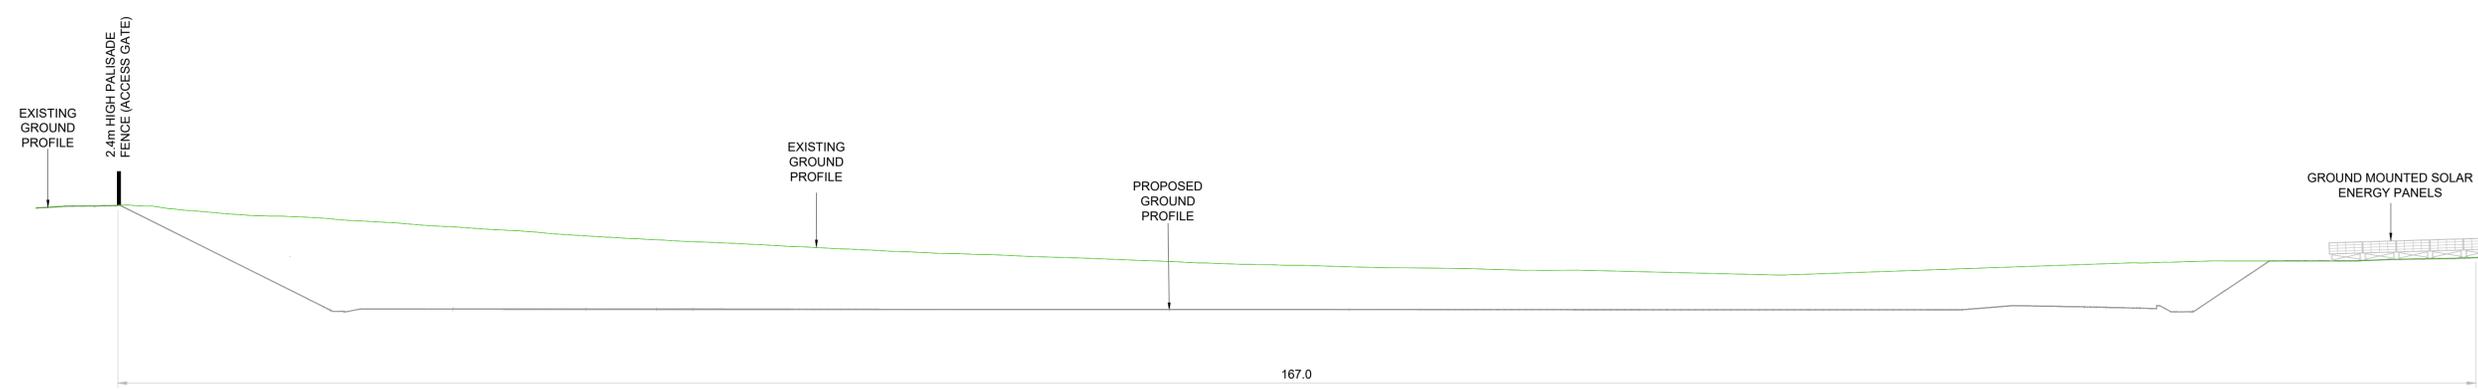

**SECTION C-C**  
SCALE 1:250 @ A1










- Notes:
1. ALL DIMENSIONS ARE IN METRES AND ALL LEVELS ARE IN METRES AOD MALIN HEAD UNLESS OTHERWISE STATED.
  2. THE PIPELINE HORIZONTAL ALIGNMENTS ARE SUBJECT TO FURTHER DEVELOPMENT. ANY CHANGES WILL BE SUBJECT TO THE LIMITS AND CONDITIONS DETAILED IN THE PLANNING SUBMISSION.
  3. THIS DRAWING IS FOR PLANNING PURPOSES ONLY.

- LEGEND:
- PLANNING APPLICATION BOUNDARY
  - INDICATIVE PERMANENT WAYLEAVE


- PROPOSED:
- 1.2m HIGH POST AND RAIL FENCE
  - PIPELINE CENTRELINE
  - ROAD SURFACE
  - CCTV DROP DOWN POLE
  - SURFACE WATER FILTER DRAIN

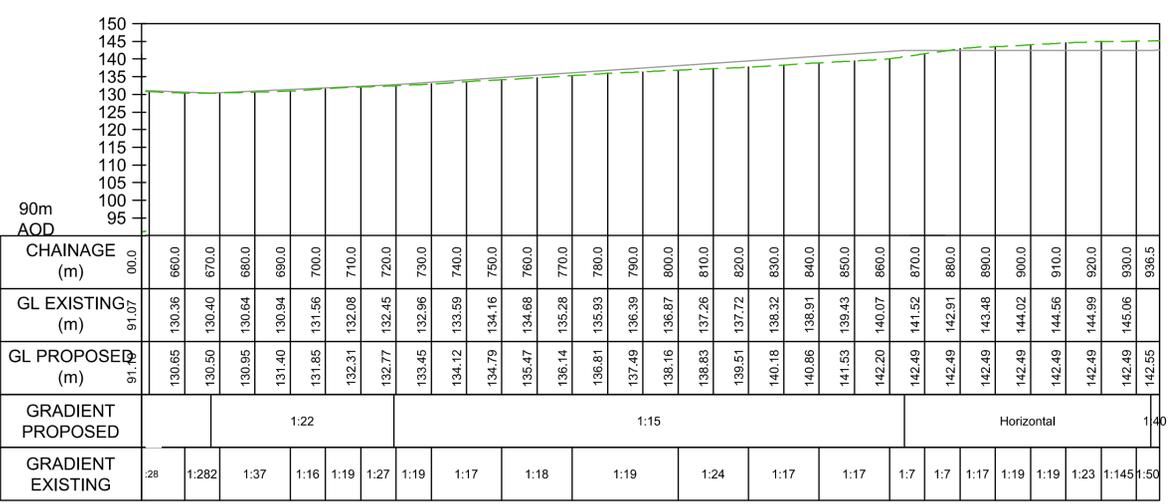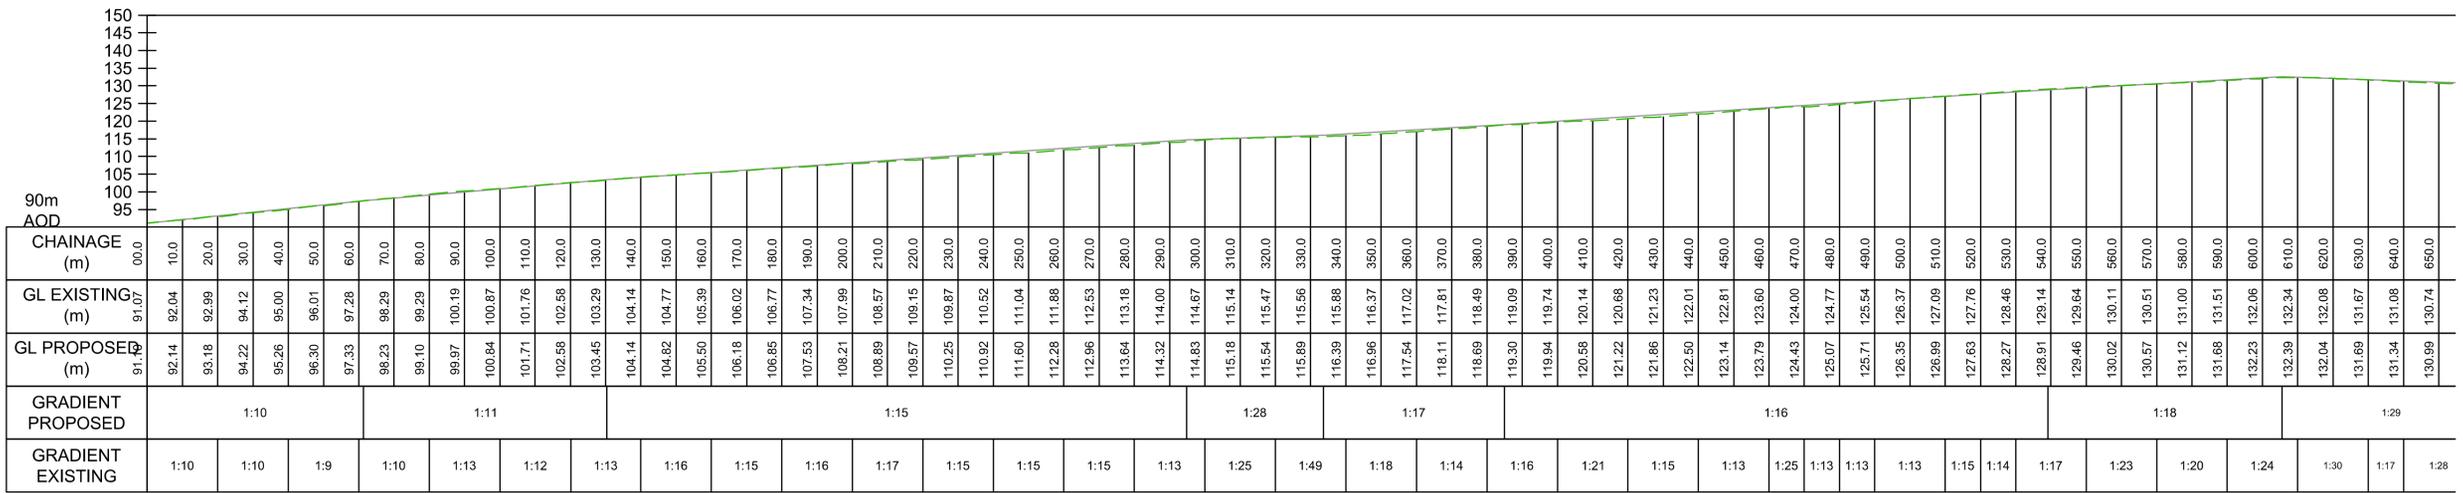

--- EXISTING GROUND PROFILE  
— PROPOSED GROUND PROFILE

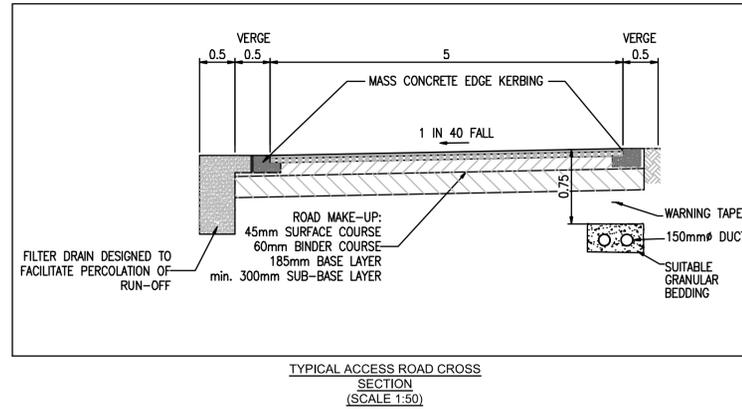

 TYPICAL ACCESS ROAD CROSS SECTION (SCALE 1:50)



OSI Sheet No's:  
4046, 4105-A

F02	FINAL FOR PLANNING	AP	MG	SW	Dec:25
F01	FINAL FOR PLANNING	AP	MG	SW	Dec:25
Rev	Description	Drawn	Chk'd	App'd	Date

**Uisce Éireann**  
Irish Water

**Tionscadal Soláthair Uisce**  
Water Supply Project

UISCE ÉIREANN  
COLVILL HOUSE,  
TALBOT STREET,  
DUBLIN 1,  
IRELAND

Call 1890 278 278  
Int: 00 353 1 707 2828

**JACOBS TOBIN**

Originated By	DM	Drawn By	AP	Checked By	MG	Approved By	SW
Date	29.08.17	Date	01.12.2025	Date	01.12.2025	Date	01.12.2025

Scale: 1:1000 @ A1  
Project Title: WATER SUPPLY PROJECT EASTERN AND MIDLANDS REGION




Drawing Title: BREAK PRESSURE TANK PROPOSED ACCESS ROAD SHEET 02

Drawing Status: FINAL FOR PLANNING  
Drawing No.: 32105801



Client No.: 9318  
Drawing No.: 32105801-850-03009

- Notes:
1. ALL DIMENSIONS ARE IN METRES AND ALL LEVELS ARE IN METRES AOD. MALIN HEAD UNLESS OTHERWISE STATED.
  2. THE PIPELINE HORIZONTAL ALIGNMENTS ARE SUBJECT TO FURTHER DEVELOPMENT. ANY CHANGES WILL BE SUBJECT TO THE LIMITS AND CONDITIONS DETAILED IN THE PLANNING SUBMISSION.
  3. THIS DRAWING IS FOR PLANNING PURPOSES ONLY.

- LEGEND:
- PLANNING APPLICATION BOUNDARY
  - INDICATIVE PERMANENT WAYLEAVE
- PROPOSED:
- 2.4m HIGH PALISADE SITE SECURITY FENCE
  - 1.2m HIGH POST AND RAIL FENCE
  - PIPELINE CENTRELINE
  - ROAD / HARDSTAND SURFACE
  - BUILDING
  - BELOW GROUND STRUCTURES
  - SOLAR ENERGY PANELS
  - CCTV DROP DOWN POLE
  - SURFACE WATER FILTER DRAIN

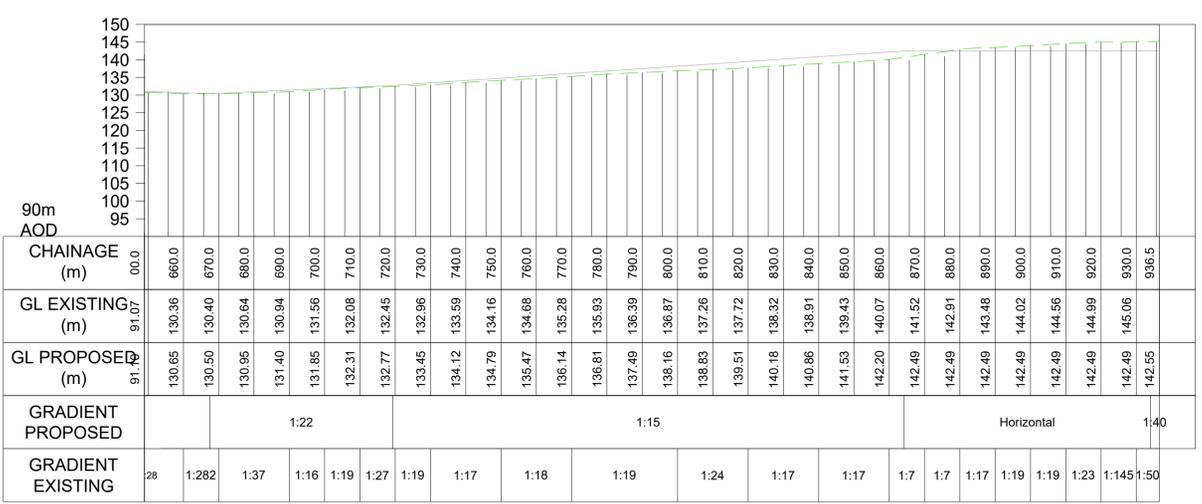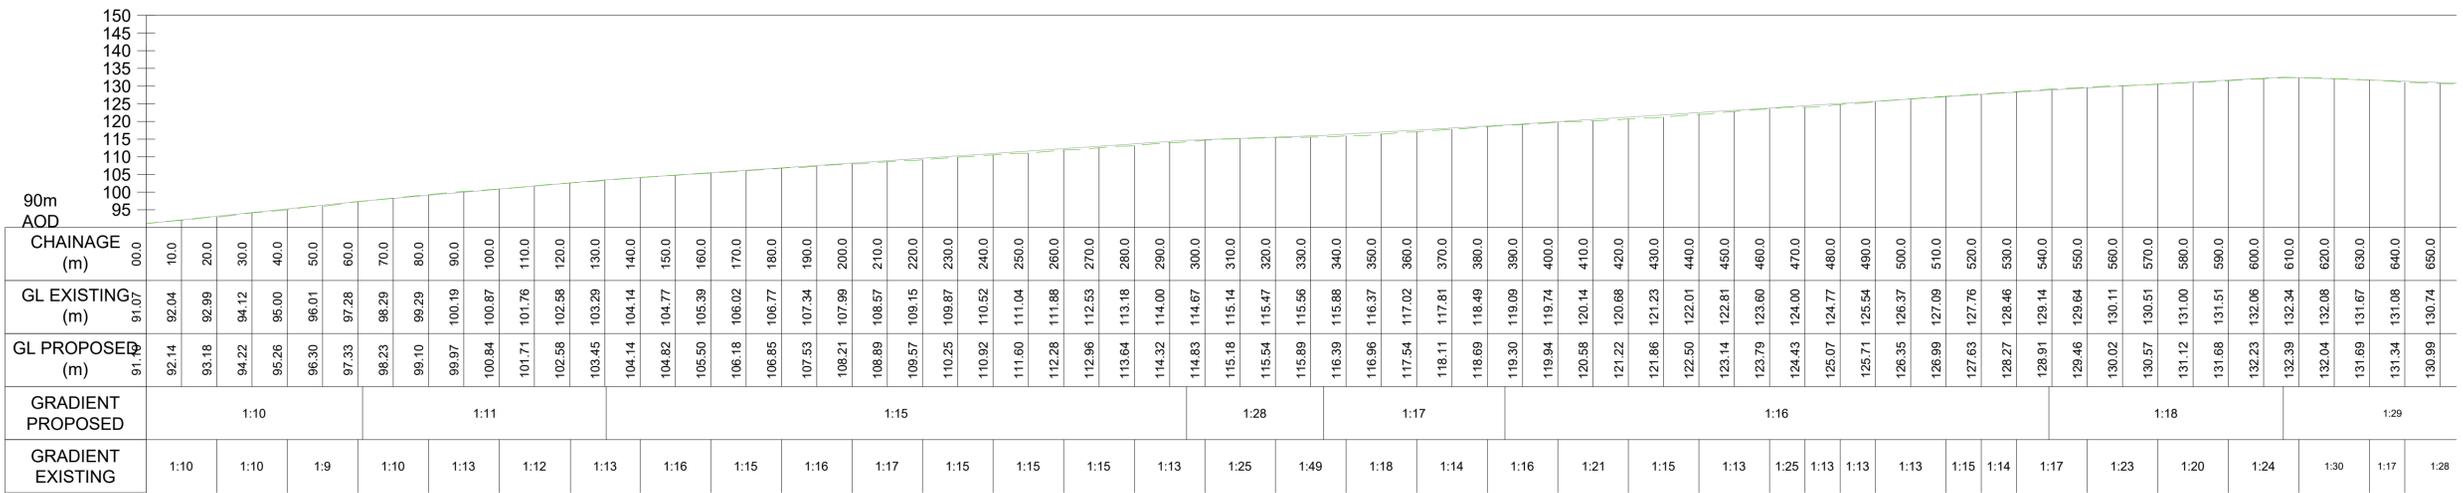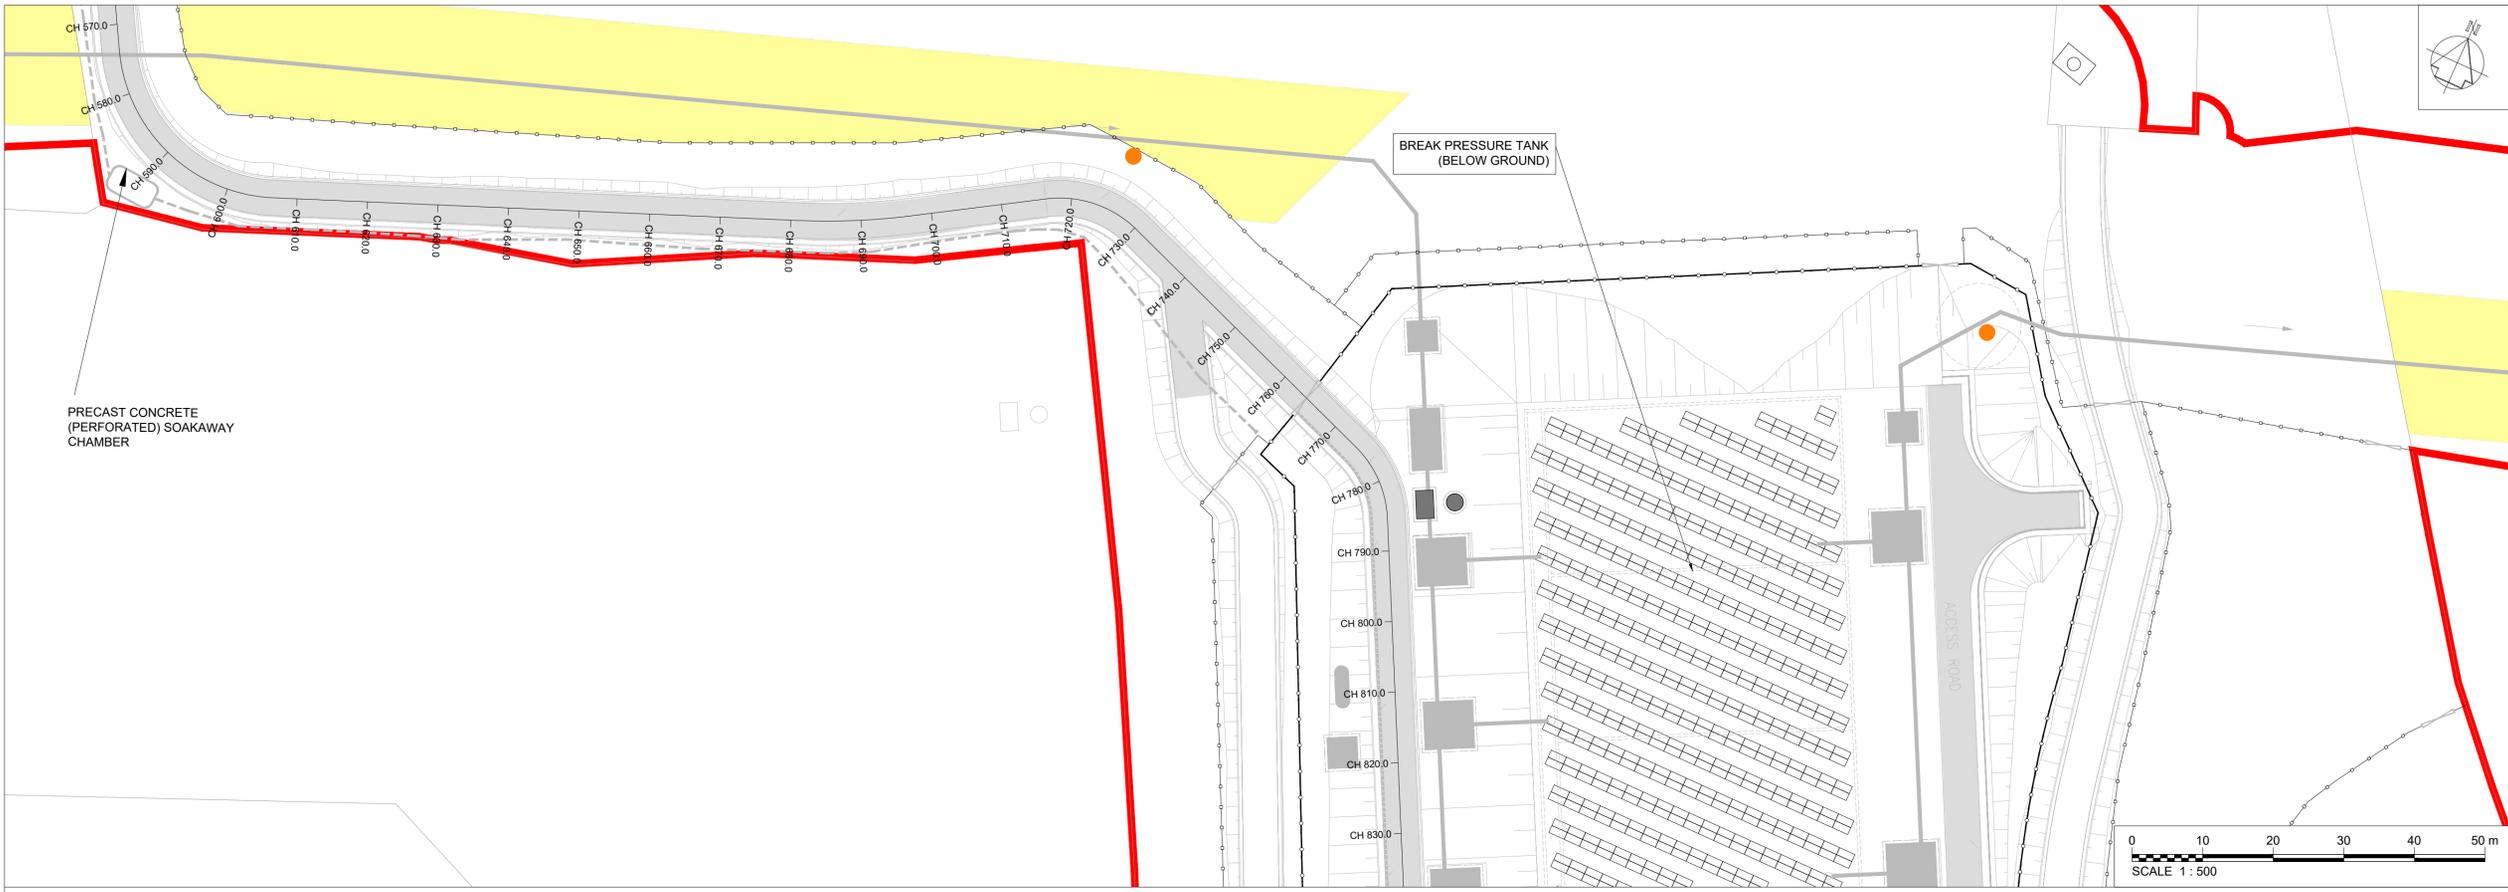

 --- EXISTING GROUND PROFILE  
— PROPOSED GROUND PROFILE

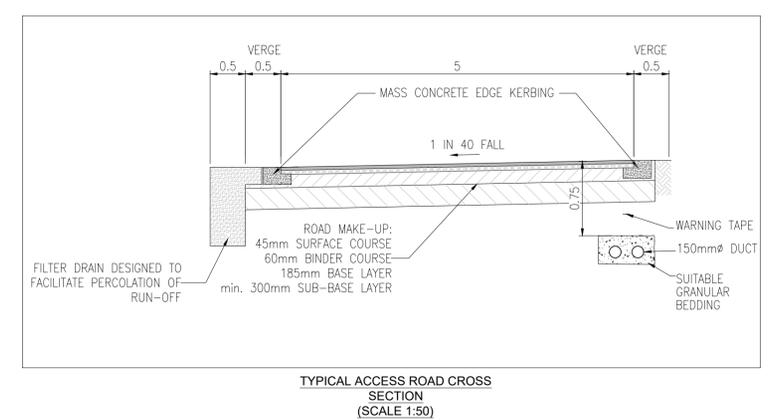

OSI 1:2500 Sheet No's:  
4046, 4105-A

Rev	Description	Drawn	Chk'd	App'd.	Date
F02	FINAL FOR PLANNING	AP	MG	SW	Dec:25
F01	FINAL FOR PLANNING	AP	MG	SW	Dec:25

**Uisce Éireann**  
Irish Water

**Tionscadal Soláthair Uisce**  
Water Supply Project

UISCE ÉIREANN  
COLVILL HOUSE,  
TALBOT STREET,  
DUBLIN 1,  
IRELAND

Call 1890 278 278  
Int: 00 353 1 707 2828

**JACOBS TOBIN**

Originated By	Drawn By	Checked By	Approved By
DM	AP	MG	SW

Date: 29.09.17 Date: 01.12.2025 Date: 01.12.2025 Date: 01.12.2025


Scale: 1:1000 @ A1 FINAL

Project Title: WATER SUPPLY PROJECT  
EASTERN AND MIDLANDS REGION


Drawing Title: BREAK PRESSURE TANK  
PROPOSED ACCESS ROAD SHEET 03

Drawing Status: FINAL FOR PLANNING  
Jacobs Tobin No. 32105801 Client No. 9318  
Drawing No. 32105801-850-03010



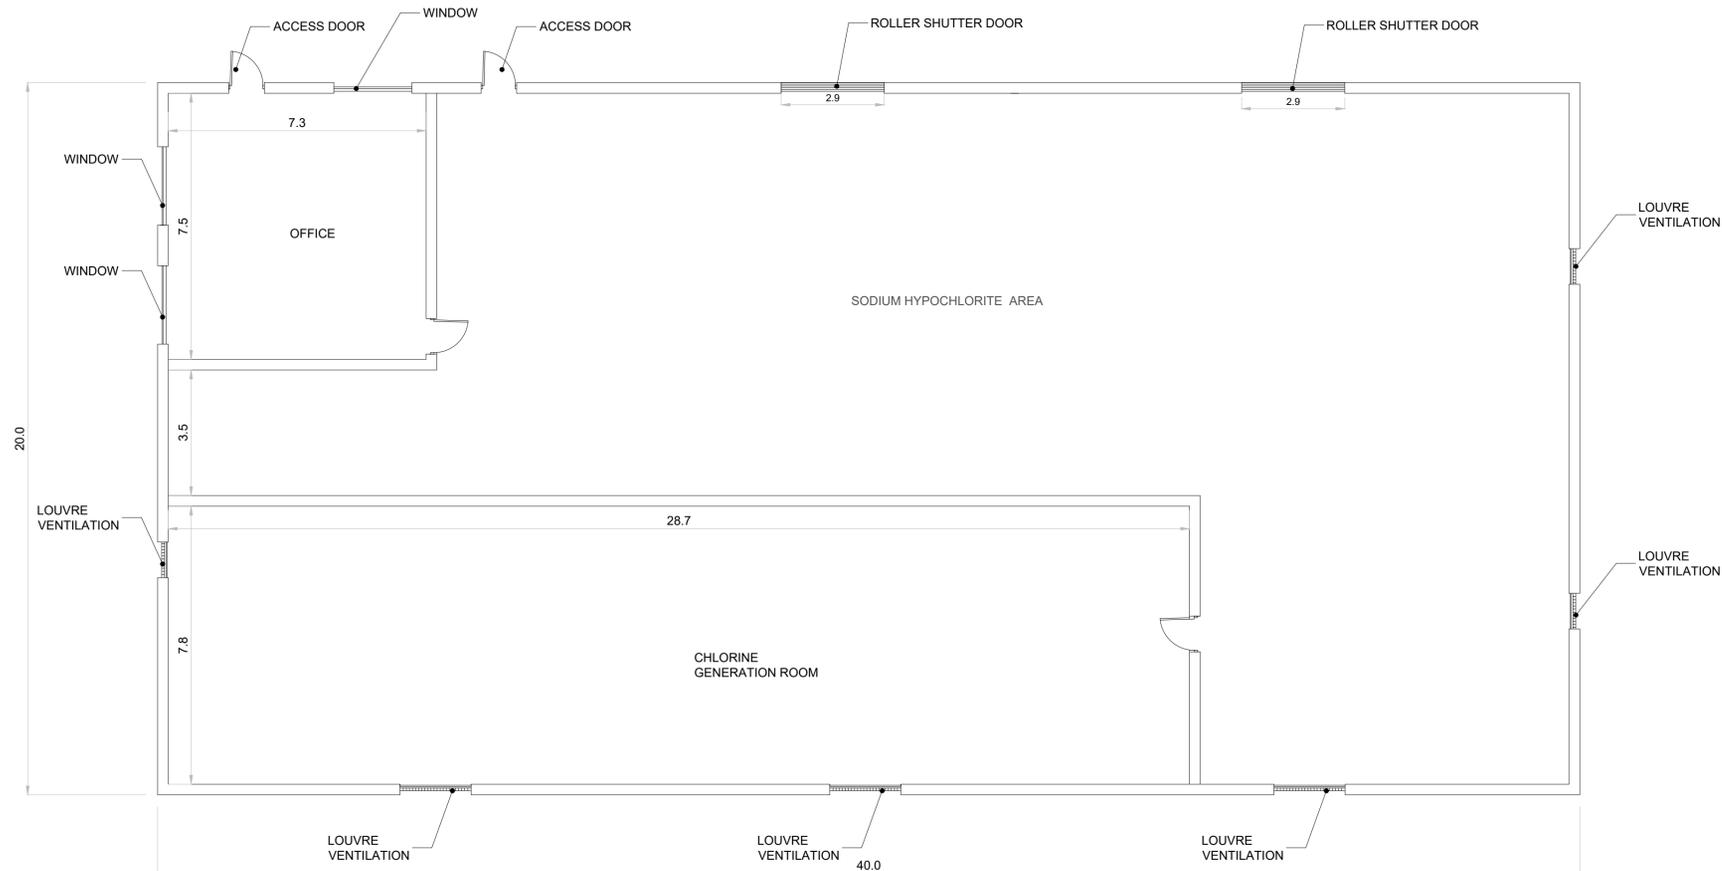

BREAK PRESSURE TANK CONTROL BUILDING - GROUND FLOOR PLAN  
SCALE 1:100 @ A1

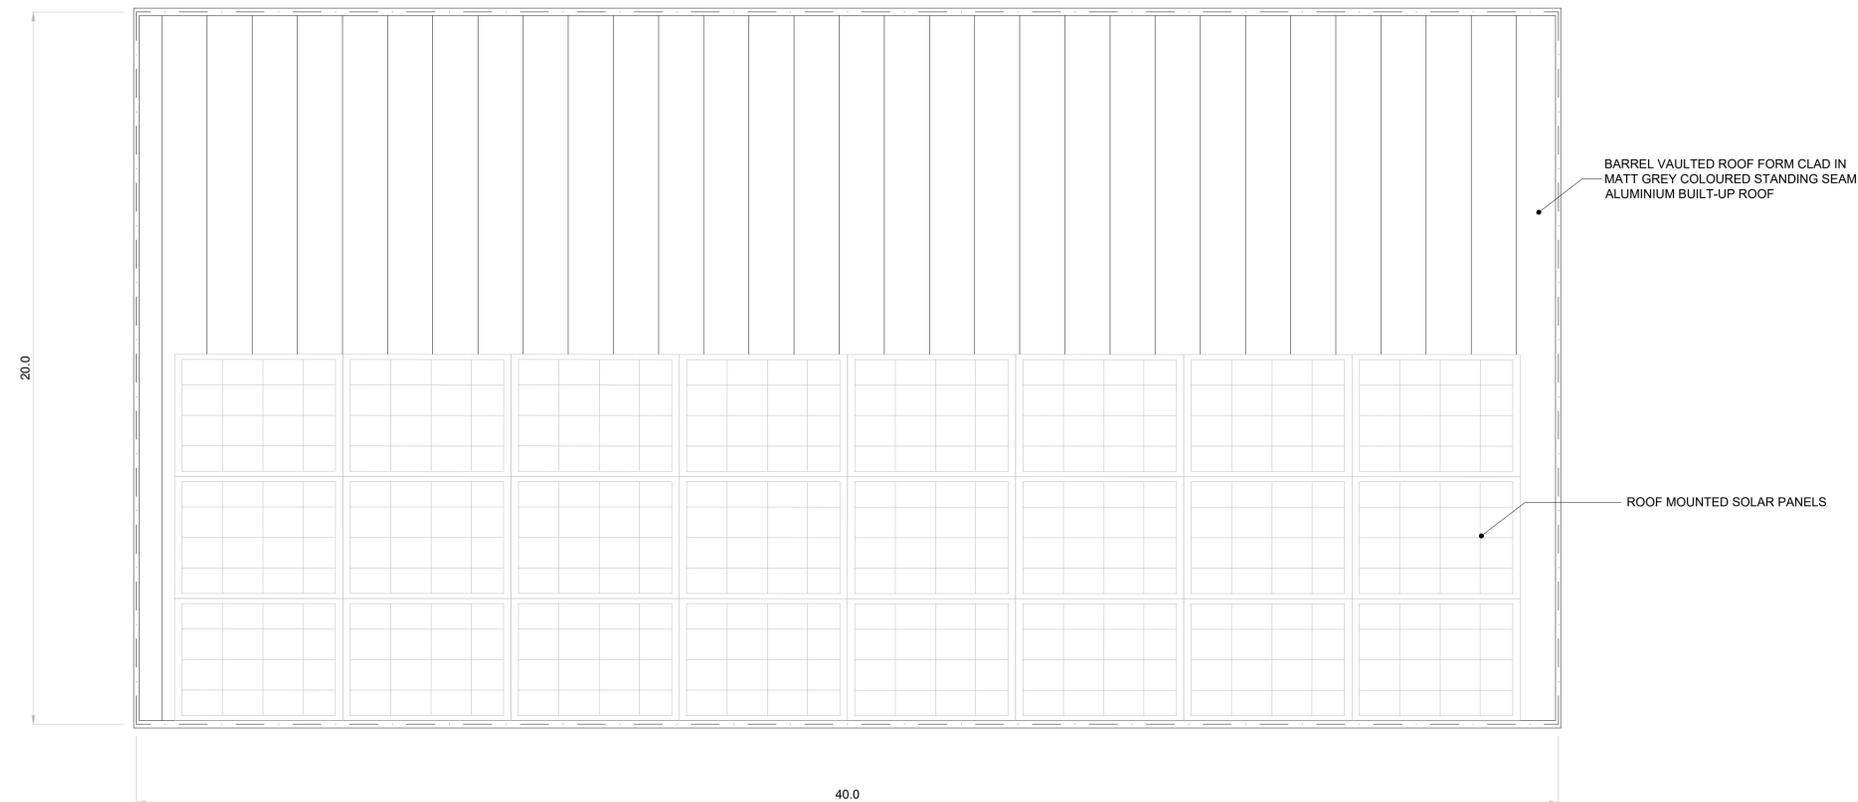


BREAK PRESSURE TANK CONTROL BUILDING - ROOF PLAN  
SCALE 1:100 @ A1



- Notes:
1. THIS DRAWING IS NOT TO BE SCALED.FIGURED DIMENSIONS ONLY TO BE TAKEN
  2. ALL DIMENSIONS ARE IN METRES AND ALL LEVELS IN METRES UNLESS OTHERWISE STATED.
  3. THIS DRAWING IS FOR PLANNING PURPOSES ONLY.

Key Plan

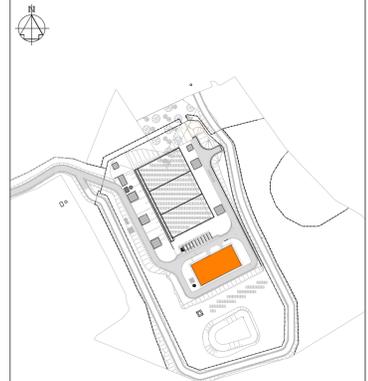

F02	FINAL FOR PLANNING	AP	MG	SW	Dec.25
F01	FINAL FOR PLANNING	AP	MG	SW	Dec.25
Rev	Description	Drawn	Chk'd	App'd.	Date

This drawing is the property of Uisce Éireann and must not be copied or used for any purpose other than that for which it is supplied without the written consent of Uisce Éireann.

**Uisce Éireann**  
Irish Water

**Tionscadal Soláthair Uisce**  
Water Supply Project

UISCE ÉIREANN  
COLVILL HOUSE,  
TALBOT STREET,  
DUBLIN 1,  
IRELAND

Call 1890 278 278  
Int: 00 353 1 707 2828

**JACOBS TOBIN**

Originated By MK	Drawn By AP	Checked By MG	Approved By SW
Date 01.02.22	Date 01.12.2025	Date 01.12.2025	Date 01.12.2025

Scale: 1:100 @ A1 FINAL






Project Title  
WATER SUPPLY PROJECT  
EASTERN AND MIDLANDS REGION

Drawing Title  
BREAK PRESSURE TANK  
CONTROL BUILDING PLANS

Drawing Status: FINAL FOR PLANNING  
Jacobs Tobin No. 32105801 Client No. 9318

Drawing No.  
**32105801-850-03015**

- Notes:
1. THIS DRAWING IS NOT TO BE SCALED. FIGURED DIMENSIONS ONLY TO BE TAKEN
  2. ALL DIMENSIONS ARE IN METRES AND ALL LEVELS IN METRES UNLESS OTHERWISE STATED.
  3. THIS DRAWING IS FOR PLANNING PURPOSES ONLY

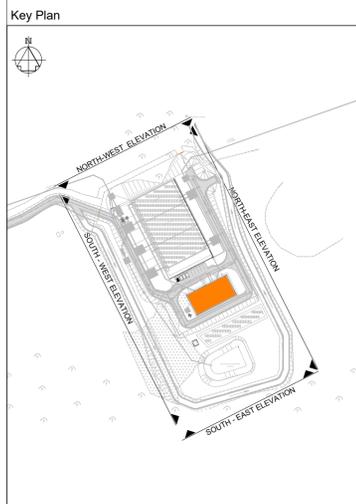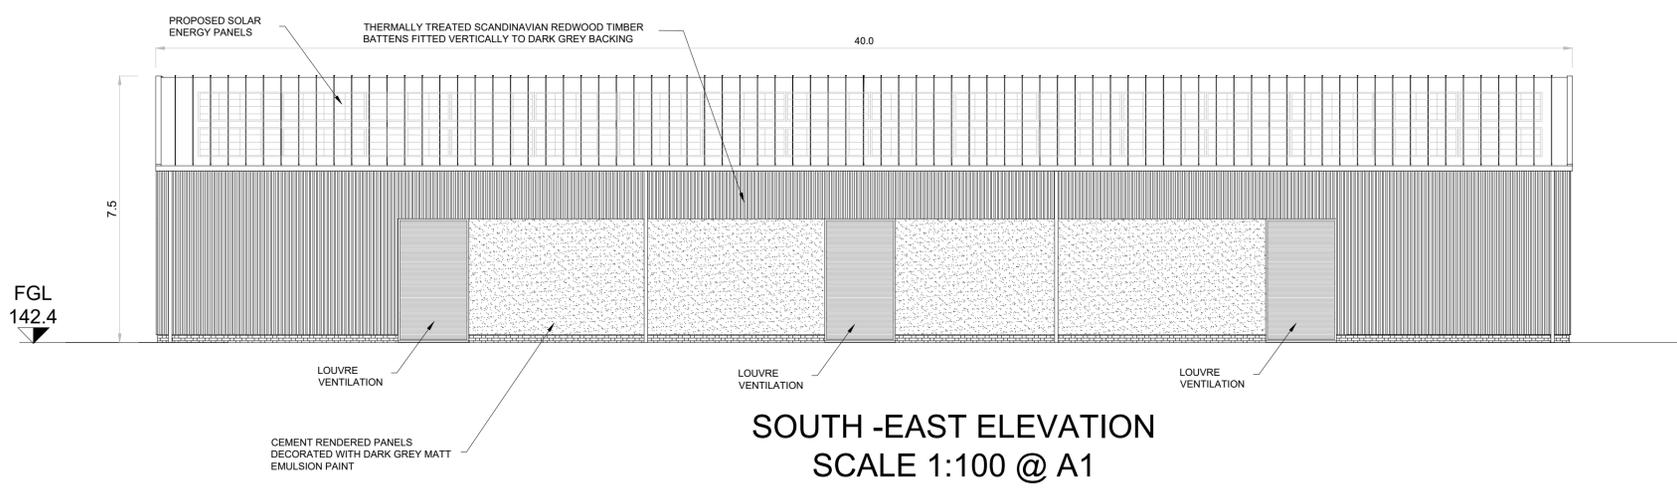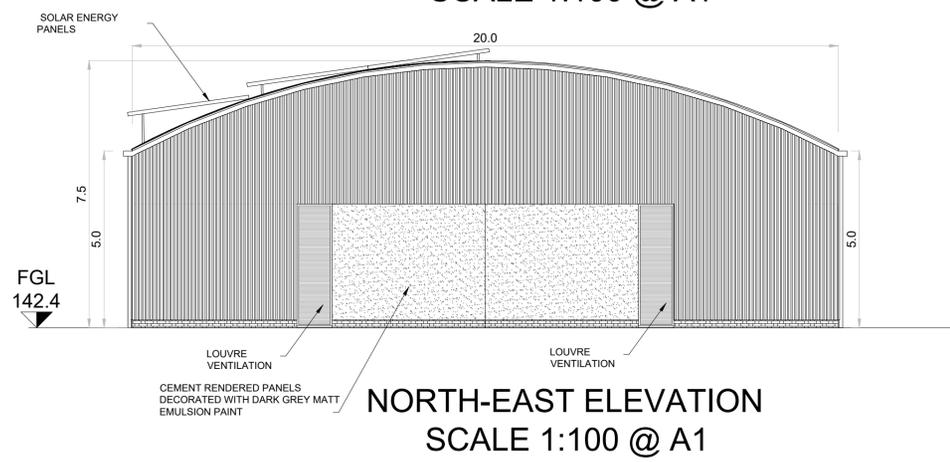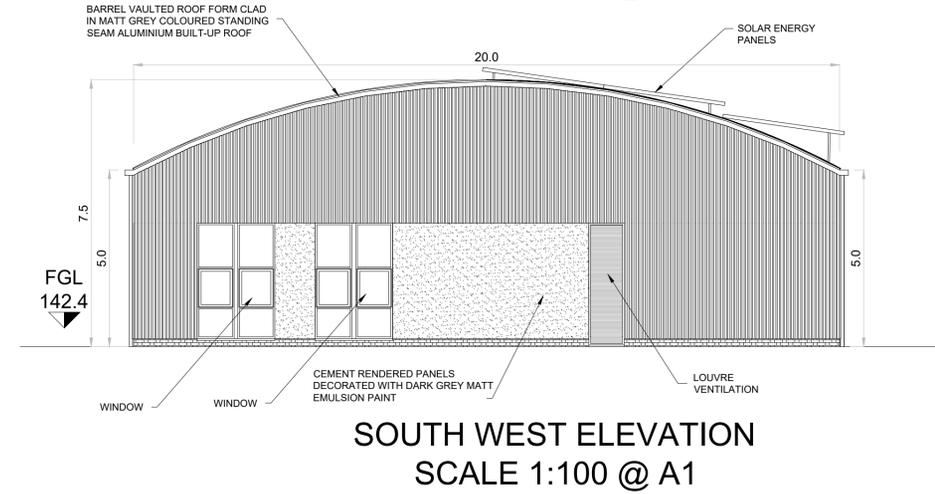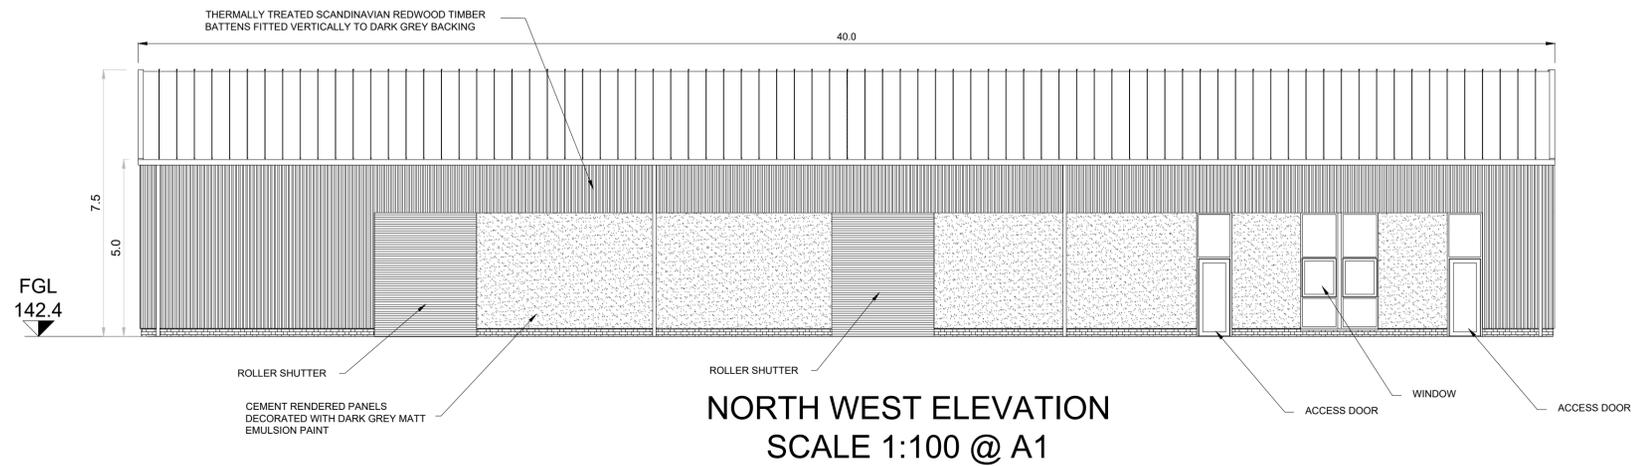

Legend:  
 FGL FINISH GROUND LEVEL

F02	FINAL FOR PLANNING	AP	MG	SW	Dec.25
F01	FINAL FOR PLANNING	AP	MG	SW	Dec.25
Rev	Description	Drawn	Chk'd	App'd.	Date

**Uisce Éireann**  
 Irish Water  
**Tionscadal Soláthair Uisce**  
 Water Supply Project

UISCE ÉIREANN  
 COLVILL HOUSE,  
 TALBOT STREET,  
 DUBLIN 1,  
 IRELAND

Call 1890 278 278  
 Int: 00 353 1 707 2828

**JACOBS TOBIN**

Originated By	Drawn By	Checked By	Approved By
MP	AP	MG	SW
Date	Date	Date	Date
13.12.23	01.12.2025	01.12.2025	01.12.2025


Scale: 1:100 @ A1  
 Project Title: WATER SUPPLY PROJECT EASTERN AND MIDLANDS REGION

Drawing Title: BREAK PRESSURE TANK CONTROL BUILDING ELEVATIONS


Drawing Status: FINAL FOR PLANNING  
 Jacobs Tobin No. 32105801 Client No. 9318  
 Drawing No. 32105801-850-03016



- Notes:
1. THIS DRAWING IS NOT TO BE SCALED. FIGURED DIMENSIONS ONLY TO BE TAKEN
  2. ALL DIMENSIONS ARE IN METRES AND ALL LEVELS IN METRES UNLESS OTHERWISE STATED.
  3. THIS DRAWING IS FOR PLANNING PURPOSES ONLY

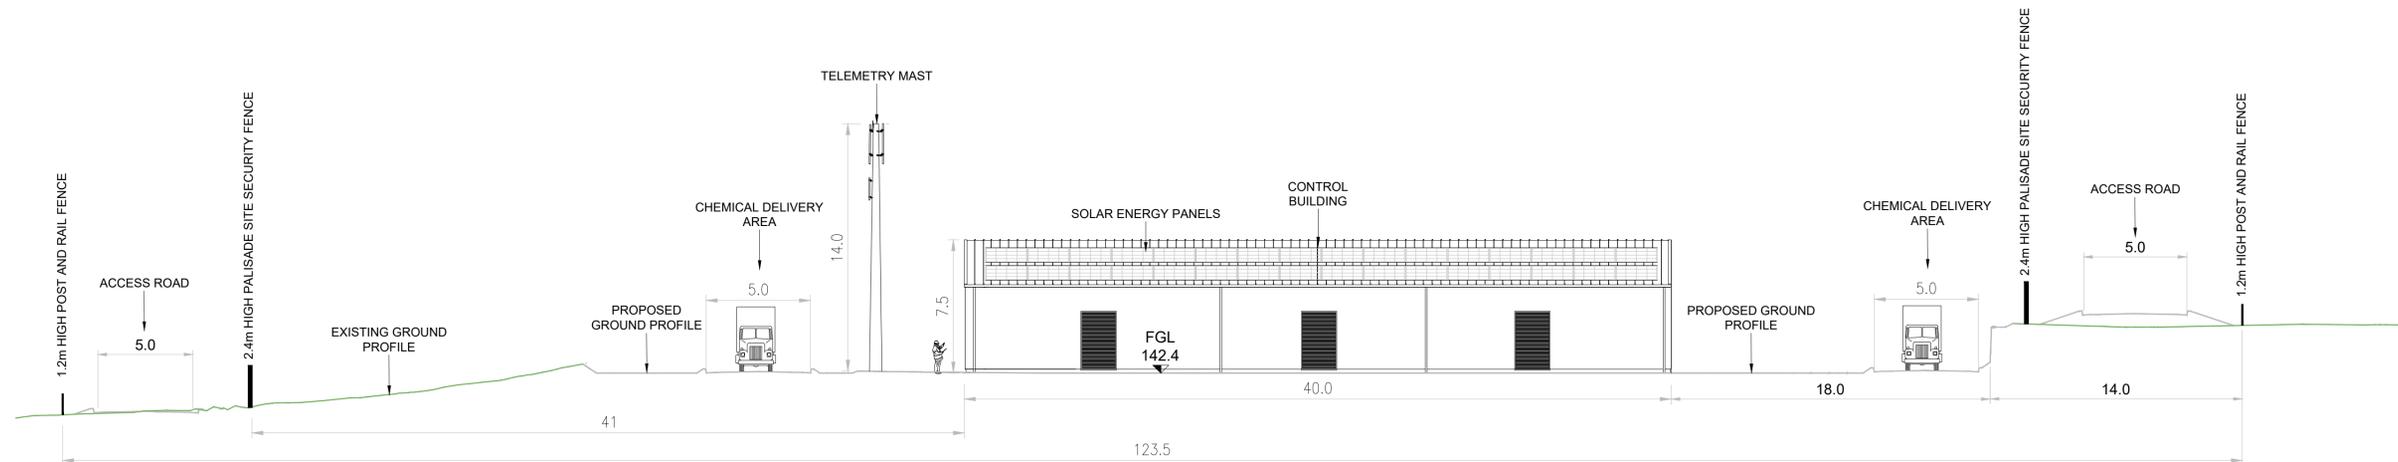

CONTIGUOUS ELEVATION OF THE SOUTH-EAST SIDE OF THE BUILDING  
SCALE 1:200@ A1

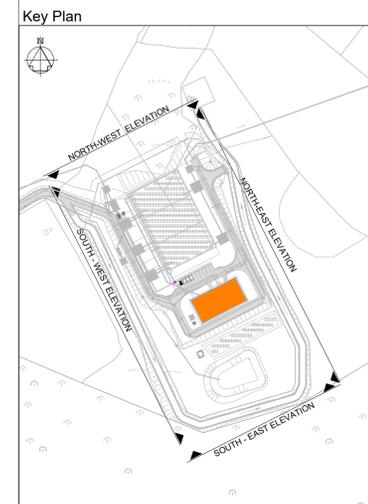

- LEGEND:
- EXISTING: GROUND PROFILE (solid green line)
  - PROPOSED: GROUND PROFILE (dashed green line)
  - FGL: FINISH GROUND LEVEL (dotted line)

F02	FINAL FOR PLANNING	AP	MG	SW	Dec 25
F01	FINAL FOR PLANNING	AP	MG	SW	Dec 25
Rev	Description	Drawn	Chk'd	App'd	Date

Uisce Éireann  
Irish Water  
Tionscadal Soláthair Uisce  
Water Supply Project

UISCE ÉIREANN  
COLVILL HOUSE,  
TALBOT STREET,  
DUBLIN 1,  
IRELAND

Call 1890 278 278  
Int: 00 353 1 707 2828

**JACOBS TOBIN**

Originated By MP	Drawn By AP	Checked By MG	Approved By SW
Date 13.12.23	Date 01.12.2025	Date 01.12.2025	Date 01.12.2025


Scale: 1:200 @ A1  
Project Title: WATER SUPPLY PROJECT EASTERN AND MIDLANDS REGION

Drawing Title: BREAK PRESSURE TANK SOUTH-EAST/NORTH-WEST CONTIGUOUS ELEVATION

Drawing Status: FINAL FOR PLANNING

Jacobs Tobin No. 32105801 Client No. 9318


Drawing No. 32105801-850-03017

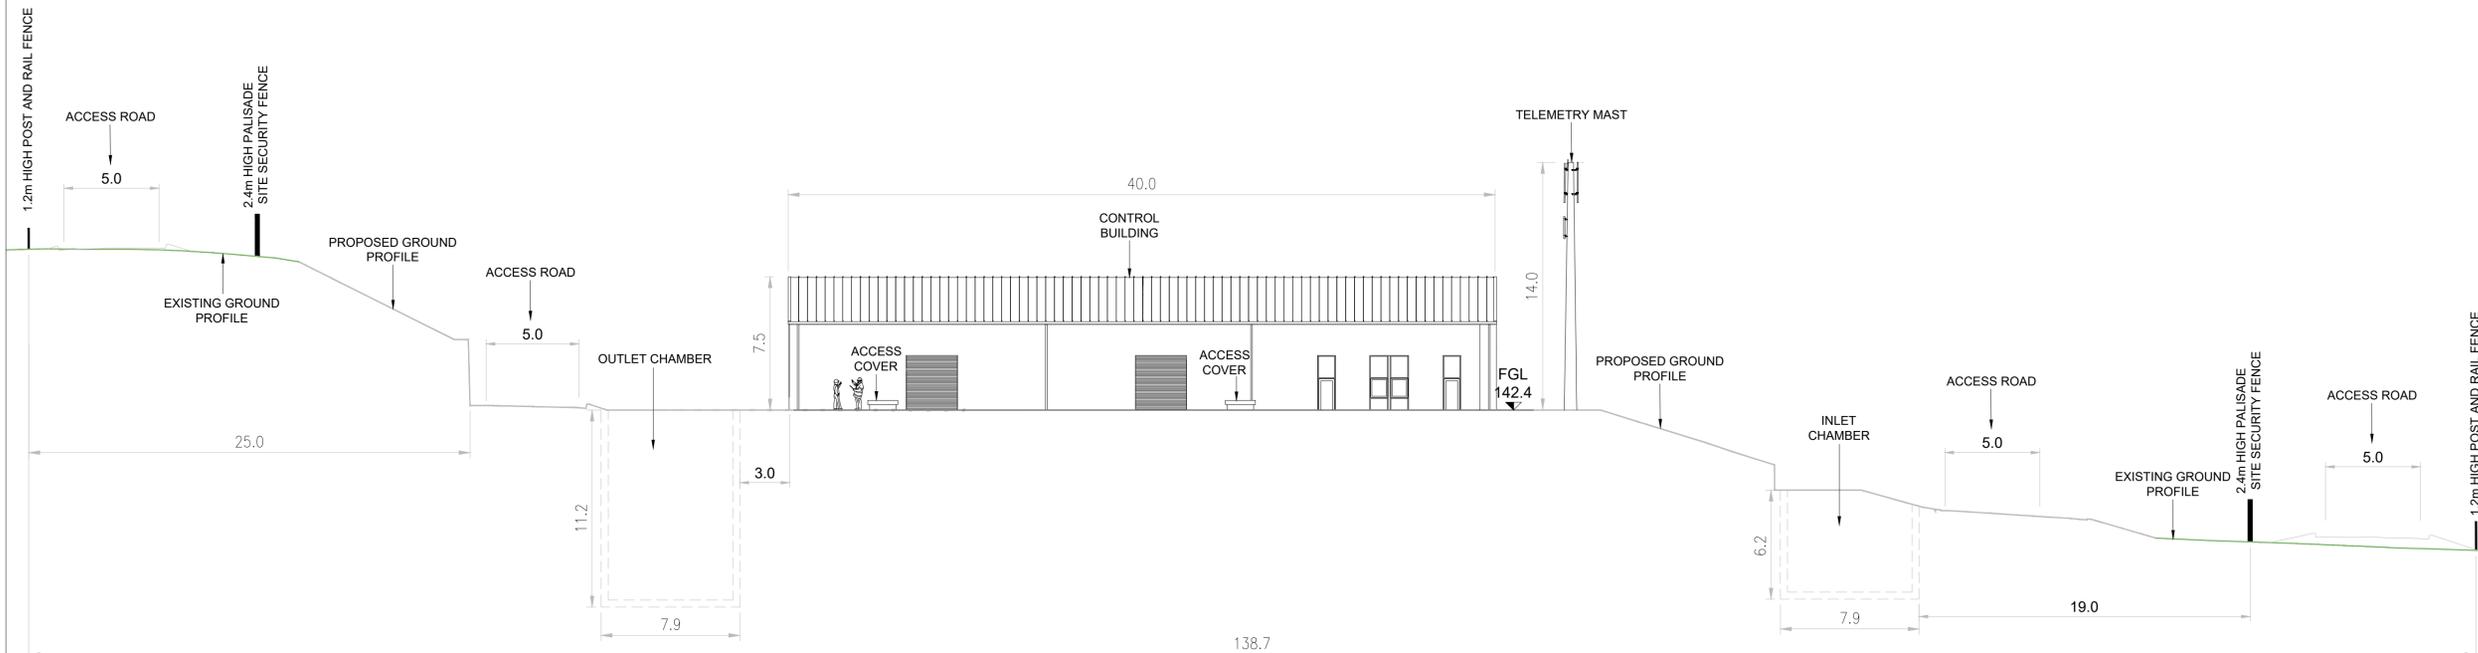


CONTIGUOUS ELEVATION OF THE NORTH-WEST SIDE OF THE BUILDING  
SCALE 1:200@ A1




- Notes:
1. THIS DRAWING IS NOT TO BE SCALED. FIGURED DIMENSIONS ONLY TO BE TAKEN
  2. ALL DIMENSIONS ARE IN METRES AND ALL LEVELS IN METRES UNLESS OTHERWISE STATED.
  3. THIS DRAWING IS FOR PLANNING PURPOSES ONLY

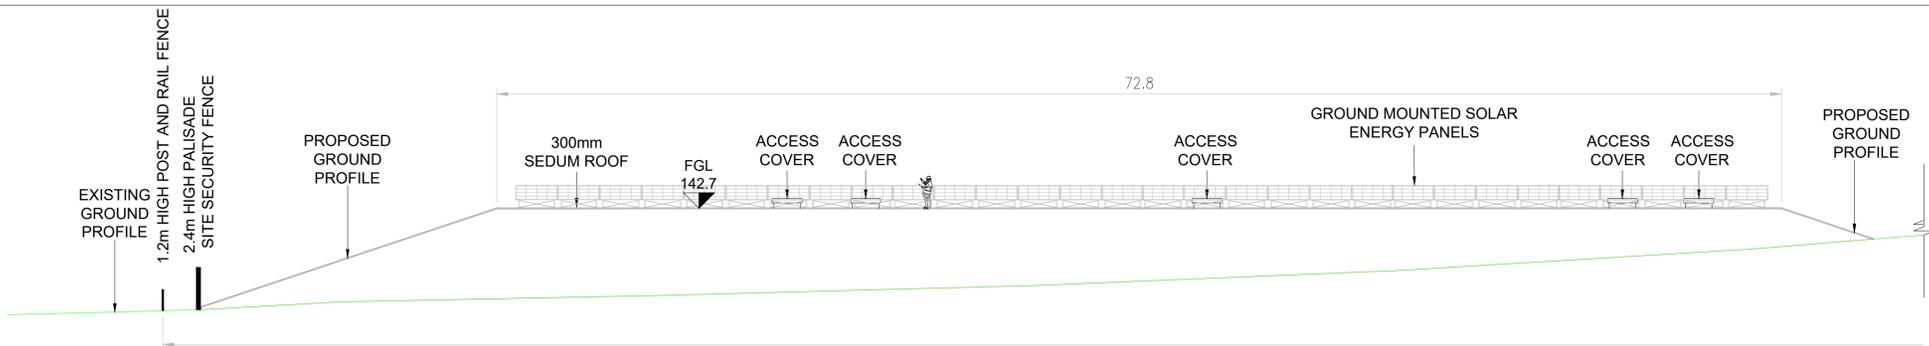


CONTIGUOUS ELEVATION OF THE SOUTH-WEST SIDE OF THE BUILDING - PART 1  
SCALE 1:200@ A1

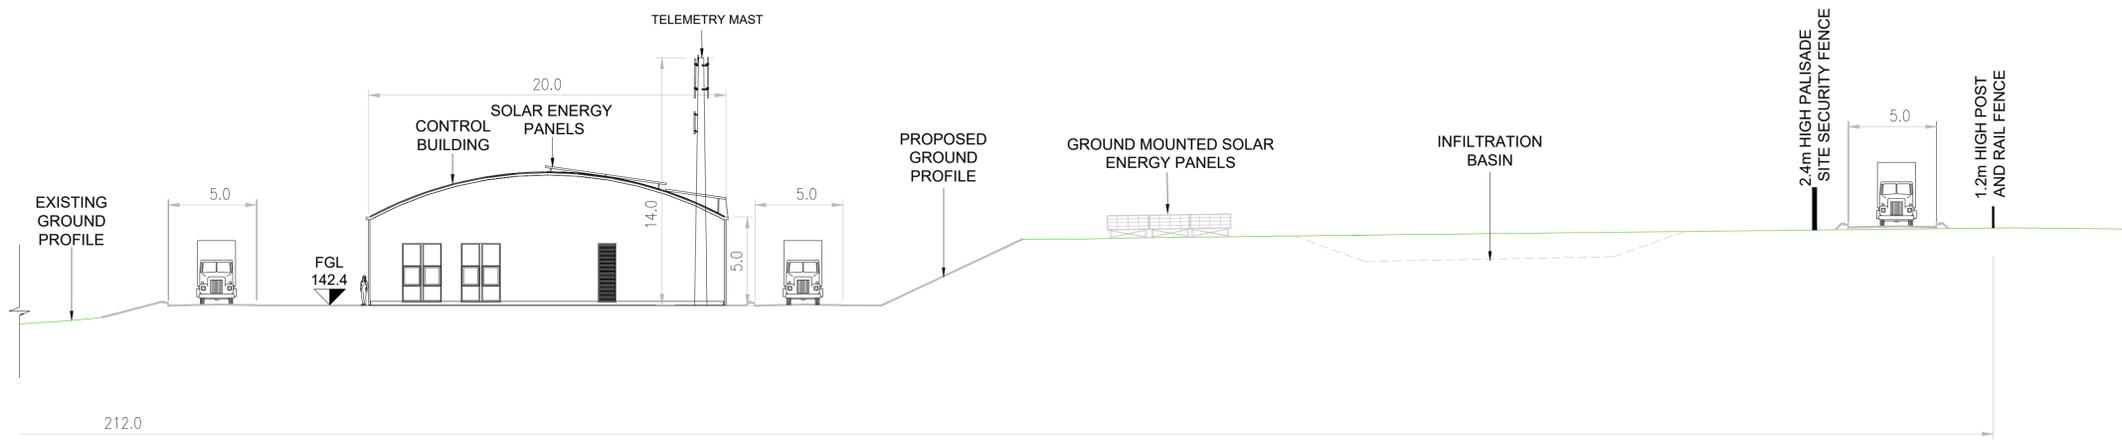


CONTIGUOUS ELEVATION OF THE SOUTH-WEST SIDE OF THE BUILDING - PART 2  
SCALE 1:200@ A1

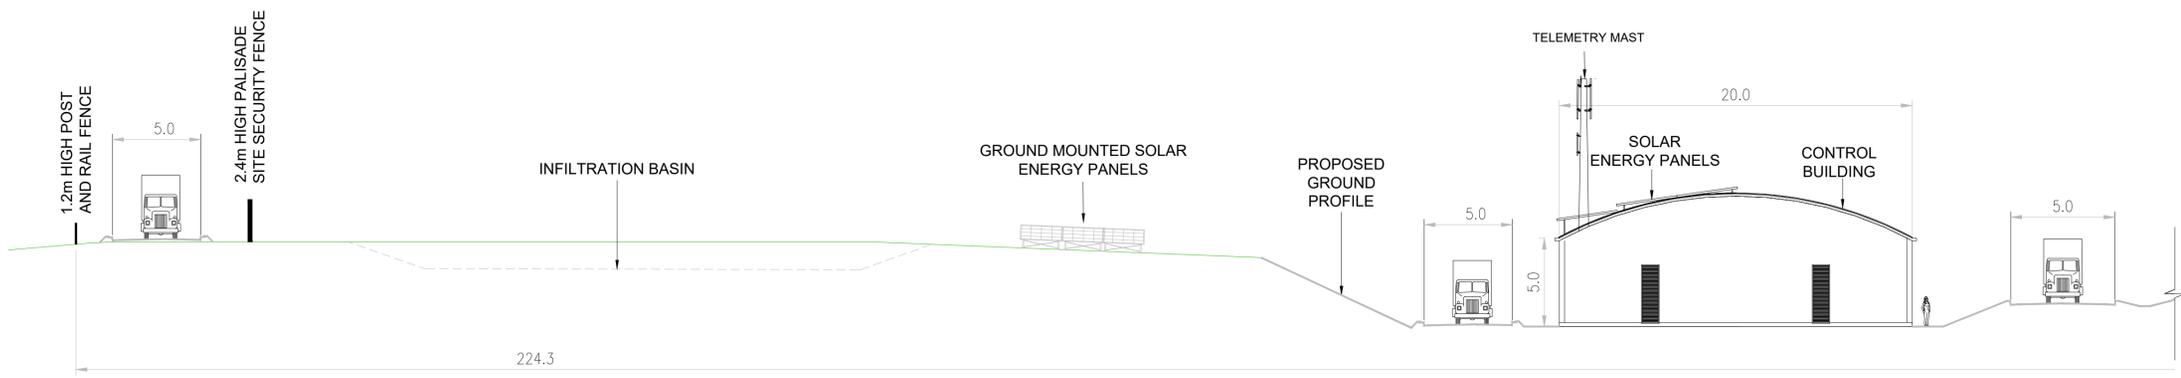

CONTIGUOUS ELEVATION OF THE NORTH-EAST SIDE OF THE BUILDING - PART 1  
SCALE 1:200@ A1

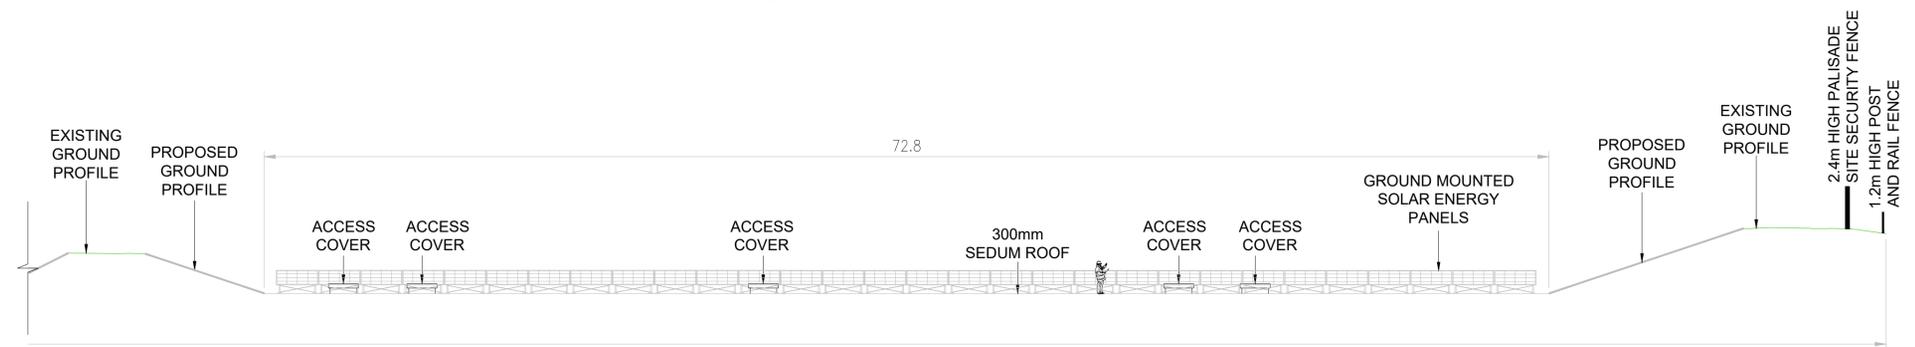

CONTIGUOUS ELEVATION OF THE NORTH-EAST SIDE OF THE BUILDING - PART 2  
SCALE 1:200@ A1

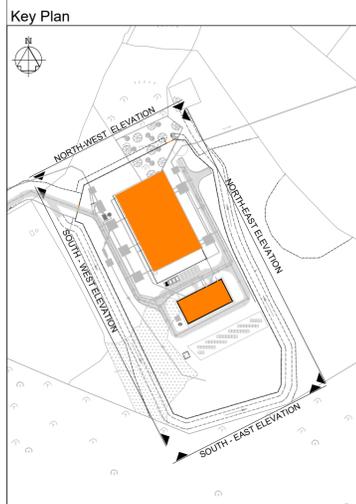

LEGEND:

EXISTING: — GROUND PROFILE

PROPOSED: — GROUND PROFILE

FGL FINISH GROUND LEVEL

F02	FINAL FOR PLANNING	AP	MG	SW	Dec 25
F01	FINAL FOR PLANNING	AP	MG	SW	Dec 25
Rev	Description	Drawn	Chk'd	App'd	Date

This drawing is the property of Uisce Éireann and must not be copied or used for any purpose other than that for which it is supplied without the written consent of Uisce Éireann.

**Uisce Éireann**  
Irish Water

**Tionscadal Soláthair Uisce**  
Water Supply Project

UISCE ÉIREANN  
COLVILL HOUSE,  
TALBOT STREET,  
DUBLIN 1,  
IRELAND

Call 1890 278 278  
Int: 00 353 1 707 2828

**Jacobs TOBIN**

Originated By	Drawn By	Checked By	Approved By
MP	AP	MG	SW
Date	Date	Date	Date
13.12.23	01.12.25	01.12.25	01.12.25

Scale: 1:200 @ A1  
FINAL

Project Title  
WATER SUPPLY PROJECT  
EASTERN AND MIDLANDS REGION

Drawing Title  
BREAK PRESSURE TANK  
SOUTH-WEST/NORTH-EAST CONTIGUOUS ELEVATION

Drawing Status: FINAL FOR PLANNING  
Jacobs Tobin No. 32105801 Client No. 9318

Drawing No.  
32105801-850-03018





- Notes:
1. THIS DRAWING IS NOT TO BE SCALED. FIGURED DIMENSIONS ONLY TO BE TAKEN
  2. ALL DIMENSIONS ARE IN METRES AND ALL LEVELS ARE IN METRES AOD MALIN HEAD UNLESS OTHERWISE STATED.
  3. THE PIPELINE HORIZONTAL ALIGNMENTS ARE SUBJECT TO FURTHER DEVELOPMENT. ANY CHANGES WILL BE SUBJECT TO THE LIMITS AND CONDITIONS DETAILED IN THE PLANNING SUBMISSION.
  4. THIS DRAWING IS FOR PLANNING PURPOSES ONLY.

- LEGEND:
- PLANNING APPLICATION BOUNDARY
  - INDICATIVE PERMANENT WAYLEAVE
- EXISTING:
- NATIONAL MONUMENT
- PROPOSED:
- 1.2m HIGH POST AND RAIL FENCE
  - 2.4m HIGH PALISADE SITE SECURITY FENCE
  - INLET PIPEWORK
  - OUTLET PIPEWORK
  - SCOUR PIPE
  - SURFACE WATER DRAINAGE
  - FILTER DRAIN
  - SERVICE PIPE
  - OVERFLOW DRAINAGE PIPE
  - CHLORINE DOSING PIPE
  - DE-CHLORINATION DOSING PIPE
  - ROAD / HARDSTAND SURFACE
  - BUILDING
  - BELOW GROUND STRUCTURES
  - Ⓜ EV CHARGING POINT
  - ♿ DISABLED PARKING SPACE
  - SOLAR ENERGY PANELS
  - CCTV DROP DOWN POLE

OSI 1:2500 Sheet No's:  
4046, 4105-A

Rev	Description	Drawn	Chk'd	App'd	Date
F02	FINAL FOR PLANNING	AP	MG	SW	Dec.25
F01	FINAL FOR PLANNING	AP	MG	SW	Dec.25

This drawing is the property of Uisce Éireann and must not be copied or used for any purpose other than that for which it is supplied without the written consent of Uisce Éireann.

**Uisce Éireann**  
Irish Water

**Tionscadal Soláthair Uisce**  
Water Supply Project

UISCE ÉIREANN  
COLVILL HOUSE,  
TALBOT STREET,  
DUBLIN 1,  
IRELAND

Call 1890 278 278  
Int: 00 353 1 707 2828

# Jacobs TOBIN

Originated By	Drawn By	Checked By	Approved By
DM	AP	MG	SW
Date	Date	Date	Date
19.07.19	01.12.2025	01.12.2025	01.12.2025

 

Scale: 1:500 @ A1 FINAL


Project Title: WATER SUPPLY PROJECT  
EASTERN AND MIDLANDS REGION

Drawing Title: BREAK PRESSURE TANK  
PROPOSED DRAINAGE PLAN

Drawing Status: FINAL FOR PLANNING  
Jacobs Tobin No. 32105801 Client No. 9318

Drawing No. 32105801-850-03022

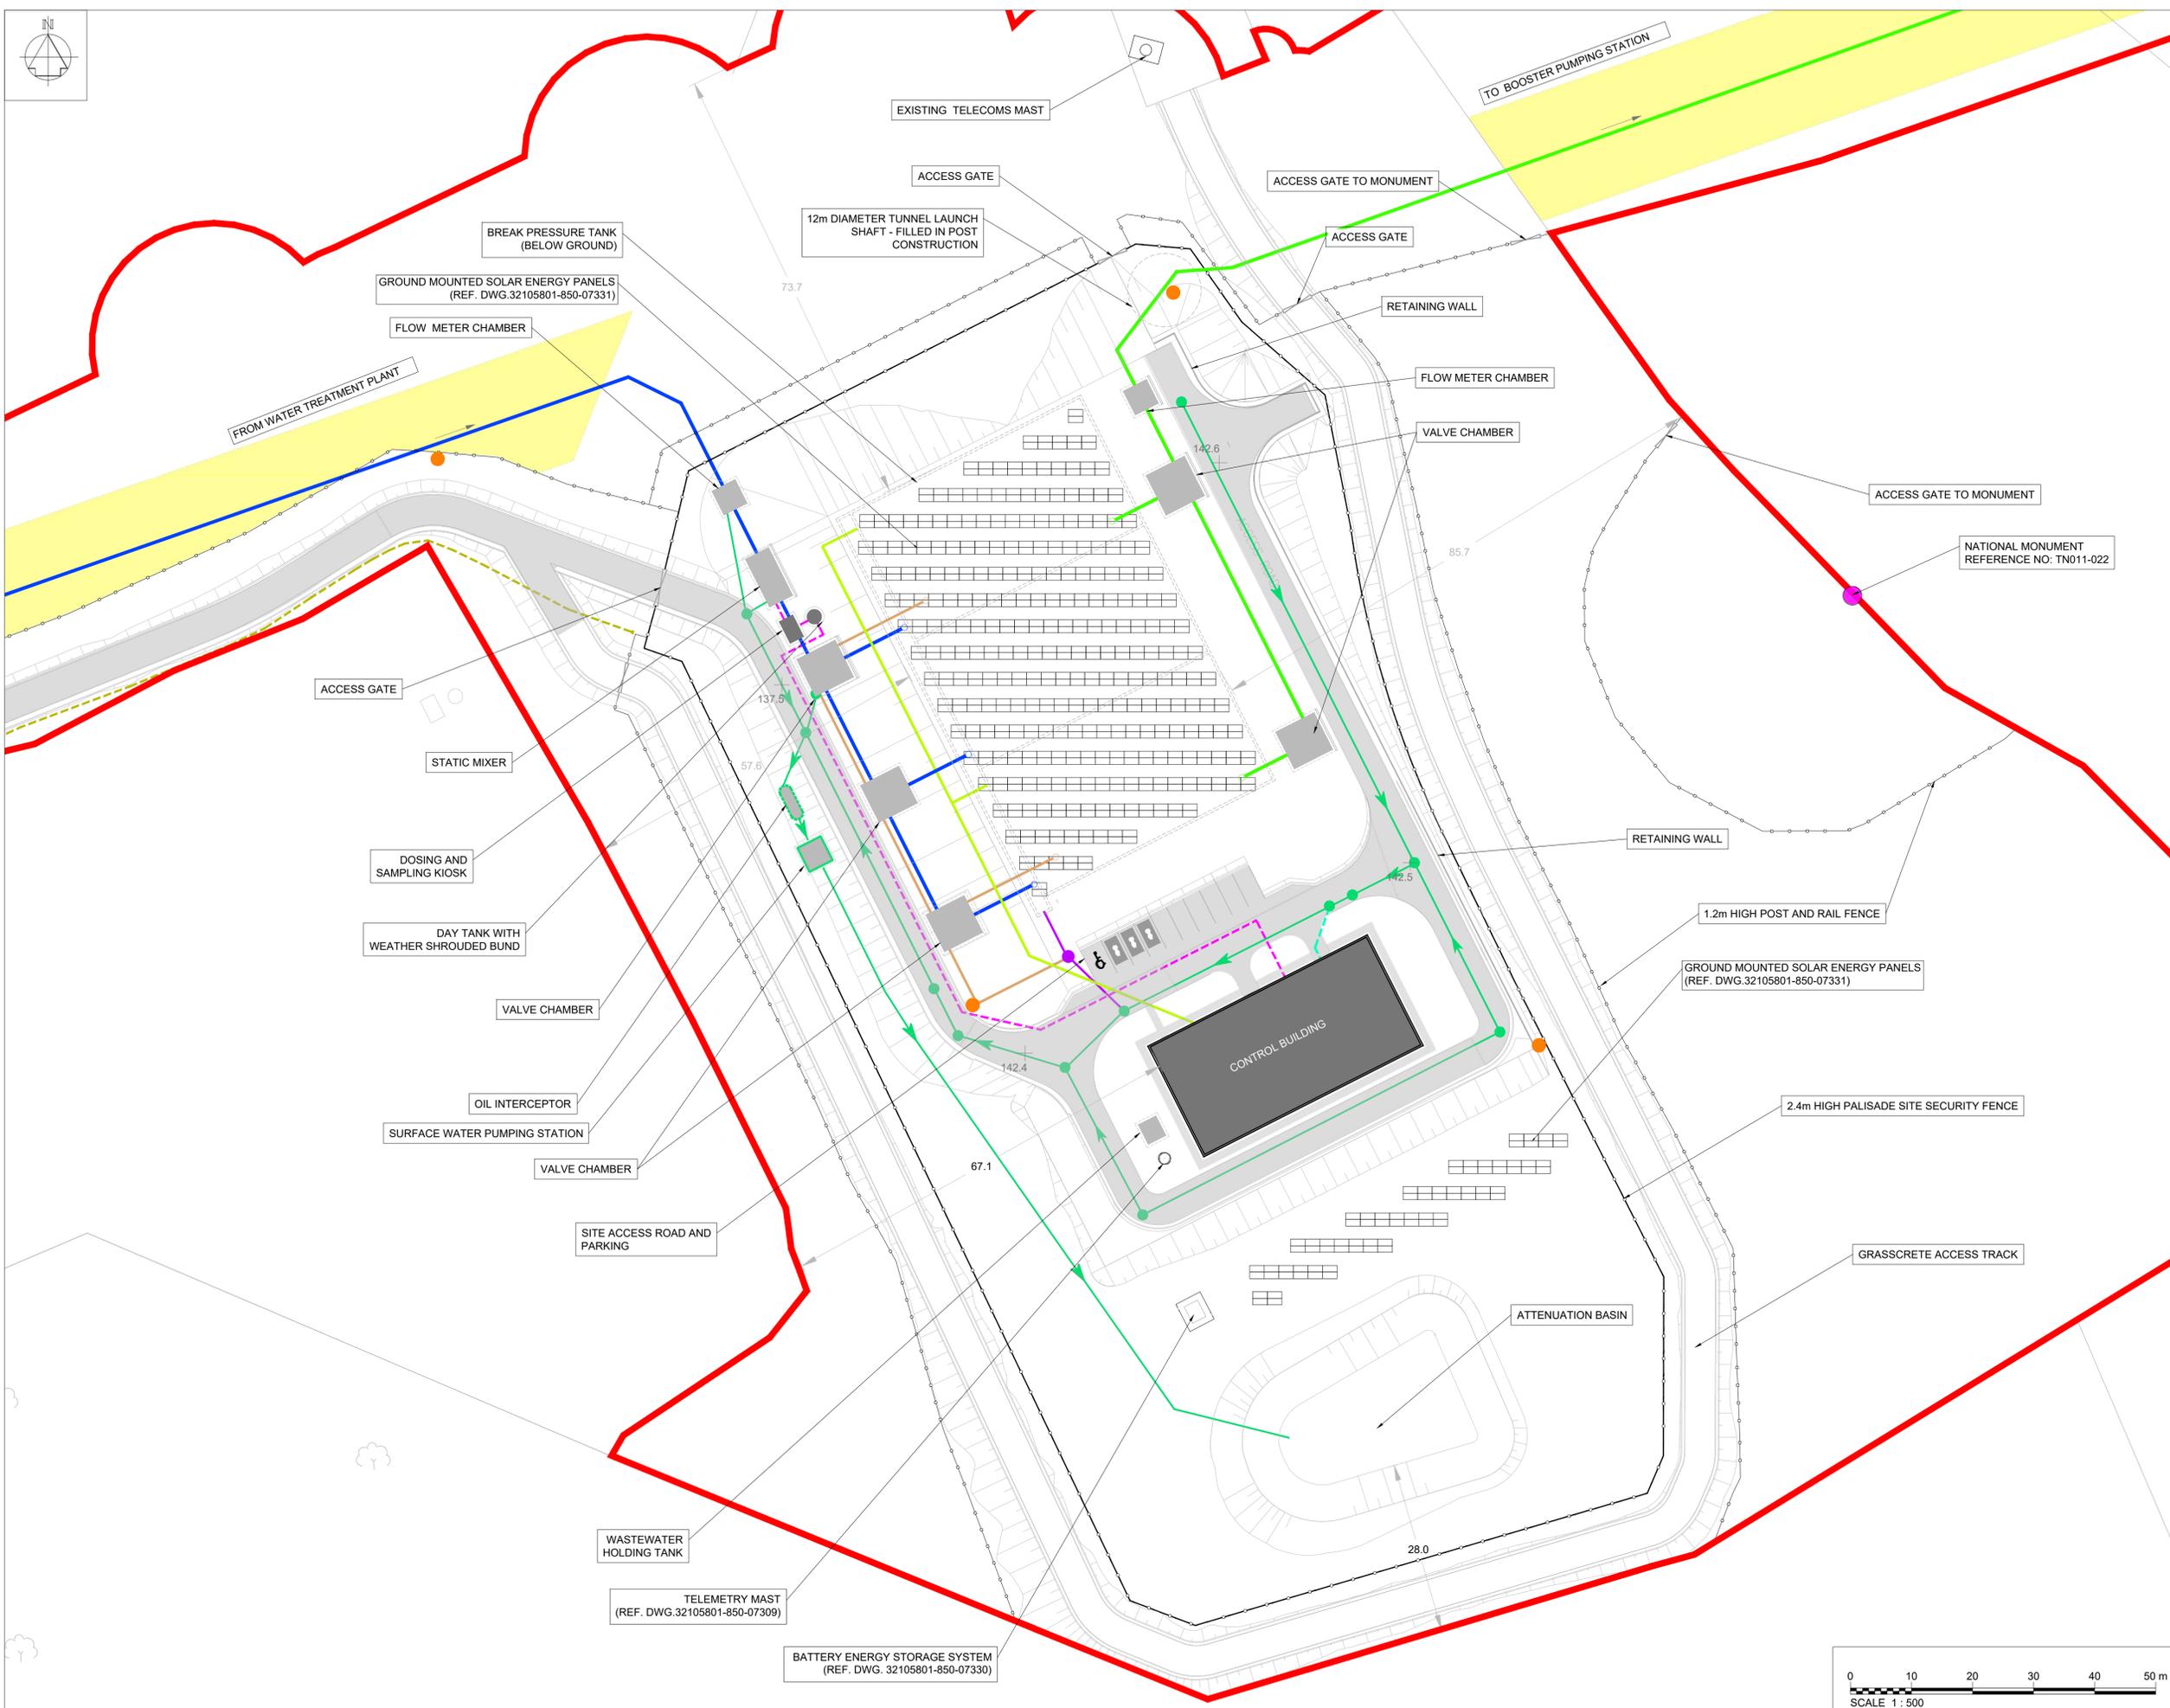

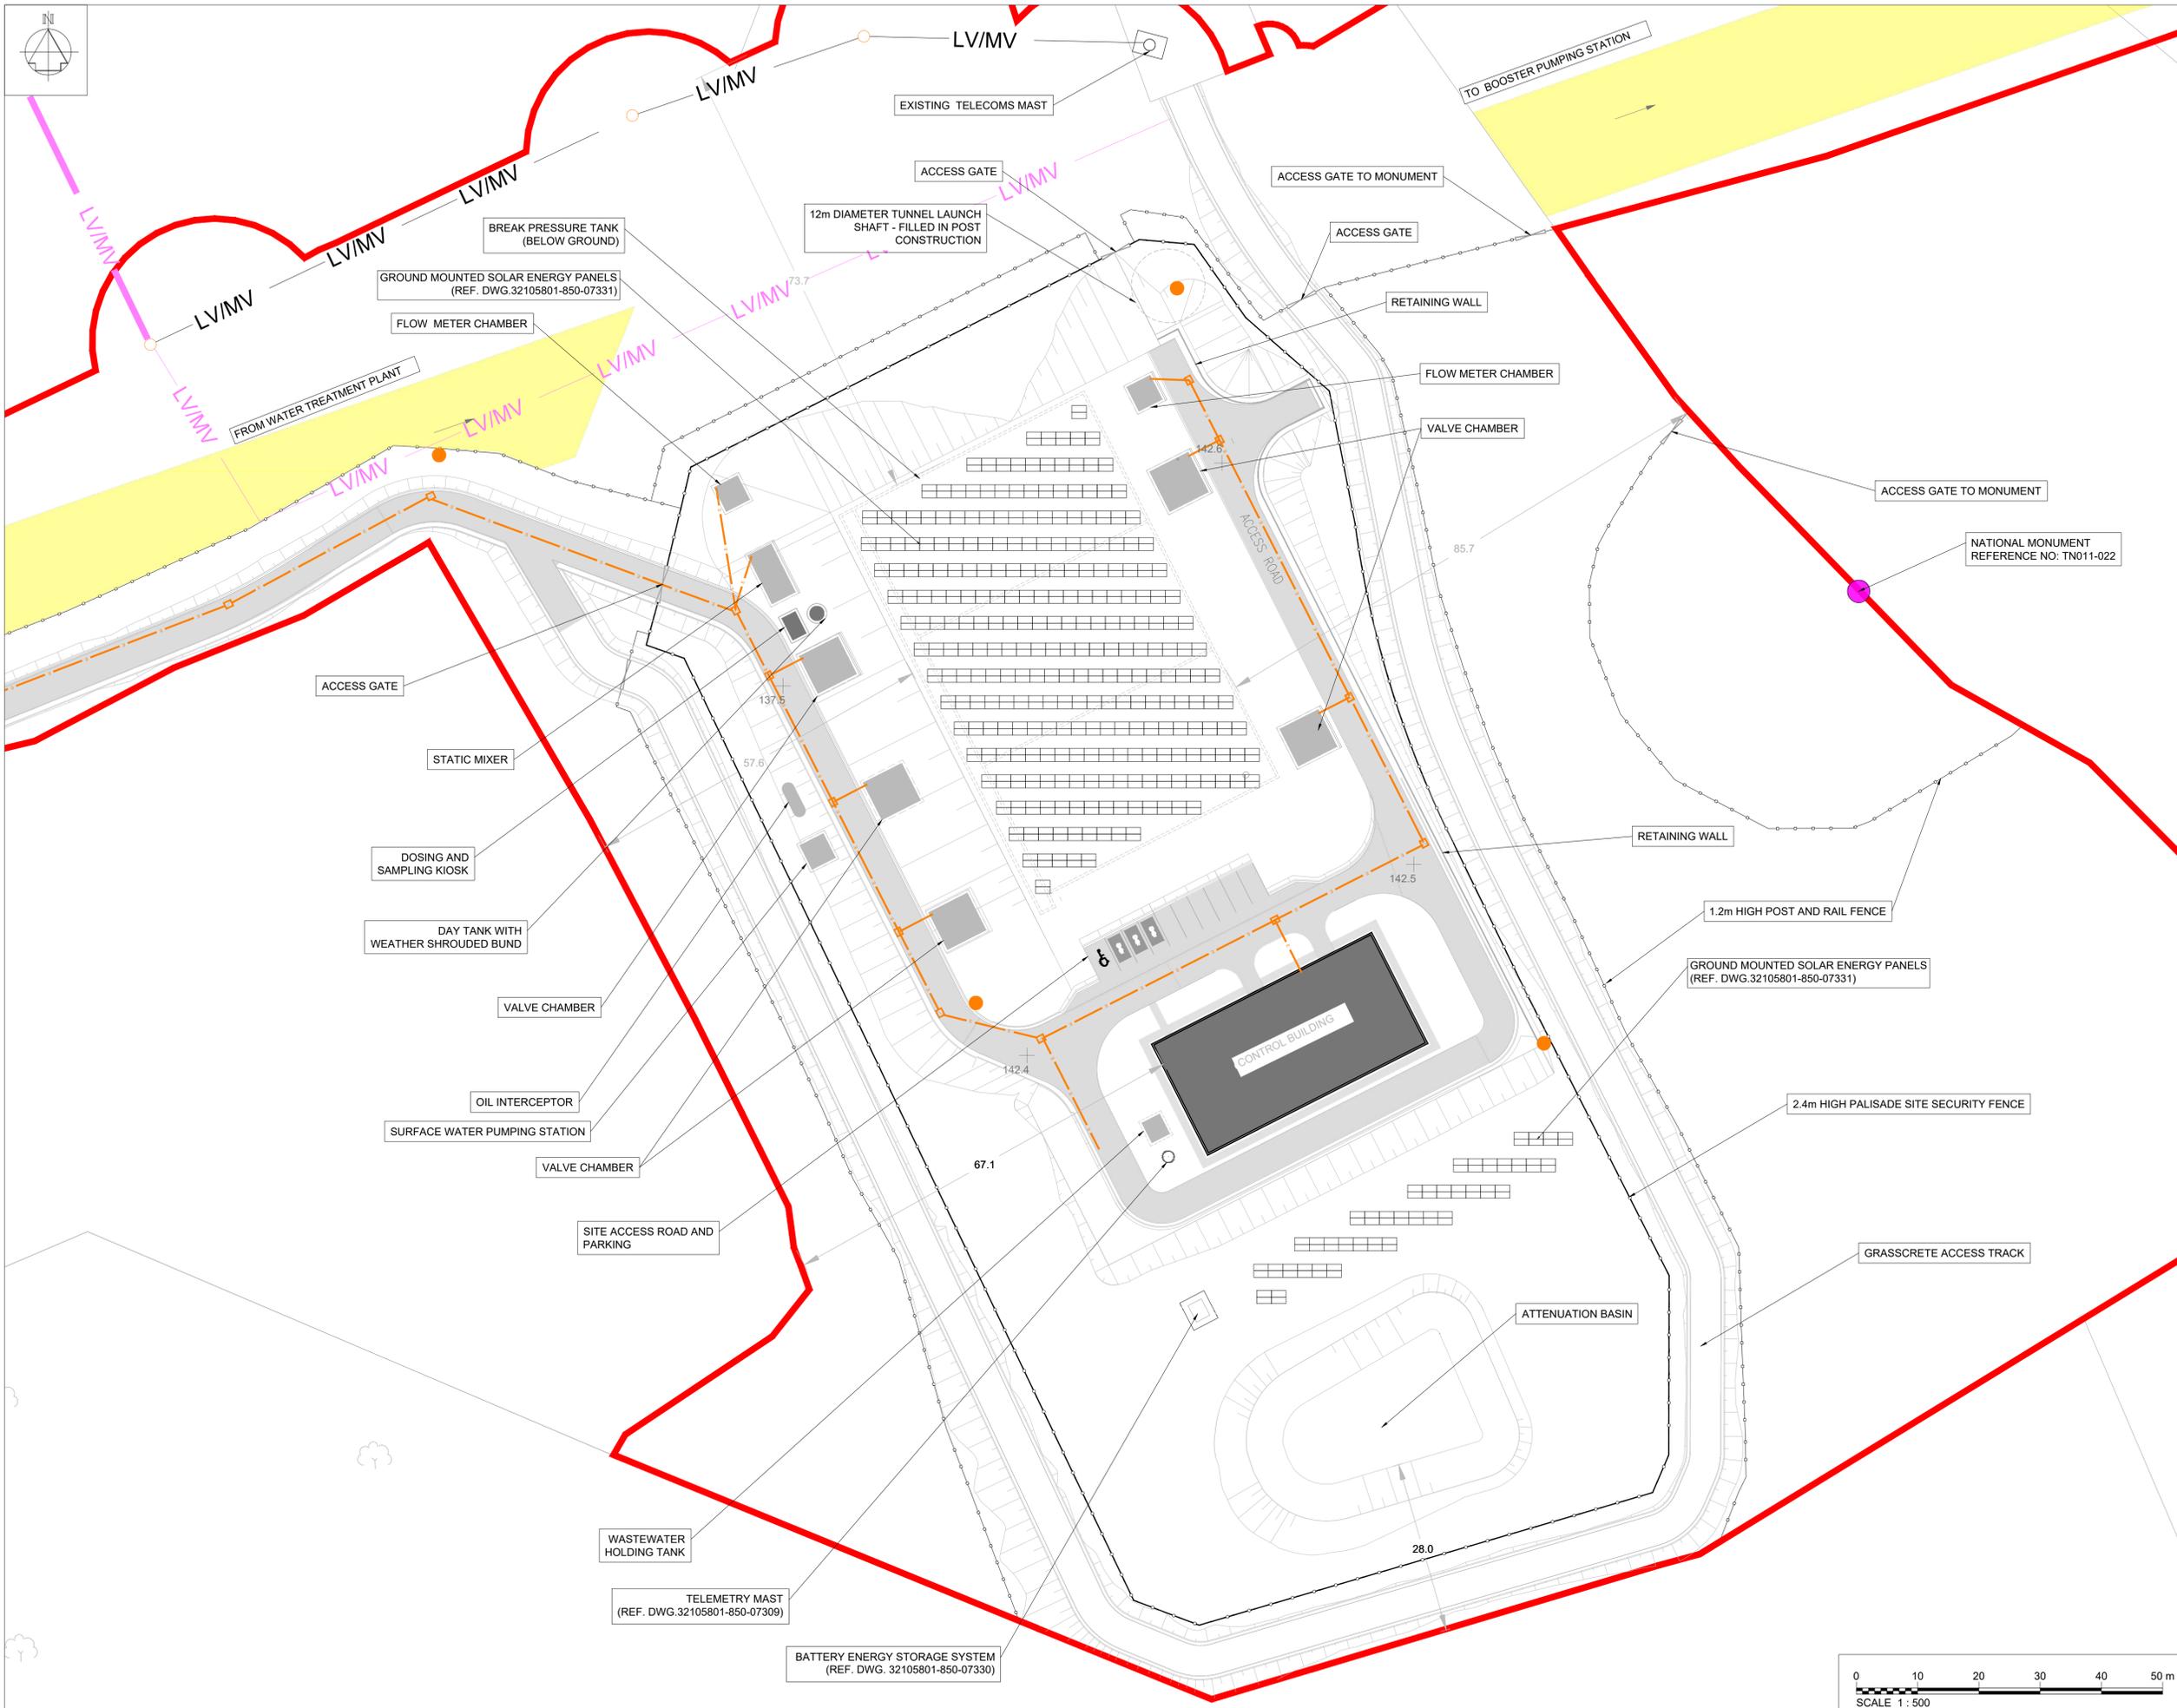

- Notes:
1. THIS DRAWING IS NOT TO BE SCALED. FIGURED DIMENSIONS ONLY TO BE TAKEN
  2. ALL DIMENSIONS ARE IN METRES AND ALL LEVELS ARE IN METRES AOD MALIN HEAD UNLESS OTHERWISE STATED.
  3. THE PIPELINE HORIZONTAL ALIGNMENTS ARE SUBJECT TO FURTHER DEVELOPMENT. ANY CHANGES WILL BE SUBJECT TO THE LIMITS AND CONDITIONS DETAILED IN THE PLANNING SUBMISSION.
  4. THIS DRAWING IS FOR PLANNING PURPOSES ONLY.

- LEGEND:
- PLANNING APPLICATION BOUNDARY
  - INDICATIVE PERMANENT WAYLEAVE
- EXISTING:
- NATIONAL MONUMENT
  - LV/MV ELECTRIC OVERHEAD POWERLINE, LOW/MEDIUM VOLTAGE
- PROPOSED:
- 1.2m HIGH POST AND RAIL FENCE
  - 2.4m HIGH PALISADE SITE SECURITY FENCE
  - ELECTRICAL NETWORK CABLES AND ACCESS CHAMBER
  - ROAD / HARDSTAND SURFACE
  - BUILDING
  - BELOW GROUND STRUCTURES
  - EV CHARGING POINT
  - DISABLED PARKING SPACE
  - SOLAR ENERGY PANELS
  - LV/MV ELECTRIC OVERHEAD POWERLINES
  - POWER POLES
  - CCTV DROP DOWN POLE
  - LV/MV ELECTRIC OVERHEAD POWERLINE, LOW/MEDIUM VOLTAGE TO BE ABANDONED

OSI Sheet No's:  
4046, 4105-A.

Rev	Description	Drawn	Chk'd	App'd.	Date
F02	FINAL FOR PLANNING	AP	MG	SW	Dec.25
F01	FINAL FOR PLANNING	AP	MG	SW	Dec.25

This drawing is the property of Uisce Éireann and must not be copied or used for any purpose other than that for which it is supplied without the written consent of Uisce Éireann.

**Uisce Éireann**  
Irish Water

**Tionscadal Soláthair Uisce**  
Water Supply Project

UISCE ÉIREANN  
COLVILL HOUSE,  
TALBOT STREET,  
DUBLIN 1,  
IRELAND

Call 1890 278 278  
Int: 00 353 1 707 2828

# JACOBS TOBIN

Originated By	Drawn By	Checked By	Approved By
DM	AP	MG	SW
Date	Date	Date	Date
19.07.19	01.12.2025	01.12.2025	01.12.2025

Scale: 1:500 @ A1 FINAL

Project Title  
WATER SUPPLY PROJECT  
EASTERN AND MIDLANDS REGION

Drawing Title  
BREAK PRESSURE TANK  
PROPOSED ELECTRICAL SERVICE PLAN

Drawing Status: FINAL FOR PLANNING  
Jacobs Tobin No. 32105801 Client No. 9318

Drawing No.  
**32105801-850-03023**

