

Copyright © Ordnance Survey Ireland.
Licence number 3/3/34/Uisce Éireann.
Survey Ireland and Government of Ireland

Original Size
A1

Notes:

1. THE PROPOSED WORKS WILL BE ENTIRELY INSIDE THE EXISTING SITE BOUNDARIES.
2. THIS DRAWING IS NOT TO BE SCALED. FIGURED DIMENSIONS ONLY TO BE TAKEN.
3. ALL DIMENSIONS ARE IN METRES AND ALL LEVELS ARE IN METRES AOD MALIN HEAD UNLESS OTHERWISE STATED.
4. THIS DRAWING IS FOR PLANNING PURPOSES ONLY.

LEGEND:

- PLANNING APPLICATION BOUNDARY
- INDICATIVE PERMANENT WAYLEAVE
- PERMANENT WAYLEAVE FOR EXISTING 1200mm MAIN

EXISTING:


- BLOCK AND RAIL FENCE

PROPOSED:

- PROPOSED 2.4m HIGH PALISADE SITE SECURITY FENCE
- PROPOSED 1.2m POST AND RAIL FENCE

OSI Sheet No's:

3325-A, 3325-B, 3325-C, 3325-D.

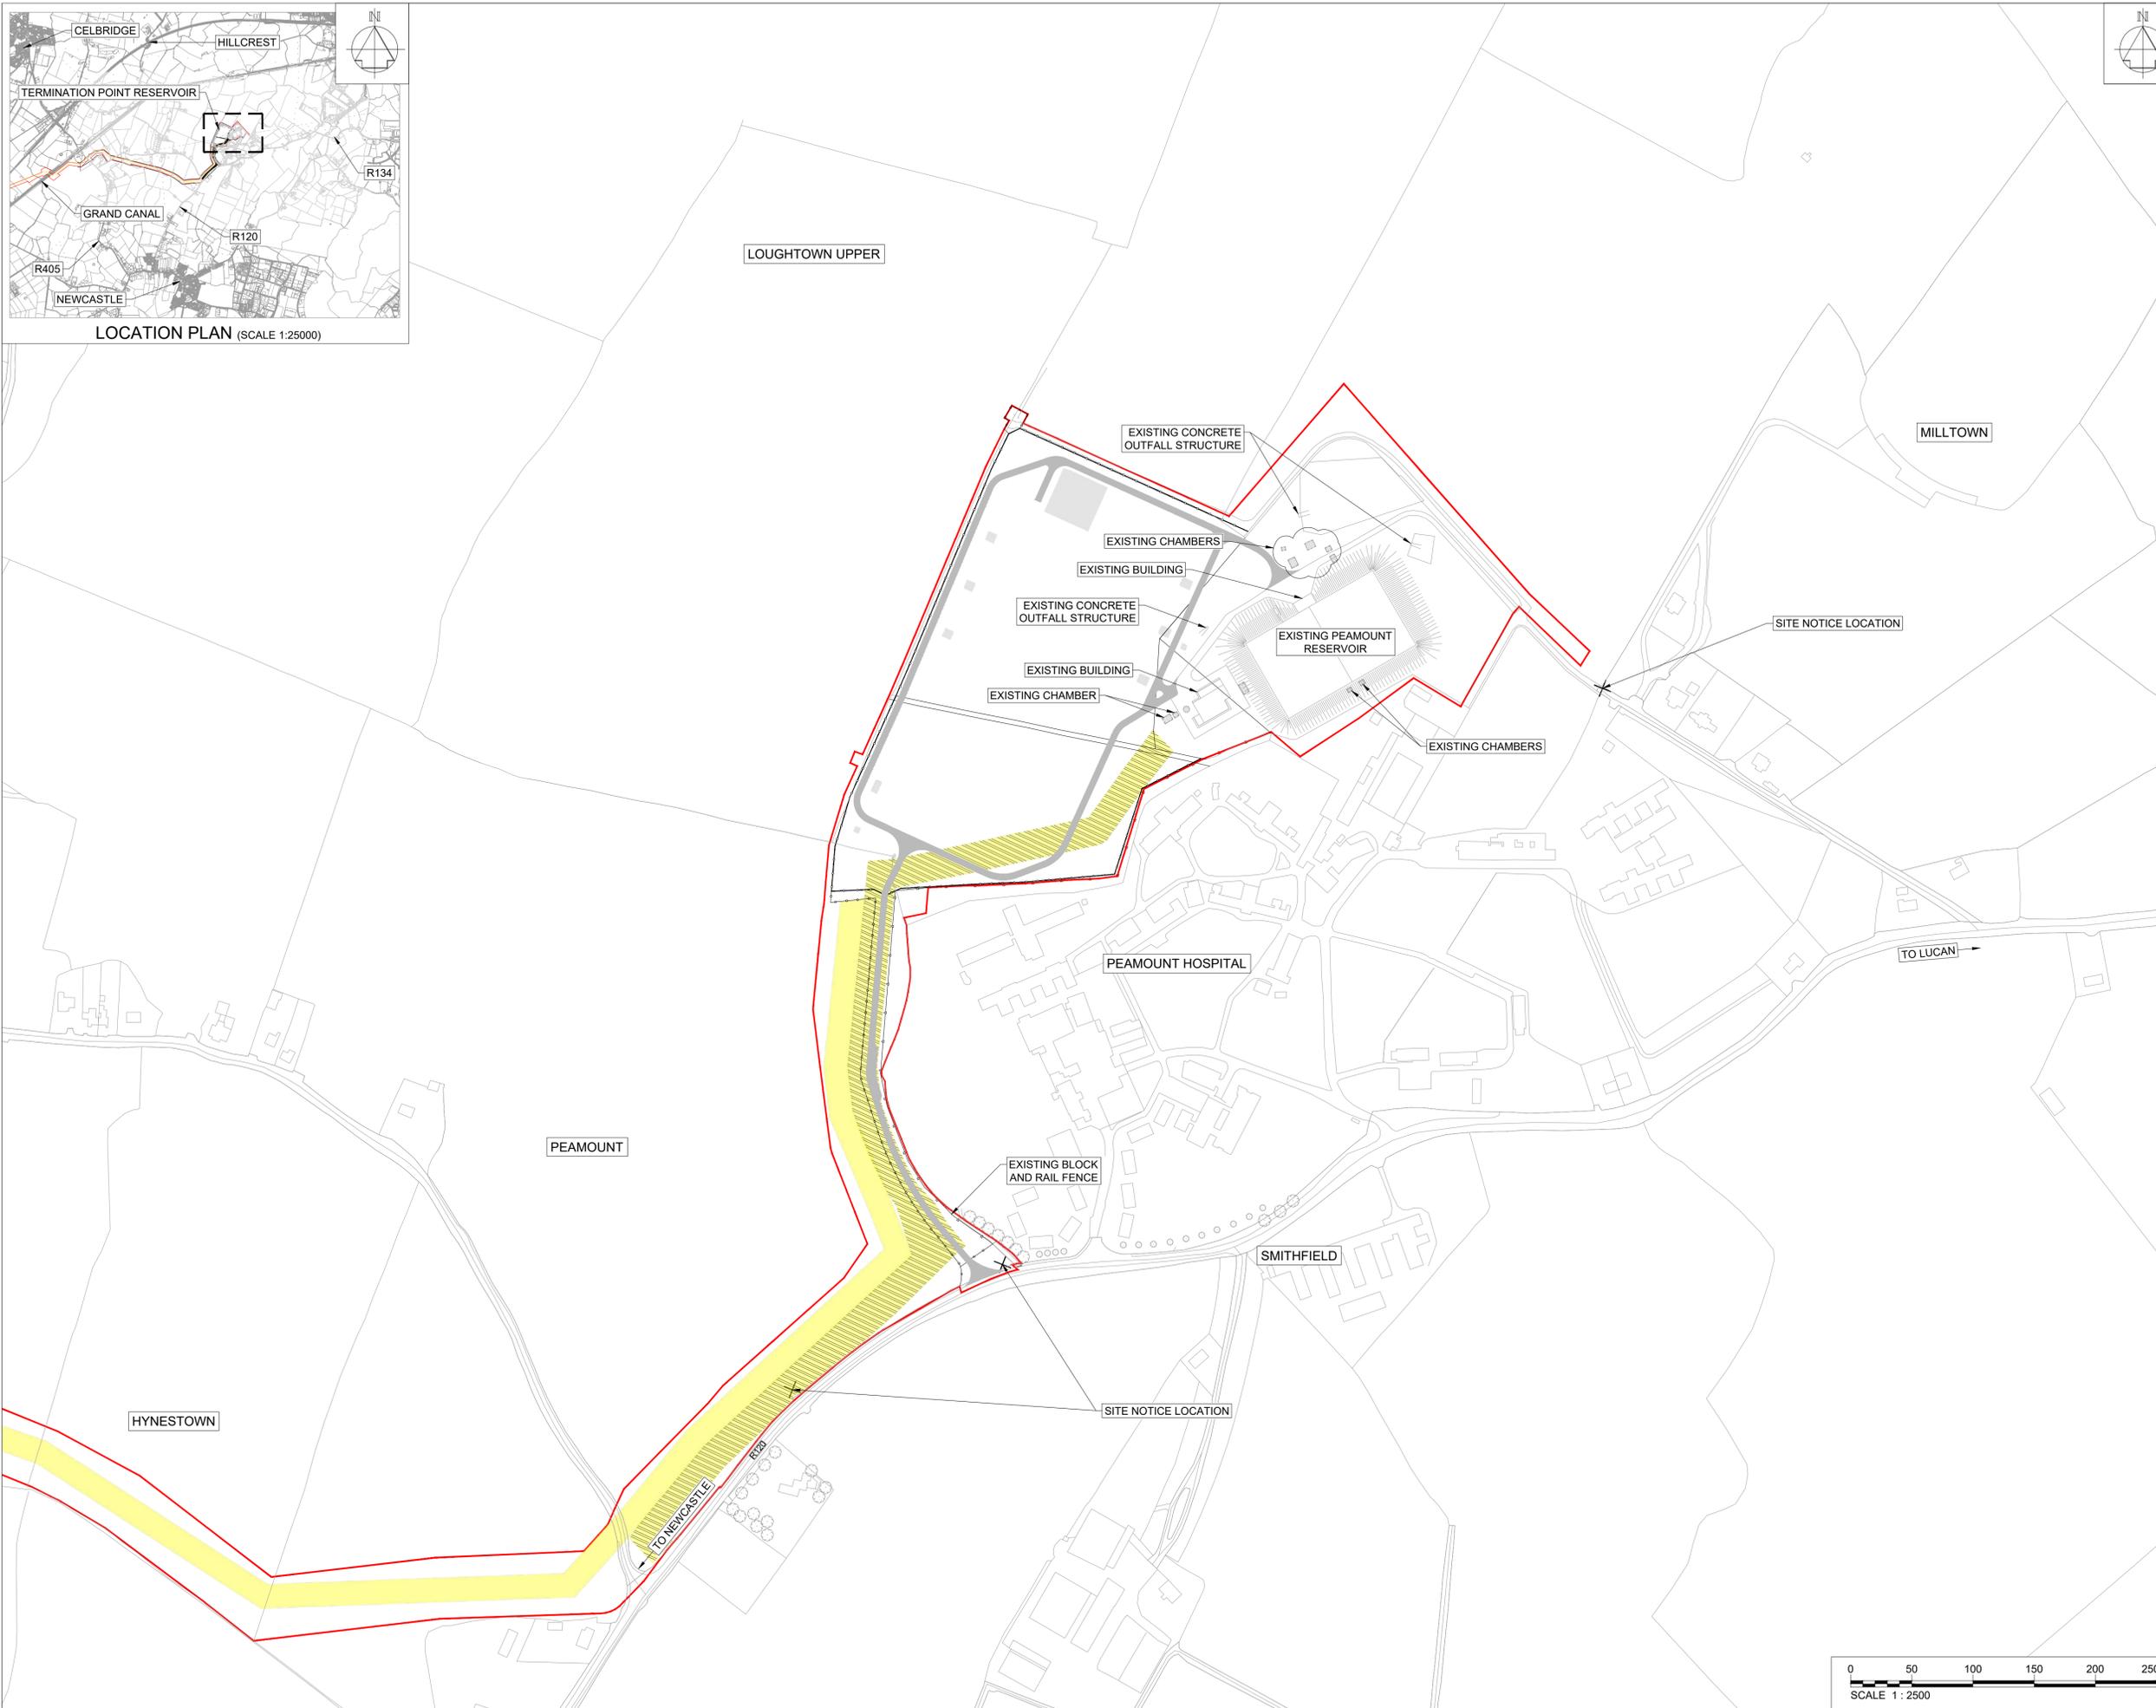

F02	FINAL FOR PLANNING	PC	MG	SW	Dec. 2025
F01	FINAL FOR PLANNING	PC	MG	SW	Dec. 2025
Rev	Description	Drawn	Chk'd	App'd.	Date

This drawing is the property of Uisce Éireann and must not be copied or used for any purpose other than that for which it is supplied without the written consent of Uisce Éireann.

Uisce Éireann
Irish Water

Tionscadal Soláthair Uisce
Water Supply Project

UISCE ÉIREANN
COLVILL HOUSE,
TALBOT STREET,
DUBLIN 1,
IRELAND

Call 1890 278 278
Int: 00 353 1 707 2828

JACOBS TOBIN

Originated By MON	Drawn By AP	Checked By MG	Approved By SW
Date 21.09.23	Date 21.09.23	Date 01.12.2025	Date 01.12.2025

Scale: 1:2500 @ A1 FINAL


Project Title
WATER SUPPLY PROJECT
EASTERN AND MIDLANDS REGION

Drawing Title
TERMINATION POINT RESERVOIR
SITE LOCATION PLAN

Drawing Status: FINAL FOR PLANNING
Jacobs Tobin No. 32105801 Client No. 9318

Drawing No.
32105801-850-06000




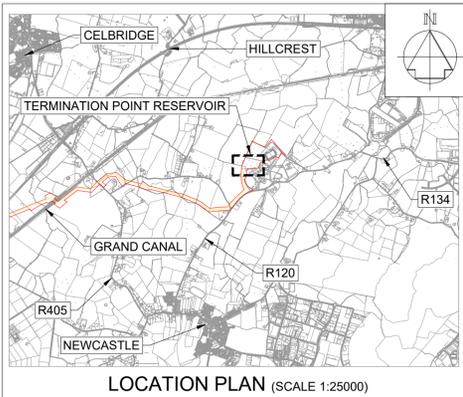

- Notes:
1. THE PROPOSED WORKS WILL BE ENTIRELY INSIDE THE EXISTING SITE BOUNDARIES.
 2. THIS DRAWING IS NOT TO BE SCALED. FIGURED DIMENSIONS ONLY TO BE TAKEN.
 3. THIS DRAWING IS FOR PLANNING PURPOSES ONLY.

- LEGEND:
- PLANNING APPLICATION BOUNDARY
 - PERMANENT WAYLEAVE FOR EXISTING 1200mm MAIN
- EXISTING:
- ELECTRIC OVERHEAD POWERLINE LOW/MEDIUM VOLTAGE
 - BLOCK AND RAIL FENCE

OSI Sheet No's:
3325-A.

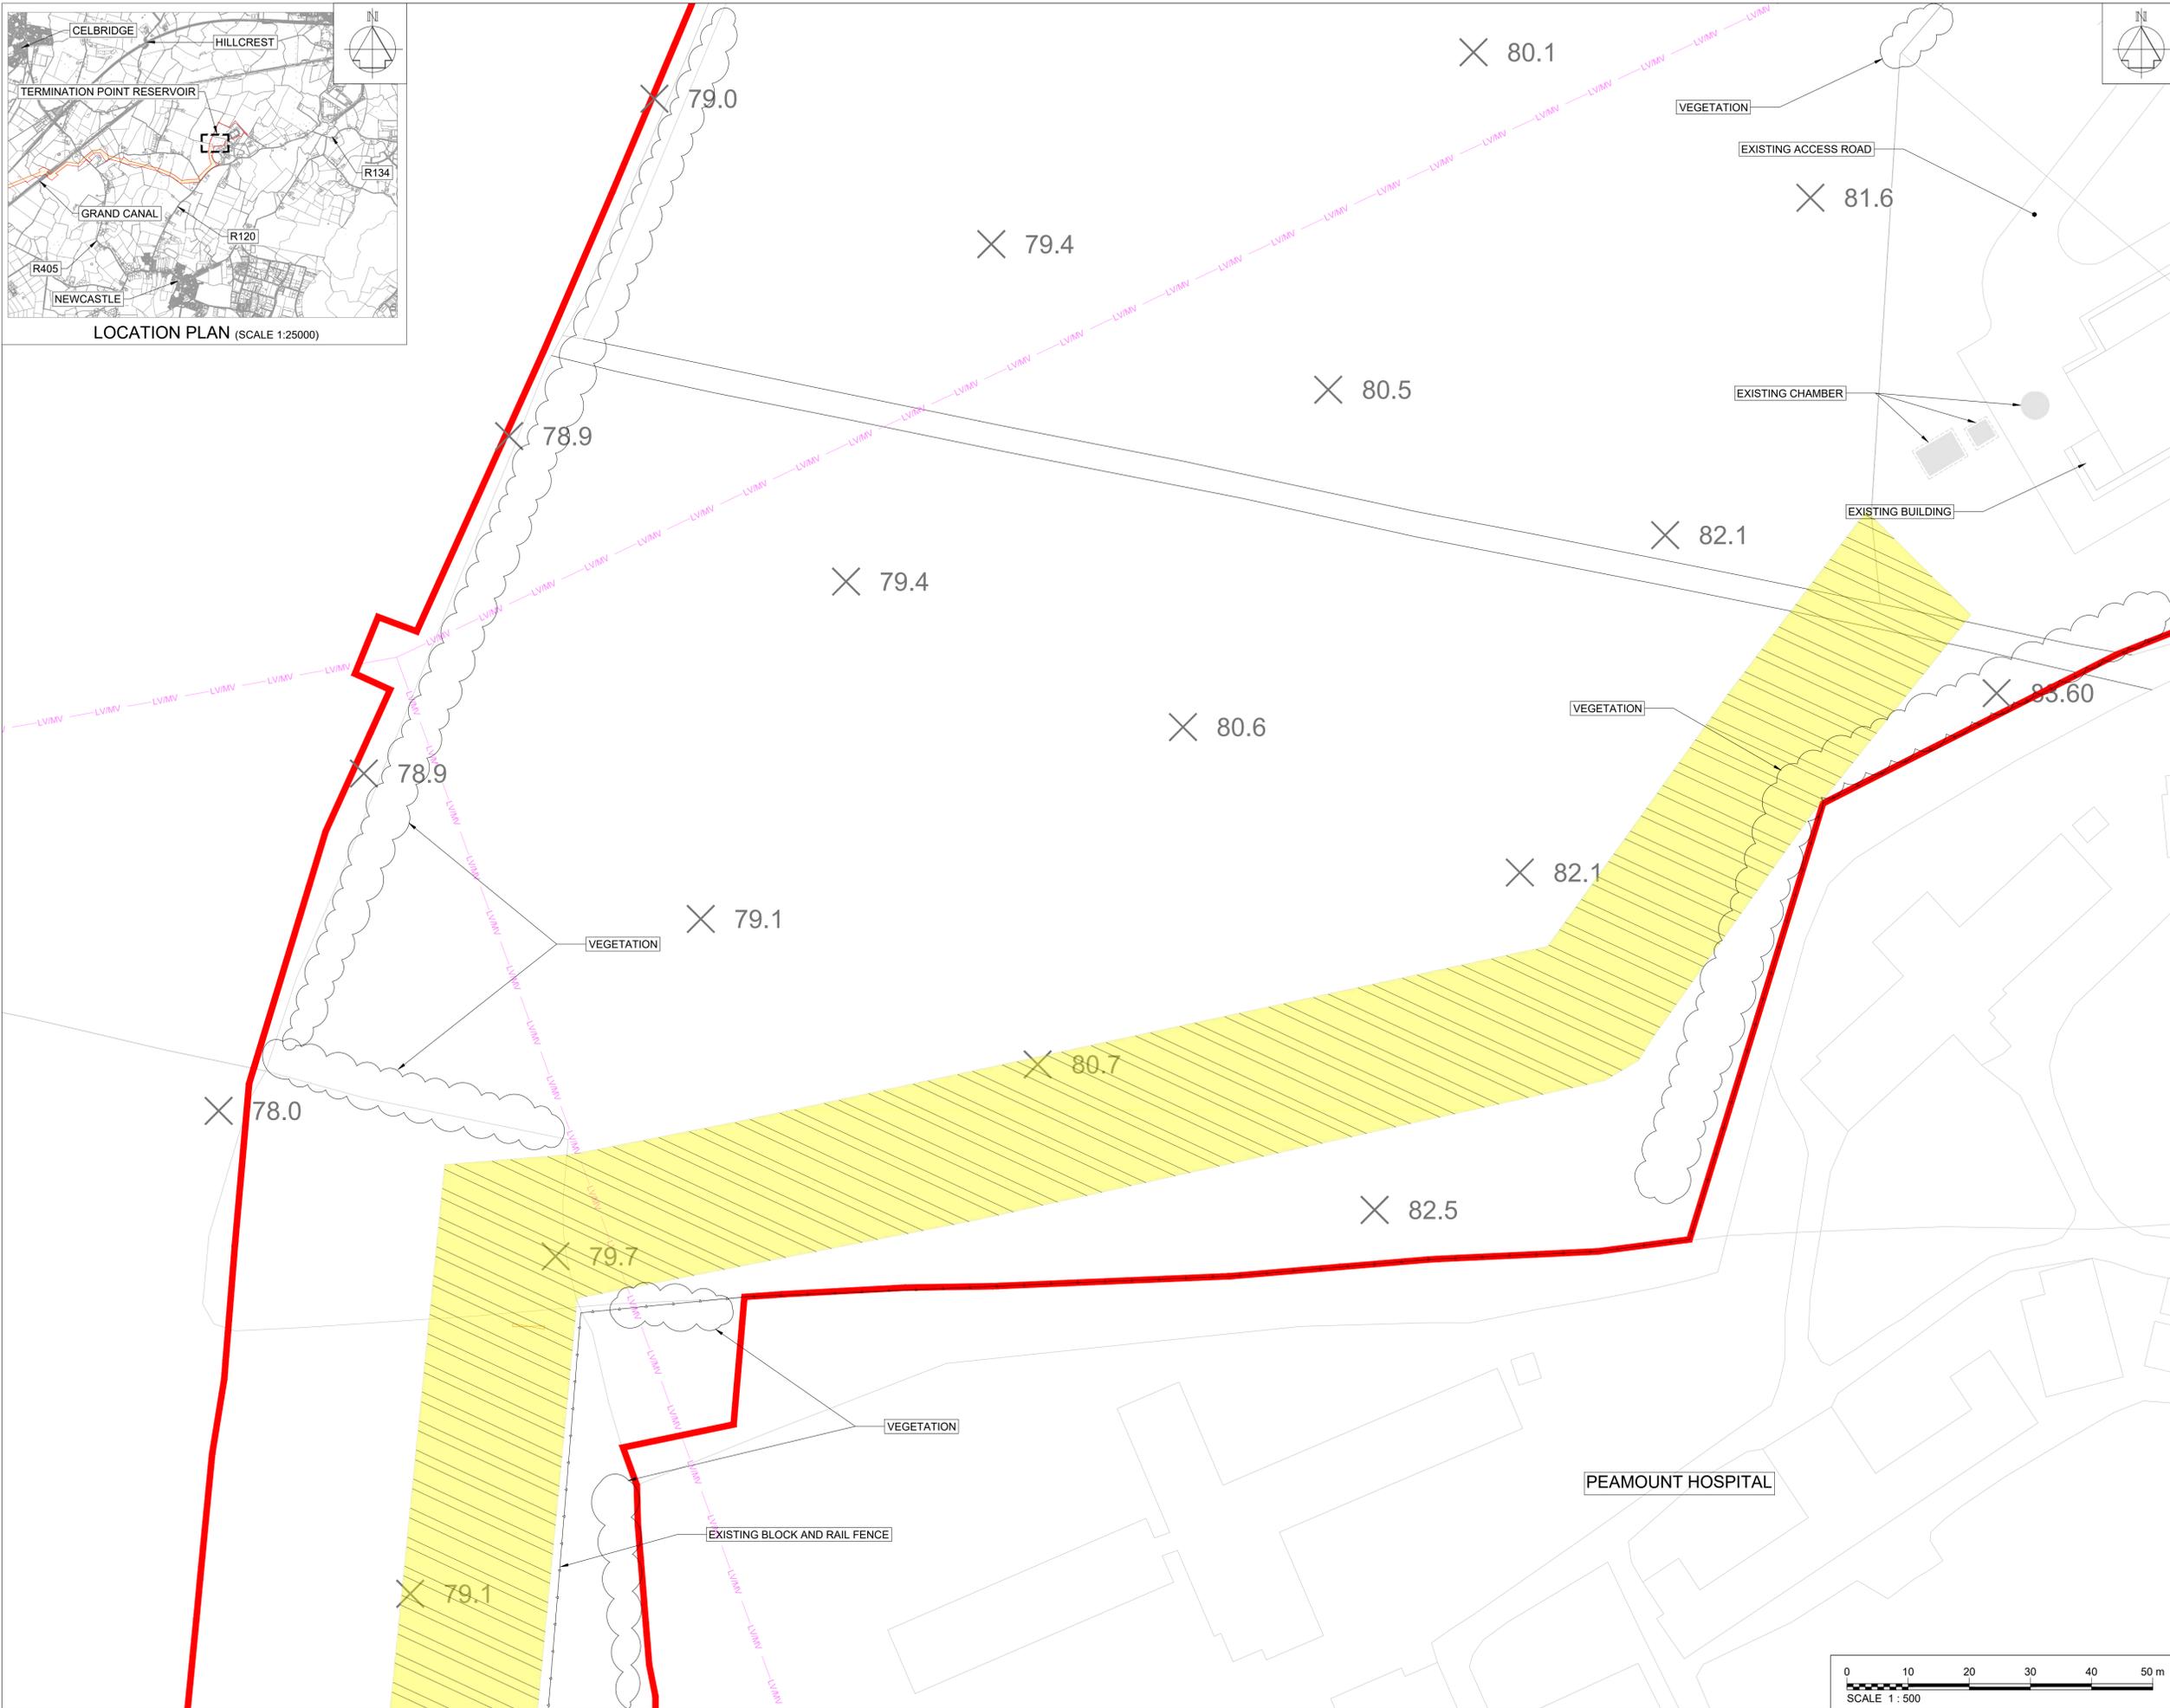

F02	FINAL FOR PLANNING	PC	MG	SW	Dec. 25
F01	FINAL FOR PLANNING	PC	MG	SW	Dec. 25
Rev	Description	Drawn	Chkd	App'd.	Date

This drawing is the property of Uisce Éireann and must not be copied or used for any purpose other than that for which it is supplied without the written consent of Uisce Éireann.

Uisce Éireann
Irish Water

Tionscadal Soláthair Uisce
Water Supply Project

UISCE ÉIREANN
COLVILL HOUSE,
TALBOT STREET,
DUBLIN 1,
IRELAND

Call 1890 278 278
Int: 00 353 1 707 2828

JACOBS TOBIN

Originated By MON	Drawn By AP	Checked By MG	Approved By SW
Date 21.09.23	Date 01.12.2025	Date 01.12.2025	Date 01.12.2025


Scale: 1:500 @ A1 FINAL


Project Title
WATER SUPPLY PROJECT
EASTERN AND MIDLANDS REGION

Drawing Title
TERMINATION POINT RESERVOIR
EXISTING SITE LAYOUT
SHEET 01

Drawing Status: FINAL FOR PLANNING
Jacobs Tobin No. 32105801 | Client No. 9318

 Drawing No.
32105801-850-06001





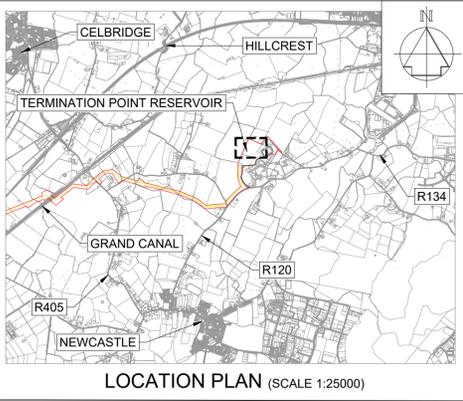

Notes:
1. THE PROPOSED WORKS WILL BE ENTIRELY INSIDE THE EXISTING SITE BOUNDARIES.
2. THIS DRAWING IS NOT TO BE SCALED. FIGURED DIMENSIONS ONLY TO BE TAKEN.
3. THIS DRAWING IS FOR PLANNING PURPOSES ONLY.

LEGEND:
 PLANNING APPLICATION BOUNDARY
 PERMANENT WAYLEAVE FOR EXISTING 1200mm MAIN
 EXISTING:
 ELECTRIC OVERHEAD POWERLINE LOW/MEDIUM VOLTAGE
 BLOCK AND RAIL FENCE

 OSI Sheet No's:
3325-A.

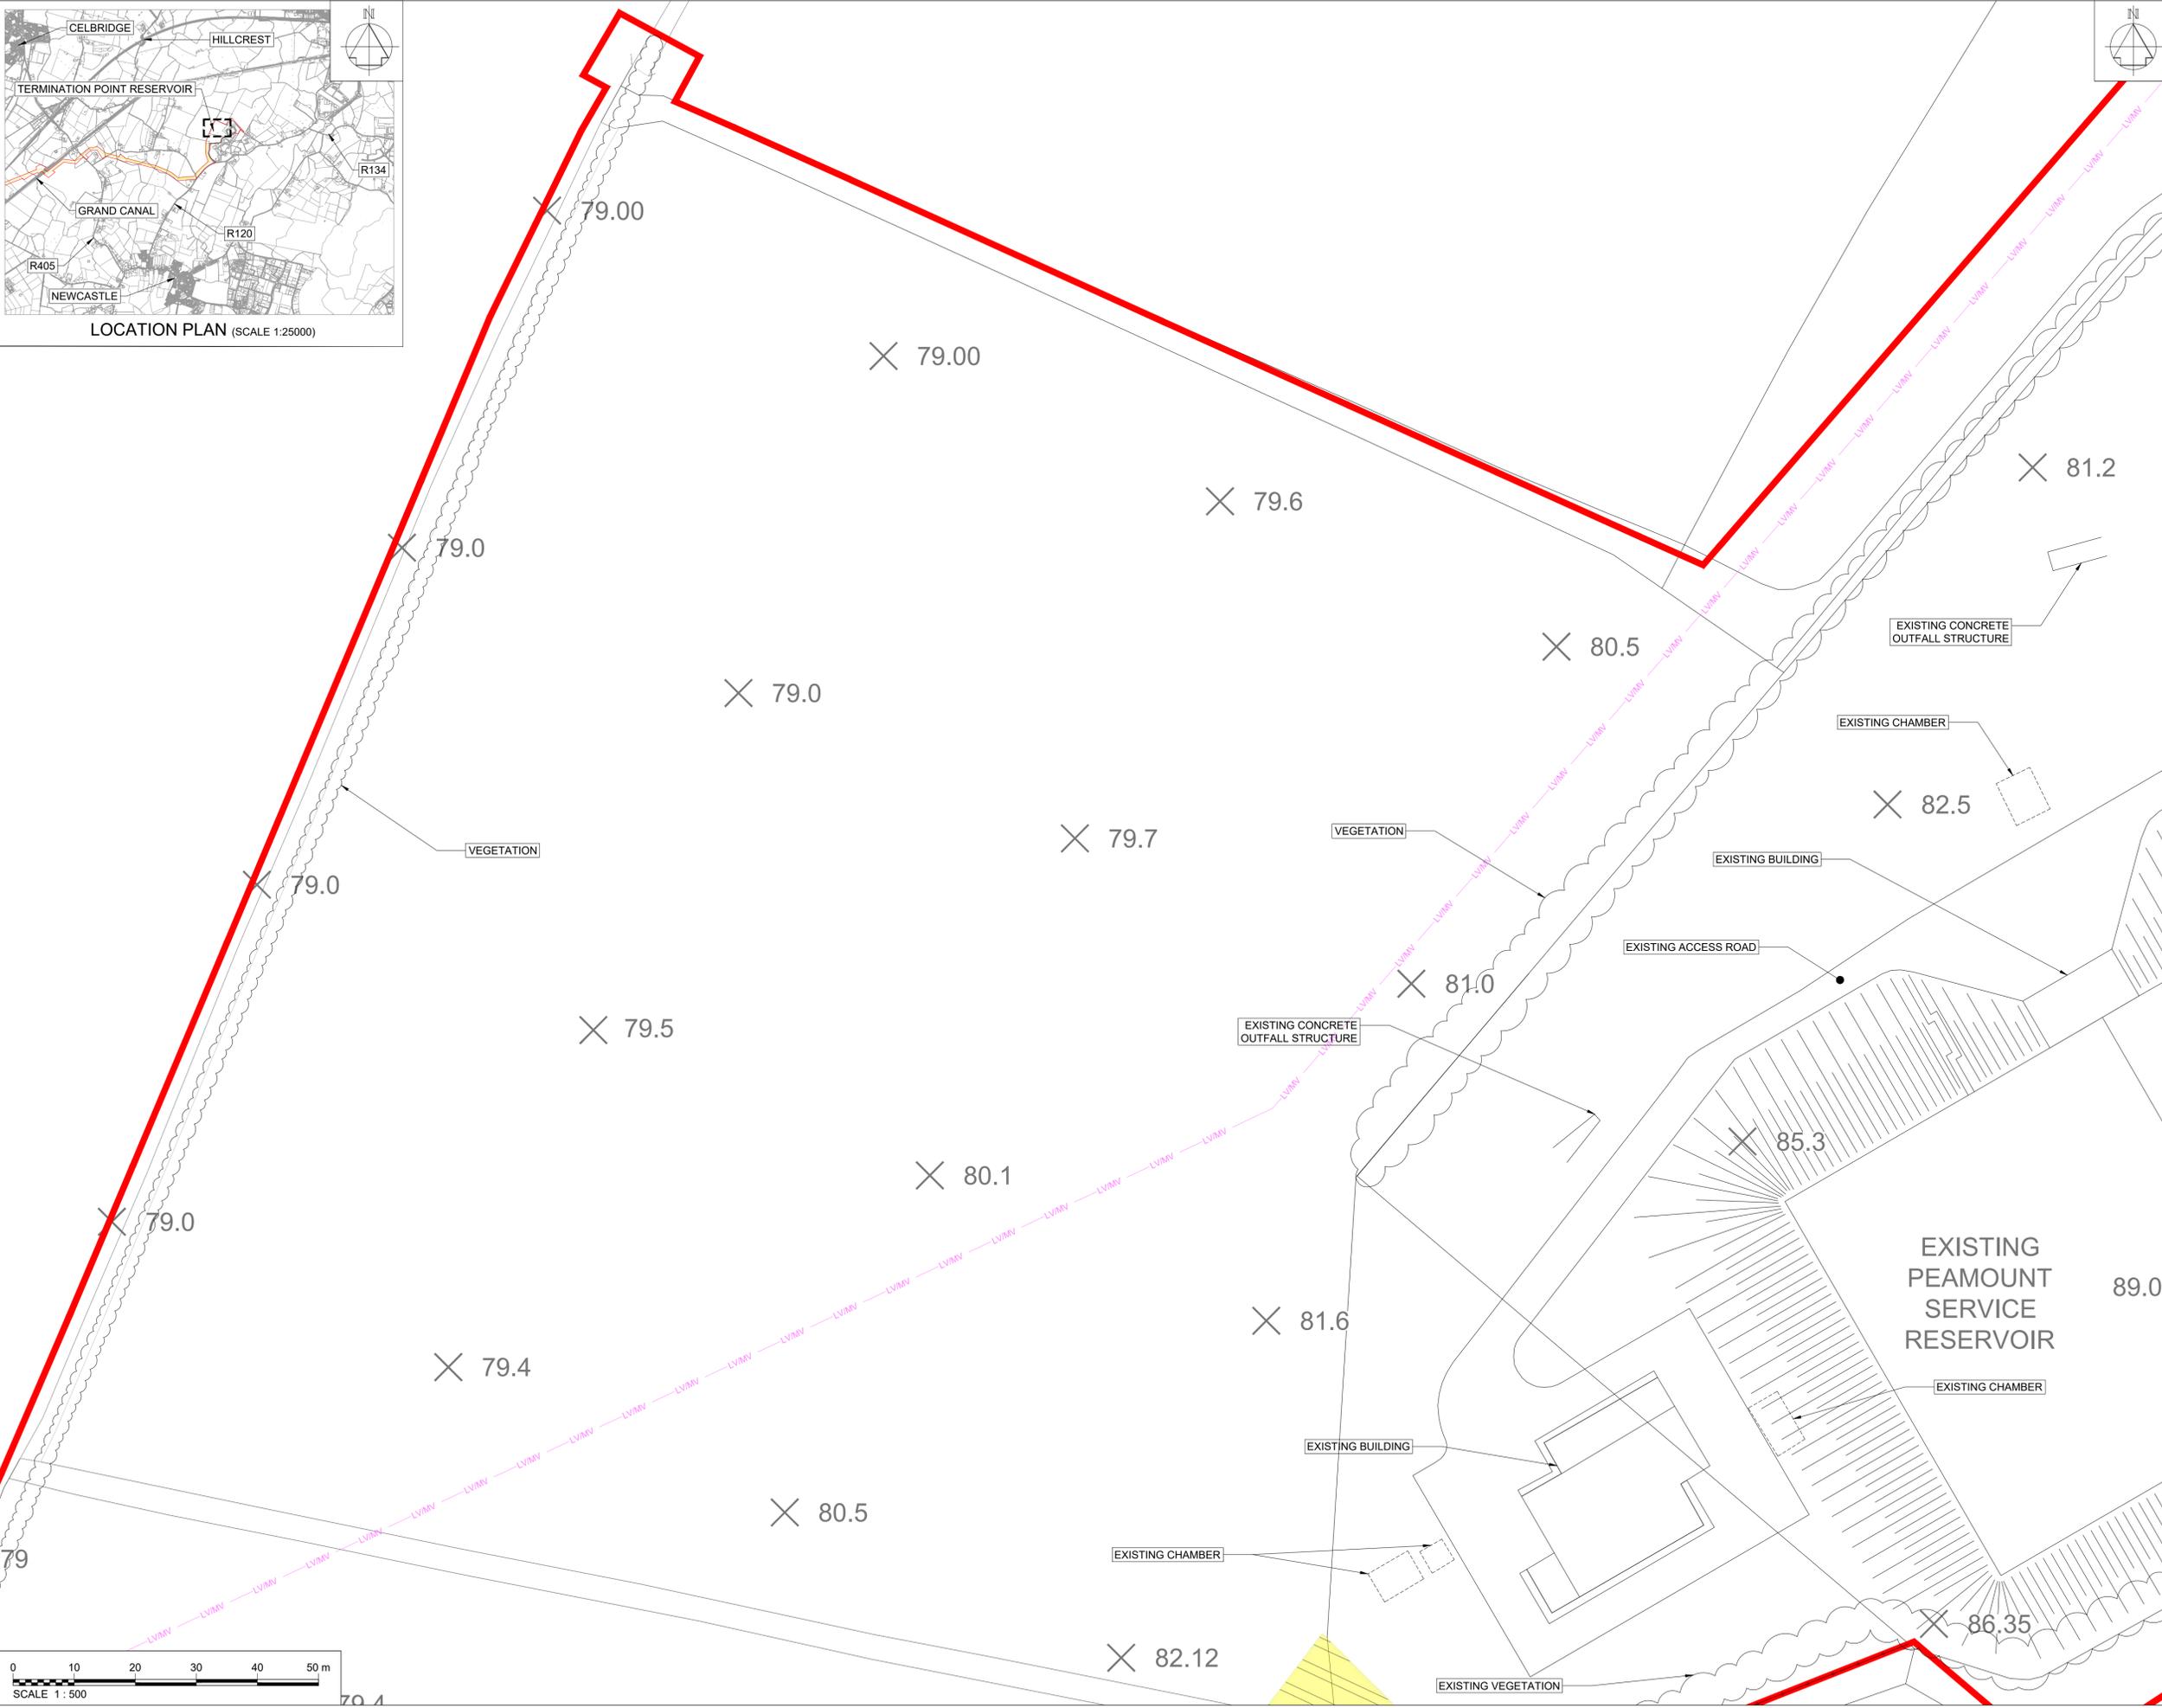

F02	FINAL FOR PLANNING	AP	MG	SM	Dec. 2025
F01	FINAL FOR PLANNING	AP	MG	SM	Dec. 2025
Rev	Description	Drawn	Chk'd	App'd.	Date

This drawing is the property of Uisce Éireann and must not be copied or used for any purpose other than that for which it is supplied without the written consent of Uisce Éireann.

Uisce Éireann
 COLVILL HOUSE,
 TALBOT STREET,
 DUBLIN 1,
 IRELAND
 Tionscald Soláthair Uisce
 Water Supply Project
 Call 1890 278 278
 Int: 00 353 1 707 2828

JACOBS TOBIN

Originated By MON	Drawn By AP	Checked By MG	Approved By SW
Date 21.09.23	Date 01.12.2025	Date 01.12.2025	Date 01.12.2025



Scale: 1:500 @ A1 **FINAL**

Project Title
WATER SUPPLY PROJECT
EASTERN AND MIDLANDS REGION

Drawing Title
TERMINATION POINT RESERVOIR
EXISTING SITE LAYOUT
SHEET 02

Drawing Status: FINAL FOR PLANNING
 Jacobs Tobin No. 32105801 | Client No. 9318

Drawing No.
32105801-850-06002

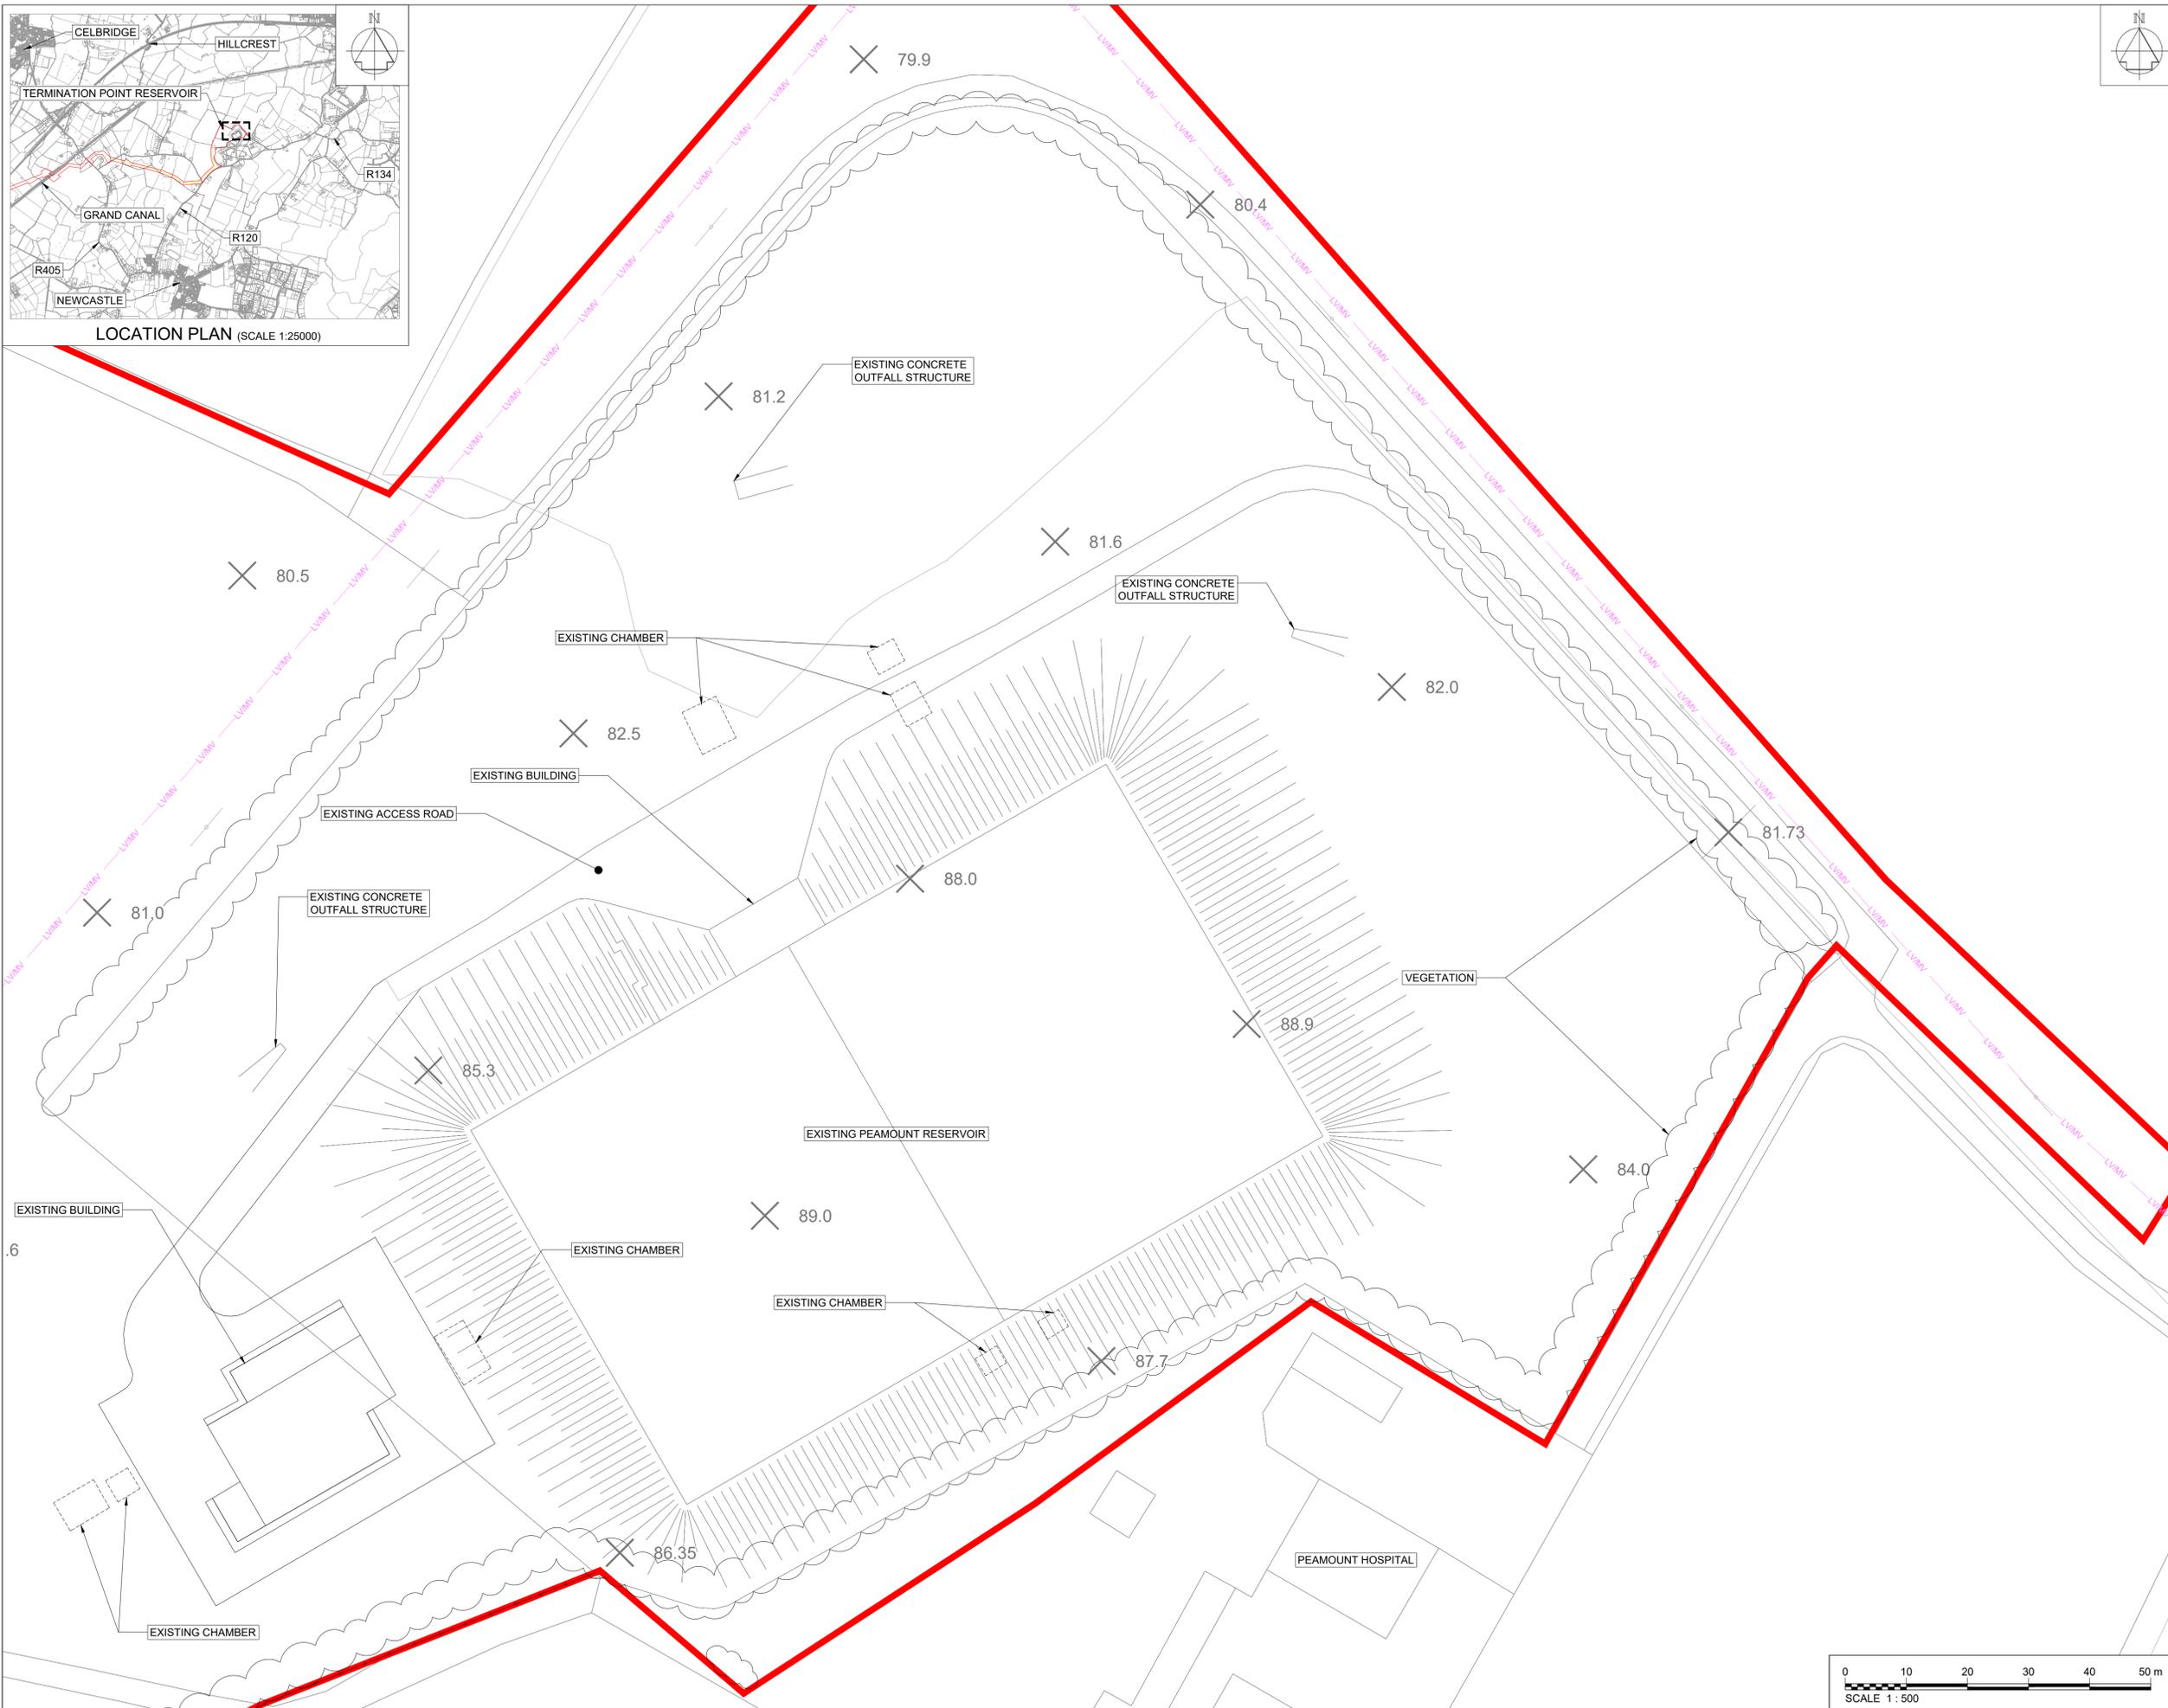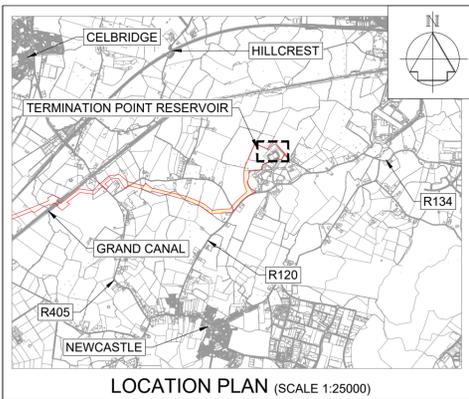

- Notes:
1. THE PROPOSED WORKS WILL BE ENTIRELY INSIDE THE EXISTING SITE BOUNDARIES.
 2. THIS DRAWING IS NOT TO BE SCALED. FIGURED DIMENSIONS ONLY TO BE TAKEN.
 3. THIS DRAWING IS FOR PLANNING PURPOSES ONLY.

- LEGEND:
- PLANNING APPLICATION BOUNDARY
- EXISTING:
- - - - - LV/MV ELECTRIC OVERHEAD POWERLINE LOW/MEDIUM VOLTAGE
 - BLOCK AND RAIL FENCE

OSI Sheet No's:
3325-A.

F02	FINAL FOR PLANNING	AP	MG	SM	Dec. 2025
F01	FINAL FOR PLANNING	AP	MG	SM	Dec. 2025
Rev	Description	Drawn	Chk'd	App'd.	Date

This drawing is the property of Uisce Éireann and must not be copied or used for any purpose other than that for which it is supplied without the written consent of Uisce Éireann.

Uisce Éireann
Irish Water

Tionscadal Soláthair Uisce
Water Supply Project

UISCE ÉIREANN
COLVILL HOUSE,
TALBOT STREET,
DUBLIN 1,
IRELAND

Call 1890 278 278
Int: 00 353 1 707 2828

JACOBS TOBIN

Originated By MON	Drawn By AP	Checked By MG	Approved By SW
Date 21.09.23	Date 01.12.2025	Date 01.12.2025	Date 01.12.2025


Scale: 1:500 @ A1 **FINAL**



Project Title
**WATER SUPPLY PROJECT
EASTERN AND MIDLANDS REGION**

Drawing Title
**TERMINATION POINT RESERVOIR
EXISTING SITE LAYOUT
SHEET 03**

Drawing Status: FINAL FOR PLANNING
Jacobs Tobin No. 32105801 | Client No. 9318

 Drawing No.
32105801-850-06003



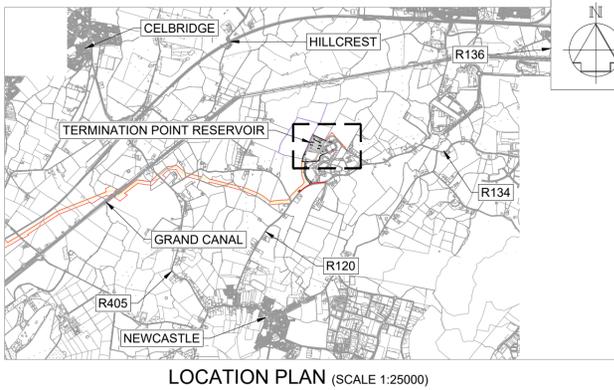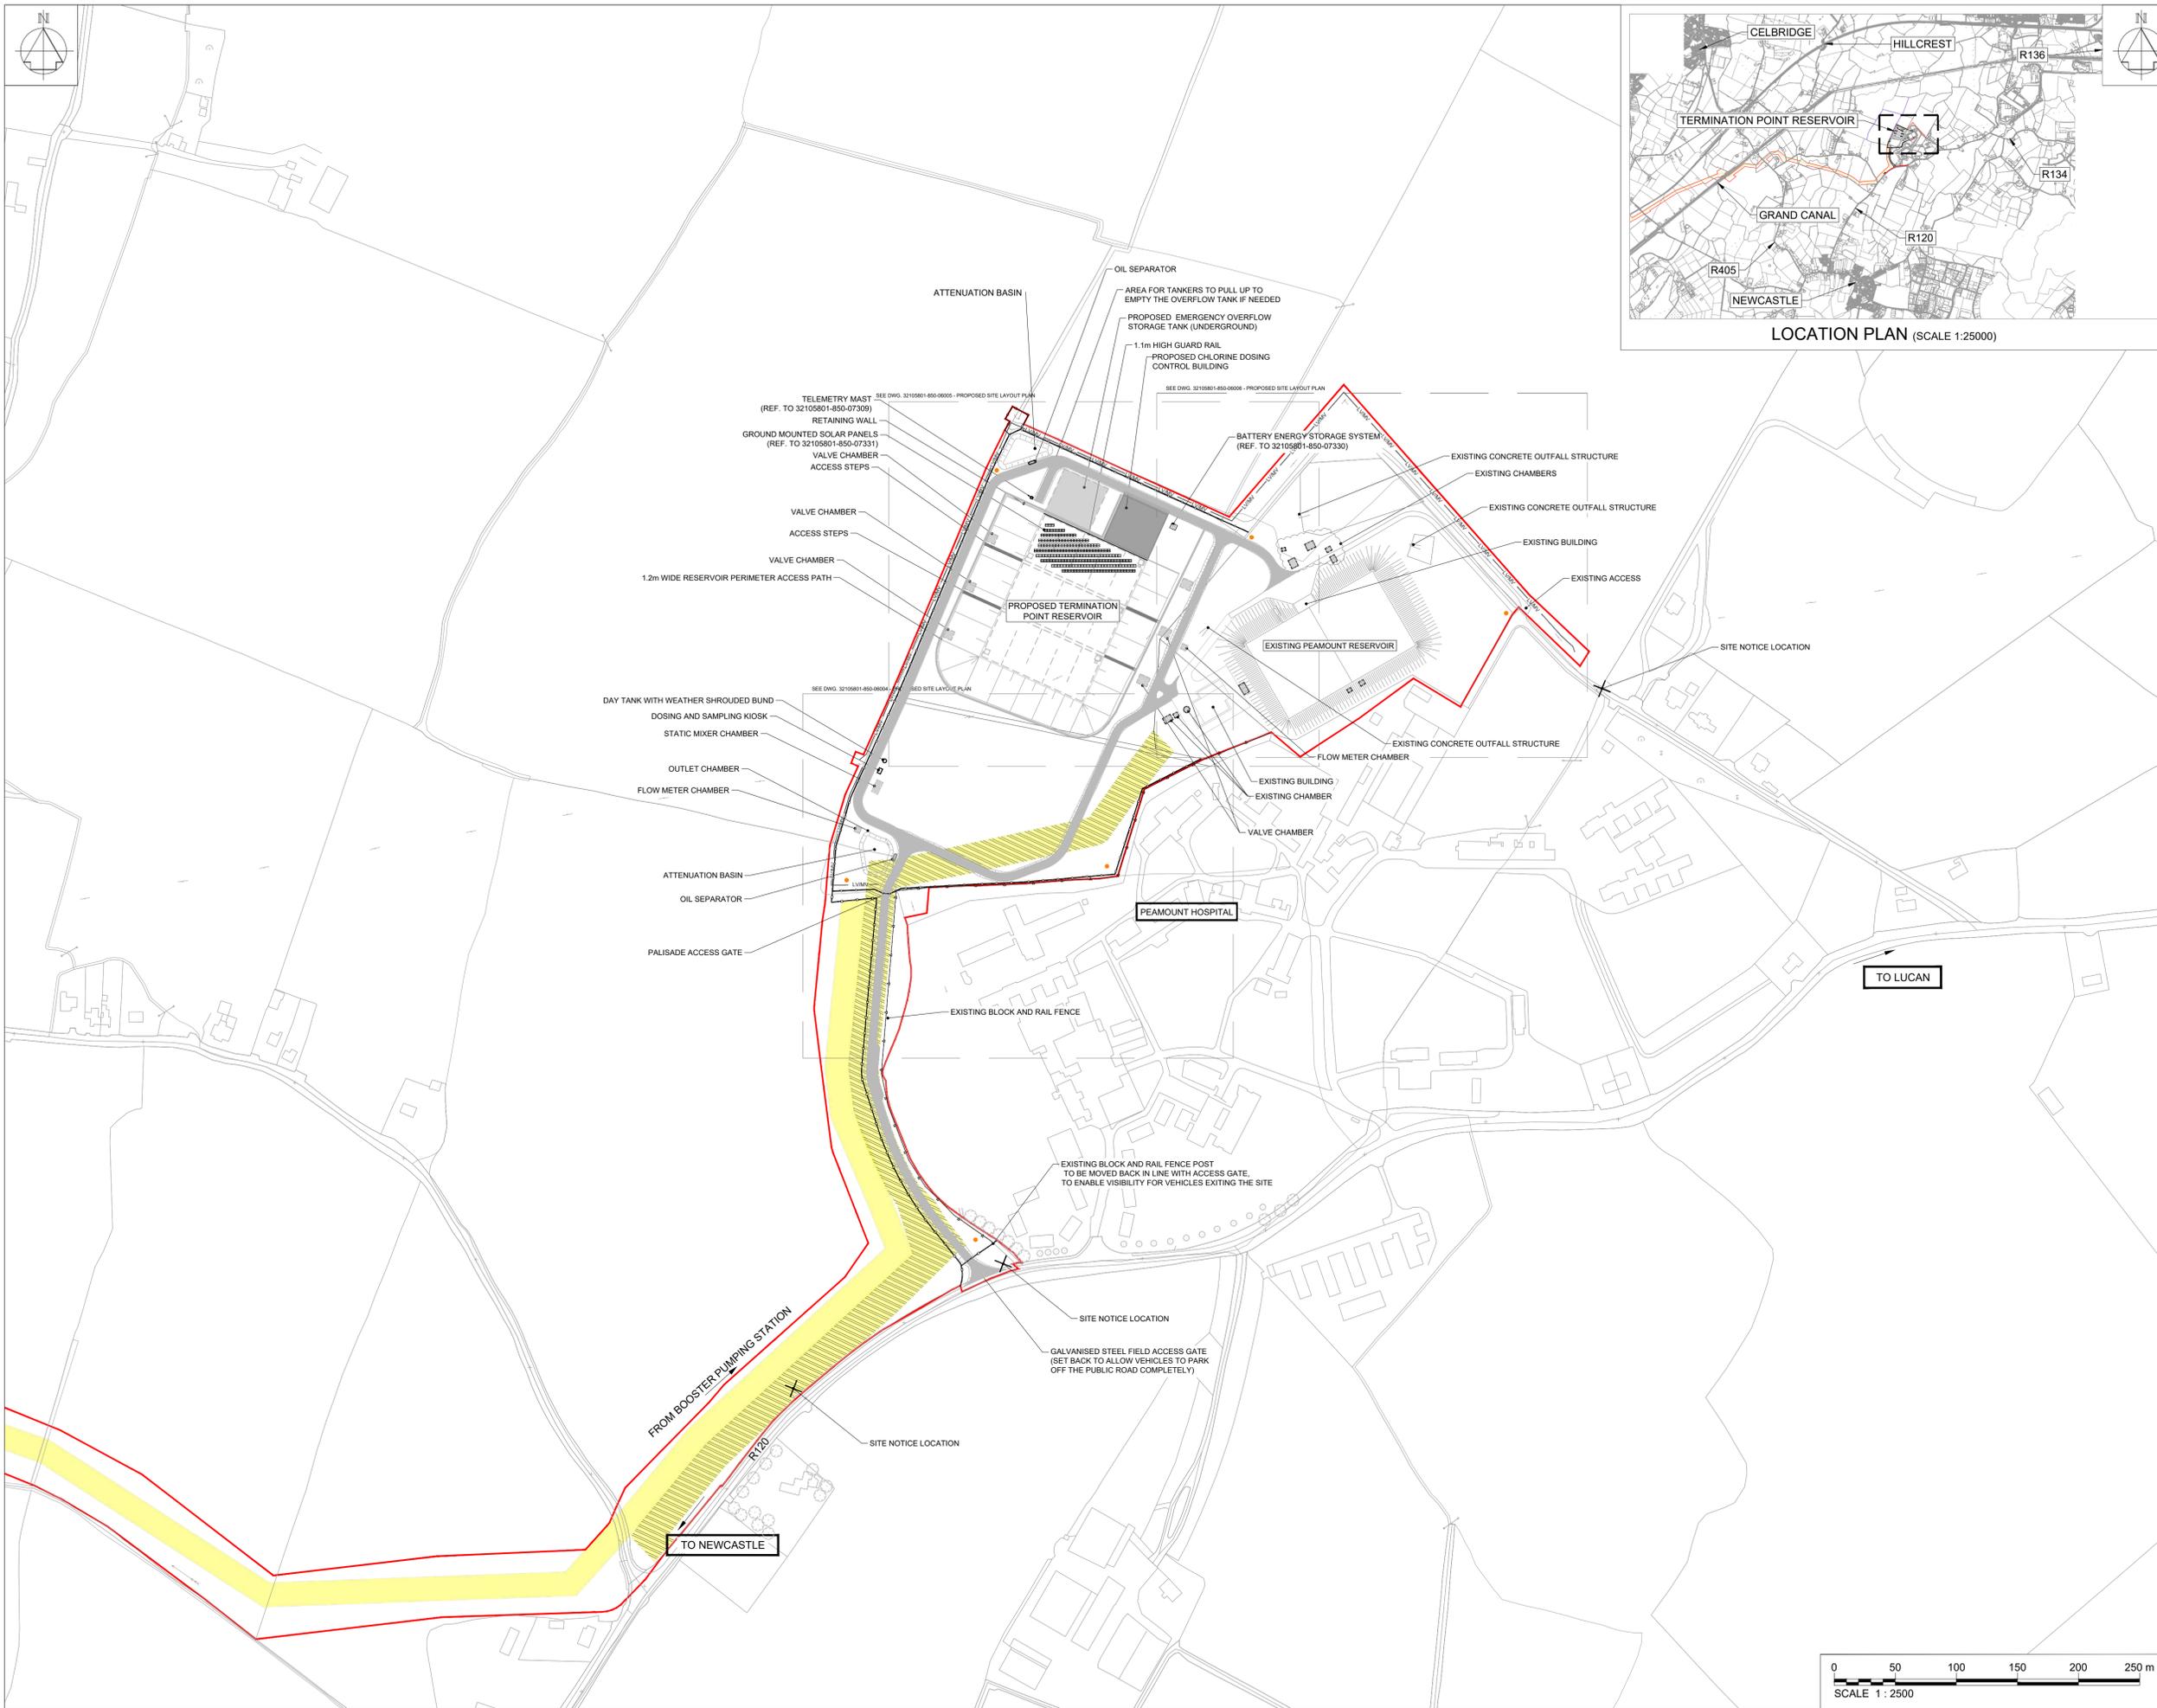

- Notes:
1. THE PROPOSED WORKS WILL BE ENTIRELY INSIDE THE EXISTING SITE BOUNDARIES.
 2. THIS DRAWING IS NOT TO BE SCALED. FIGURED DIMENSIONS ONLY TO BE TAKEN.
 3. THIS DRAWING IS FOR PLANNING PURPOSES ONLY.

- LEGEND:
- PLANNING APPLICATION BOUNDARY
 - INDICATIVE PERMANENT WAYLEAVE
 - PERMANENT WAYLEAVE FOR EXISTING 1200mm MAIN

- EXISTING:
- BLOCK AND RAIL FENCE
- PROPOSED:
- 1.2m HIGH POST AND RAIL FENCE
 - 2.4m HIGH PALISADE SITE SECURITY FENCE
 - ESBN LINE DIVERSION
 - ROAD / HARDSTAND SURFACE
 - BUILDING
 - BELOW GROUND STRUCTURES
 - SOLAR ENERGY PANELS
 - CCTV DROP DOWN POLE

OSI Sheet No's:
 3325-A, 3325-C.

F02	FINAL FOR PLANNING	AL	MG	SW	Dec. 2025
F01	FINAL FOR PLANNING	AL	MG	SW	Dec. 2025
Rev	Description	Drawn	Chk'd	App'd.	Date

This drawing is the property of Uisce Éireann and must not be copied or used for any purpose other than that for which it is supplied without the written consent of Uisce Éireann.

Uisce Éireann
Irish Water

Tionscald Soláthair Uisce
Water Supply Project

UISCE ÉIREANN
 COLVILL HOUSE,
 TALBOT STREET,
 DUBLIN 1,
 IRELAND

Call 1890 278 278
 Int: 00 353 1 707 2828

Jacobs TOBIN

Originated By MON	Drawn By PC	Checked By MG	Approved By SW
Date 21.09.23	Date 01.12.2025	Date 01.12.2025	Date 01.12.2025

 
Scale: 1:2500 @ A1 FINAL

Project Title
 WATER SUPPLY PROJECT
 EASTERN AND MIDLANDS REGION

Drawing Title
 TERMINATION POINT RESERVOIR
 PROPOSED SITE LAYOUT PLAN

Drawing Status: FINAL FOR PLANNING
 Jacobs Tobin No. 32105801 Client No. 9318

Drawing No.
32105801-850-06099





- Notes:
1. ALL DIMENSIONS ARE IN METRES AND ALL LEVELS ARE IN METRES AOD MALIN HEAD UNLESS OTHERWISE STATED.
 2. THIS DRAWING IS NOT TO BE SCALED. FIGURED DIMENSIONS ONLY TO BE TAKEN.
 3. THIS DRAWING IS FOR PLANNING PURPOSES ONLY.

- LEGEND:
- PLANNING APPLICATION BOUNDARY
 - INDICATIVE PERMANENT WAYLEAVE
 - PERMANENT WAYLEAVE FOR EXISTING 1200mm MAIN
- EXISTING:
- BLOCK AND RAIL FENCE
 - ELECTRICAL OVERHEAD POWER LINE LOW/MEDIUM VOLTAGE
- PROPOSED:
- 1.2m HIGH POST AND RAIL FENCE
 - 2.4m HIGH PALISADE SITE SECURITY FENCE
 - ROAD / HARDSTAND SURFACE
 - BELOW GROUND STRUCTURES
 - CCTV DROP DOWN POLE
 - ESBN LINE DIVERSION

OSI Sheet No's:
3325-A.

F02	FINAL FOR PLANNING	AP	MG	SM	Dec. 2025
F01	FINAL FOR PLANNING	AP	MG	SM	Dec. 2025
Rev	Description	Drawn	Chkd	App'd.	Date

This drawing is the property of Uisce Éireann and must not be copied or used for any purpose other than that for which it is supplied without the written consent of Uisce Éireann.

Uisce Éireann
Irish Water

Tionscadal Soláthair Uisce
Water Supply Project

UISCE ÉIREANN
COLVILL HOUSE,
TALBOT STREET,
DUBLIN 1,
IRELAND

Call 1890 278 278
Int: 00 353 1 707 2828

JACOBS TOBIN

Originated By JMC	Drawn By AP	Checked By MG	Approved By SW
Date 17.01.18	Date 01.12.2025	Date 01.12.2025	Date 01.12.2025

Scale: 1:500 @ A1

 

Project Title
FINAL

WATER SUPPLY PROJECT
EASTERN AND MIDLANDS REGION

Drawing Title
TERMINATION POINT RESERVOIR
PROPOSED SITE LAYOUT PLAN
SHEET 01

Drawing Status: FINAL FOR PLANNING
Drawing No. 32105801 Client No. 9318

Drawing No.
32105801-850-06004

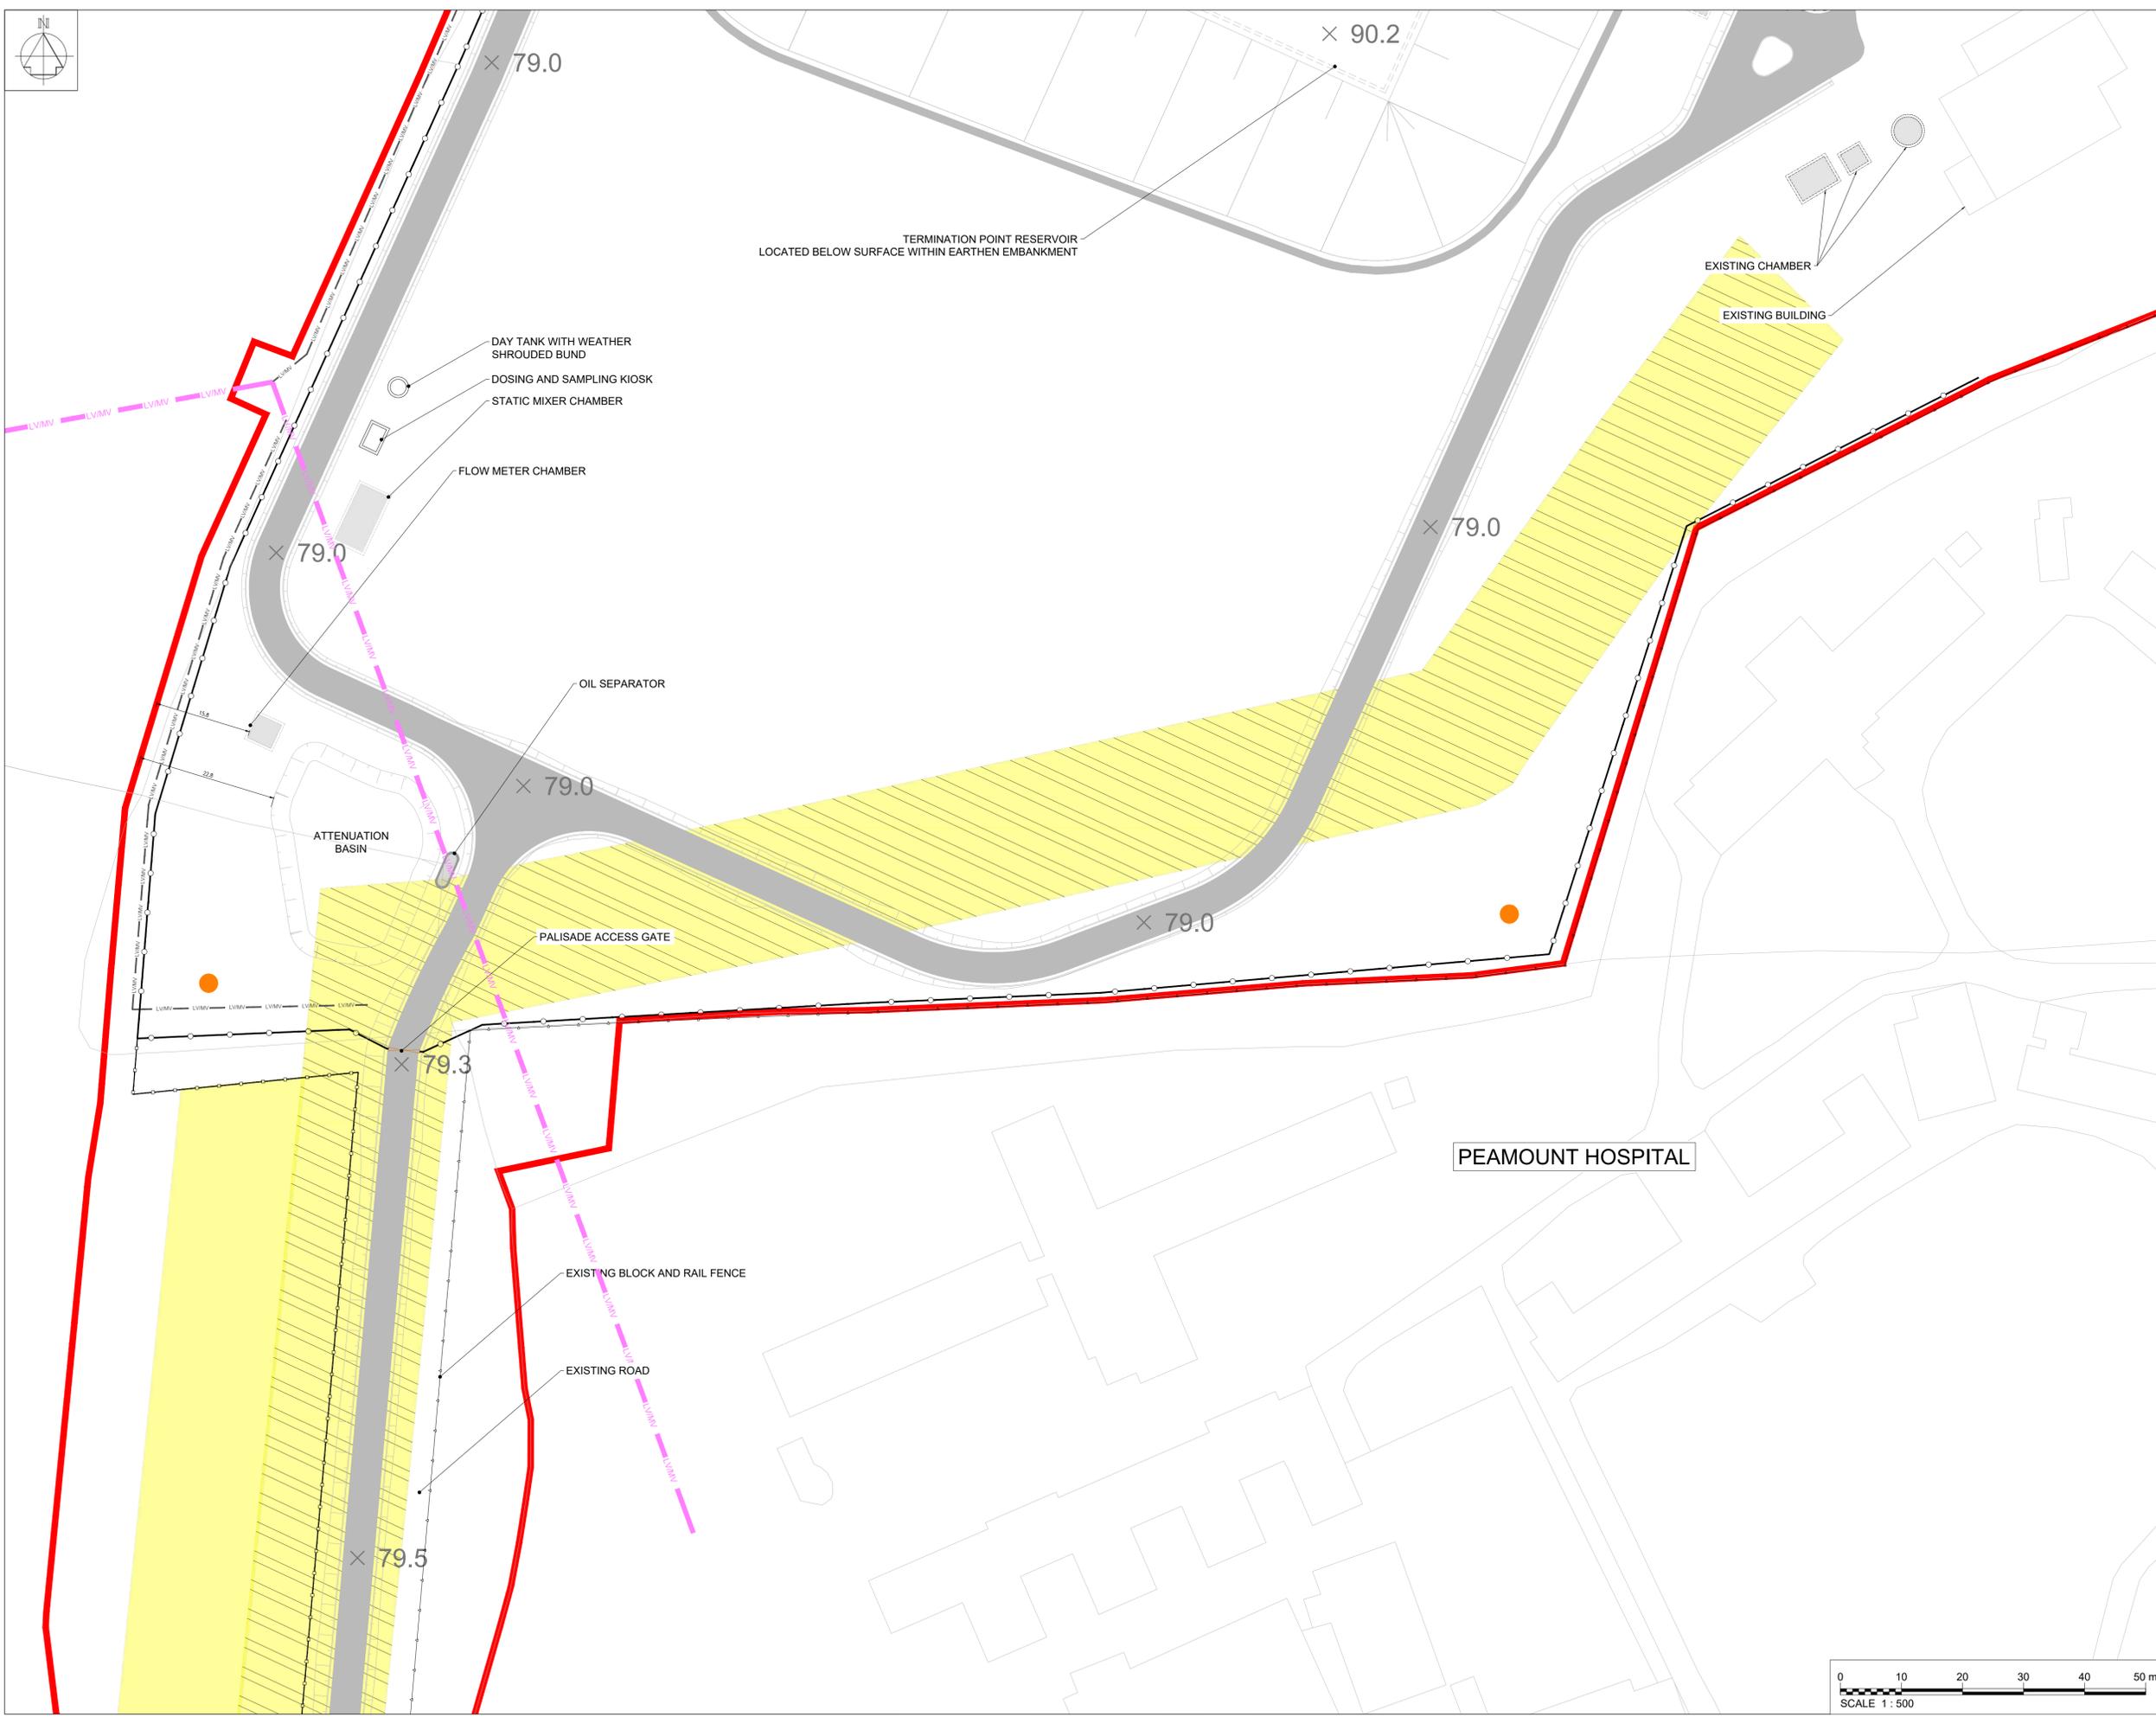



- Notes:
1. ALL DIMENSIONS ARE IN METRES AND ALL LEVELS ARE IN METRES AOD MALIN HEAD UNLESS OTHERWISE STATED.
 2. THIS DRAWING IS NOT TO BE SCALED. FIGURED DIMENSIONS ONLY TO BE TAKEN.
 3. THIS DRAWING IS FOR PLANNING PURPOSES ONLY.

- LEGEND:
- PLANNING APPLICATION BOUNDARY
 - INDICATIVE PERMANENT WAYLEAVE
 - PERMANENT WAYLEAVE FOR EXISTING 1200mm MAIN
- EXISTING:
- BLOCK AND RAIL FENCE
- PROPOSED:
- 1.2m HIGH POST AND RAIL FENCE
 - 2.4m HIGH PALISADE SITE SECURITY FENCE
 - ESBN LINE DIVERSION
 - ACCESS STEPS
 - ROAD / HARDSTAND SURFACE
 - BUILDING
 - BELOW GROUND STRUCTURES
 - SOLAR ENERGY PANELS
 - CCTV DROP DOWN POLE

OSI Sheet No's:
3325-A.

F02	FINAL FOR PLANNING	AP	MG	SW	Dec. 2025
F01	FINAL FOR PLANNING	AP	MG	SW	Dec. 2025
Rev	Description	Drawn	Chkd	App'd.	Date

This drawing is the property of Uisce Éireann and must not be copied or used for any purpose other than that for which it is supplied without the written consent of Uisce Éireann.



Uisce Éireann
Irish Water



Tionscadal Soláthair Uisce
Water Supply Project

UISCE ÉIREANN
COLVILL HOUSE,
TALBOT STREET,
DUBLIN 1,
IRELAND

Call 1890 278 278
Int: 00 353 1 707 2828

JACOBS TOBIN

Originated By JMC	Drawn By AP	Checked By MG	Approved By SW
Date 17.01.18	Date 01.12.2025	Date 01.12.2025	Date 01.12.2025


Scale: 1:500 @ A1


Project Title
**WATER SUPPLY PROJECT
EASTERN AND MIDLANDS REGION**

Drawing Title
**TERMINATION POINT RESERVOIR
PROPOSED SITE LAYOUT PLAN
SHEET 02**

Drawing Status: FINAL FOR PLANNING
Jacobs Tobin No. 32105801 | Client No. 9318

Drawing No.
32105801-850-06005

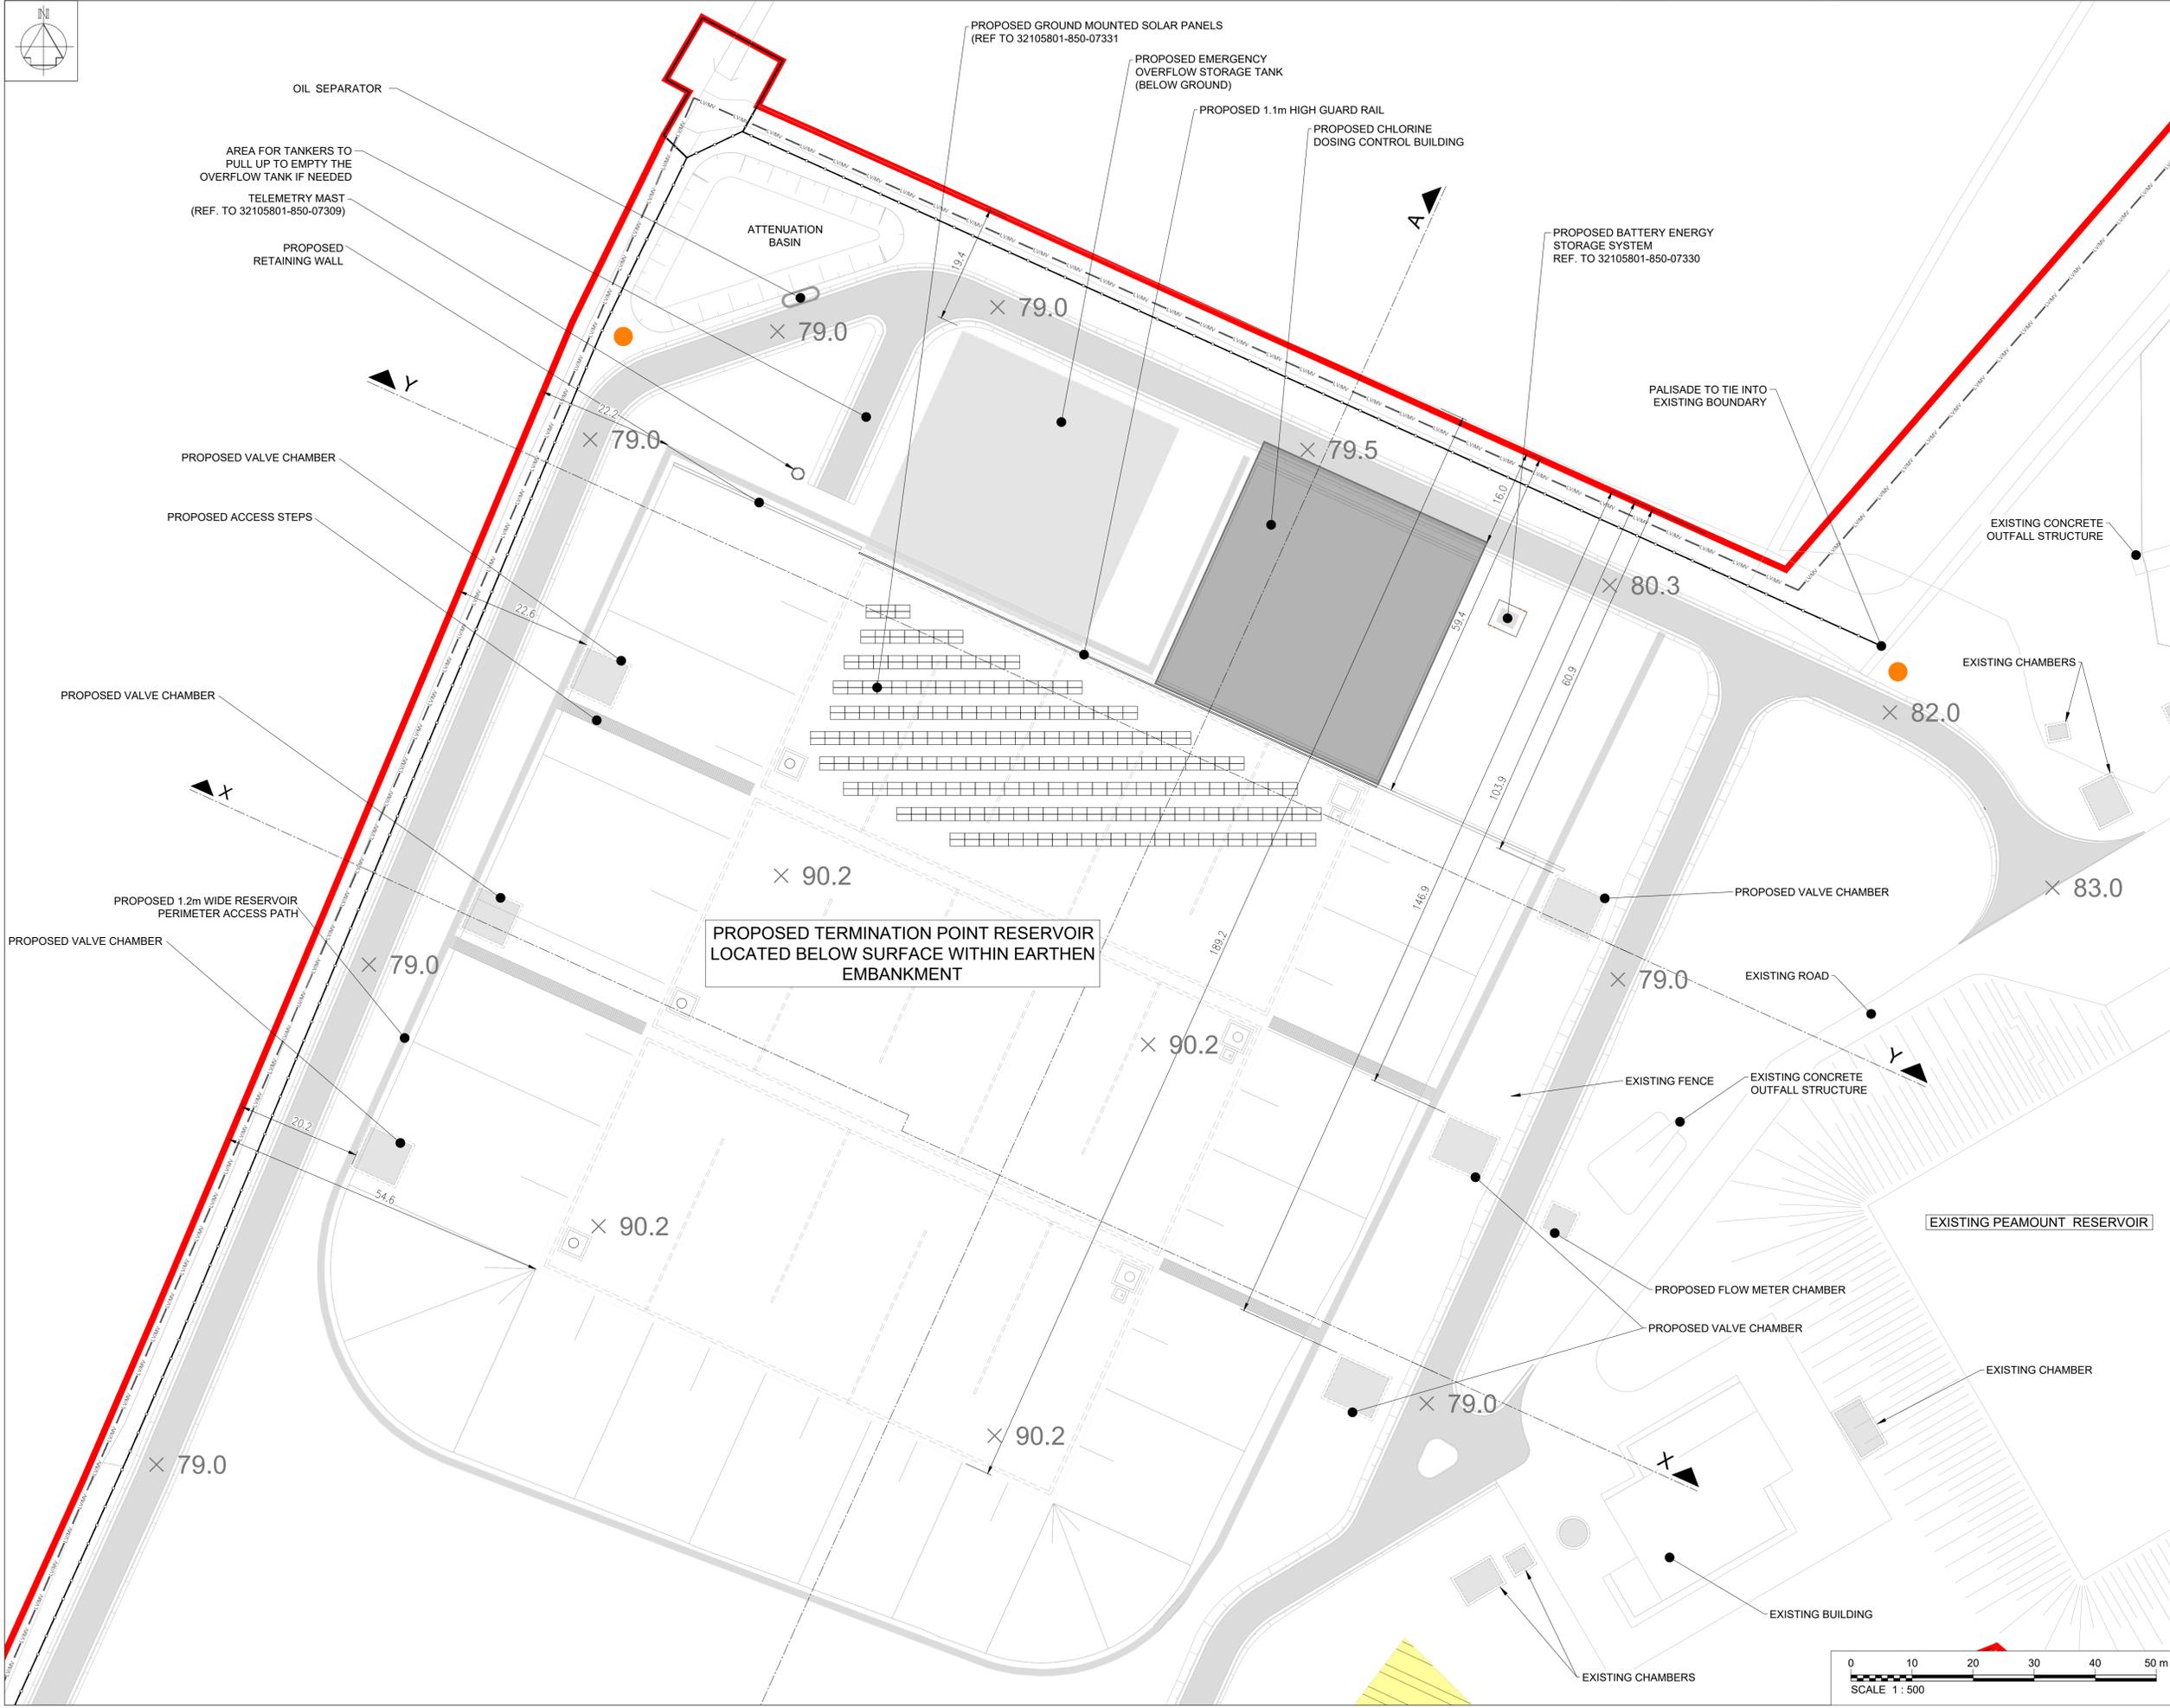

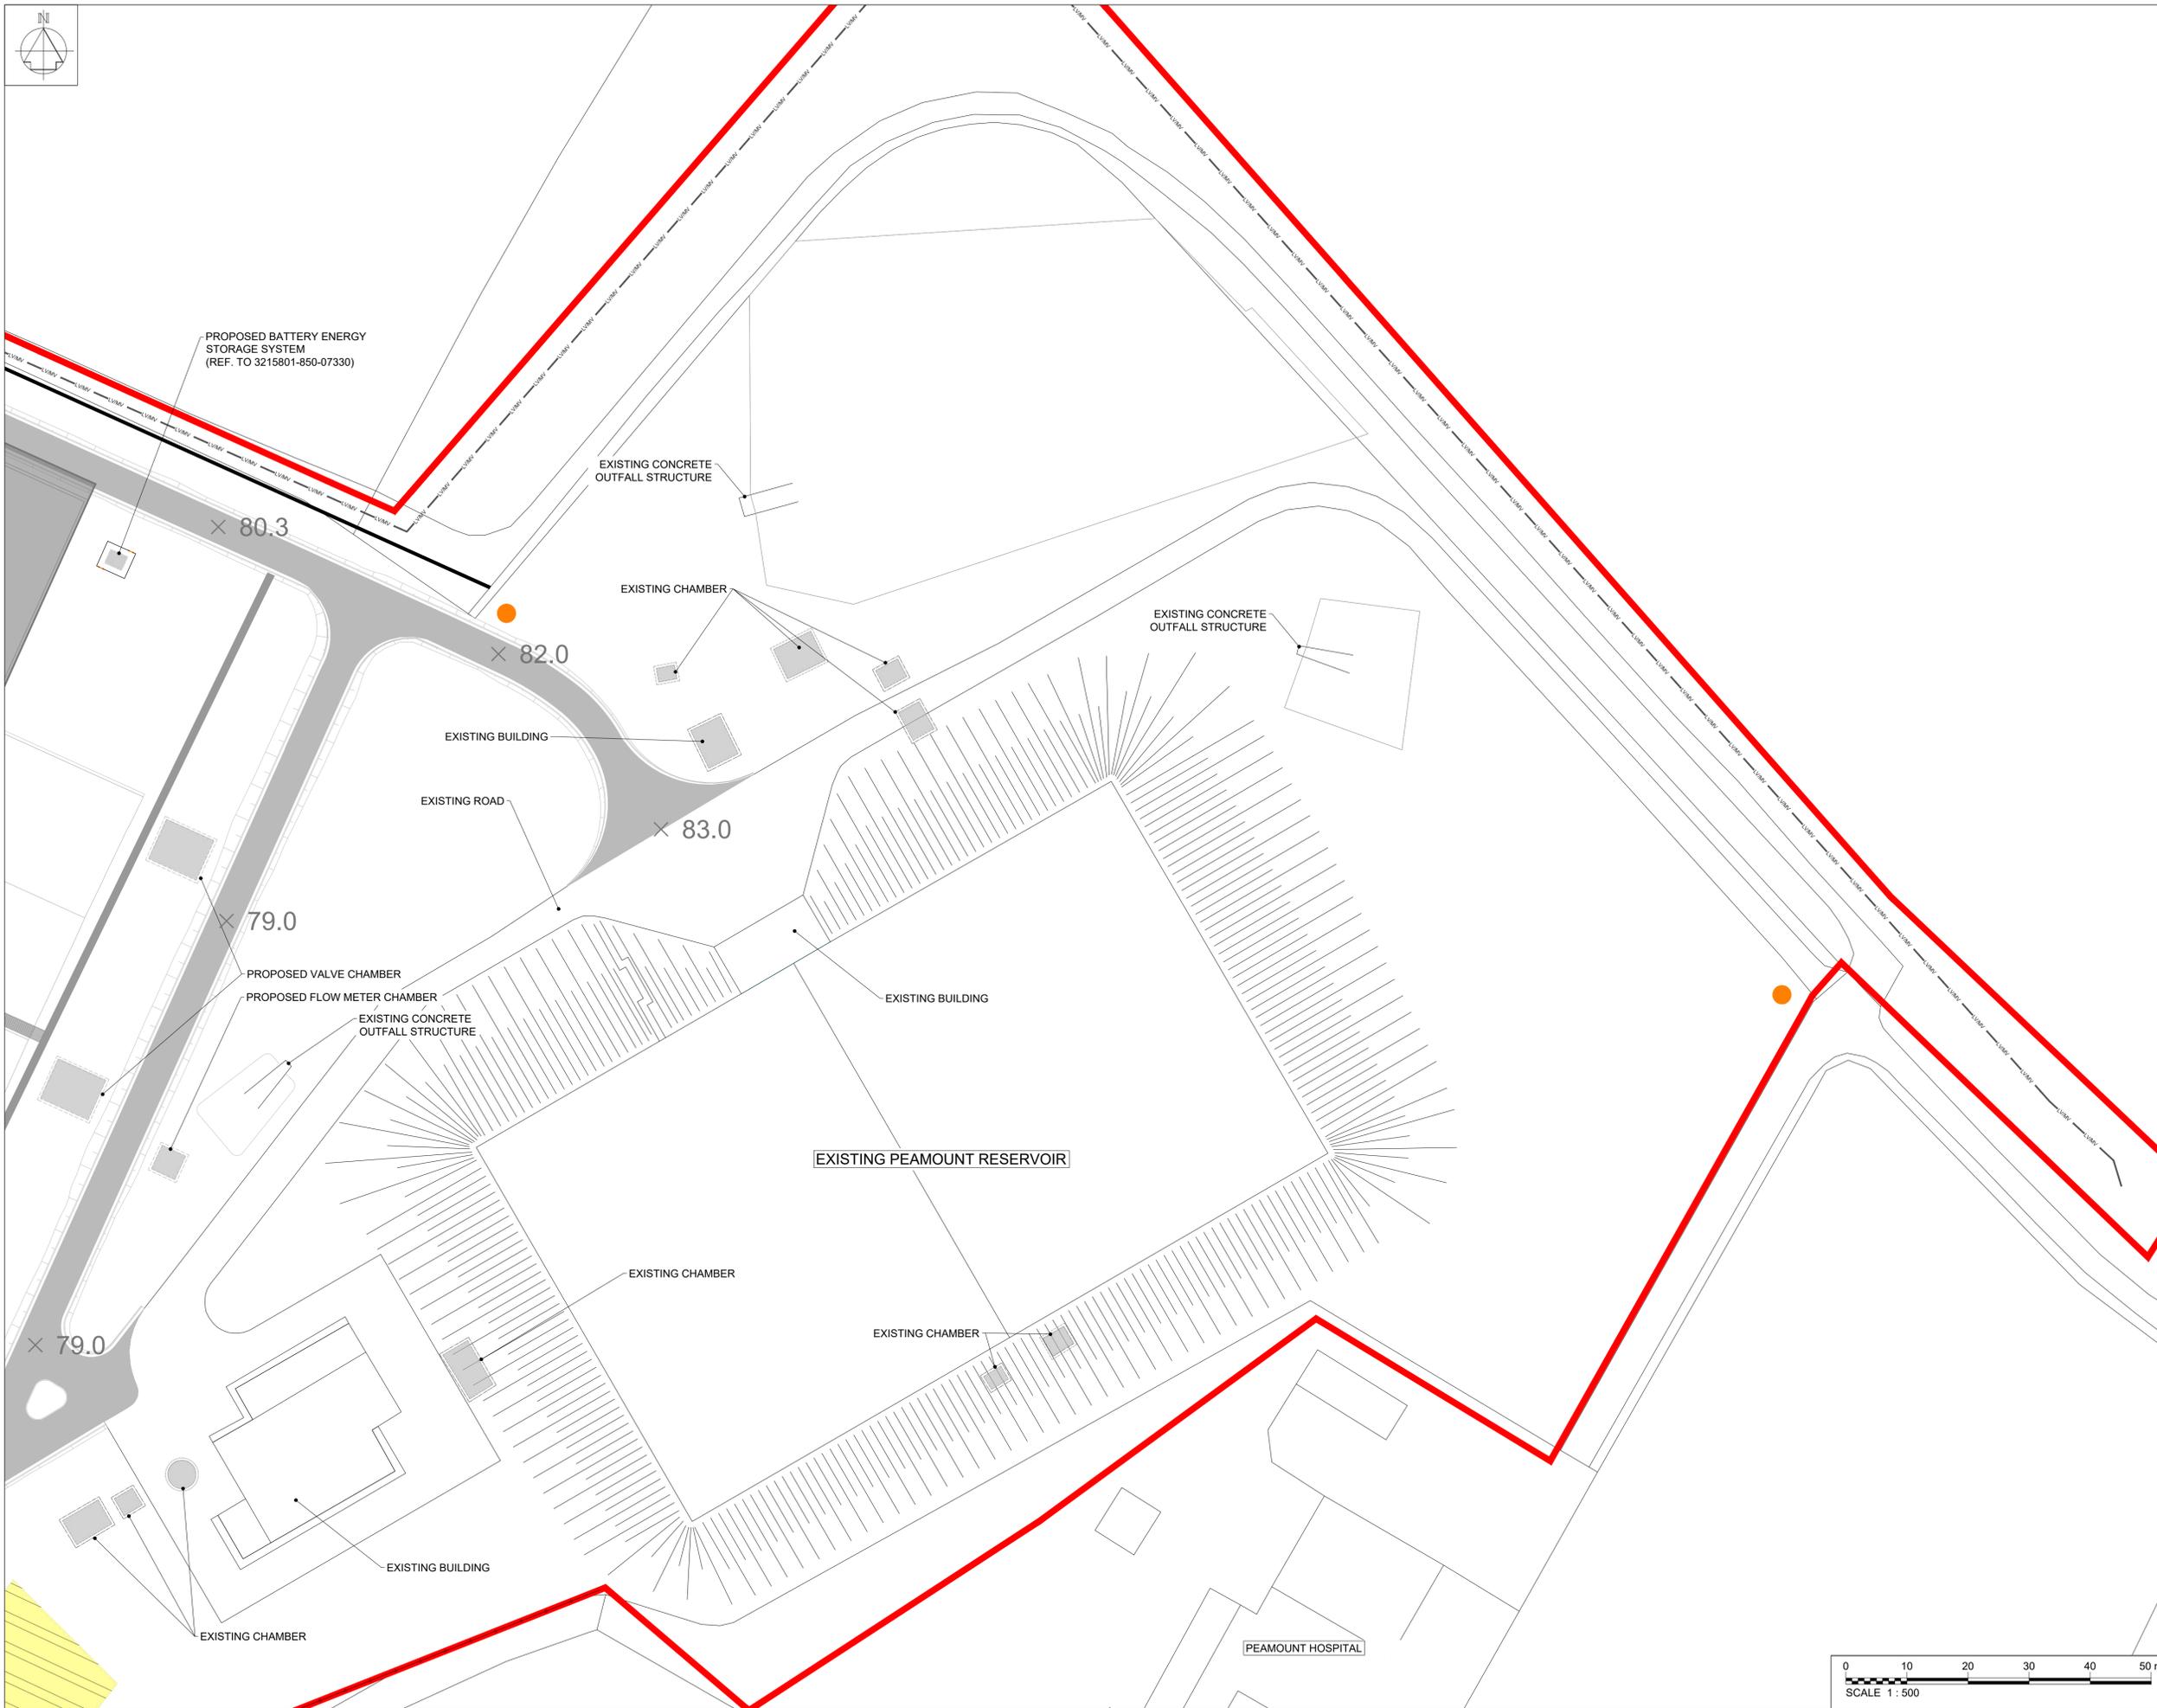

Notes:
1. ALL DIMENSIONS ARE IN METRES AND ALL LEVELS ARE IN METRES AOD MALIN HEAD UNLESS OTHERWISE STATED.
2. THIS DRAWING IS NOT TO BE SCALED. FIGURED DIMENSIONS ONLY TO BE TAKEN.
3. THIS DRAWING IS FOR PLANNING PURPOSES ONLY.

- LEGEND:
- PLANNING APPLICATION BOUNDARY
 - INDICATIVE PERMANENT WAYLEAVE
 - PERMANENT WAYLEAVE FOR EXISTING 1200mm MAIN
- EXISTING:
- BLOCK AND RAIL FENCE
- PROPOSED:
- 1.2m HIGH POST AND RAIL FENCE
 - 2.4m HIGH PALISADE SITE SECURITY FENCE
 - ESBN LINE DIVERSION
 - ACCESS STEPS
 - ROAD / HARDSTAND SURFACE
 - BUILDING
 - BELOW GROUND STRUCTURES
 - SOLAR ENERGY PANELS
 - CCTV DROP DOWN POLE

OSI Sheet No's:
3325-A.

F02	FINAL FOR PLANNING	AP	MG	SM	Dec. 2025
F01	FINAL FOR PLANNING	AP	MG	SM	Dec. 2025
Rev	Description	Drawn	Chk'd	App'd.	Date

This drawing is the property of Uisce Éireann and must not be copied or used for any purpose other than that for which it is supplied without the written consent of Uisce Éireann.



Uisce Éireann
Irish Water



Tionscadal Soláthair Uisce
Water Supply Project

UISCE ÉIREANN
COLVILL HOUSE,
TALBOT STREET,
DUBLIN 1,
IRELAND

Call 1890 278 278
Int: 00 353 1 707 2828

JACOBS TOBIN

Originated By JMC	Drawn By AP	Checked By MG	Approved By SW
Date 17.01.18	Date 01.12.2025	Date 01.12.2025	Date 01.12.2025

Scale: 1:500 @ A1 FINAL

Project Title
WATER SUPPLY PROJECT
EASTERN AND MIDLANDS REGION


Drawing Title
TERMINATION POINT RESERVOIR
PROPOSED SITE LAYOUT PLAN
SHEET 03

Drawing Status: FINAL FOR PLANNING
Jacobs Tobin No. 32105801 Client No. 9318


Drawing No.
32105801-850-06006



- Notes:
1. ALL DIMENSIONS ARE IN METRES AND ALL LEVELS ARE IN METRES AOD MALIN HEAD UNLESS OTHERWISE STATED.
 2. THIS DRAWING IS NOT TO BE SCALED. FIGURED DIMENSIONS ONLY TO BE TAKEN.
 3. THIS DRAWING IS FOR PLANNING PURPOSES ONLY.

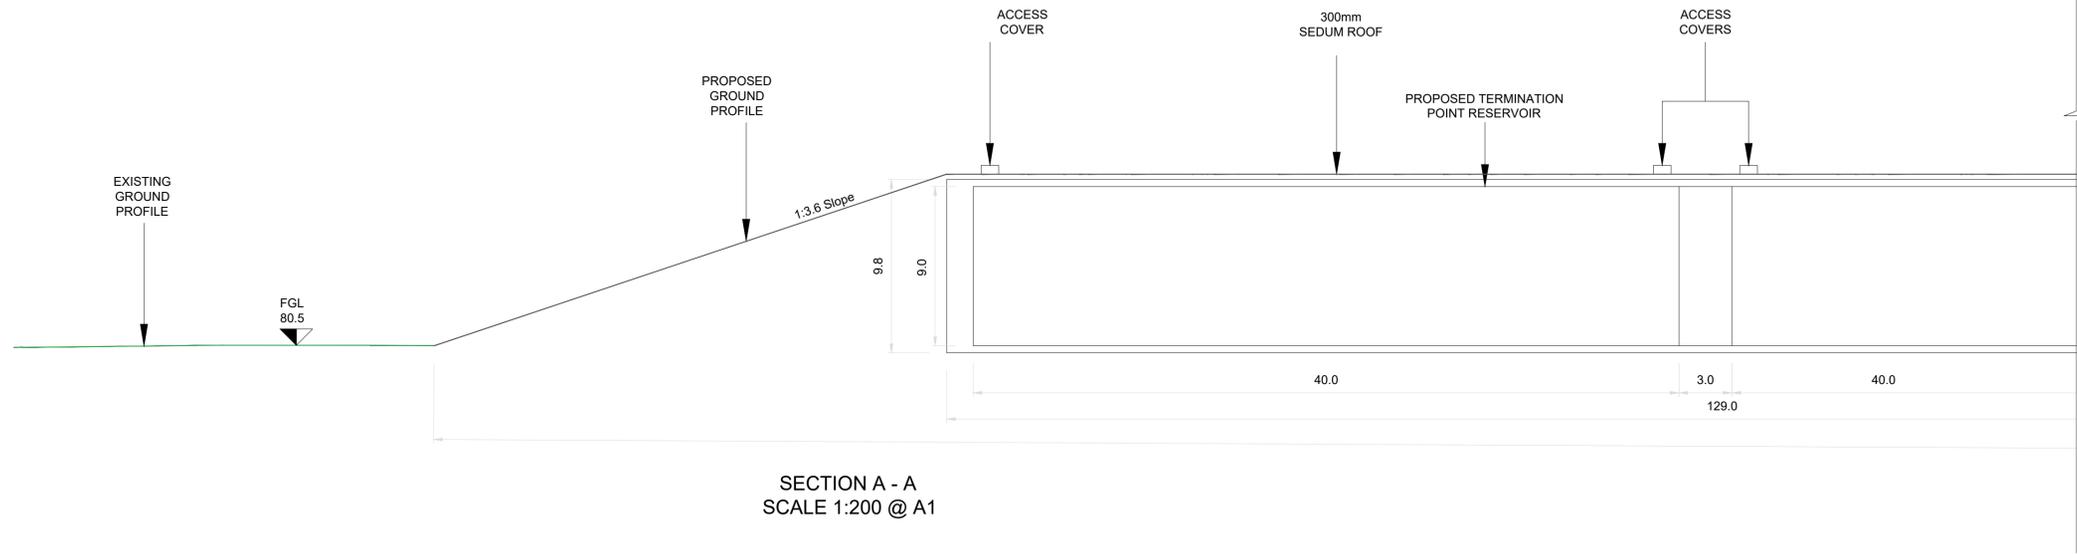

SECTION A - A
SCALE 1:200 @ A1

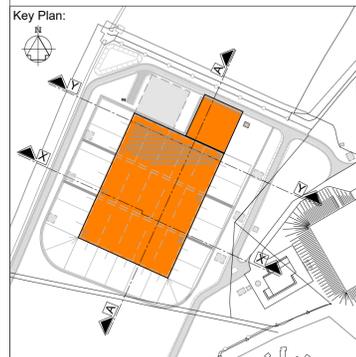

- LEGEND:
- EXISTING: GROUND PROFILE
 - PROPOSED: GROUND PROFILE
 - FGL FINISHED GROUND LEVEL

F02	FINAL FOR PLANNING	AP	MG	SM	Dec. 2025
F01	FINAL FOR PLANNING	AP	MG	SM	Dec. 2025
Rev	Description	Drawn	Chk'd	App'd.	Date

This drawing is the property of Uisce Éireann and must not be copied or used for any purpose other than that for which it is supplied without the written consent of Uisce Éireann.

UISCE ÉIREANN
COLVILL HOUSE,
TALBOT STREET,
DUBLIN 1,
IRELAND

Call 1890 278 278
Int: 00 353 1 707 2828

Jacobs TOBIN


Originated By MK	Drawn By AP	Checked By MG	Approved By SW
Date 14.01.2022	Date 01.12.2025	Date 01.12.2025	Date 01.12.2025
Scale 1:200 @ A1		FINAL	

Project Title
WATER SUPPLY PROJECT
EASTERN AND MIDLANDS REGION

Drawing Title
TERMINATION POINT RESERVOIR
CROSS SECTION A-A

Drawing Status: FINAL FOR PLANNING
Jacobs Tobin No. 32105801 Client No. 9318


Drawing No.
32105801-850-06007

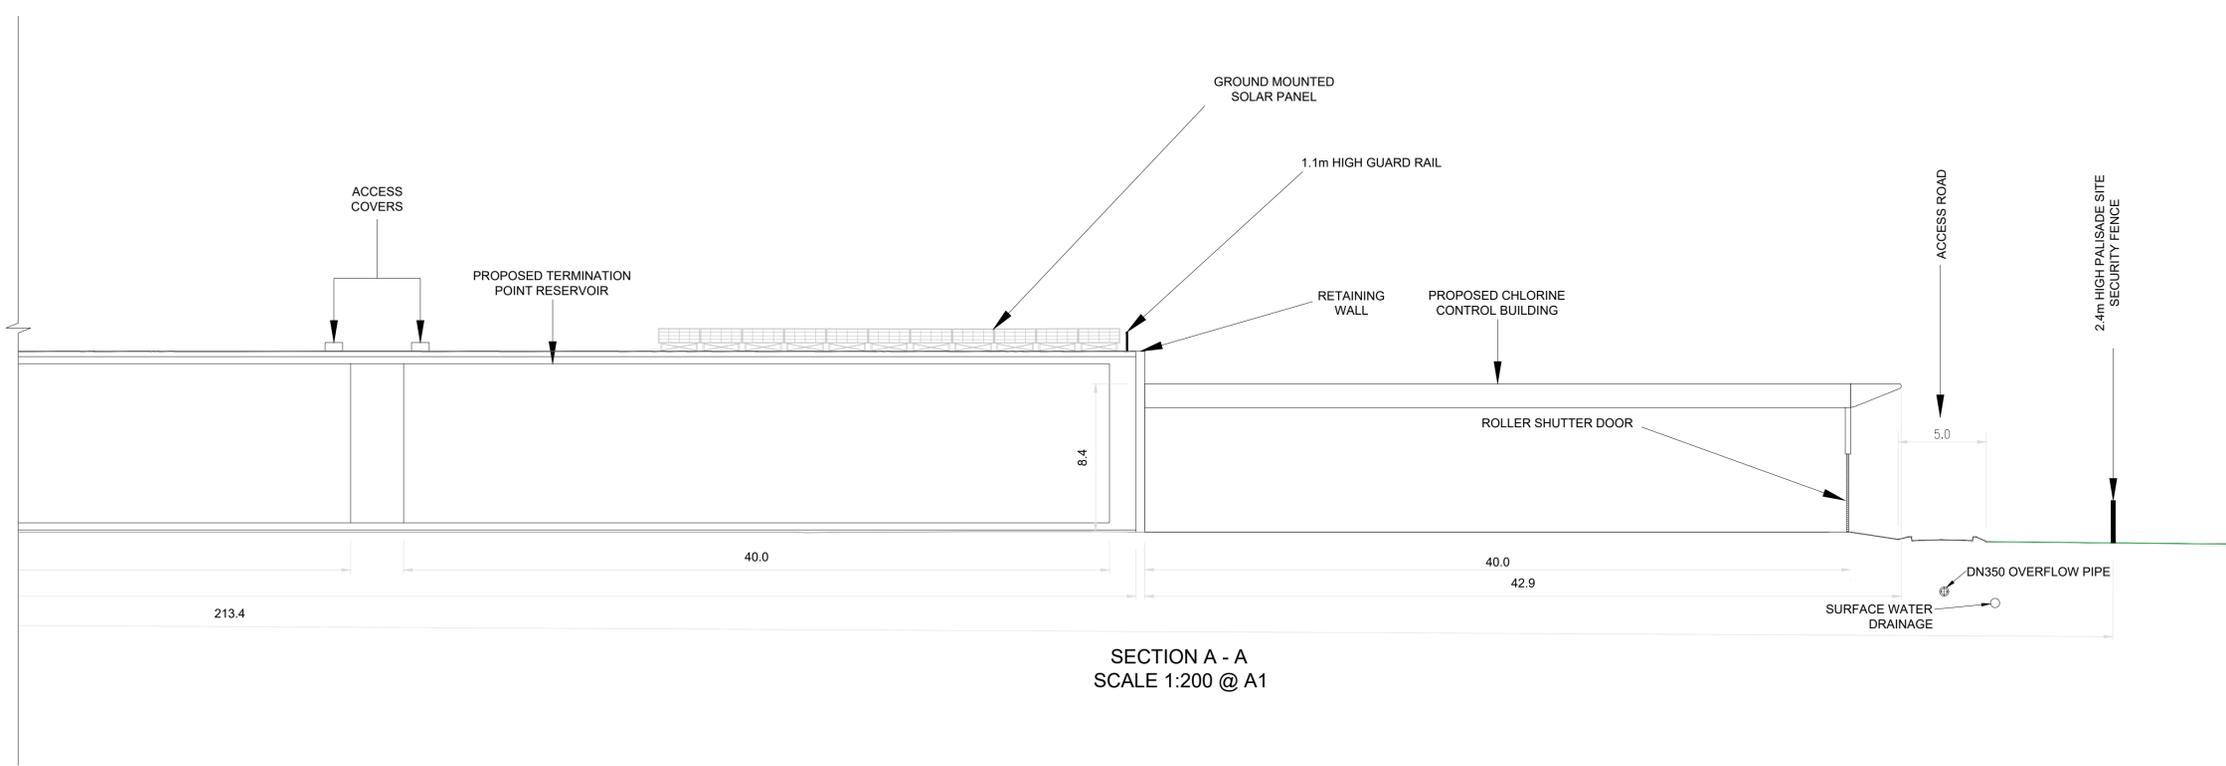


SECTION A - A
SCALE 1:200 @ A1



- Notes:
1. ALL DIMENSIONS ARE IN METRES AND ALL LEVELS ARE IN METRES AOD MALIN HEAD UNLESS OTHERWISE STATED.
 2. THIS DRAWING IS NOT TO BE SCALED. FIGURED DIMENSIONS ONLY TO BE TAKEN.
 3. THIS DRAWING IS FOR PLANNING PURPOSES ONLY.

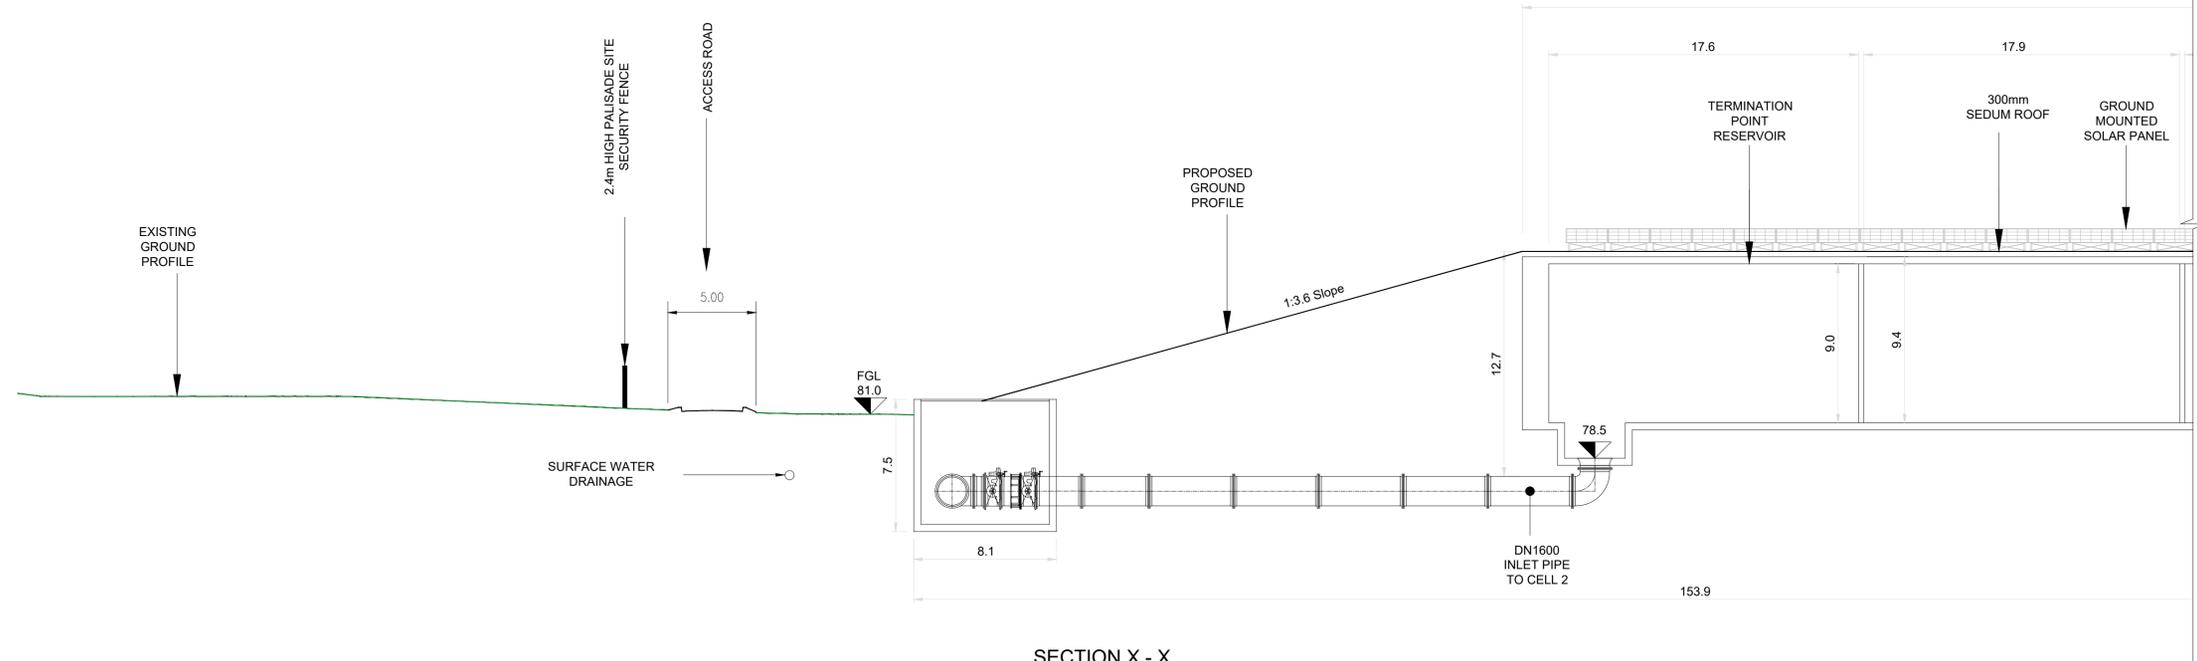

SECTION X - X
SCALE 1:200 @ A1

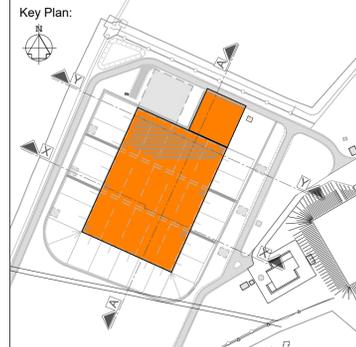

- LEGEND:
- EXISTING: — GROUND PROFILE
 - PROPOSED: — GROUND PROFILE
 - FGL FINISHED GROUND LEVEL

F02	FINAL FOR PLANNING	PC	MG	SW	Dec. 2025
F01	FINAL FOR PLANNING	PC	MG	SW	Dec. 2025
Rev	Description	Drawn	Chk'd	App'd	Date

This drawing is the property of Uisce Éireann and must not be copied or used for any purpose other than that for which it is supplied without the written consent of Uisce Éireann.

UISCE ÉIREANN
COLVILL HOUSE,
TALBOT STREET,
DUBLIN 1,
IRELAND
Call 1890 278 278
Int: 00 353 1 707 2828

Jacobs TOBIN

Originated By MK	Drawn By PC	Checked By MG	Approved By SW
Date 14.01.2022	Date 01.12.2025	Date 01.12.2025	Date 01.12.2025


Scale: 1:200 @ A1 **FINAL**

Project Title
WATER SUPPLY PROJECT
EASTERN AND MIDLANDS REGION


Drawing Title
TERMINATION POINT RESERVOIR
CROSS SECTION X-X

Drawing Status: FINAL FOR PLANNING
Jacobs Tobin No. 32105801 Client No. 9318



Drawing No.
32105801-850-06008

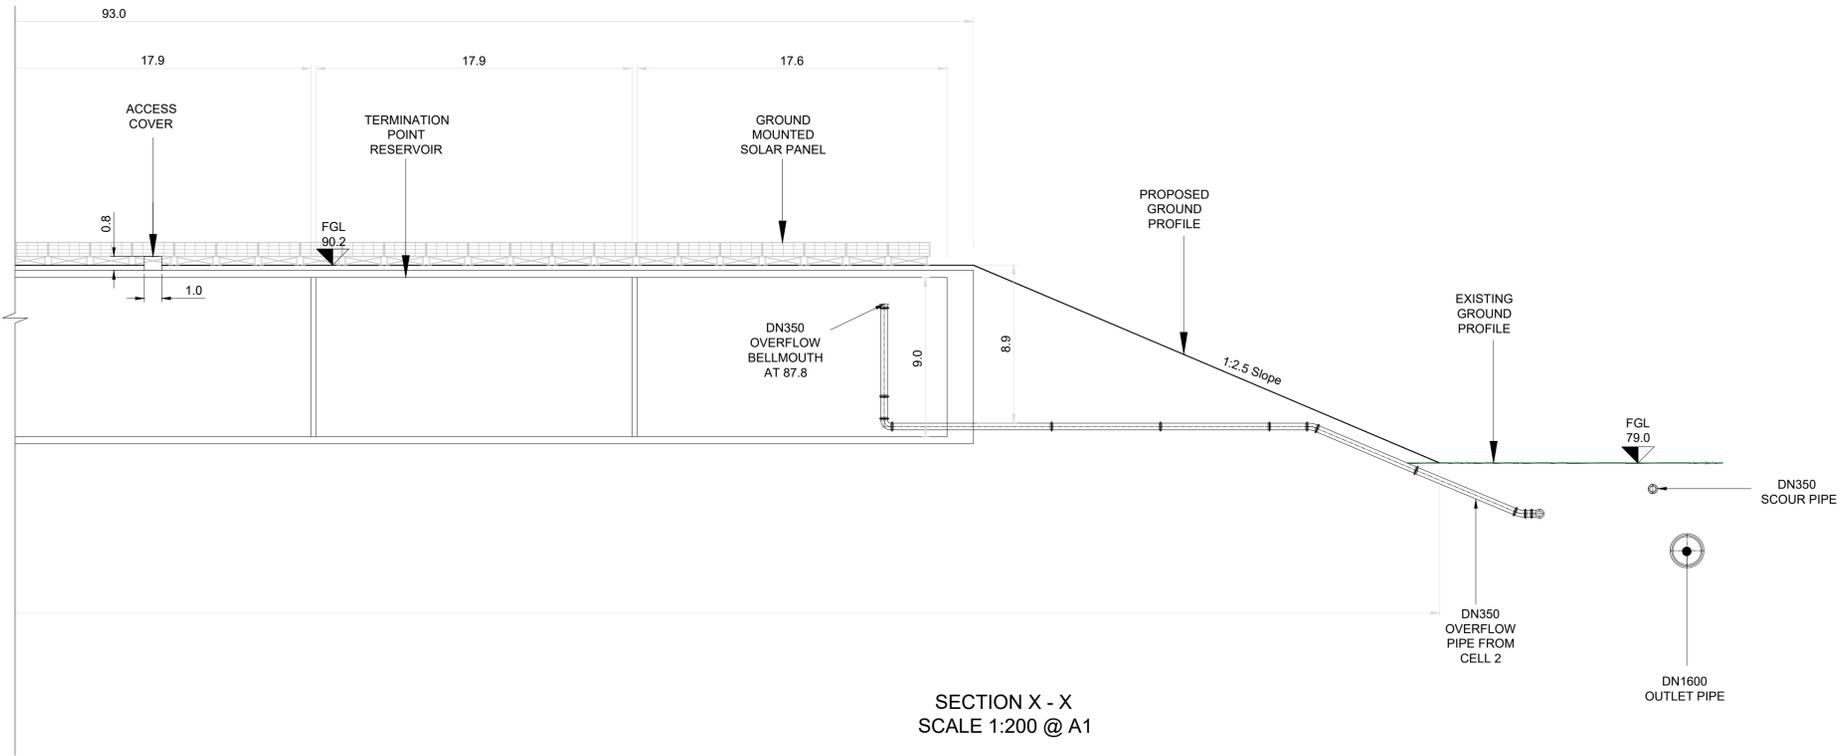

SECTION X - X
SCALE 1:200 @ A1

 

- Notes:
1. ALL DIMENSIONS ARE IN METRES AND ALL LEVELS IN METRES UNLESS OTHERWISE STATED.
 2. THIS DRAWING IS NOT TO BE SCALED. FIGURED DIMENSIONS ONLY TO BE TAKEN.
 3. THIS DRAWING IS FOR PLANNING PURPOSES ONLY.

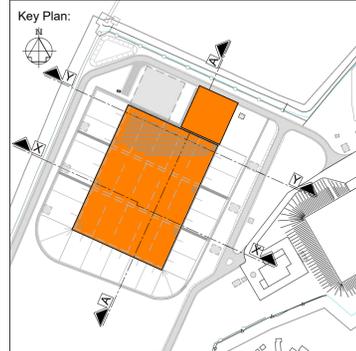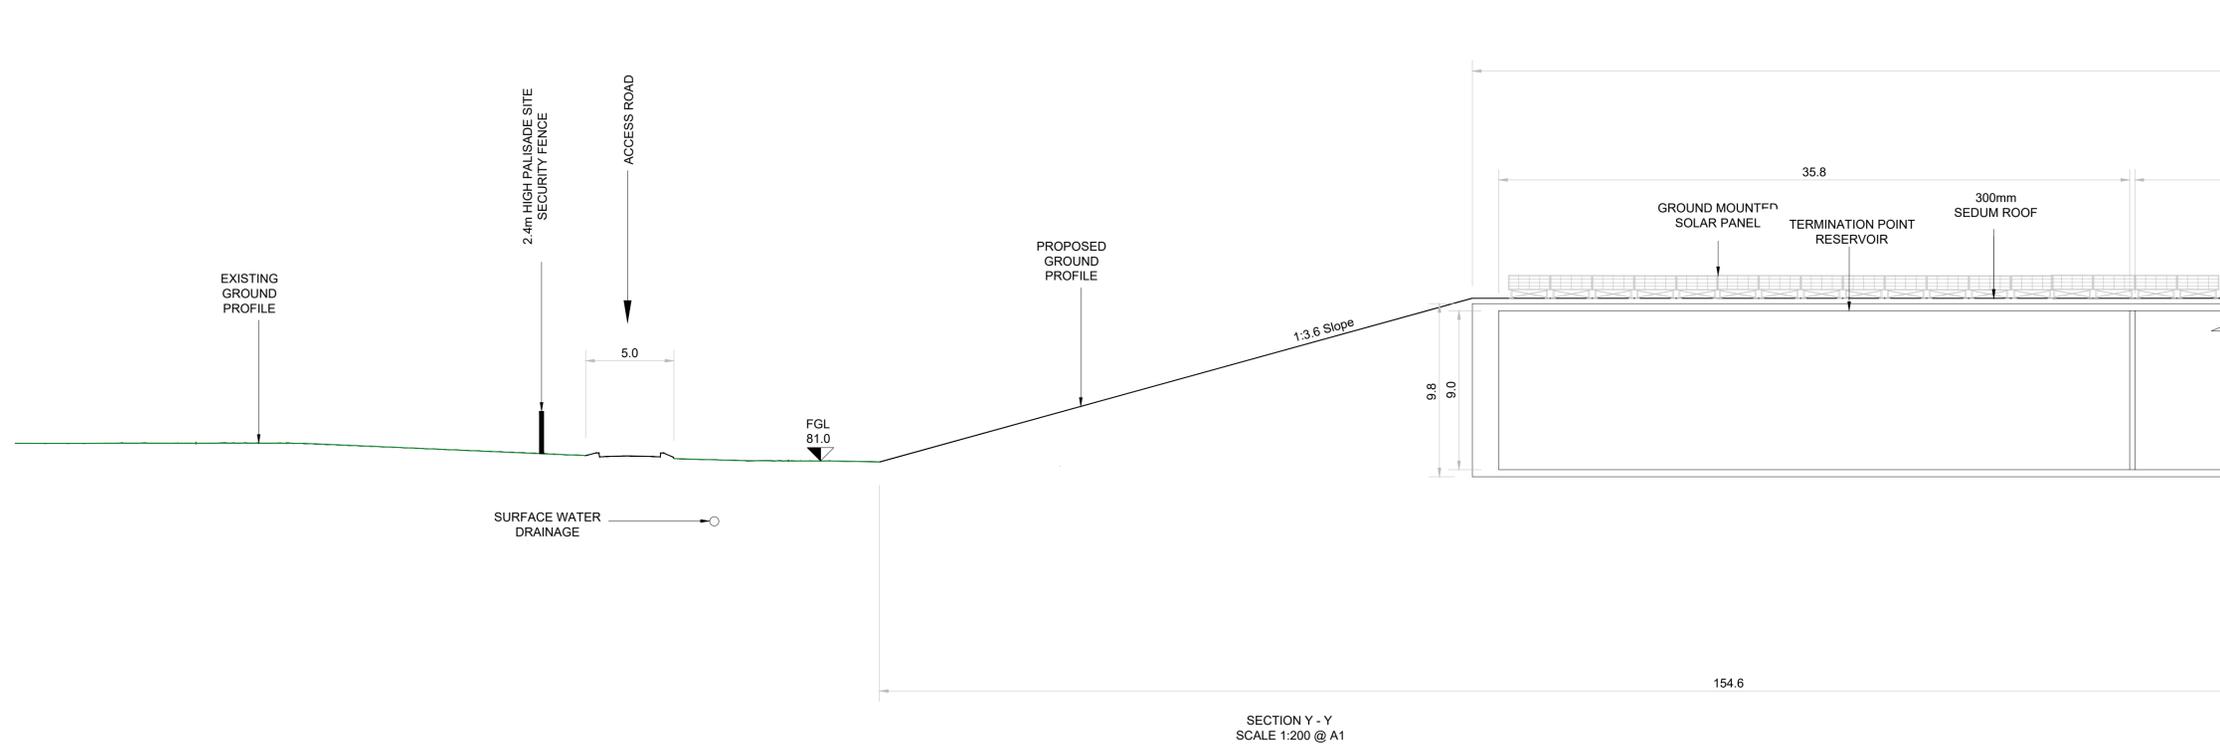

- LEGEND:
- EXISTING: — GROUND PROFILE
- PROPOSED: — GROUND PROFILE
- FGL FINISHED GROUND LEVEL

F02	FINAL FOR PLANNING	PC	MG	SW	Dec. 2025
F01	FINAL FOR PLANNING	PC	MG	SW	Dec. 2025
Rev	Description	Drawn	Chk'd	App'd	Date

This drawing is the property of Uisce Éireann and must not be copied or used for any purpose other than that for which it is supplied without the written consent of Uisce Éireann.

UISCE ÉIREANN
COLVILL HOUSE,
TALBOT STREET,
DUBLIN 1,
IRELAND

Call 1890 278 278
Int: 00 353 1 707 2828

Jacobs TOBIN

Originated By MK	Drawn By PC	Checked By MG	Approved By SW
Date 14.01.2022	Date 01.12.2025	Date 01.12.2025	Date 14.01.2022


Scale: 1:200 @ A1 **FINAL**

Project Title
**WATER SUPPLY PROJECT
EASTERN AND MIDLANDS REGION**

Drawing Title
**TERMINATION POINT RESERVOIR
CROSS SECTION Y-Y**



Drawing Status: FINAL FOR PLANNING
Jacobs Tobin No. 32105801 Client No. 9318

Drawing No.
32105801-850-06009

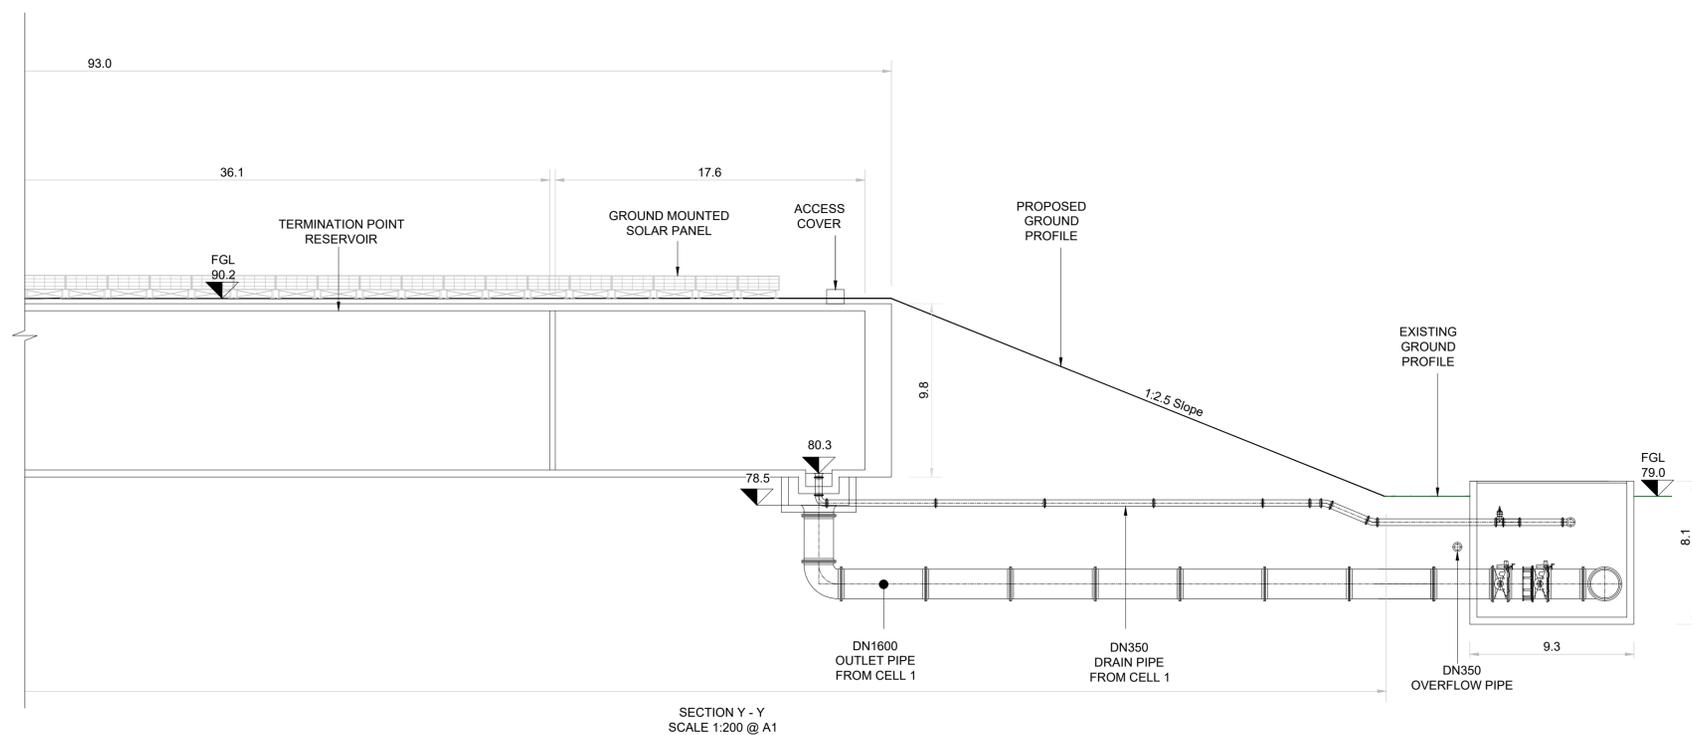




- Notes:
1. ALL DIMENSIONS ARE IN METRES AND ALL LEVELS IN METRES UNLESS OTHERWISE STATED.
 2. THIS DRAWING IS NOT TO BE SCALED. FIGURED DIMENSIONS ONLY TO BE TAKEN.
 3. THIS DRAWING IS FOR PLANNING PURPOSES ONLY.

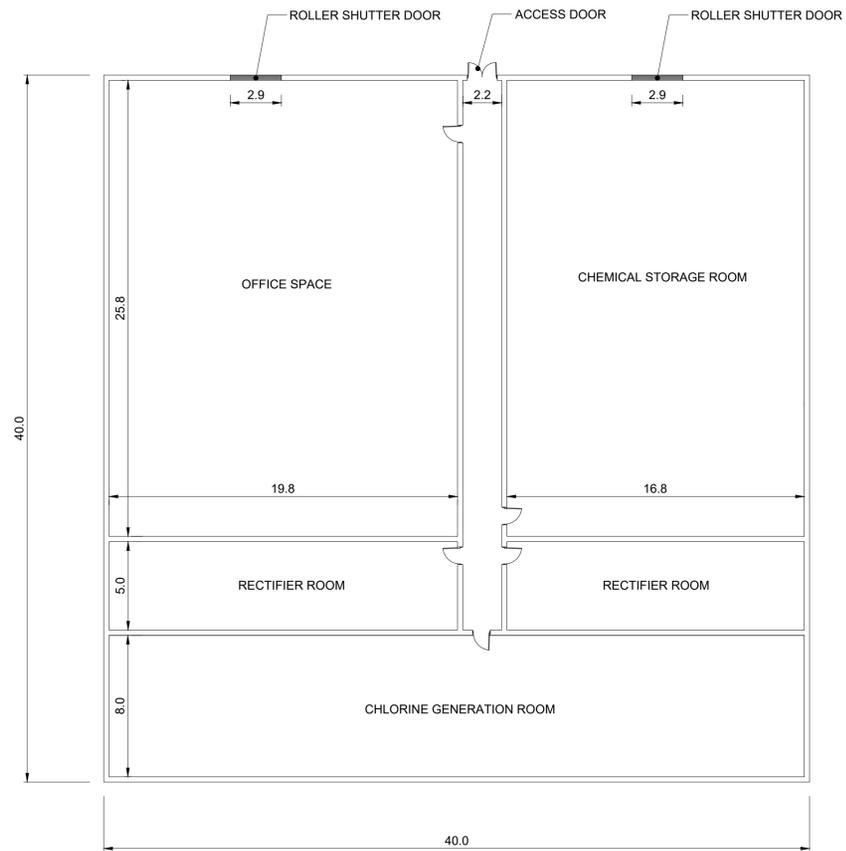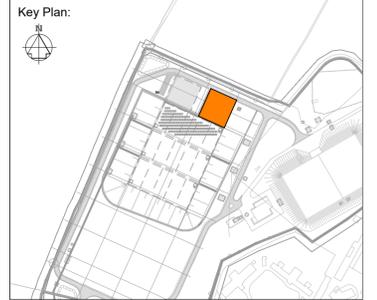

TERMINATION POINT RESERVOIR
CHLORINE DOSING CONTROL BUILDING
GROUND FLOOR PLAN
SCALE 1:200 @ A1

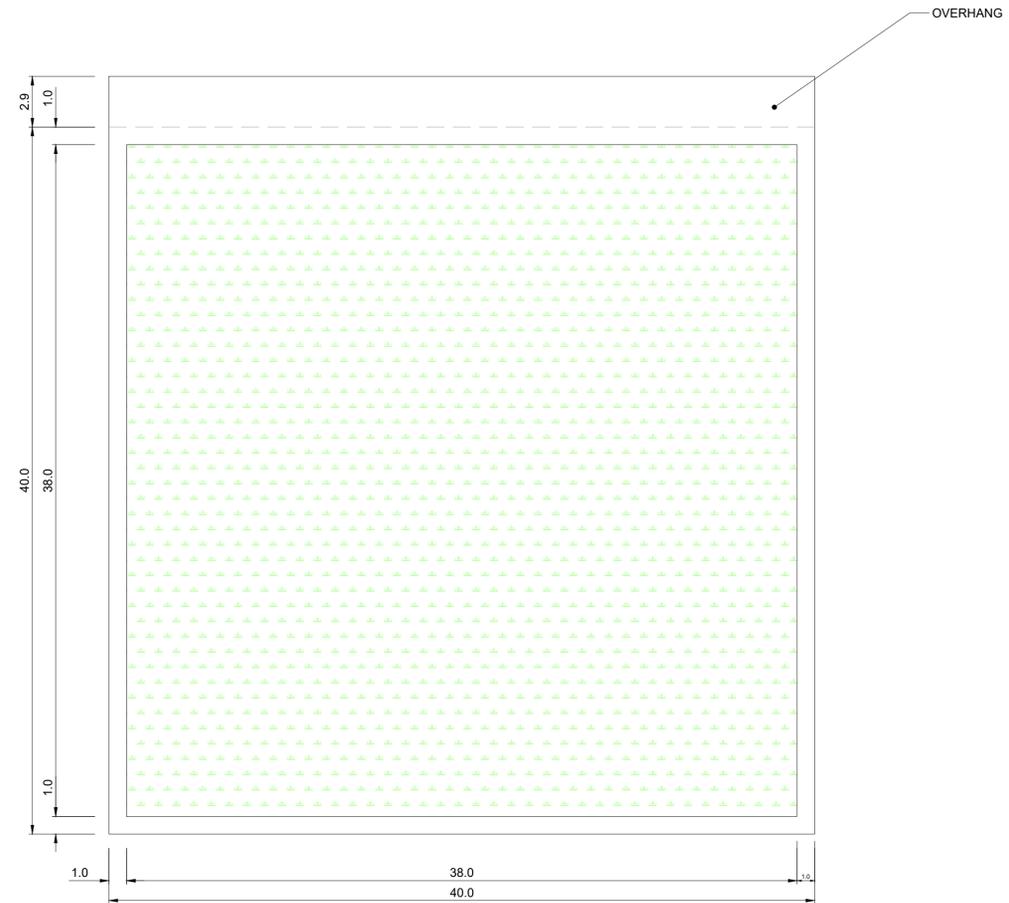

TERMINATION POINT RESERVOIR
CHLORINE DOSING CONTROL BUILDING
ROOF PLAN
SCALE 1:200 @ A1

LEGEND:

GREEN ROOF

F02	FINAL FOR PLANNING	PC	MG	SW	Dec.2025
F01	FINAL FOR PLANNING	PC	MG	SW	Dec.2025
Rev	Description	Drawn	Chk'd	App'd	Date

This drawing is the property of Uisce Éireann and must not be copied or used for any purpose other than that for which it is supplied without the written consent of Uisce Éireann.

UISCE ÉIREANN
COLVILL HOUSE,
TALBOT STREET,
DUBLIN 1,
IRELAND

Call 1890 278 278
Int: 00 353 1 707 2828

JACOBS TOBIN


Originated By MK	Drawn By PC	Checked By MG	Approved By SW
Date 28.01.22	Date 01.12.2025	Date 01.12.2025	Date 01.12.2025
Scale 1:200 @ A1		FINAL	

Project Title
WATER SUPPLY PROJECT
EASTERN AND MIDLANDS REGION



Drawing Title
TERMINATION POINT RESERVOIR
PROPOSED CHLORINE DOSING
CONTROL BUILDING PLAN

Drawing Status
FINAL FOR PLANNING

 Jacobs Tobin No. 32105801 Client No. 9318
Drawing No. 32105801-850-06010



- Notes:
1. ALL DIMENSIONS ARE IN METRES AND ALL LEVELS IN METRES UNLESS OTHERWISE STATED.
 2. THIS DRAWING IS NOT TO BE SCALED. FIGURED DIMENSIONS ONLY TO BE TAKEN.
 3. THIS DRAWING IS FOR PLANNING PURPOSES ONLY.

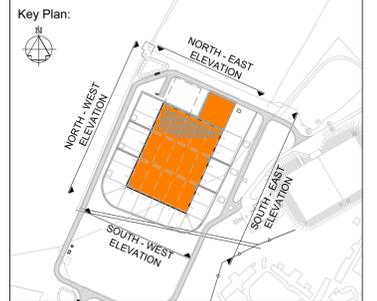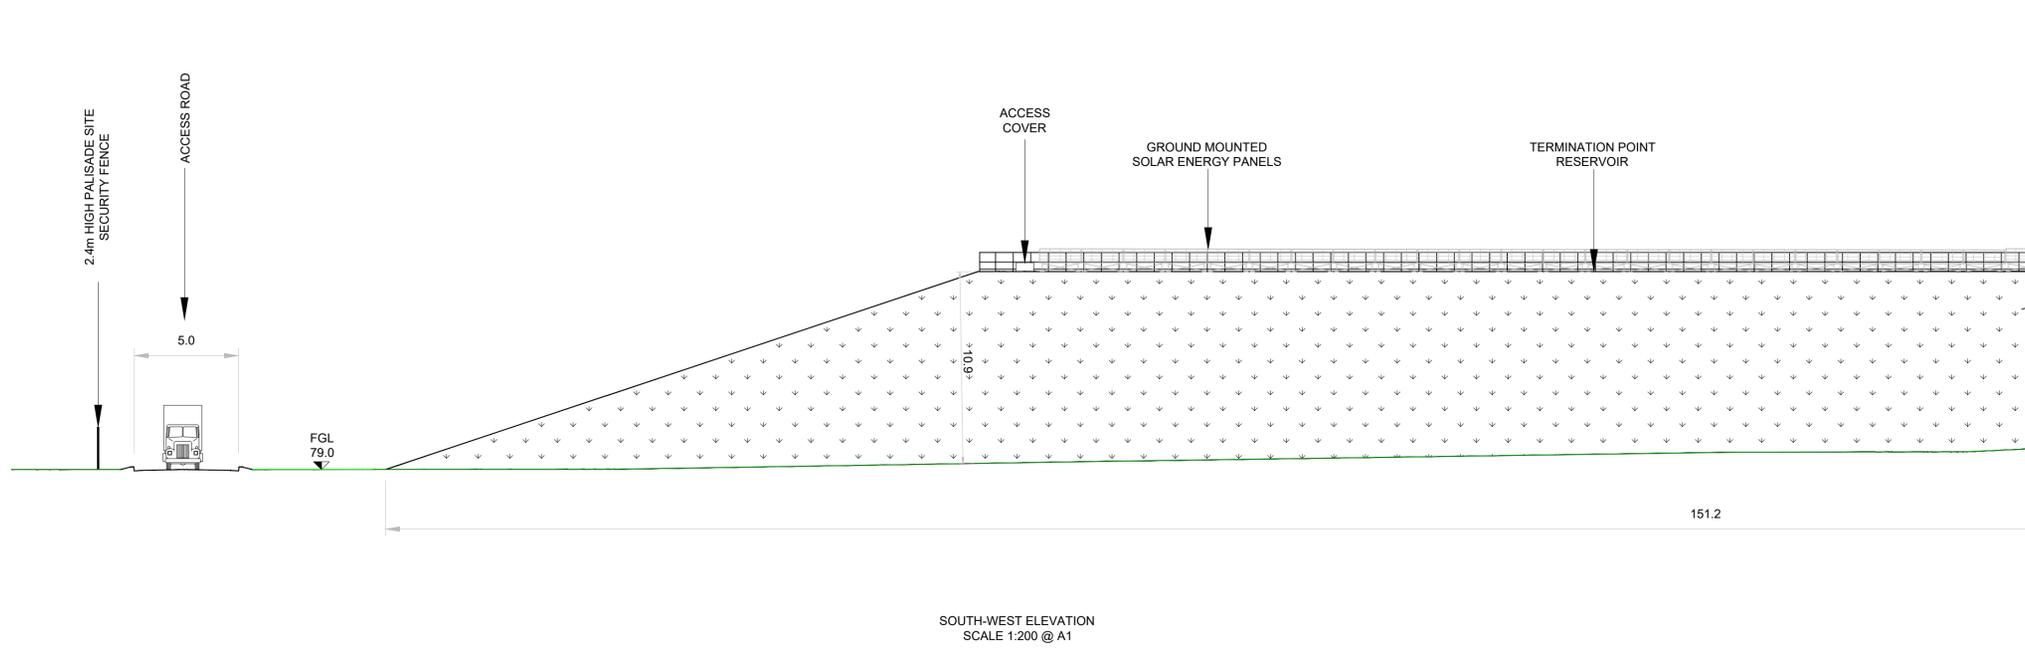

- LEGEND:
- EXISTING:
 — GROUND PROFILE
- PROPOSED:
 — GROUND PROFILE
 GRASSED EMBANKMENT
 FGL FINISHED GROUND LEVEL

F02	FINAL FOR PLANNING	AP	MG	SW	Dec.2025
F01	FINAL FOR PLANNING	AP	MG	SW	Dec.2025
Rev	Description	Drawn	Chk'd	App'd	Date

This drawing is the property of Uisce Éireann and must not be copied or used for any purpose other than that for which it is supplied without the written consent of Uisce Éireann.

UISCE ÉIREANN
 COLVILL HOUSE,
 TALBOT STREET,
 DUBLIN 1,
 IRELAND

Call 1890 278 278
 Int: 00 353 1 707 2828

Jacobs TOBIN

Originated By MG	Drawn By PC	Checked By MG	Approved By SW
Date 21.03.25	Date 01.12.2025	Date 01.12.2025	Date 01.12.2025


Scale: 1:200 @ A1 FINAL

Project Title
 WATER SUPPLY PROJECT
 EASTERN AND MIDLANDS REGION



Drawing Title
 TERMINATION POINT RESERVOIR
 SOUTH WEST ELEVATION

Drawing Status: FINAL FOR PLANNING
 Jacobs Tobin No. 32105801 Client No. 9318


Drawing No.
32105801-850-06011

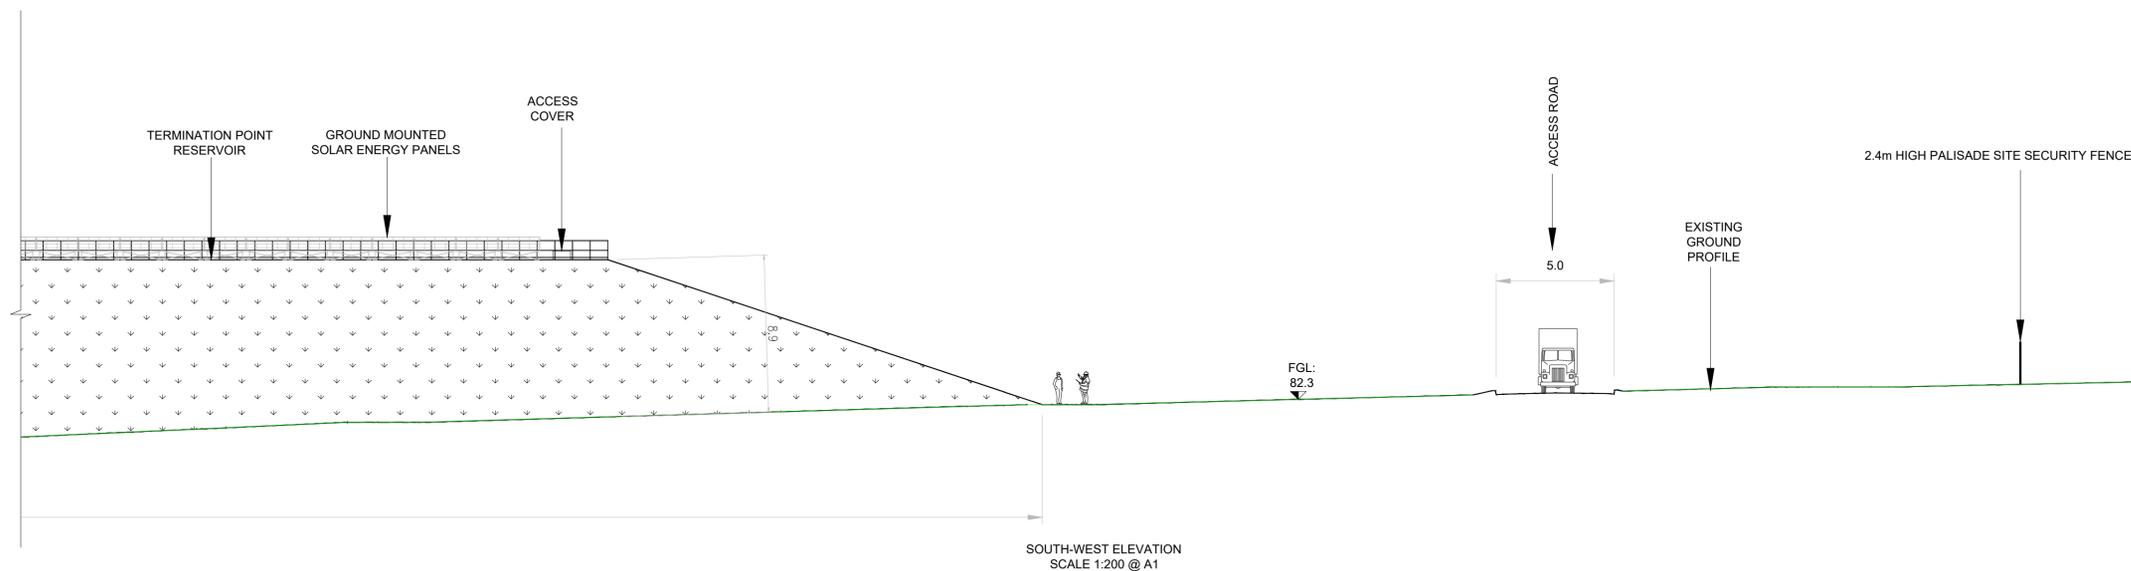

- Notes:
1. ALL DIMENSIONS ARE IN METRES AND ALL LEVELS IN METRES UNLESS OTHERWISE STATED.
 2. THIS DRAWING IS NOT TO BE SCALED. FIGURED DIMENSIONS ONLY TO BE TAKEN.
 3. THIS DRAWING IS FOR PLANNING PURPOSES ONLY.

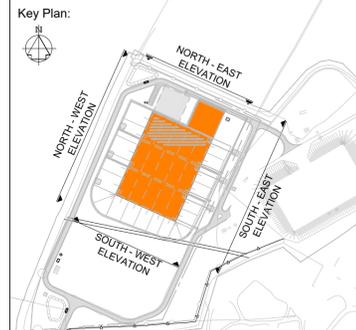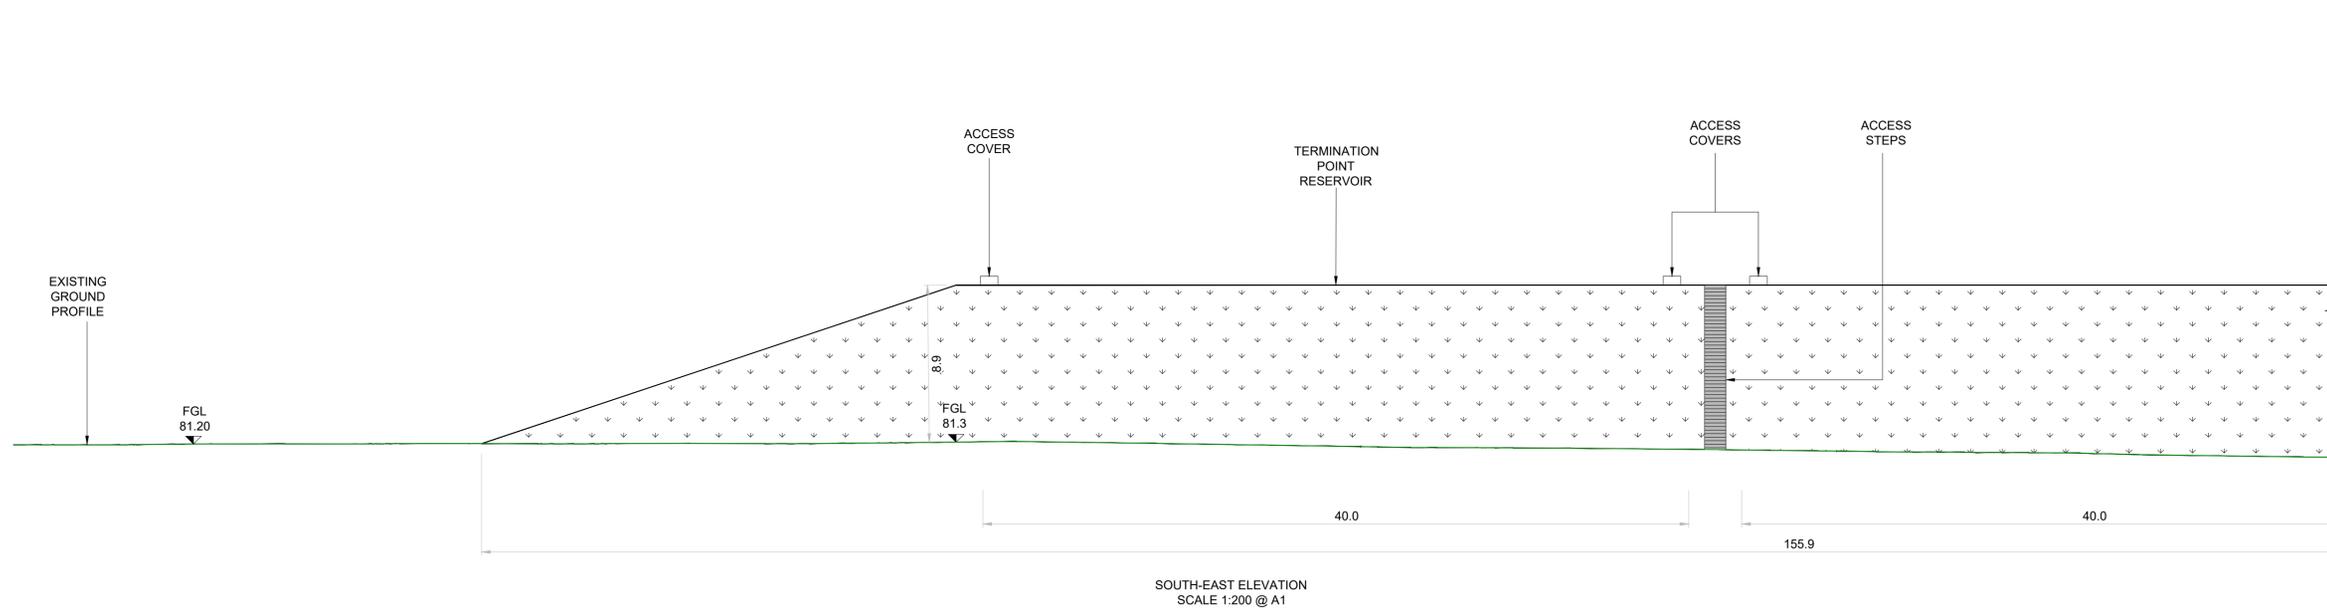

- LEGEND:
- EXISTING:
- GROUND PROFILE
- PROPOSED:
- GROUND PROFILE
 - ▾ GRASSED EMBANKMENT
 - ▽ FGL FINISHED GROUND LEVEL

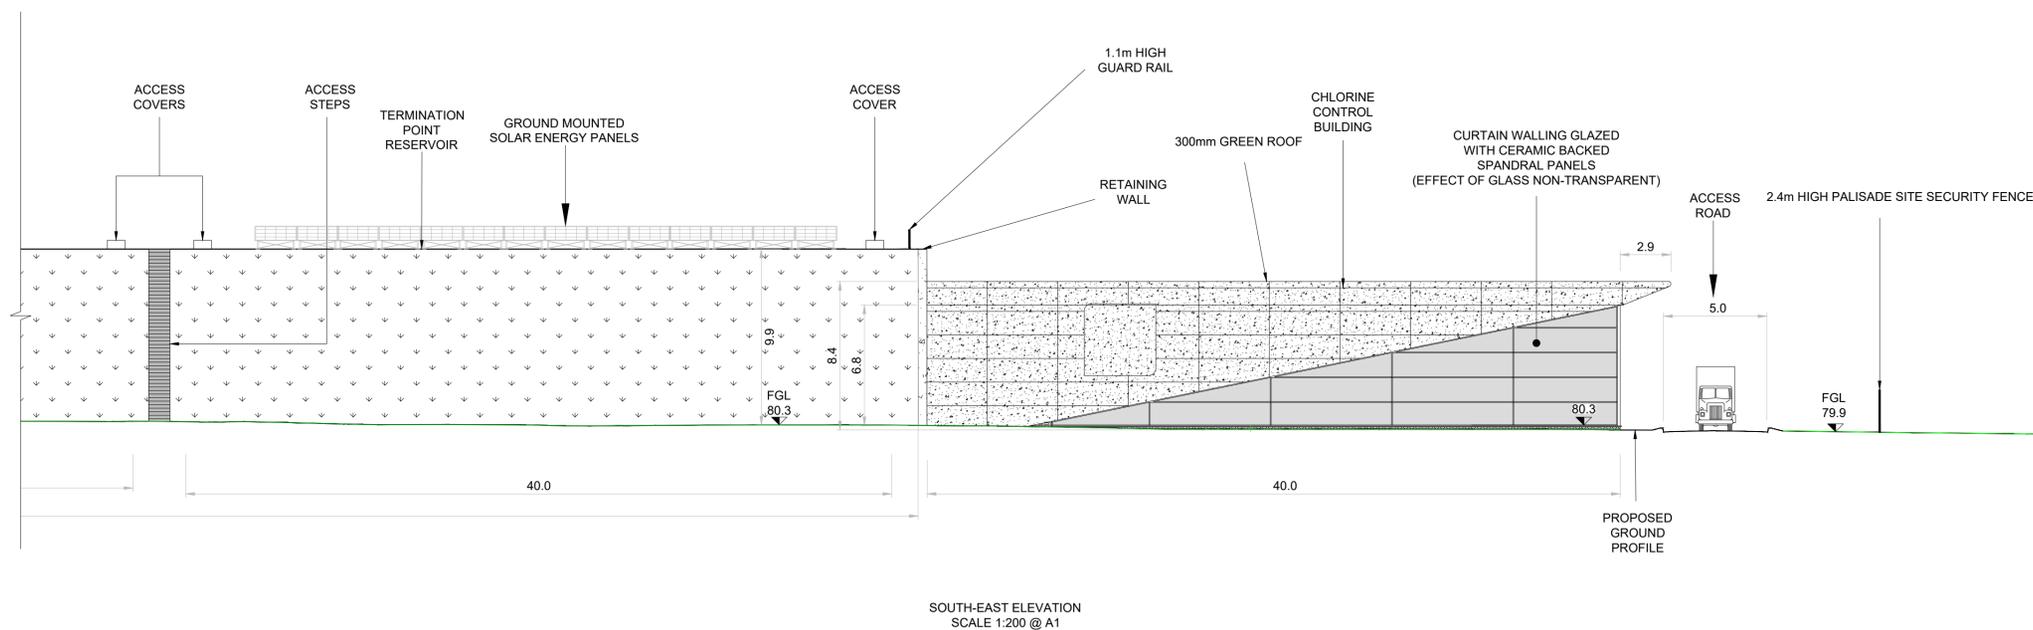

F02	FINAL FOR PLANNING	AP	MG	SW	Dec. 2025
F01	FINAL FOR PLANNING	AP	MG	SW	Dec. 2025
Rev	Description	Drawn	Chk'd	App'd	Date

This drawing is the property of Uisce Éireann and must not be copied or used for any purpose other than that for which it is supplied without the written consent of Uisce Éireann.

Uisce Éireann
Irish Water

Tionscadal Soláthair Uisce
Water Supply Project

UISCE ÉIREANN
COLVILL HOUSE,
TALBOT STREET,
DUBLIN 1,
IRELAND

Call 1890 278 278
Int: 00 353 1 707 2828

Jacobs TOBIN

Originated By	Drawn By	Checked By	Approved By
MG	AP	MG	SW
Date	Date	Date	Date
21.03.25	01.12.2025	01.12.2025	01.12.2025

Scale: 1:200 @ A1

FINAL

Project Title: WATER SUPPLY PROJECT
EASTERN AND MIDLANDS REGION





Drawing Title: TERMINATION POINT RESERVOIR
SOUTH EAST ELEVATION

Drawing Status: FINAL FOR PLANNING
Jacobs Tobin No. 32105801 Client No. 9318

Drawing No. 32105801-850-06012



- Notes:
1. ALL DIMENSIONS ARE IN METRES AND ALL LEVELS IN METRES UNLESS OTHERWISE STATED.
 2. THIS DRAWING IS NOT TO BE SCALED. FIGURED DIMENSIONS ONLY TO BE TAKEN.
 3. THIS DRAWING IS FOR PLANNING PURPOSES ONLY.

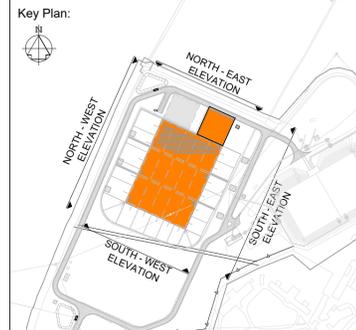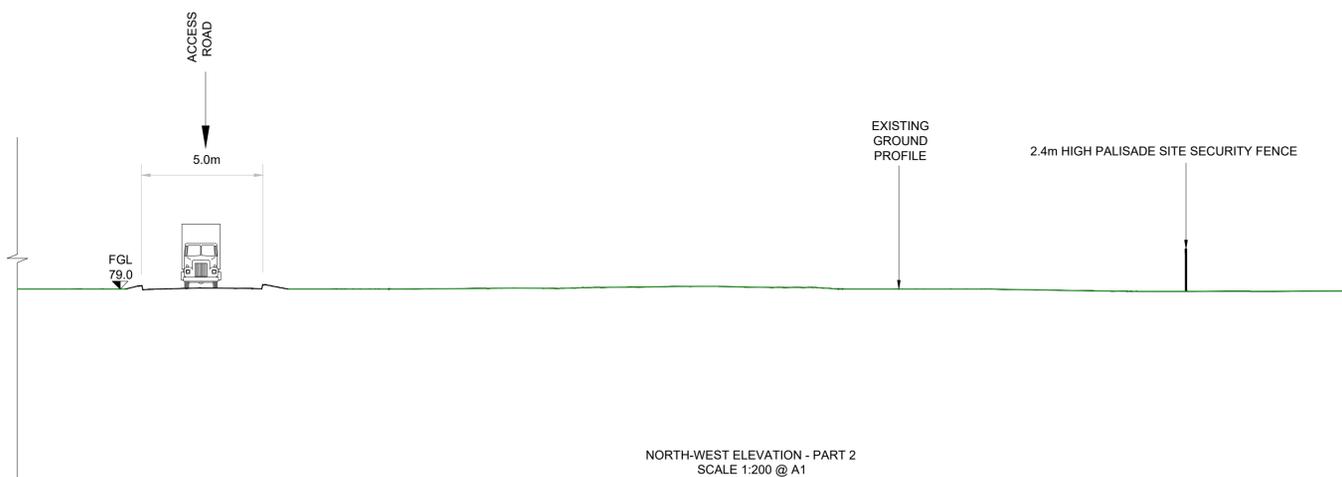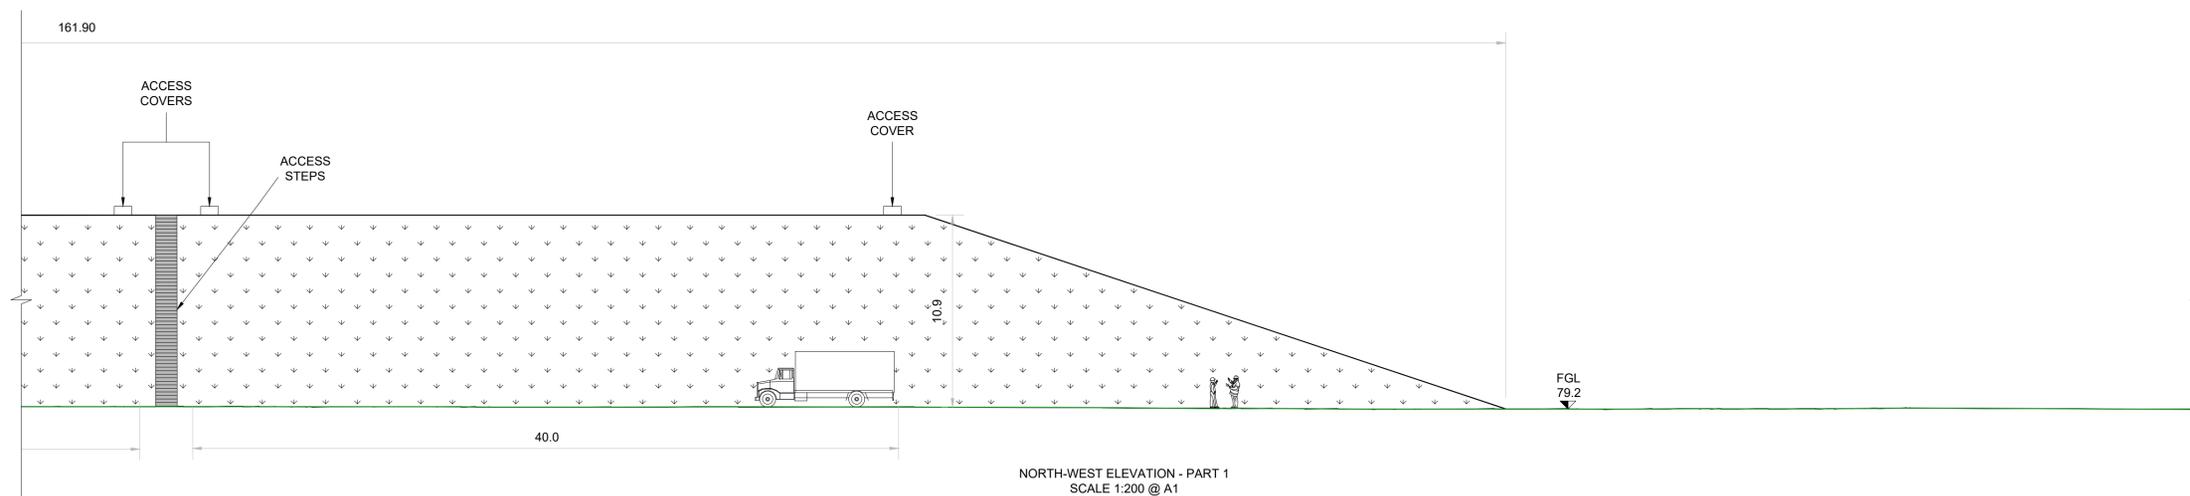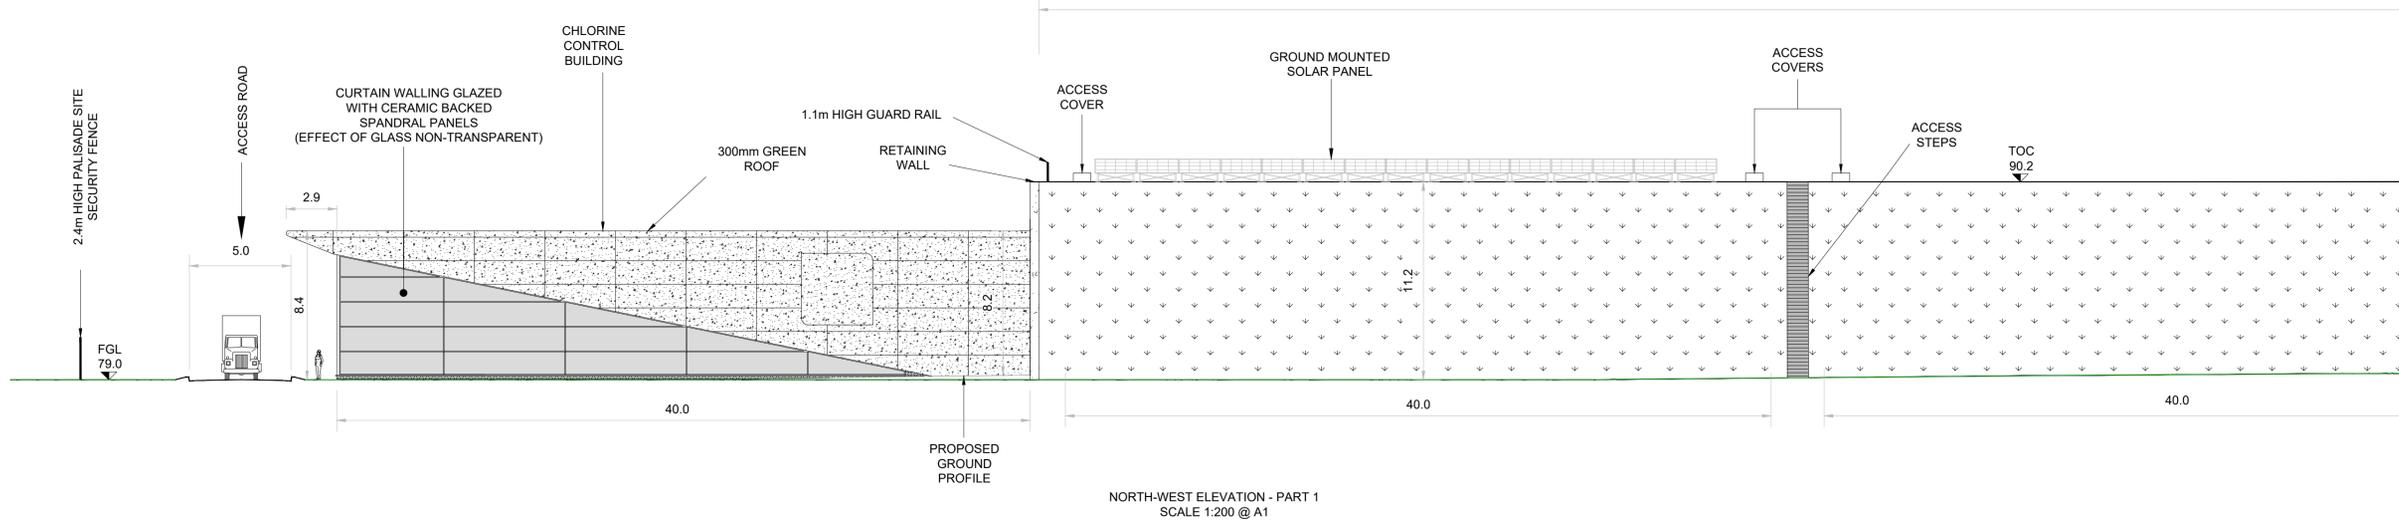

- LEGEND:
- EXISTING: GROUND PROFILE
 - PROPOSED: GROUND PROFILE
 - GRASSED EMBANKMENT
 - FGL FINISHED GROUND LEVEL

F02	FINAL FOR PLANNING	AP	MG	SW	Dec. 2025
F01	FINAL FOR PLANNING	AP	MG	SW	Dec. 2025
Rev	Description	Drawn	Chk'd	App'd	Date

Uisce Éireann
Irish Water

Tionscadal Soláthair Uisce
Water Supply Project

UISCE ÉIREANN
COLVILL HOUSE,
TALBOT STREET,
DUBLIN 1,
IRELAND

Call 1890 278 278
Int: 00 353 1 707 2828

JACOBS TOBIN

Originated By MG	Drawn By AP	Checked By MG	Approved By SW
Date 21.03.25	Date 01.12.2025	Date 01.12.2025	Date 01.12.2025

 
Scale: 1:200 @ A1 **DO NOT SCALE**

Project Title
WATER SUPPLY PROJECT
EASTERN AND MIDLANDS REGION


Drawing Title
TERMINATION POINT RESERVOIR
NORTH WEST ELEVATION

Drawing Status: FINAL FOR PLANNING
Jacobs Tobin No. 32105801 Client No. 9318


Drawing No.
32105801-850-06013




- Notes:
1. ALL DIMENSIONS ARE IN METRES AND ALL LEVELS IN METRES UNLESS OTHERWISE STATED.
 2. THIS DRAWING IS NOT TO BE SCALED. FIGURED DIMENSIONS ONLY TO BE TAKEN.
 3. THIS DRAWING IS FOR PLANNING PURPOSES ONLY.

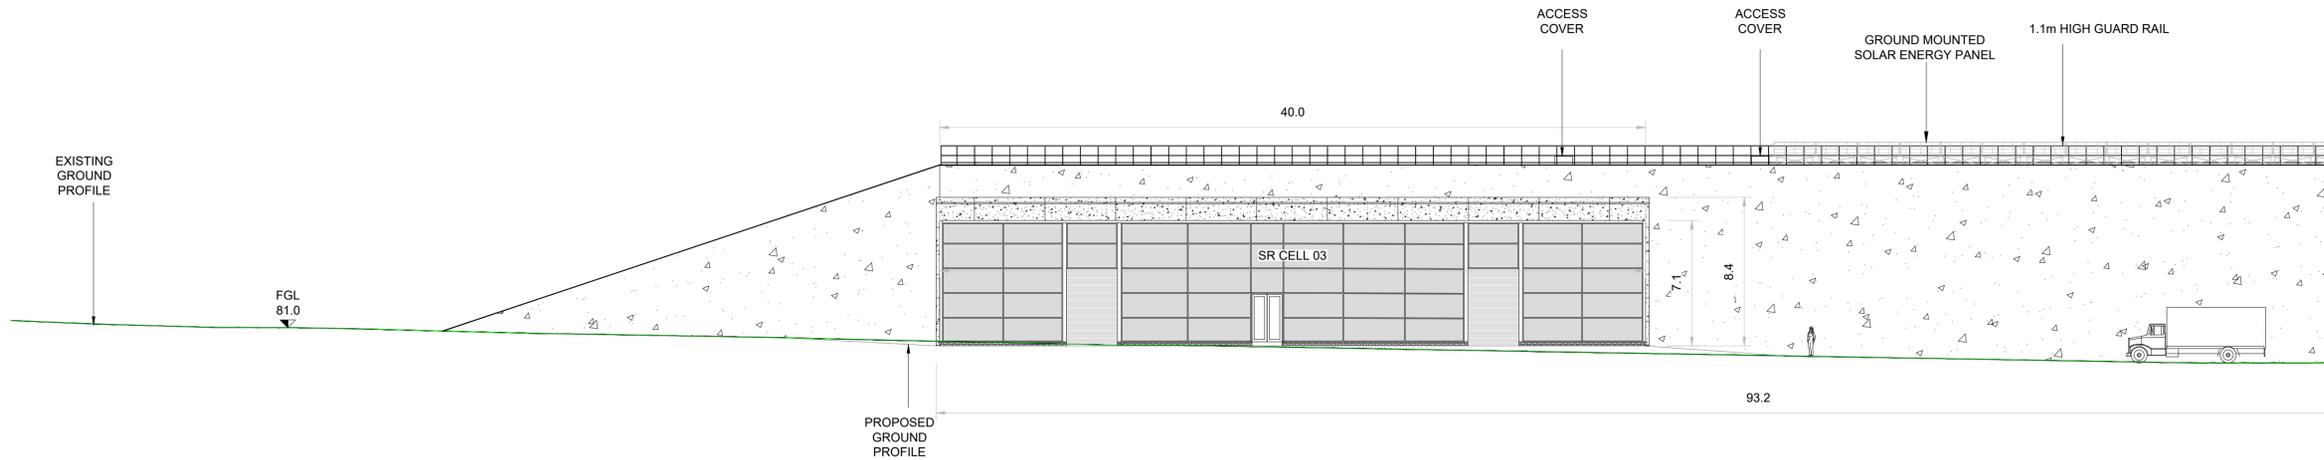

NORTH-EAST ELEVATION
SCALE 1:200 @ A1

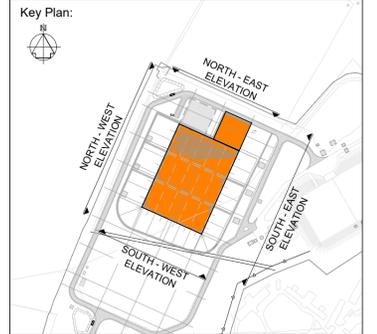

- LEGEND:
- EXISTING:
— GROUND PROFILE
- PROPOSED:
— GROUND PROFILE
△ CONCRETE
FGL FINISHED GROUND LEVEL

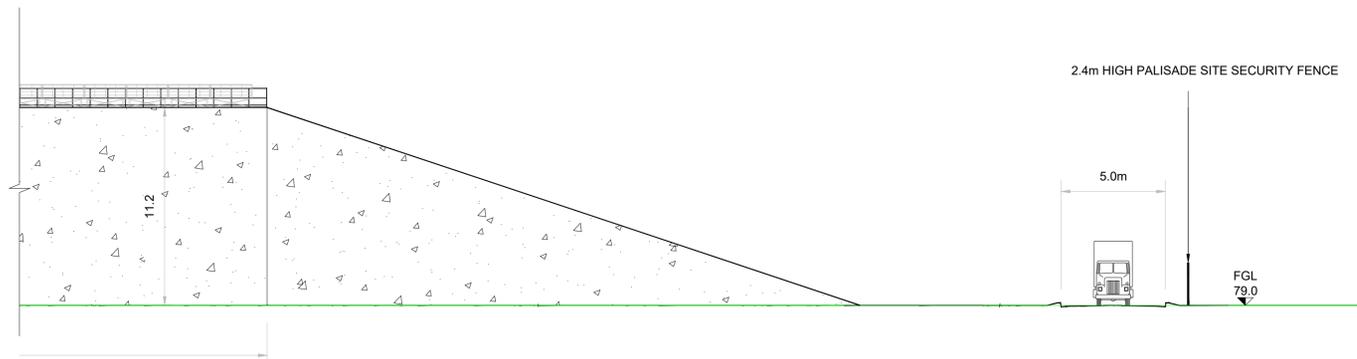

NORTH-EAST ELEVATION
SCALE 1:200 @ A1

F02	FINAL FOR PLANNING	PC	MG	SW	Dec. 2025
F01	FINAL FOR PLANNING	PC	MG	SW	Dec. 2025
Rev	Description	Drawn	Chk'd	App'd	Date

This drawing is the property of Uisce Éireann and must not be copied or used for any purpose other than that for which it is supplied without the written consent of Uisce Éireann.

Uisce Éireann
Irish Water

Tionscadal Soláthair Uisce
Water Supply Project

UISCE ÉIREANN
COLVILL HOUSE,
TALBOT STREET,
DUBLIN 1,
IRELAND

Call 1890 278 278
Int: 00 353 1 707 2828

Jacobs TOBIN


Originated By MG	Drawn By PC	Checked By MG	Approved By SW
Date 21.03.25	Date 01.12.2025	Date 01.12.2025	Date 01.12.2025
Scale 1:200 @ A1		DO NOT SCALE	


Project Title
WATER SUPPLY PROJECT
EASTERN AND MIDLANDS REGION

Drawing Title
TERMINATION POINT RESERVOIR
NORTH EAST ELEVATION

Drawing Status
FINAL FOR PLANNING
Jacobs Tobin No. 32105801 Client No. 9318

 Drawing No.
32105801-850-06014







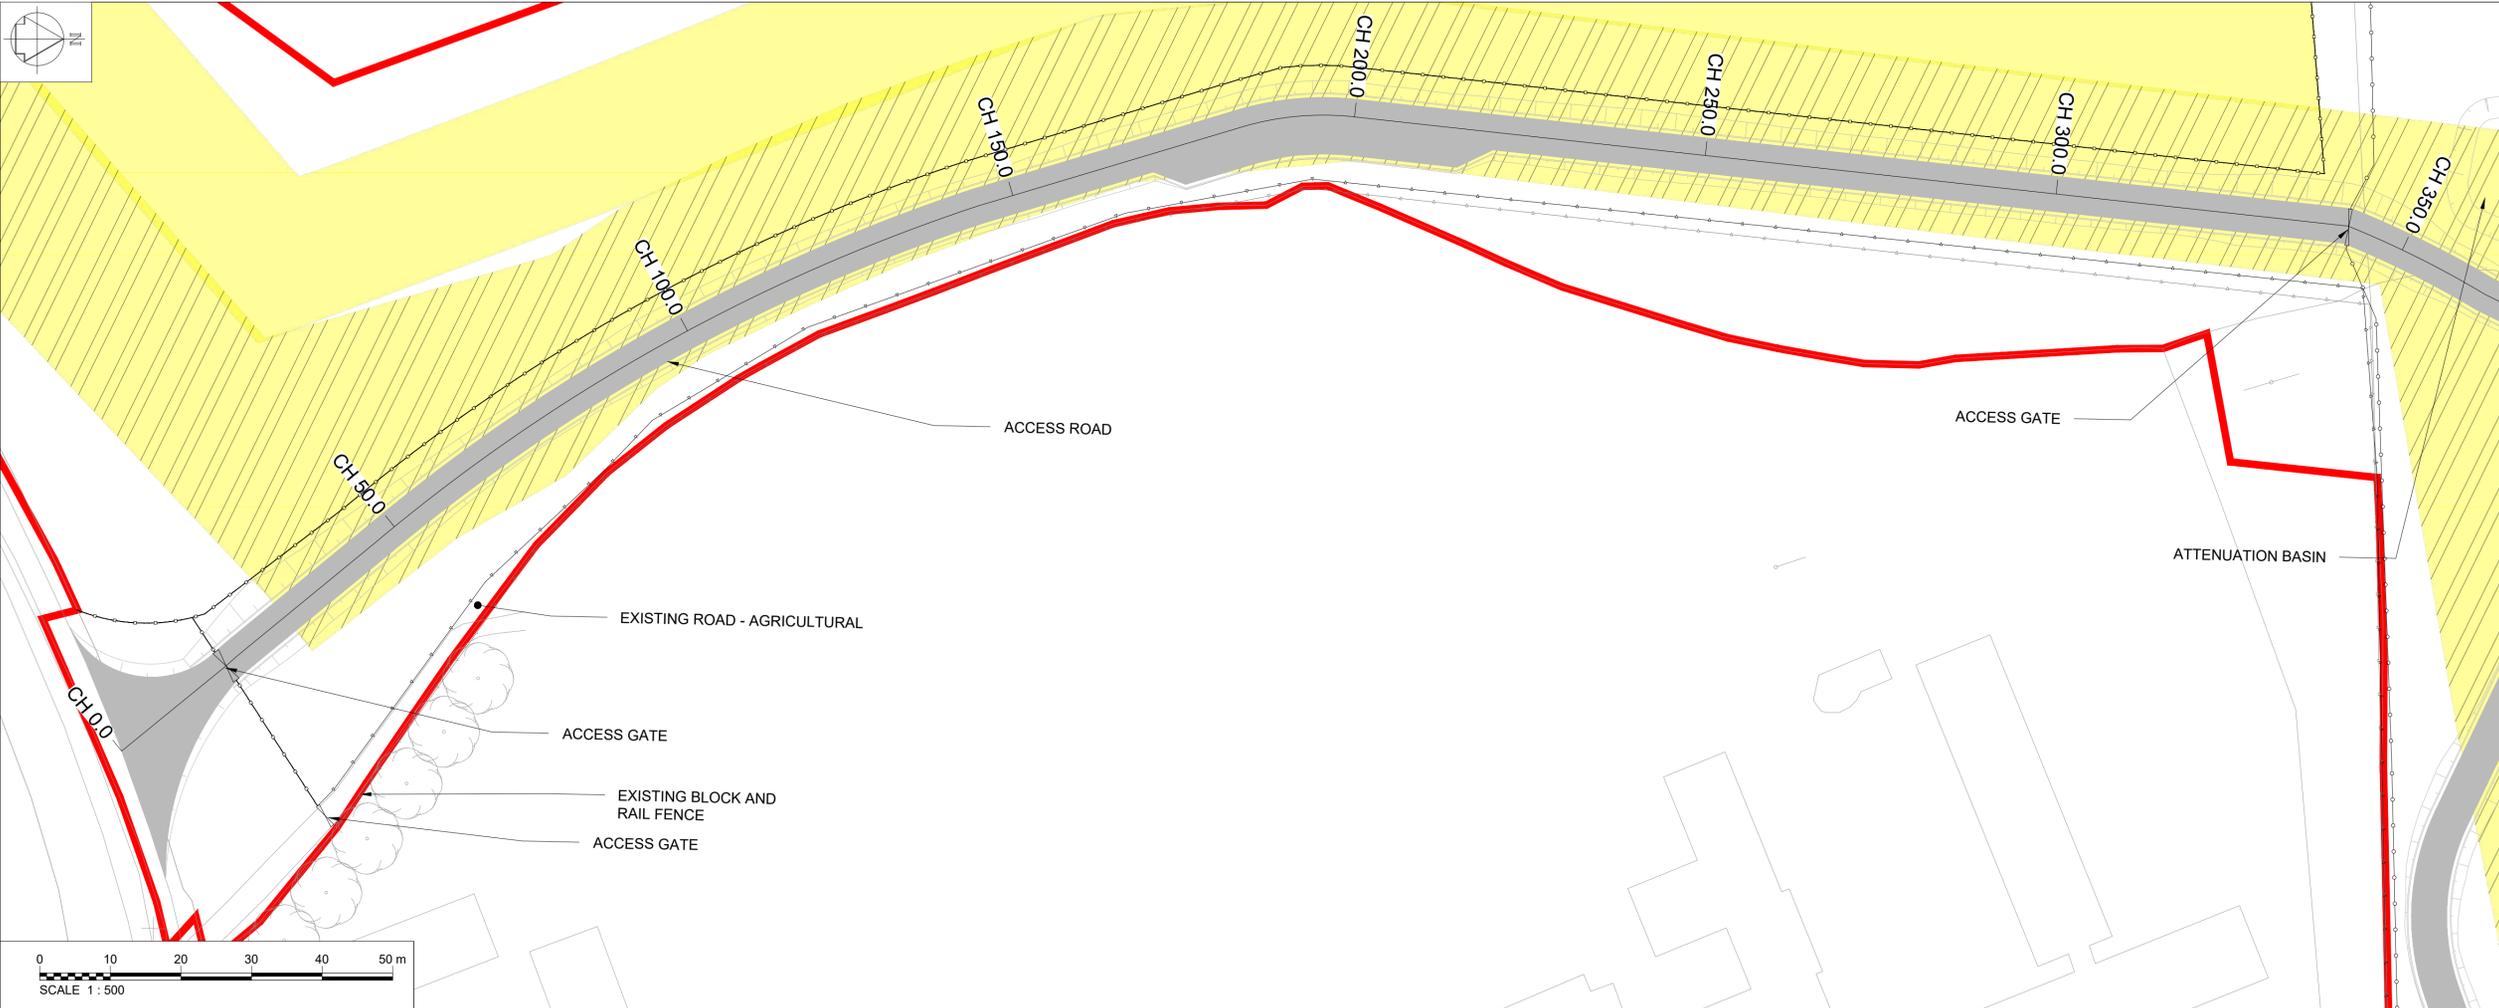

- Notes:
1. ALL DIMENSIONS ARE IN METRES AND ALL LEVELS ARE IN METRES AOD MALIN HEAD UNLESS OTHERWISE STATED.
 2. THIS DRAWING IS NOT TO BE SCALED. FIGURED DIMENSIONS ONLY TO BE TAKEN.
 3. THIS DRAWING IS FOR PLANNING PURPOSES ONLY.
 4. THE LOCATIONS OF EXISTING SERVICES ARE NOT SHOWN FOR CLARITY.

- LEGEND:
- PLANNING APPLICATION BOUNDARY
 - INDICATIVE PERMANENT WAYLEAVE
 - PERMANENT WAYLEAVE FOR EXISTING 1200mm MAIN
- EXISTING:
- BLOCK AND RAIL FENCE
- PROPOSED:
- 1.2m HIGH POST AND RAIL FENCE
 - 2.4m HIGH PALISADE SITE SECURITY FENCE
 - ROAD / HARDSTAND SURFACE

OSI Sheet No's:
3325-A.3325-C.

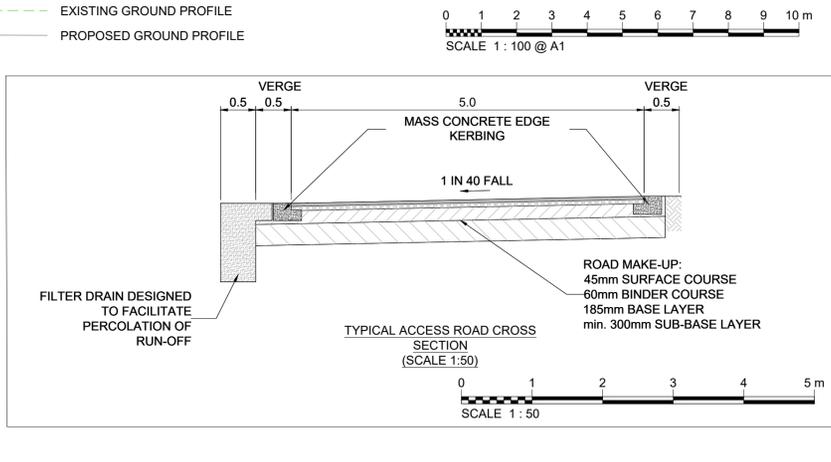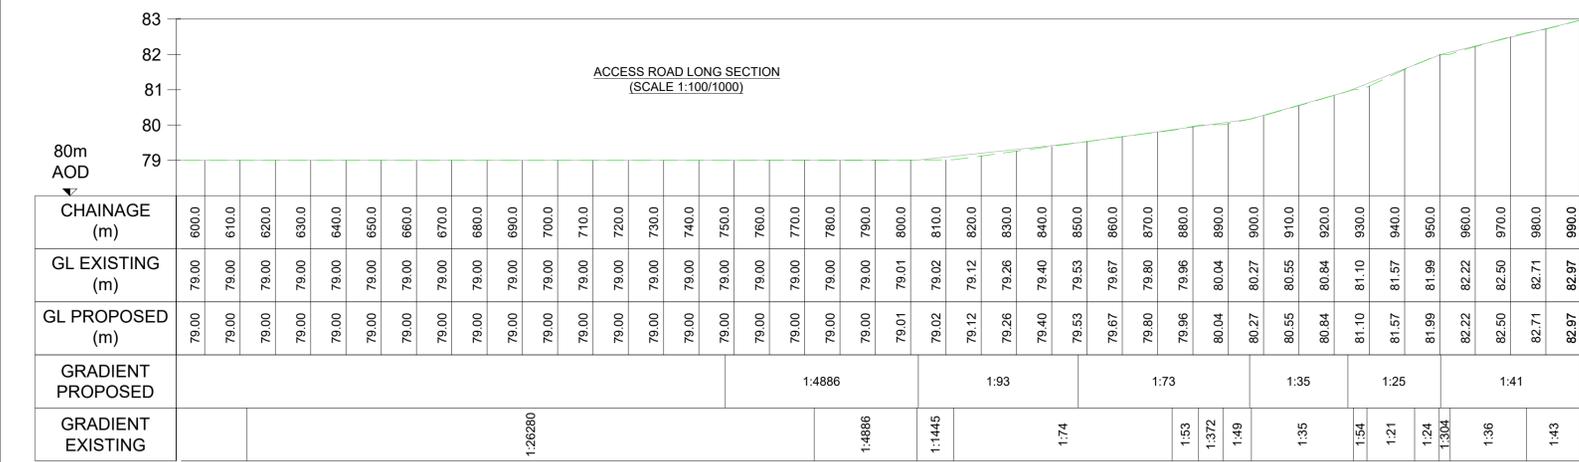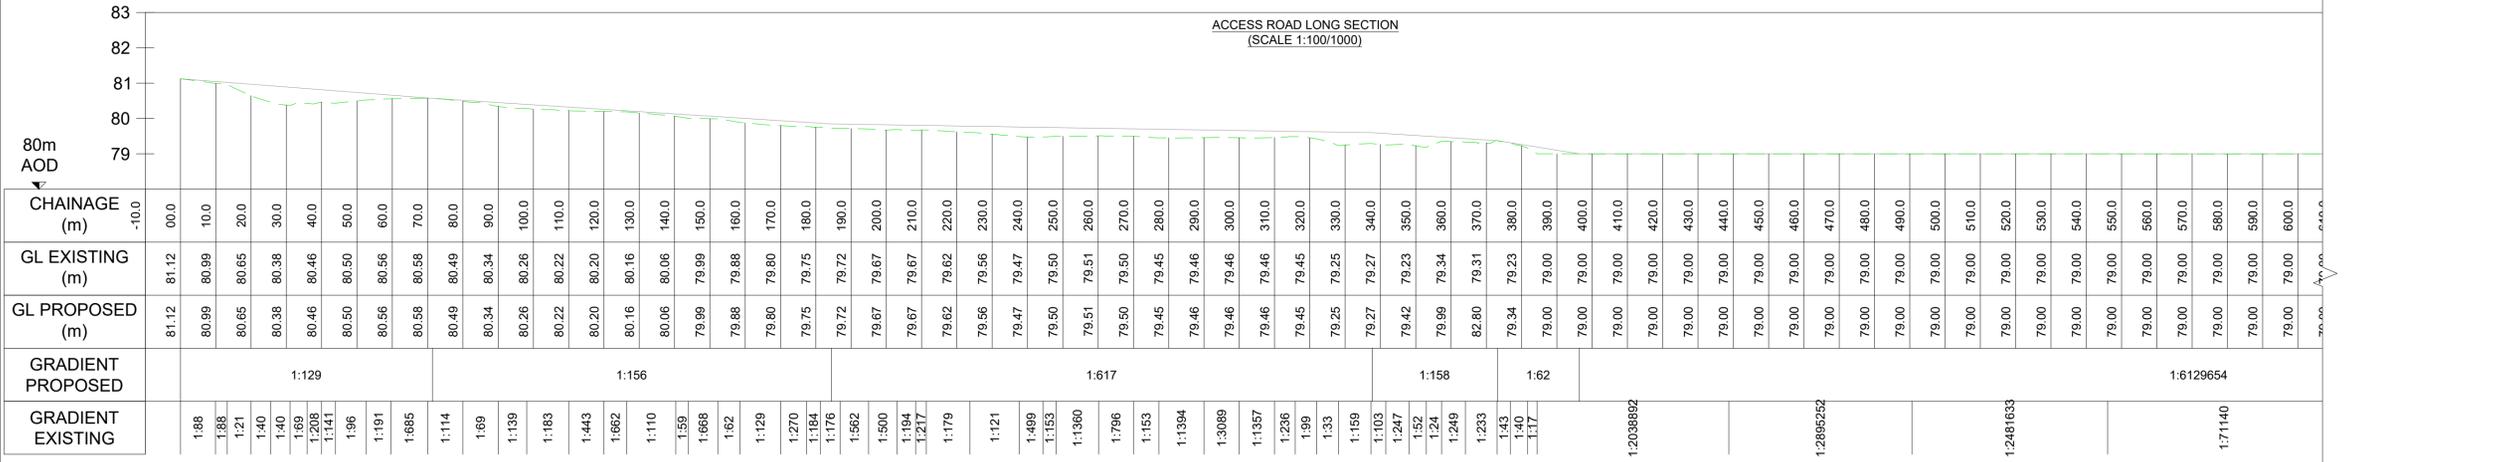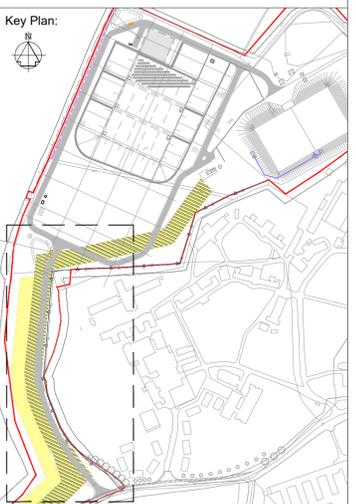

F02	FINAL FOR PLANNING	AP	MG	SW	Dec. 2025
F01	FINAL FOR PLANNING	AP	MG	SW	Dec. 2025
Rev	Description	Drawn	Chk'd	App'd.	Date

Uisce Éireann
Irish Water
Tionscadal Soláthair Uisce
Water Supply Project

UISCÉ ÉIREANN
COLVILL HOUSE,
TALBOT STREET,
DUBLIN 1,
IRELAND

Call 1890 278 278
Int: 00 353 1 707 2828

JACOBS TOBIN

Scale	AS SHOWN @ A1	FINAL
Project Title	WATER SUPPLY PROJECT EASTERN AND MIDLANDS REGION	
Drawing Title	TERMINATION POINT RESERVOIR PROPOSED ACCESS ROAD SHEET 01	
Drawing Status	FINAL FOR PLANNING	
Jacobs Tobin No.	32105801	Client No. 9318
Drawing No.	32105801-850-06015	




 


 

- Notes:
1. ALL DIMENSIONS ARE IN METRES AND ALL LEVELS ARE IN METRES AOD UNLESS OTHERWISE STATED.
 2. THIS DRAWING IS NOT TO BE SCALED. FIGURED DIMENSIONS ONLY TO BE TAKEN.
 3. THIS DRAWING IS FOR PLANNING PURPOSES ONLY.
 4. THE LOCATIONS OF EXISTING SERVICES ARE NOT SHOWN FOR CLARITY.

- LEGEND:
- PLANNING APPLICATION BOUNDARY
 - INDICATIVE PERMANENT WAYLEAVE
 - ▨ PERMANENT WAYLEAVE FOR EXISTING 1200mm MAIN

- EXISTING:
- BLOCK AND RAIL FENCE

- PROPOSED:
- 1.2m HIGH POST AND RAIL FENCE
 - 2.4m HIGH PALISADE SITE SECURITY FENCE
 - ROAD / HARDSTAND SURFACE
 - BELOW GROUND STRUCTURES

OSI Sheet No's:
3325-A

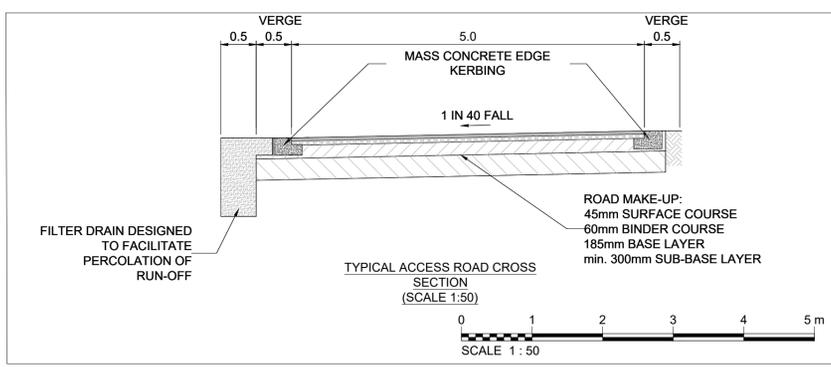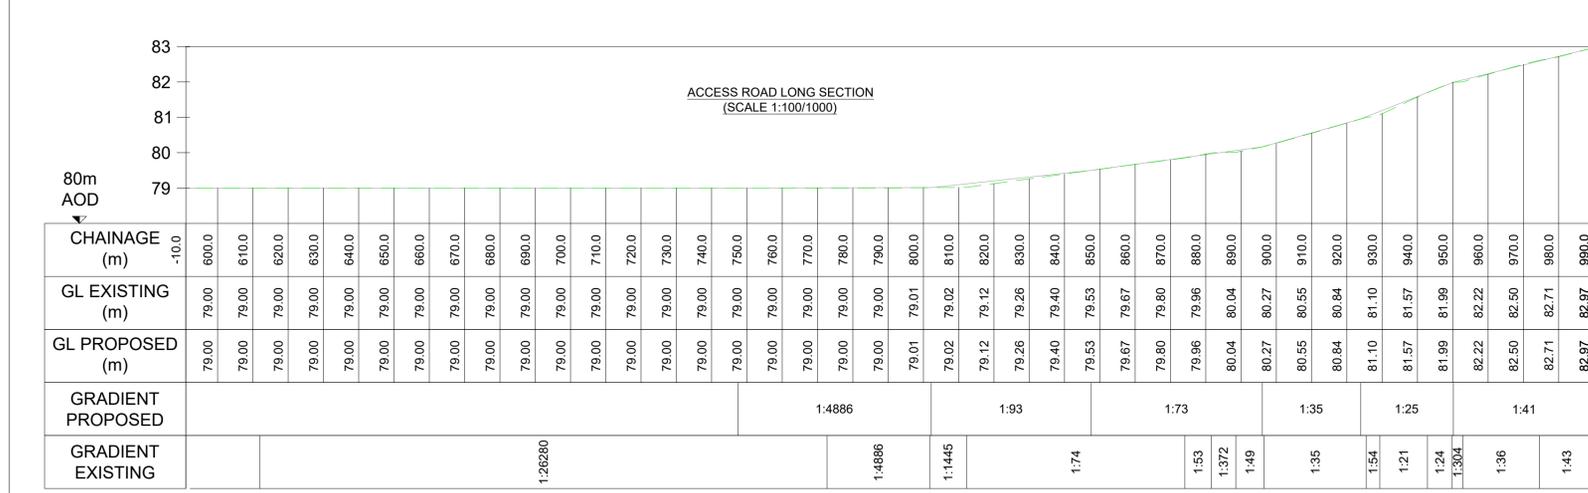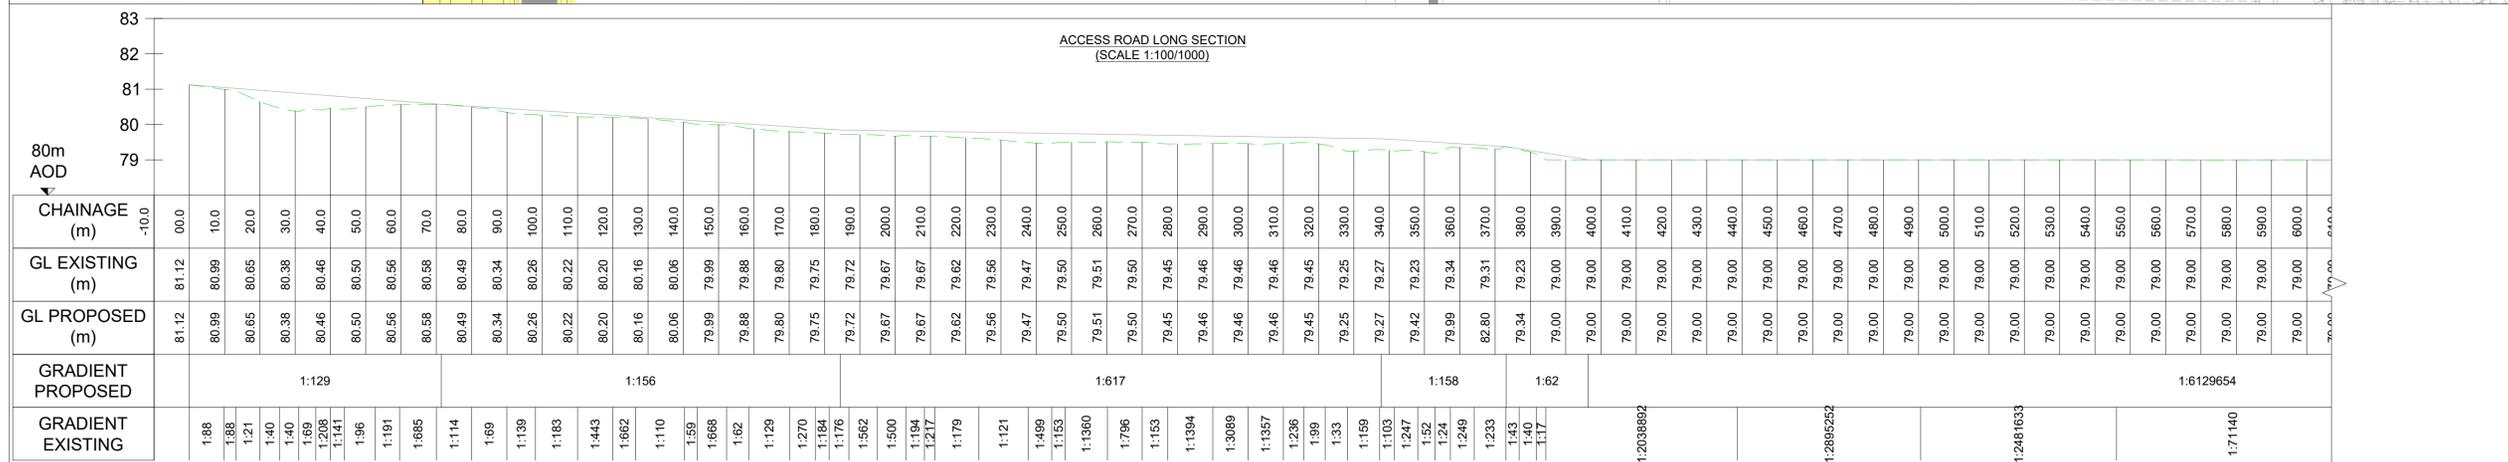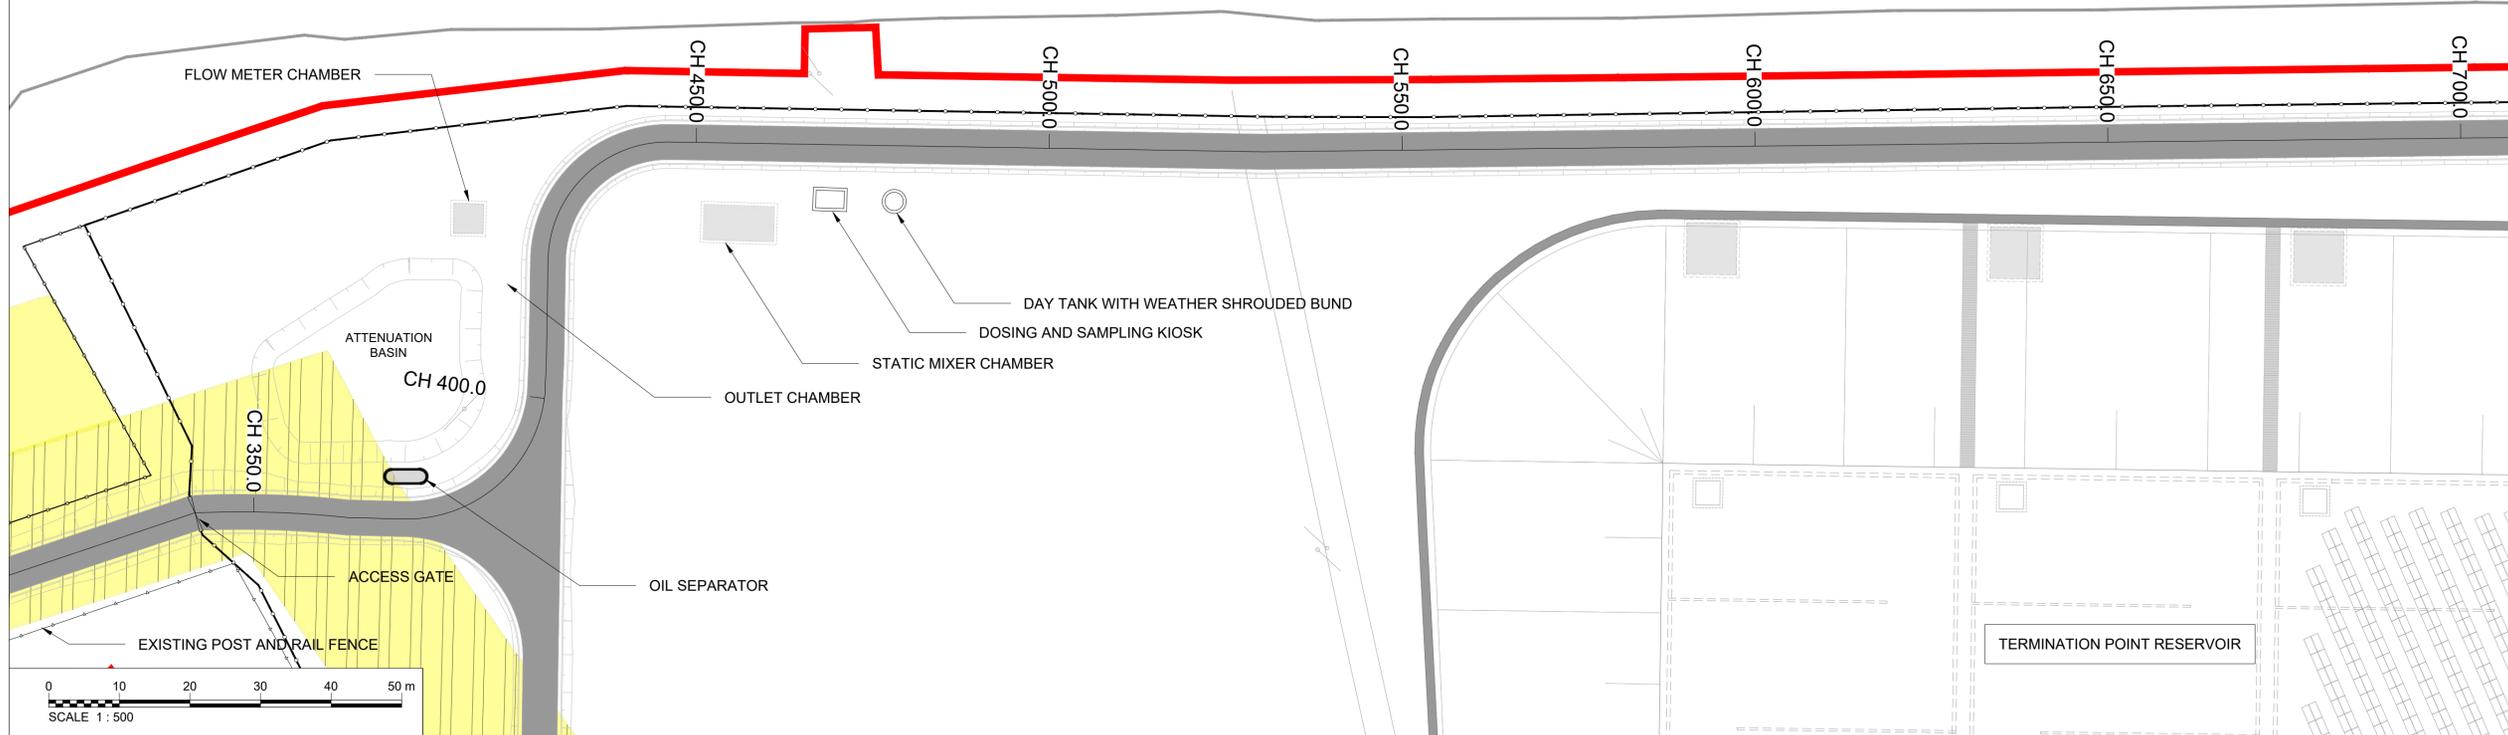

F02	FINAL FOR PLANNING	AP	MG	SW	Dec. 2025
F01	FINAL FOR PLANNING	AP	MG	SW	Dec. 2025
Rev	Description	Drawn	Chk'd	App'd.	Date

This drawing is the property of Usisce Éireann and must not be copied or used for any purpose other than that for which it is supplied without the written consent of Usisce Éireann.

Usisce Éireann
Irish Water

Tionscadal Soláthair Usisce
Water Supply Project

USISCE ÉIREANN
COLVILL HOUSE,
TALBOT STREET,
DUBLIN 1,
IRELAND

Call 1890 278 278
Int: 00 353 1 707 2828

JACOBS TOBIN

Scale	AS SHOWN @ A1	FINAL
Project Title	WATER SUPPLY PROJECT EASTERN AND MIDLANDS REGION	
Drawing Title	TERMINATION POINT RESERVOIR PROPOSED ACCESS ROAD SHEET 02	
Drawing Status	FINAL FOR PLANNING	
Jacobs Tobin No.	32105801	Client No. 9318
Drawing No.	32105801-850-06016	






 

- Notes:
1. ALL DIMENSIONS ARE IN METRES AND ALL LEVELS ARE IN METRES AOD MALIN HEAD UNLESS OTHERWISE STATED.
 2. THIS DRAWING IS NOT TO BE SCALED. FIGURED DIMENSIONS ONLY TO BE TAKEN.
 3. THIS DRAWING IS FOR PLANNING PURPOSES ONLY.
 4. THE LOCATIONS OF EXISTING SERVICES ARE NOT SHOWN FOR CLARITY.

- LEGEND:
- PLANNING APPLICATION BOUNDARY
 - INDICATIVE PERMANENT WAYLEAVE
 - PERMANENT WAYLEAVE FOR EXISTING 1200mm MAIN

- EXISTING:
- BLOCK AND RAIL FENCE

- PROPOSED:
- 1.2m HIGH POST AND RAIL FENCE
 - 2.4m HIGH PALISADE SITE SECURITY FENCE
 - ROAD / HARDSTAND SURFACE
 - BUILDING

OSI Sheet No's:
3325-A

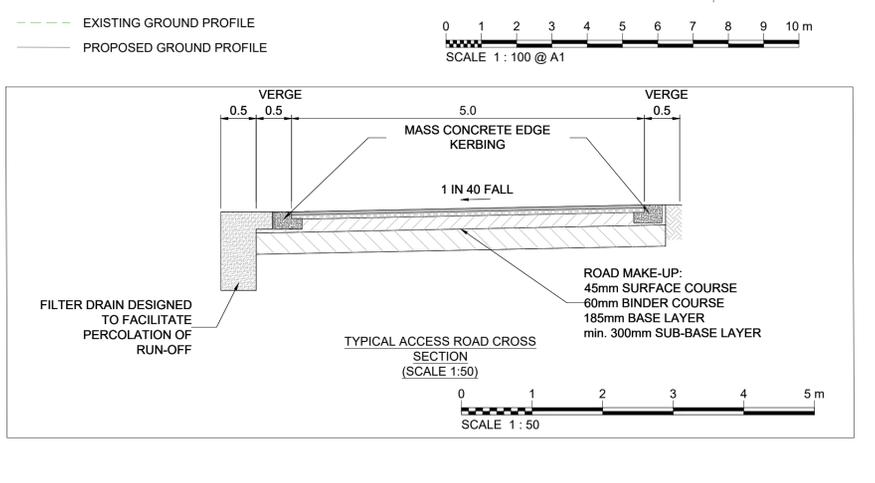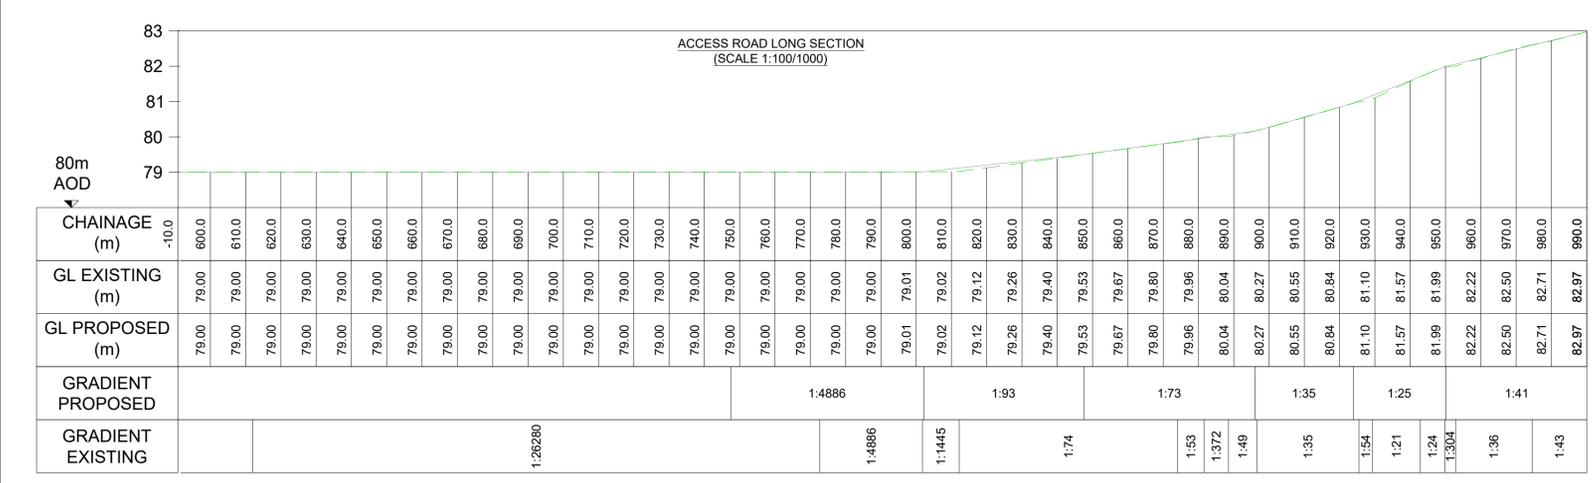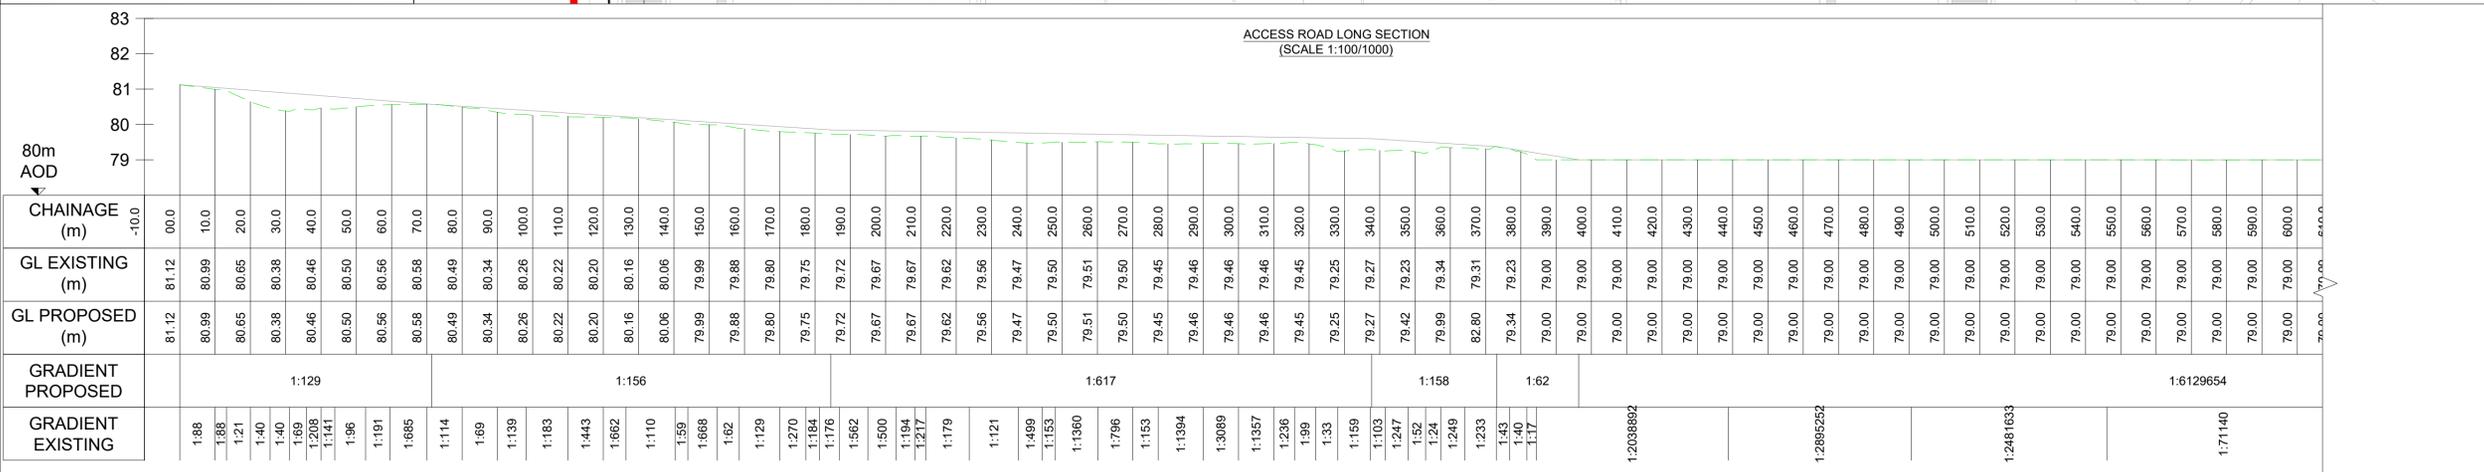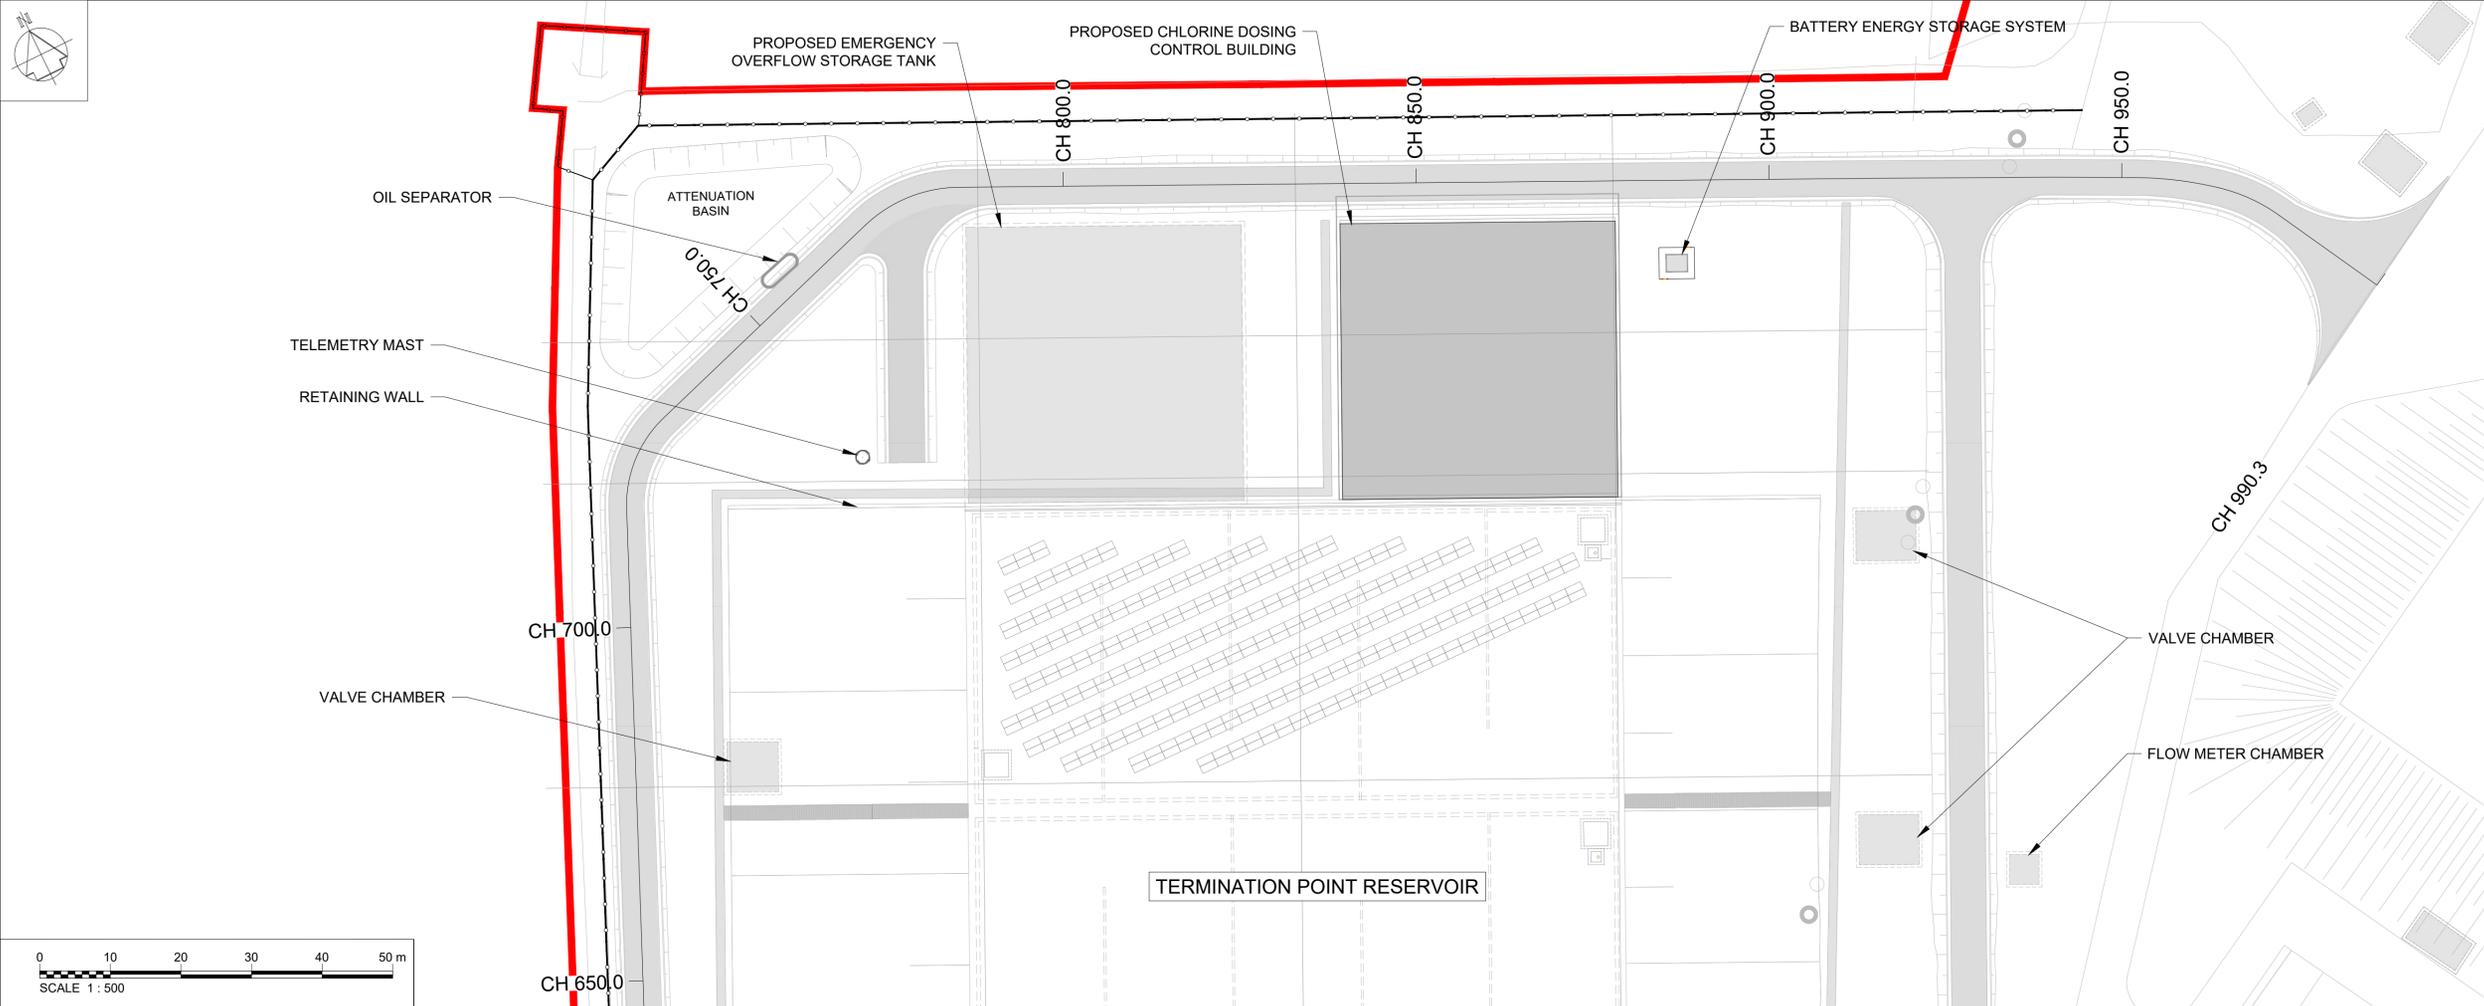

Rev	Description	Drawn	Chk'd	App'd	Date
F02	FINAL FOR PLANNING	AP	MG	SW	Dec. 2025
F01	FINAL FOR PLANNING	AP	MG	SW	Dec. 2025

Uisce Éireann
Irish Water

Tionscatal Soláthair Uisce
Water Supply Project

UISCE ÉIREANN
COLVILL HOUSE,
TALBOT STREET,
DUBLIN 1,
IRELAND

Call 1890 278 278
Int: 00 353 1 707 2828

JACOBS TOBIN

Originated By	Drawn By	Checked By	Approved By
MG	PC	MG	SW
Date	Date	Date	Date
21.03.25	01.12.2025	01.12.2025	01.12.2025


Scale: AS SHOWN @ A1

Project Title: WATER SUPPLY PROJECT
EASTERN AND MIDLANDS REGION

Drawing Title: TERMINATION POINT RESERVOIR
PROPOSED ACCESS ROAD
SHEET 03


Drawing Status: FINAL FOR PLANNING
Jacobs Tobin No. 32105801 Client No. 9318

Drawing No. 32105801-850-06017

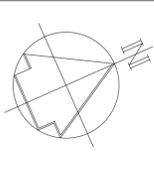

Notes:
1. ALL DIMENSIONS ARE IN METRES AND ALL LEVELS ARE IN METRES AOD MALIN HEAD UNLESS OTHERWISE STATED.
2. THIS DRAWING IS NOT TO BE SCALED. FIGURED DIMENSIONS ONLY TO BE TAKEN.
3. THIS DRAWING IS FOR PLANNING PURPOSES ONLY.

- LEGEND:
- PLANNING APPLICATION BOUNDARY
 - INDICATIVE PERMANENT WAYLEAVE
 - PERMANENT WAYLEAVE FOR EXISTING 1200mm MAIN
- EXISTING:
- BLOCK AND RAIL FENCE
 - 300/350mmØ SCOUR PIPE
 - PROPOSED PIPELINE CENTRELINE
- PROPOSED:
- 1.2m HIGH POST AND RAIL FENCE
 - 2.4m HIGH PALISADE SITE SECURITY FENCE
 - ROAD / HARDSTAND SURFACE
 - BELOW GROUND STRUCTURES
 - PROPOSED PIPELINE CENTRELINE
 - FOUL SEWER DIVERSION
 - FOUL SEWER ABANDONMENT
 - SURFACE WATER DRAINAGE
 - SURFACE WATER FILTER DRAIN
 - CCTV DROP DOWN POLE

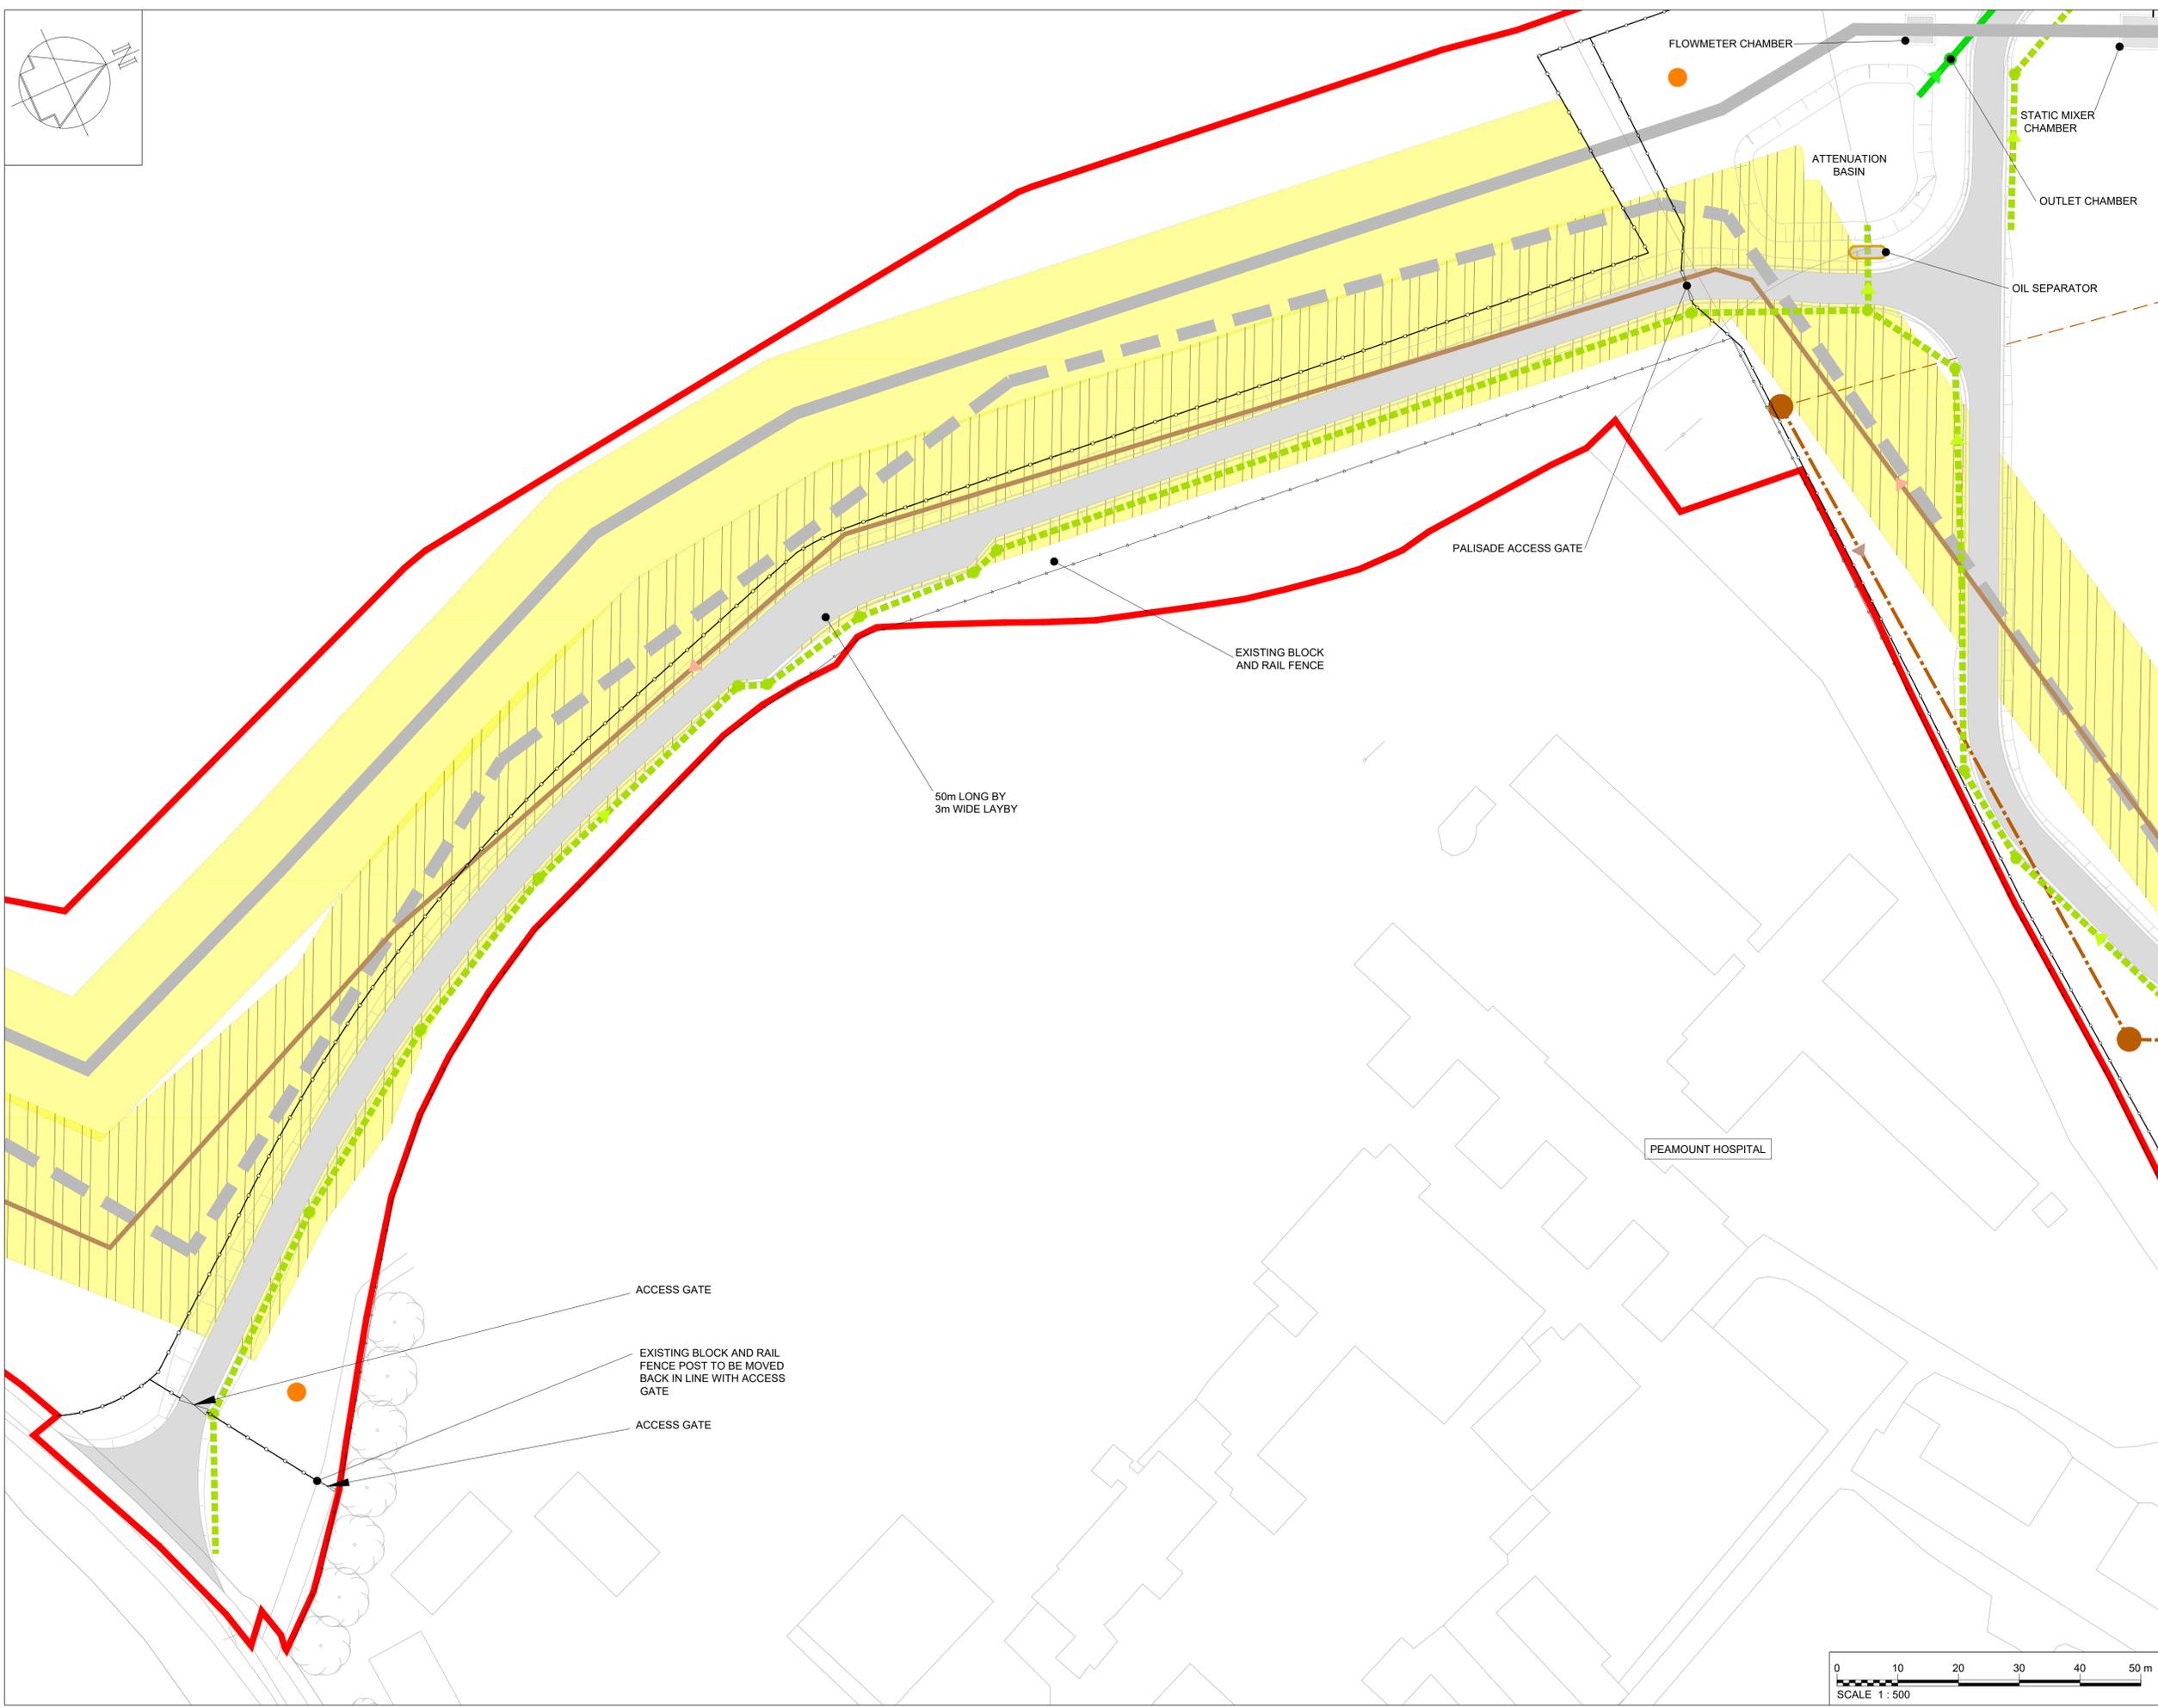

50m LONG BY
3m WIDE LAYBY

EXISTING BLOCK
AND RAIL FENCE

PALISADE ACCESS GATE

PEAMOUNT HOSPITAL

ACCESS GATE

EXISTING BLOCK AND RAIL
FENCE POST TO BE MOVED
BACK IN LINE WITH ACCESS
GATE

ACCESS GATE

OSI Sheet No's:
3325-A, 3325-C.

F02	FINAL FOR PLANNING	AP	MG	SW	Dec. 2025
F01	FINAL FOR PLANNING	AP	MG	SW	Dec. 2025
Rev	Description	Drawn	Chk'd	App'd.	Date

This drawing is the property of Uisce Éireann and must not be copied or used for any purpose other than that for which it is supplied without the written consent of Uisce Éireann.

Uisce Éireann
Irish Water

Tionscadal Soláthair Uisce
Water Supply Project

UISCE ÉIREANN
COLVILL HOUSE,
TALBOT STREET,
DUBLIN 1,
IRELAND

Call 1890 278 278
Int: 00 353 1 707 2828

JACOBS TOBIN

Originated By JMC	Drawn By AP	Checked By MG	Approved By SW
Date 17.01.18	Date 01.12.2025	Date 01.12.2025	Date 01.12.2025


Scale: 1:500 @ A1

Project Title
**WATER SUPPLY PROJECT
EASTERN AND MIDLANDS REGION**

Drawing Title
**TERMINATION POINT RESERVOIR
PROPOSED DRAINAGE PLAN
SHEET 01**

Drawing Status: FINAL FOR PLANNING
Jacobs Tobin No. 32105801 | Client No. 9318

 Drawing No.
32105801-850-06022





- Notes:
1. ALL DIMENSIONS ARE IN METRES AND ALL LEVELS ARE IN METRES AOD MALIN HEAD UNLESS OTHERWISE STATED.
 2. THIS DRAWING IS NOT TO BE SCALED. FIGURED DIMENSIONS ONLY TO BE TAKEN.
 3. THIS DRAWING IS FOR PLANNING PURPOSES ONLY.

- LEGEND:
- PLANNING APPLICATION BOUNDARY
 - INDICATIVE PERMANENT WAYLEAVE
 - PERMANENT WAYLEAVE FOR EXISTING 1200mm MAIN
- EXISTING:
- BLOCK AND RAIL FENCE
 - 300/350mmØ SCOUR PIPE
 - PIPELINE CENTRELINE
 - 1600mmØ PIPEWORK
- PROPOSED:
- PIPELINE CENTRELINE
 - 1.2m HIGH POST AND RAIL FENCE
 - 2.4m HIGH PALISADE SITE SECURITY FENCE
 - ROAD / HARDSTAND SURFACE
 - BELOW GROUND STRUCTURES
 - OUTLET PIPEWORK
 - OVERFLOW DRAINAGE PIPE
 - 300/350mmØ SCOUR PIPE
 - FOUL SEWER DIVERSION
 - FOUL SEWER ABANDONMENT
 - SURFACE WATER DRAINAGE
 - SURFACE WATER FILTER DRAIN
 - CCTV DROP DOWN POLE

OSI Sheet No's:
3325-A.

F02	FINAL FOR PLANNING	AP	MG	SW	Dec. 2025
F01	FINAL FOR PLANNING	AP	MG	SW	Dec. 2025
Rev	Description	Drawn	Chk'd	App'd.	Date

This drawing is the property of Uisce Éireann and must not be copied or used for any purpose other than that for which it is supplied without the written consent of Uisce Éireann.

UISCE ÉIREANN
COLVILL HOUSE,
TALBOT STREET,
DUBLIN 1,
IRELAND

Call 1890 278 278
Int: 00 353 1 707 2828

JACOBS TOBIN

Originated By JMC	Drawn By AP	Checked By MG	Approved By SW
Date 17.01.18	Date 01.12.2025	Date 01.12.2025	Date 01.12.2025


 
Scale: 1:500 @ A1 FINAL

Project Title
WATER SUPPLY PROJECT
EASTERN AND MIDLANDS REGION

Drawing Title
TERMINATION POINT RESERVOIR
PROPOSED DRAINAGE PLAN
SHEET 02

Drawing Status: FINAL FOR PLANNING
Jacobs Tobin No. 32105801 Client No. 9318

Drawing No.
32105801-850-06023

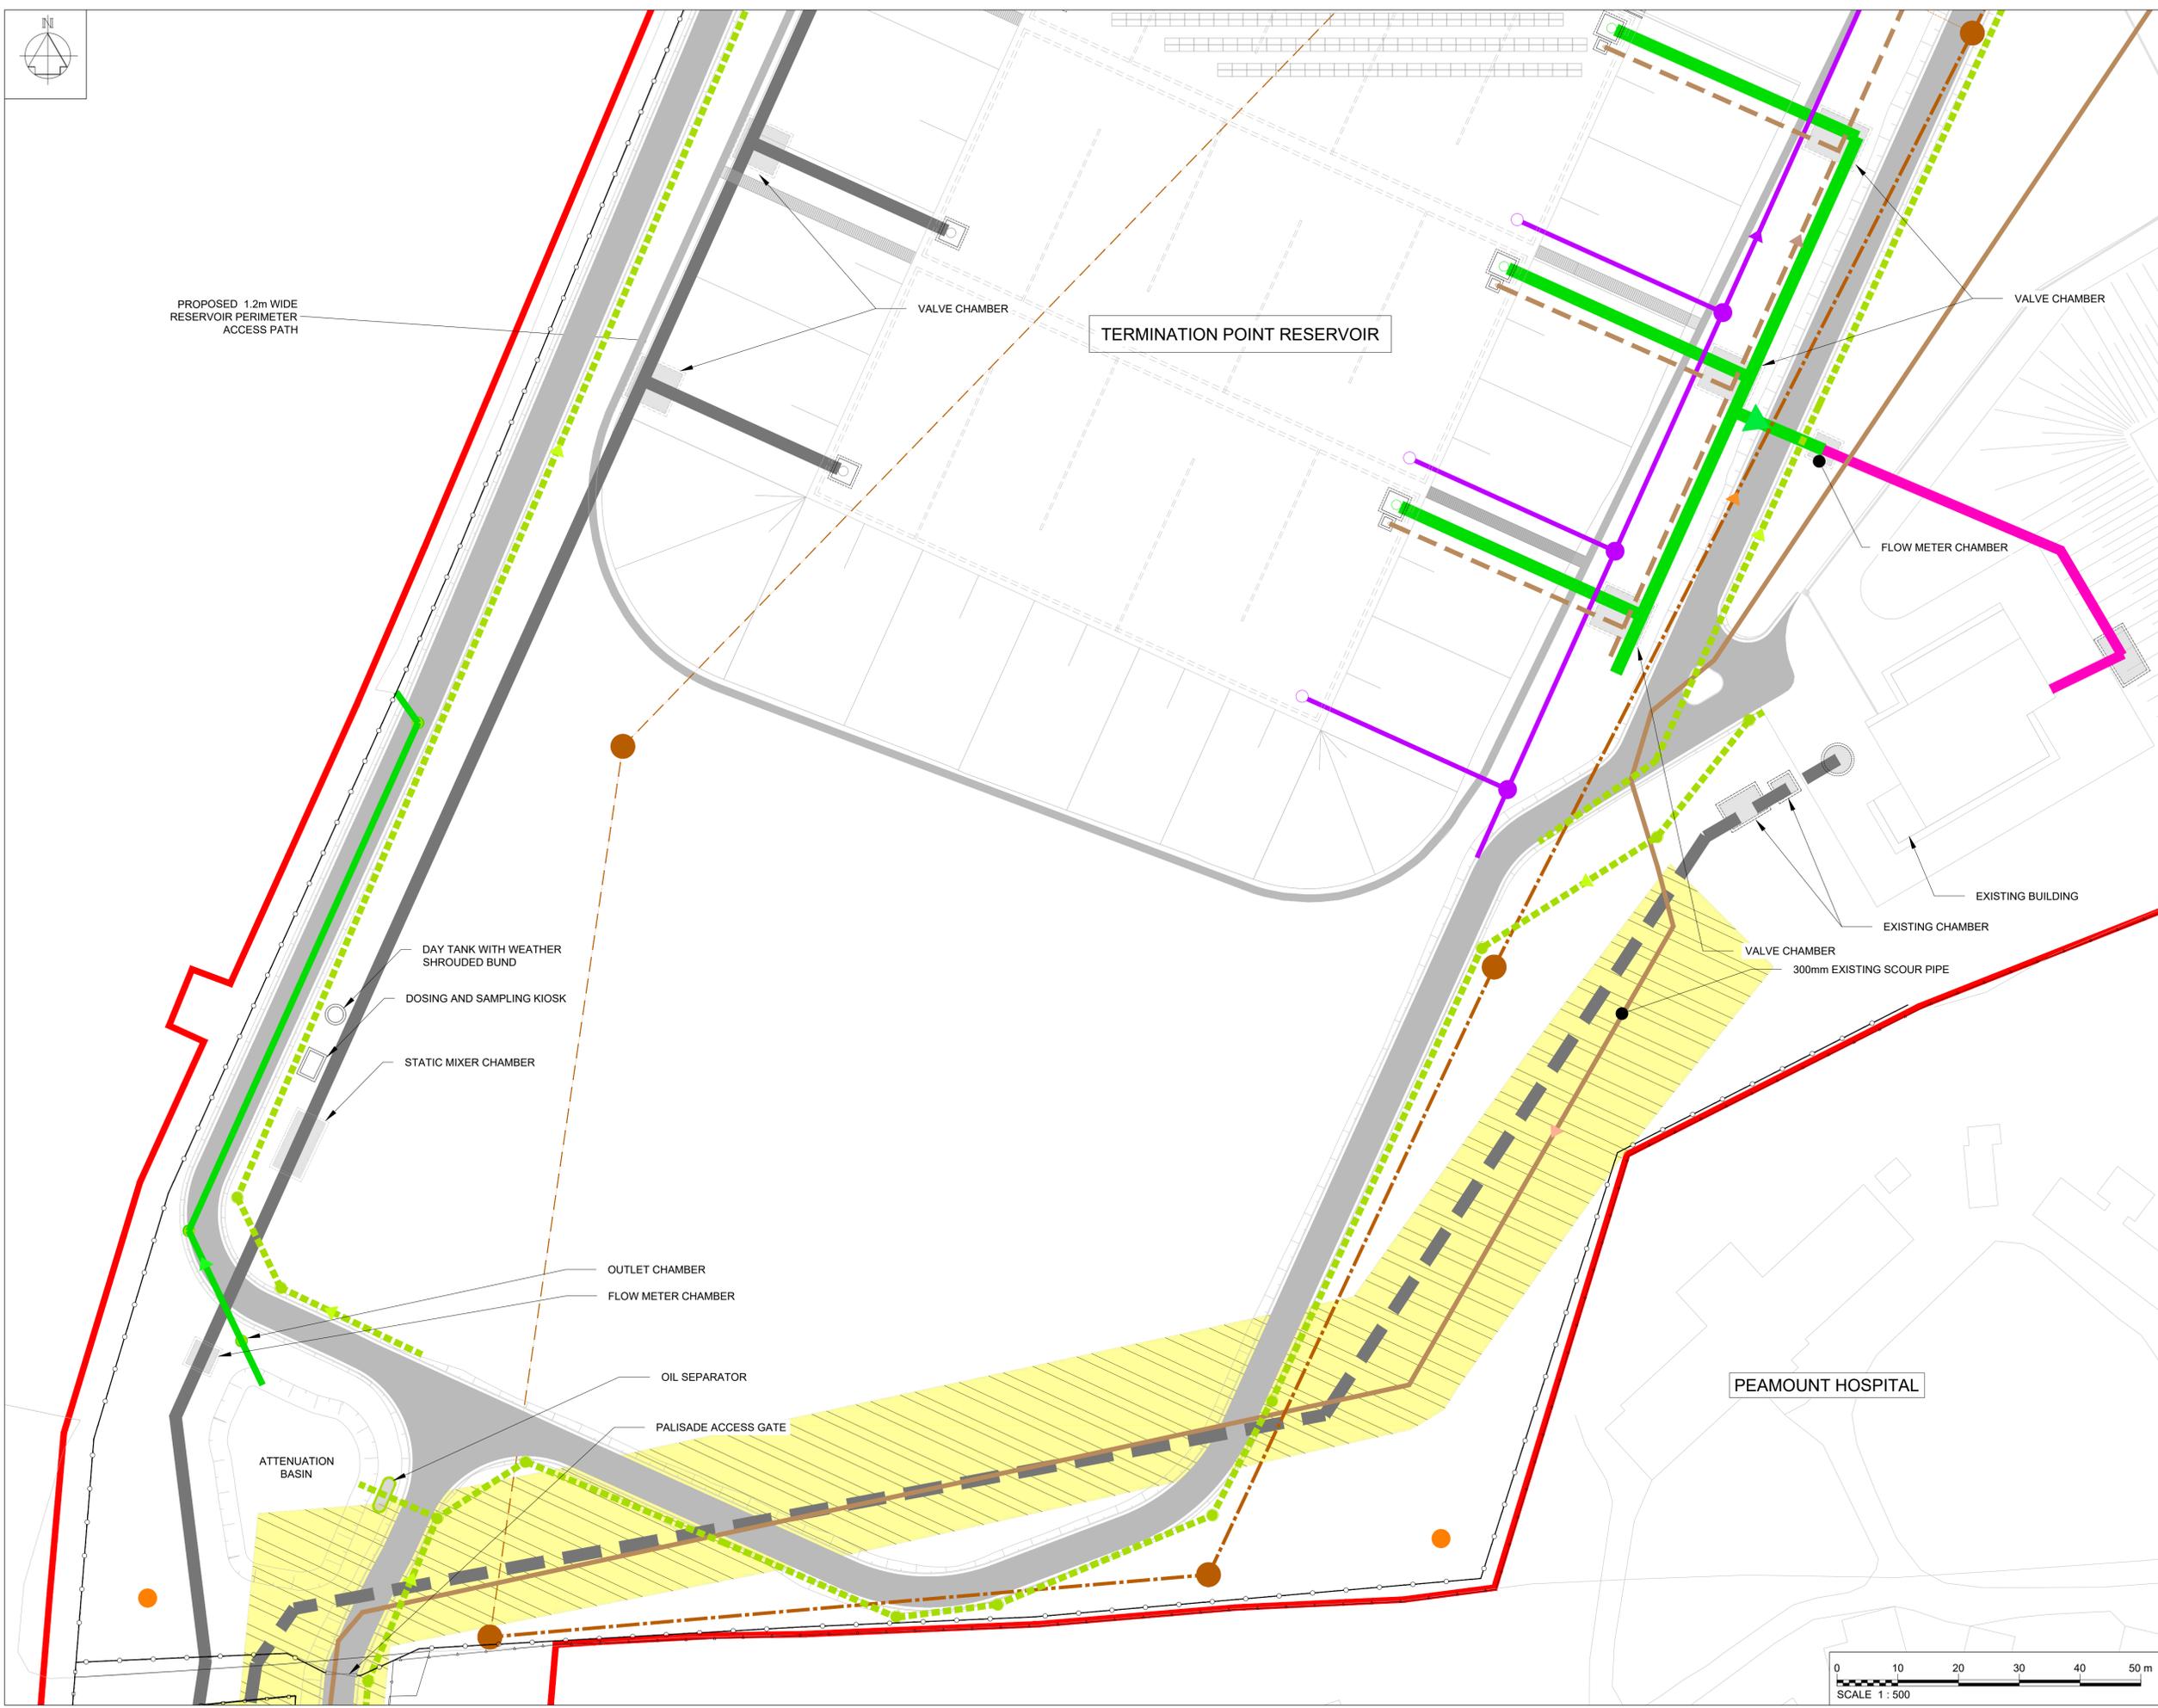

PROPOSED 1.2m WIDE
RESERVOIR PERIMETER
ACCESS PATH

VALVE CHAMBER

TERMINATION POINT RESERVOIR

VALVE CHAMBER

FLOW METER CHAMBER

DAY TANK WITH WEATHER
SHROUDED BUND
DOSING AND SAMPLING KIOSK
STATIC MIXER CHAMBER

EXISTING BUILDING
EXISTING CHAMBER

VALVE CHAMBER
300mm EXISTING SCOUR PIPE

OUTLET CHAMBER
FLOW METER CHAMBER
OIL SEPARATOR
PALISADE ACCESS GATE

PEAMOUNT HOSPITAL

ATTENUATION BASIN



- Notes:
1. ALL DIMENSIONS ARE IN METRES AND ALL LEVELS ARE IN METRES AOD MALIN HEAD UNLESS OTHERWISE STATED.
 2. THIS DRAWING IS NOT TO BE SCALED. FIGURED DIMENSIONS ONLY TO BE TAKEN.
 3. THIS DRAWING IS FOR PLANNING PURPOSES ONLY.

- LEGEND:
- PLANNING APPLICATION BOUNDARY
- EXISTING:
- 300/350mmØ SCOUR PIPE
 - - - 225mm FOUL SEWER (APPROXIMATE LOCATION)
 - 1600mmØ PIPEWORK
- PROPOSED:
- 1.2m HIGH POST AND RAIL FENCE
 - 2.4m HIGH PALISADE SITE SECURITY FENCE
 - ROAD / HARDSTAND SURFACE
 - BELOW GROUND STRUCTURES
 - OUTLET PIPEWORK
 - OVERFLOW DRAINAGE PIPE
 - 300/350mmØ SCOUR PIPE
 - - - FOUL SEWER DIVERSION
 - - - FOUL SEWER ABANDONMENT
 - SURFACE WATER DRAINAGE
 - - - SURFACE WATER FILTER DRAIN
 - CCTV DROP DOWN POLE

OSI Sheet No's:
3325-A.

F02	FINAL FOR PLANNING	AP	MG	SW	Dec. 2025
F01	FINAL FOR PLANNING	AP	MG	SW	Dec. 2025
Rev	Description	Drawn	Chk'd	App'd.	Date

This drawing is the property of Uisce Éireann and must not be copied or used for any purpose other than that for which it is supplied without the written consent of Uisce Éireann.



Uisce Éireann
Irish Water



Tionscail Soláthair Uisce
Water Supply Project

UISCE ÉIREANN
COLVILL HOUSE,
TALBOT STREET,
DUBLIN 1,
IRELAND

Call 1890 278 278
Int: 00 353 1 707 2828

JACOBS TOBIN

Originated By JMC	Drawn By AP	Checked By MG	Approved By SW
Date 17.01.18	Date 01.12.2025	Date 01.12.2025	Date 01.12.2025



Scale: 1:500 @ A1 FINAL


Project Title
WATER SUPPLY PROJECT
EASTERN AND MIDLANDS REGION

Drawing Title
TERMINATION POINT RESERVOIR
PROPOSED DRAINAGE PLAN
SHEET 03

Drawing Status: FINAL FOR PLANNING
Jacobs Tobin No. 32105801 | Client No. 9318

 Drawing No.
32105801-850-06024

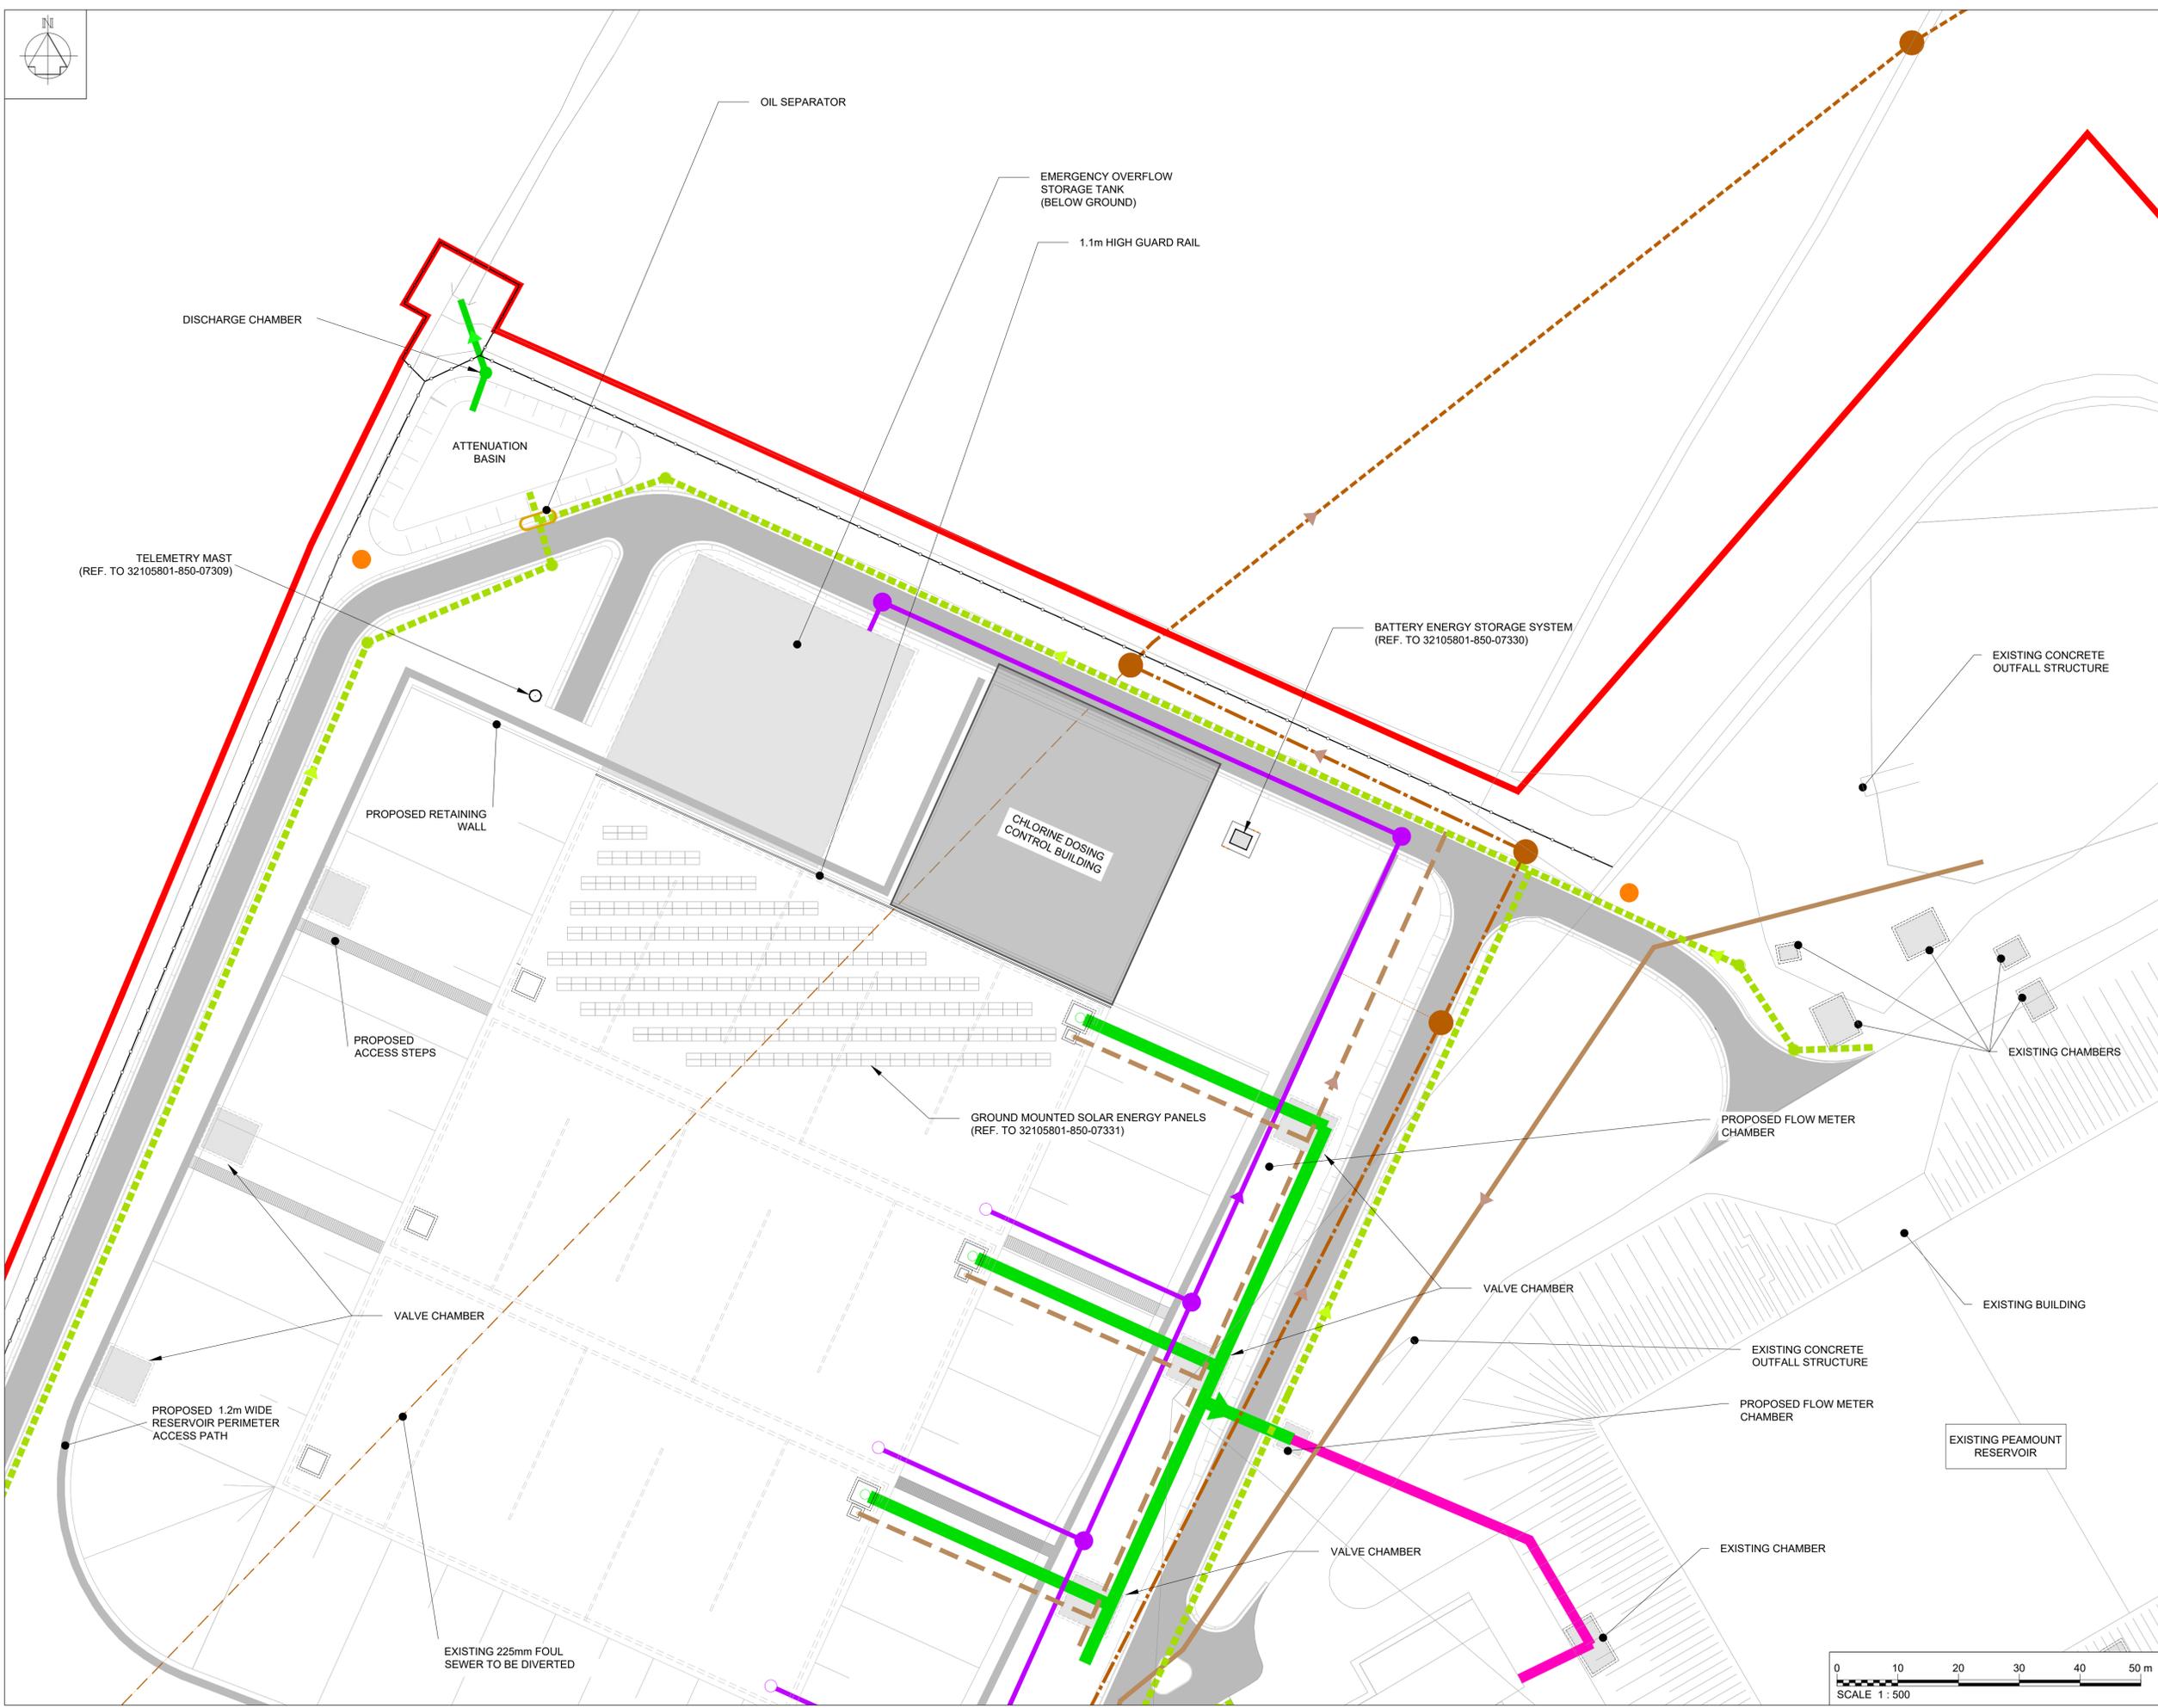

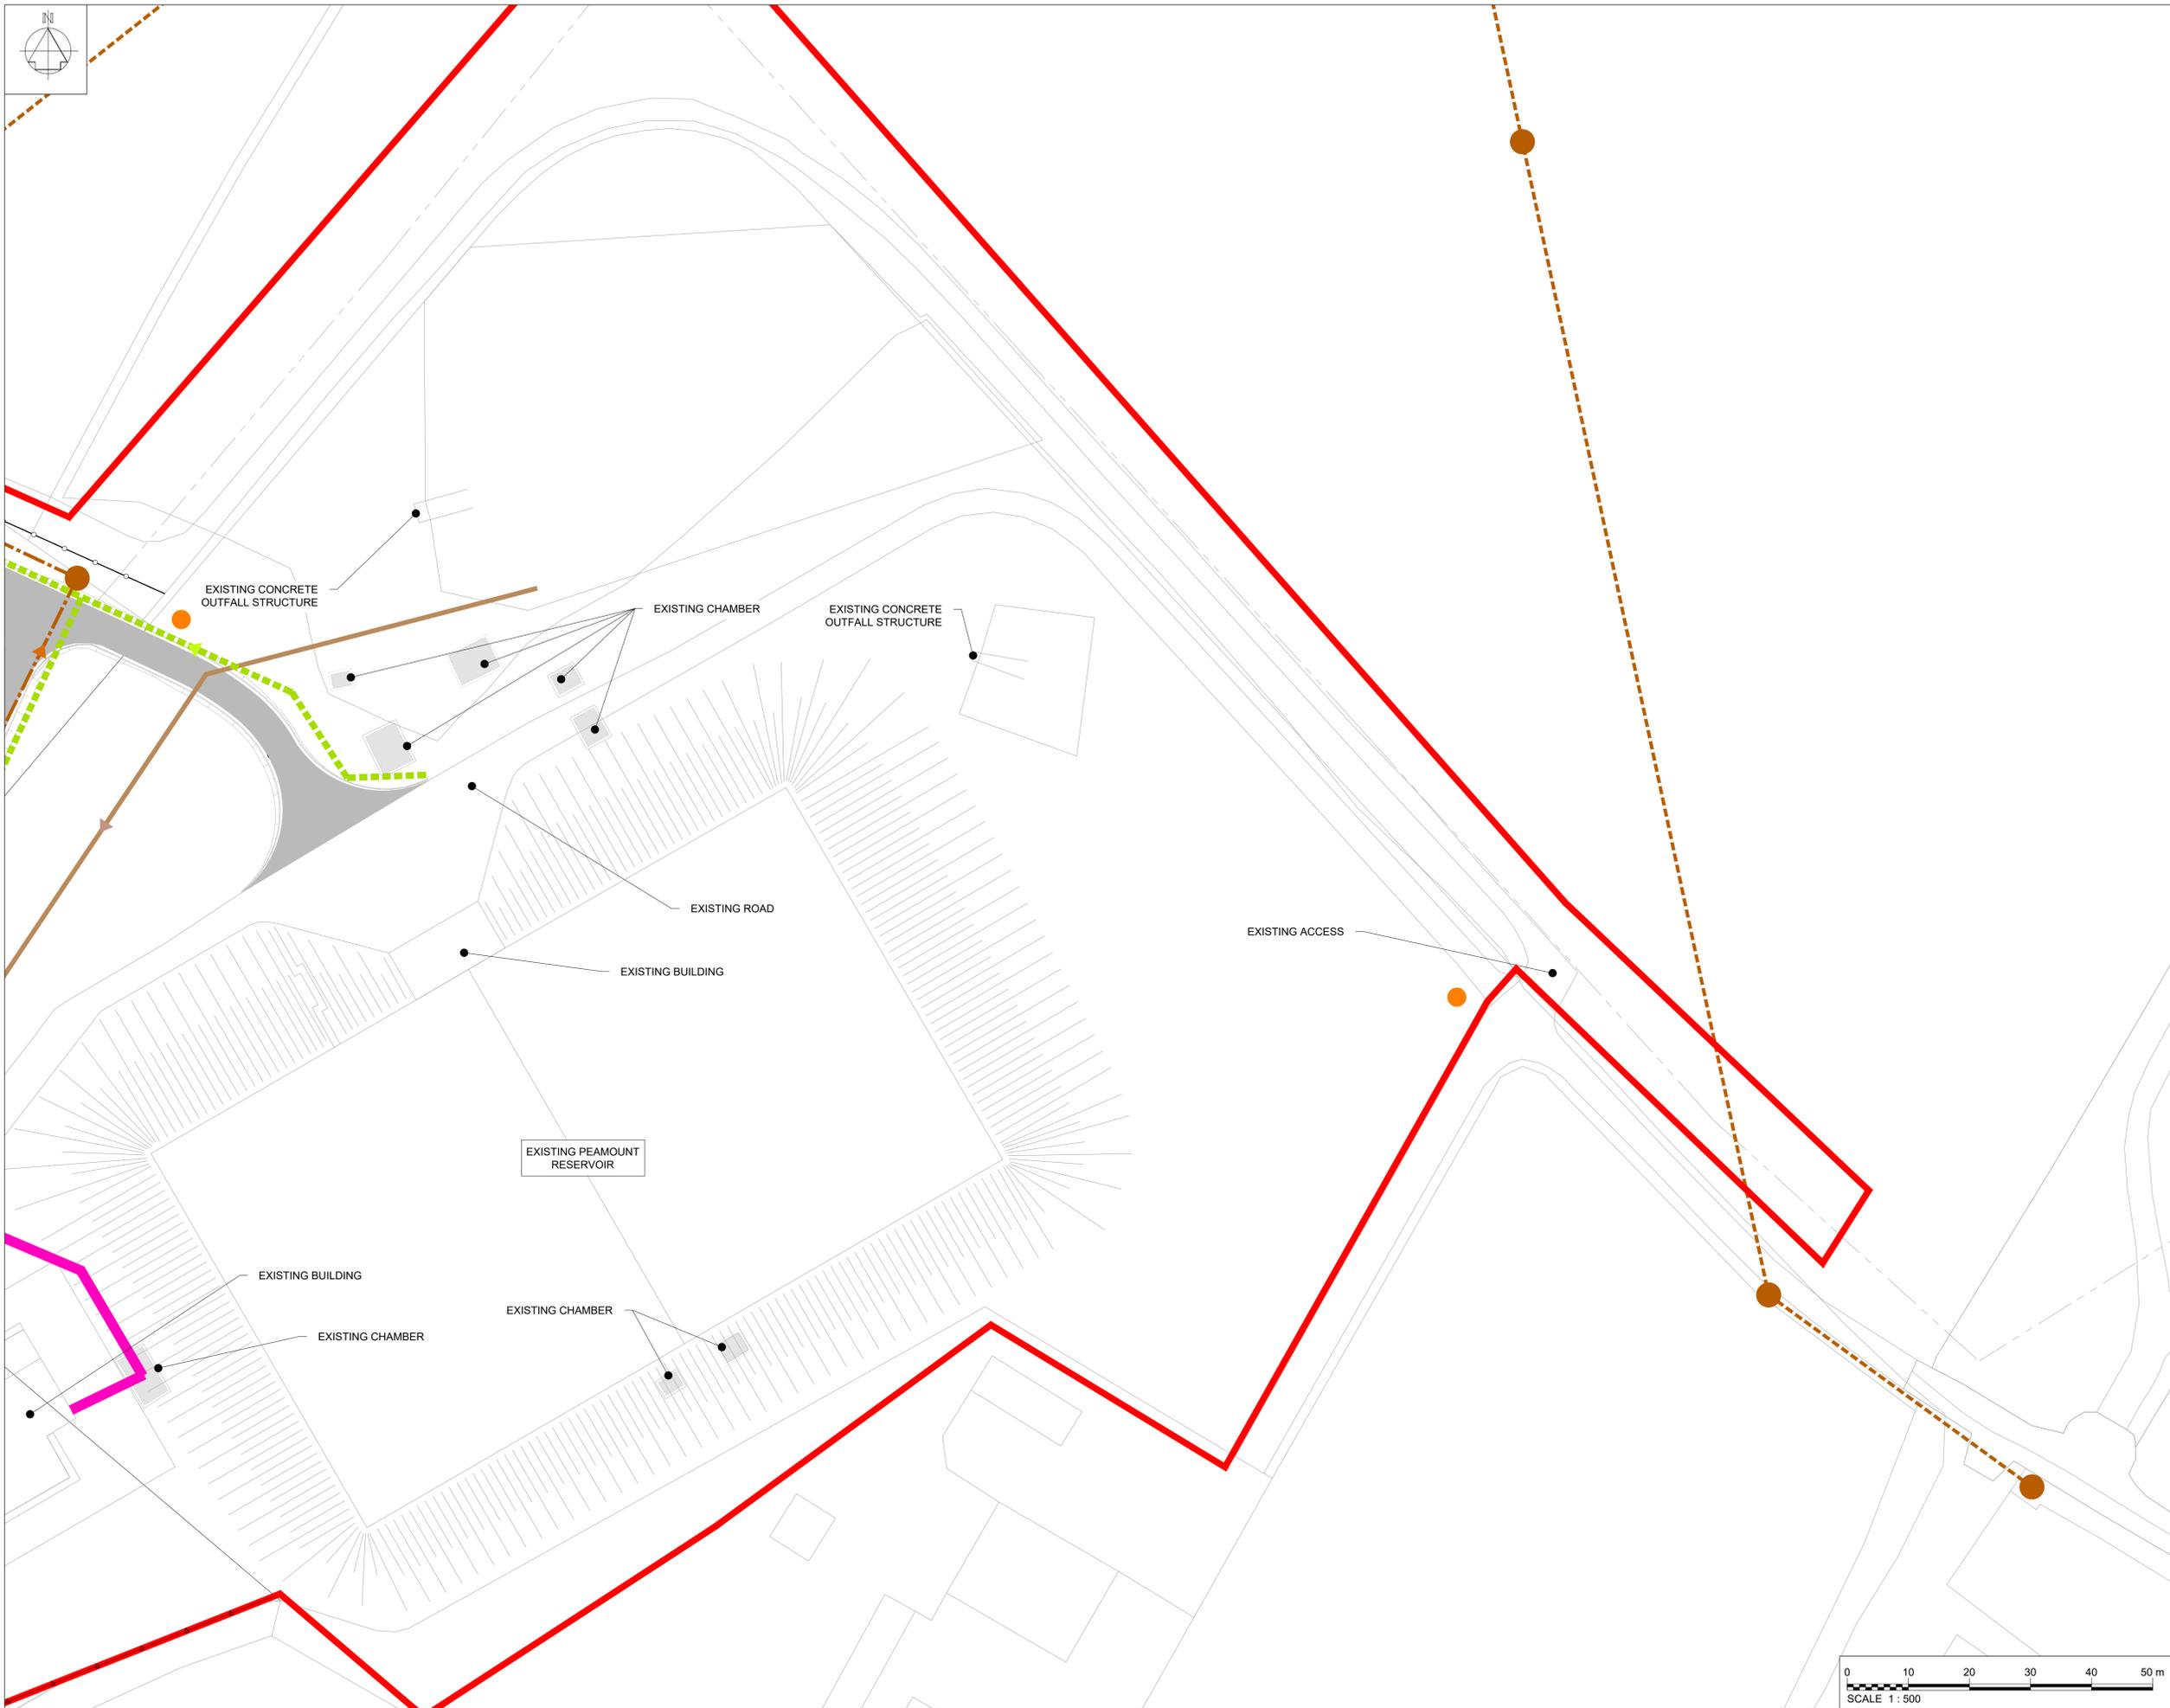

- Notes:
1. ALL DIMENSIONS ARE IN METRES AND ALL LEVELS ARE IN METRES AOD MALIN HEAD UNLESS OTHERWISE STATED.
 2. THIS DRAWING IS NOT TO BE SCALED. FIGURED DIMENSIONS ONLY TO BE TAKEN.
 3. THIS DRAWING IS FOR PLANNING PURPOSES ONLY.

- LEGEND:
- PLANNING APPLICATION BOUNDARY
 - INDICATIVE PERMANENT WAYLEAVE
- EXISTING:
- BLOCK AND RAIL FENCE
 - 300/350mmØ SCOUR PIPE
 - 225mm FOUL SEWER (APPROXIMATE LOCATION)
 - 1600mmØ PIPEWORK
- PROPOSED:
- 1.2m HIGH POST AND RAIL FENCE
 - 2.4m HIGH PALISADE SITE SECURITY FENCE
 - ROAD / HARDSTAND SURFACE
 - BELOW GROUND STRUCTURES
 - FOUL SEWER DIVERSION
 - SURFACE WATER FILTER DRAIN
 - CCTV DROP DOWN POLE

OSI Sheet No's:
 3325-A.

F02	FINAL FOR PLANNING	AP	MG	SW	Dec. 2025
F01	FINAL FOR PLANNING	AP	MG	SW	Dec. 2025
Rev	Description	Drawn	Chk'd	App'd.	Date

This drawing is the property of Uisce Éireann and must not be copied or used for any purpose other than that for which it is supplied without the written consent of Uisce Éireann.

UISCE ÉIREANN
 COLVILL HOUSE,
 TALBOT STREET,
 DUBLIN 1,
 IRELAND

Call 1890 278 278
 Int: 00 353 1 707 2828

JACOBS TOBIN

Originated By JMC	Drawn By AP	Checked By MG	Approved By SW
Date 17.01.18	Date 01.12.2025	Date 01.12.2025	Date 01.12.2025


Scale: 1:500 @ A1 FINAL

Project Title
 WATER SUPPLY PROJECT
 EASTERN AND MIDLANDS REGION

Drawing Title
 TERMINATION POINT RESERVOIR
 PROPOSED DRAINAGE PLAN
 SHEET 04

Drawing Status: FINAL FOR PLANNING
 Jacobs Tobin No. 32105801 | Client No. 9318

 Drawing No.
32105801-850-06025





- Notes:
1. ALL DIMENSIONS ARE IN METRES AND ALL LEVELS ARE IN METRES AOD MALIN HEAD UNLESS OTHERWISE STATED.
 2. THIS DRAWING IS NOT TO BE SCALED. FIGURED DIMENSIONS ONLY TO BE TAKEN.
 3. THIS DRAWING IS FOR PLANNING PURPOSES ONLY.

- LEGEND:
- PLANNING APPLICATION BOUNDARY
 - EXISTING:
 - ELECTRICAL OVERHEAD POWERLINE LOW/MEDIUM VOLTAGE
 - PROPOSED:
 - ELECTRICAL OVERHEAD POWERLINE LOW/MEDIUM VOLTAGE TO BE ABANDONED
 - UNDERGROUND ELECTRICAL DUCT
 - 2.4m HIGH PALISADE SITE SECURITY FENCE
 - ROAD / HARDSTAND SURFACE
 - BELOW GROUND STRUCTURES
 - CCTV DROP DOWN POLE

OSI Sheet No's:
3325-A.

F02	FINAL FOR PLANNING	AP	MG	SW	Dec. 2025
F01	FINAL FOR PLANNING	AP	MG	SW	Dec. 2025
Rev	Description	Drawn	Chk'd	App'd.	Date

This drawing is the property of Uisce Éireann and must not be copied or used for any purpose other than that for which it is supplied without the written consent of Uisce Éireann.



UISCE ÉIREANN
COLVILL HOUSE,
TALBOT STREET,
DUBLIN 1,
IRELAND



Call 1890 278 278
Int: 00 353 1 707 2828

JACOBS TOBIN

Originated By JMC	Drawn By AP	Checked By MG	Approved By SW
Date 17.01.18	Date 01.12.2025	Date 01.12.2025	Date 01.12.2025


Scale: 1:500 @ A1 FINAL

Project Title
WATER SUPPLY PROJECT
EASTERN AND MIDLANDS REGION

Drawing Title
TERMINATION POINT RESERVOIR
PROPOSED ELECTRICAL SERVICE PLAN
SHEET 01

Drawing Status: FINAL FOR PLANNING
Jacobs Tobin No. 32105801 | Client No. 9318

Drawing No.
32105801-850-06026

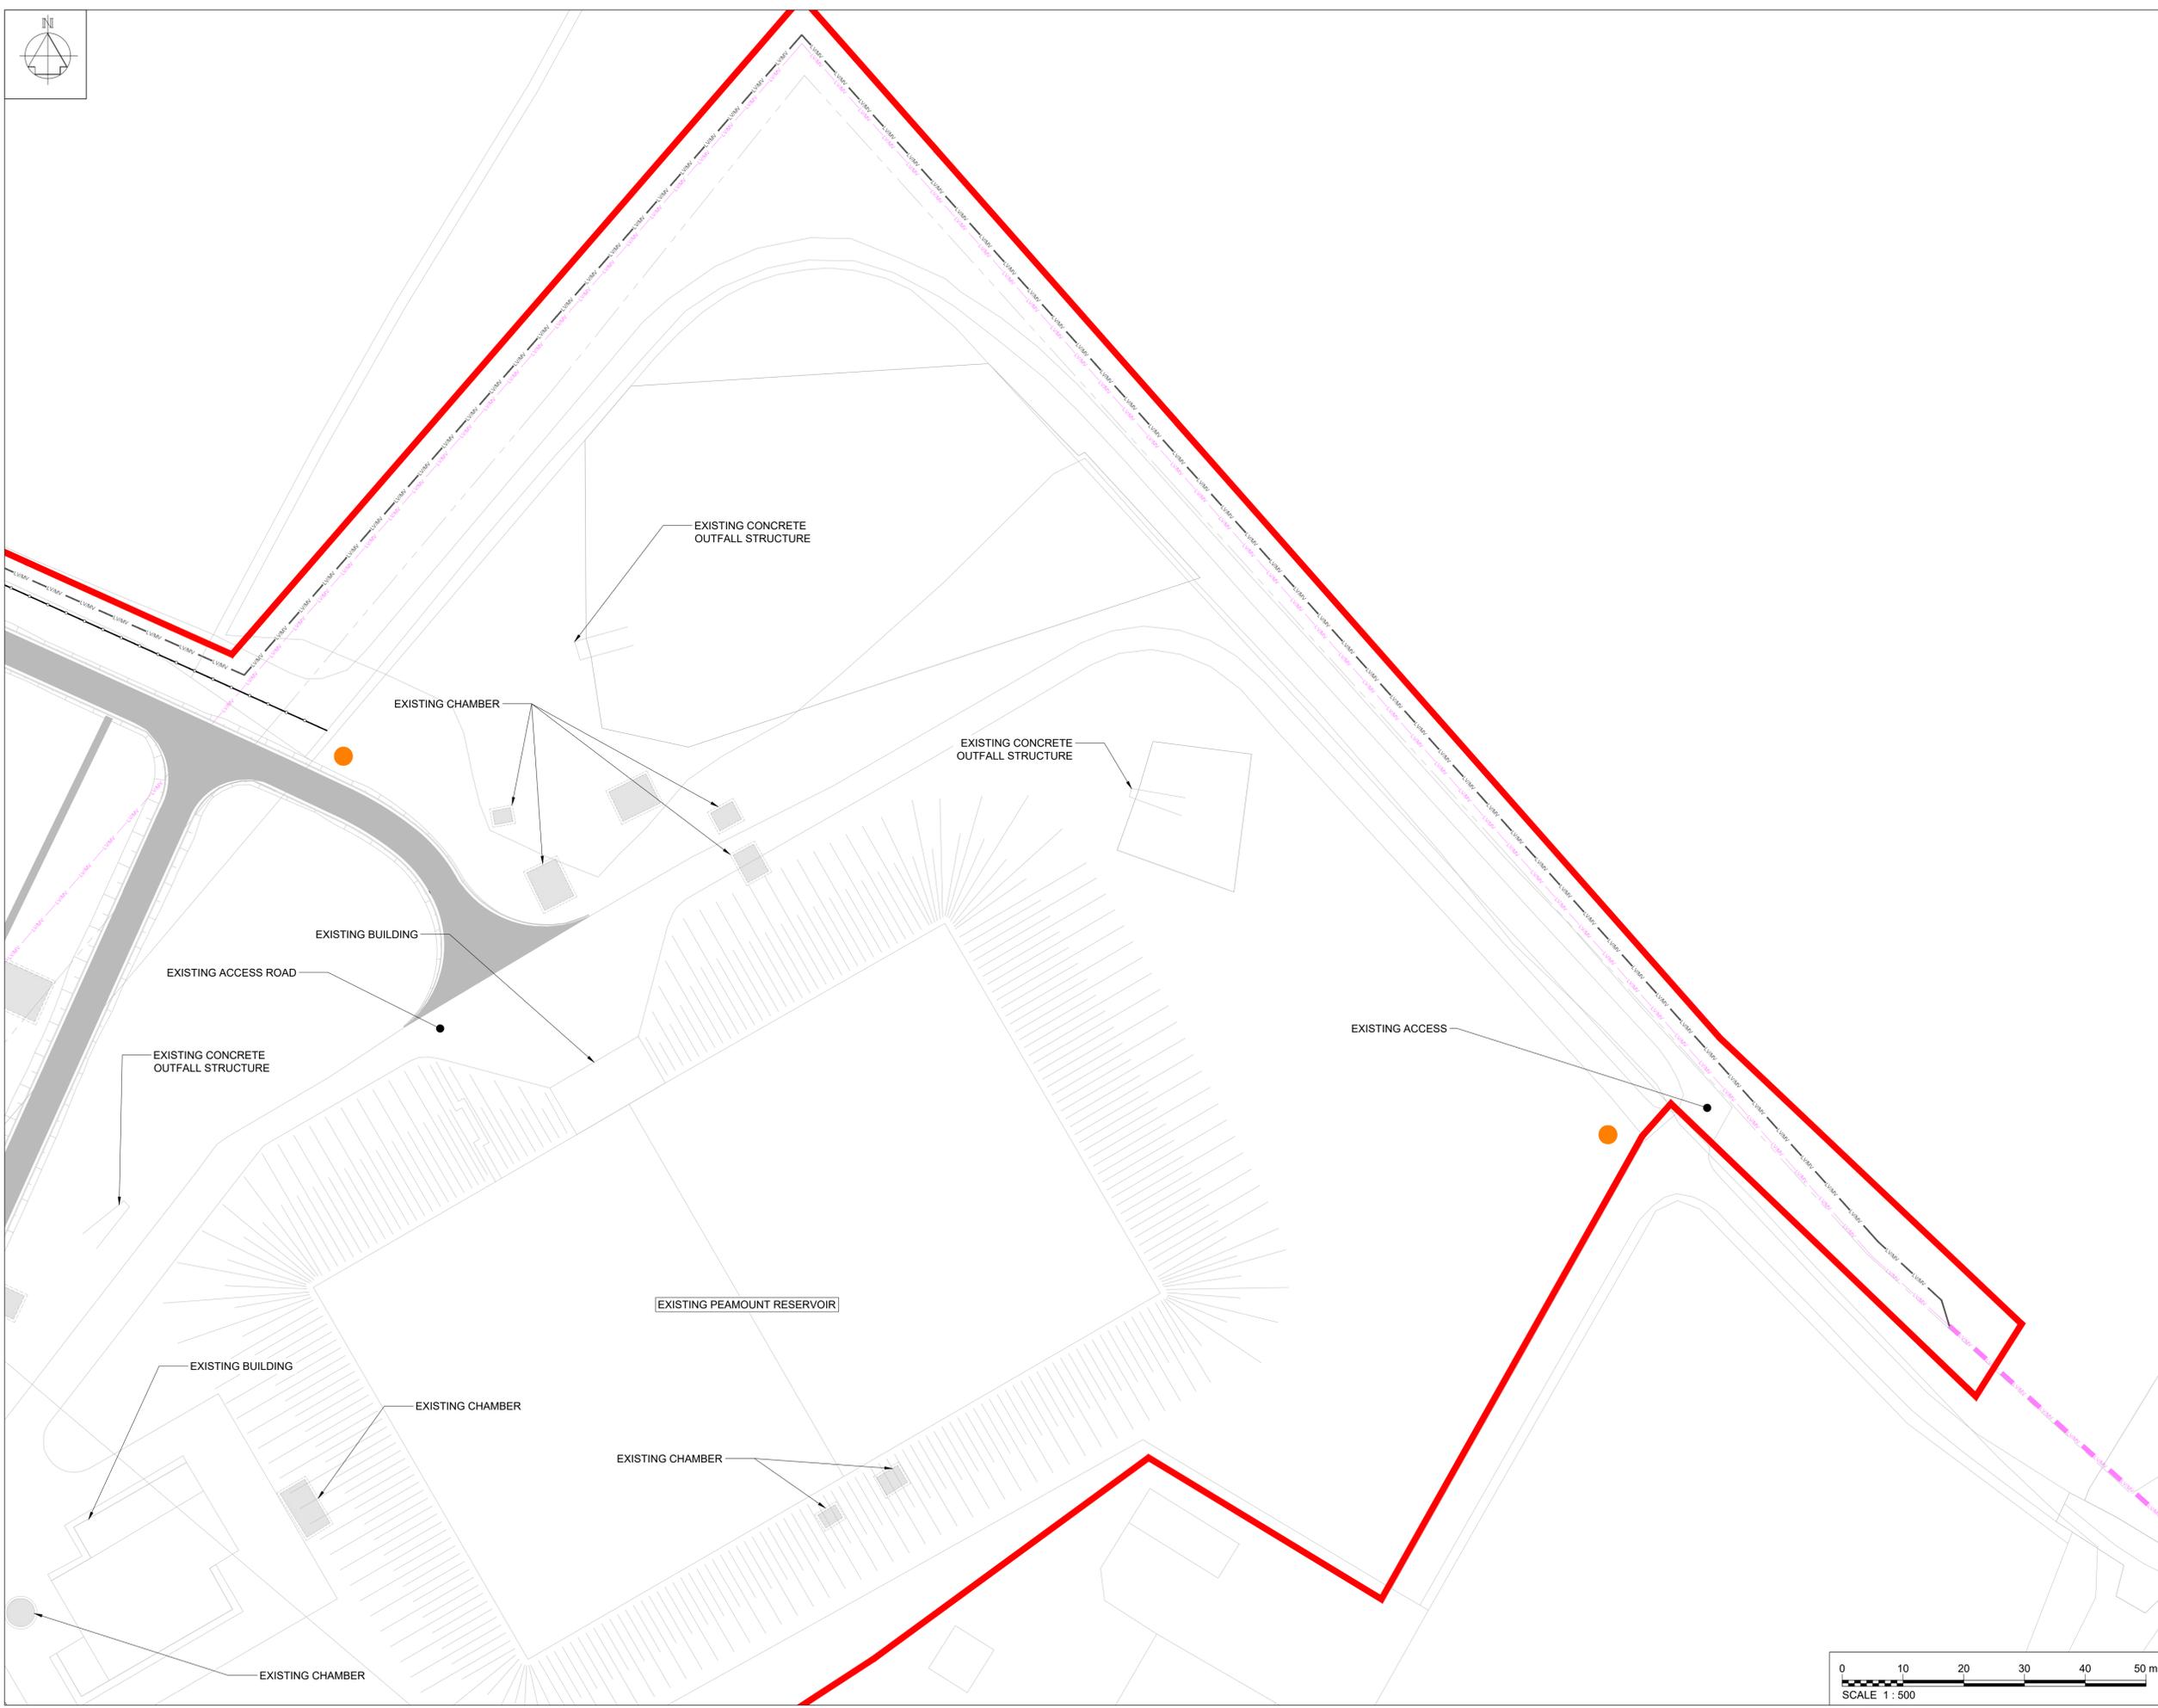



- Notes:
1. ALL DIMENSIONS ARE IN METRES AND ALL LEVELS ARE IN METRES AOD MALIN HEAD UNLESS OTHERWISE STATED.
 2. THIS DRAWING IS NOT TO BE SCALED. FIGURED DIMENSIONS ONLY TO BE TAKEN.
 3. THIS DRAWING IS FOR PLANNING PURPOSES ONLY.

- LEGEND:
- PLANNING APPLICATION BOUNDARY
 - PERMANENT WAYLEAVE FOR EXISTING 1200mm MAIN
- EXISTING:
- BLOCK AND RAIL FENCE
- PROPOSED:
- LV/MV ELECTRICAL OVERHEAD POWERLINE LOW/MEDIUM VOLTAGE TO BE ABANDONED
 - LV/MV UNDERGROUND ELECTRICAL DUCT
 - 2.4m HIGH PALISADE SITE SECURITY FENCE
 - ROAD / HARDSTAND SURFACE
 - BELOW GROUND STRUCTURES
 - CCTV DROP DOWN POLE

OSI Sheet No's:
3325-A.

F02	FINAL FOR PLANNING	AP	MG	SW	Dec. 2025
F01	FINAL FOR PLANNING	AP	MG	SW	Dec. 2025
Rev	Description	Drawn	Chk'd	App'd.	Date

This drawing is the property of Uisce Éireann and must not be copied or used for any purpose other than that for which it is supplied without the written consent of Uisce Éireann.



Uisce Éireann
Irish Water



Tionscadal Soláthair Uisce
Water Supply Project

UISCE ÉIREANN
COLVILL HOUSE,
TALBOT STREET,
DUBLIN 1,
IRELAND

Call 1890 278 278
Int: 00 353 1 707 2828

JACOBS TOBIN

Originated By JMC	Drawn By AP	Checked By MG	Approved By SW
Date 17.01.18	Date 01.12.2025	Date 01.12.2025	Date 01.12.2025


Scale: 1:500 @ A1 FINAL

Project Title
WATER SUPPLY PROJECT
EASTERN AND MIDLANDS REGION

Drawing Title
TERMINATION POINT RESERVOIR
PROPOSED ELECTRICAL SERVICE PLAN
SHEET 02

Drawing Status: FINAL FOR PLANNING
Jacobs Tobin No. 32105801 | Client No. 9318

 Drawing No.
32105801-850-06027





- Notes:
1. ALL DIMENSIONS ARE IN METRES AND ALL LEVELS ARE IN METRES AOD MALIN HEAD UNLESS OTHERWISE STATED.
 2. THIS DRAWING IS NOT TO BE SCALED. FIGURED DIMENSIONS ONLY TO BE TAKEN.
 3. THIS DRAWING IS FOR PLANNING PURPOSES ONLY.

- LEGEND:
- PLANNING APPLICATION BOUNDARY
 - INDICATIVE PERMANENT WAYLEAVE
 - PERMANENT WAYLEAVE FOR EXISTING 1200mm MAIN
- EXISTING:
- ELECTRICAL OVERHEAD POWERLINE LOW/MEDIUM VOLTAGE
 - BLOCK AND RAIL FENCE
- PROPOSED:
- ELECTRICAL OVERHEAD POWERLINE LOW/MEDIUM VOLTAGE TO BE ABANDONED
 - UNDERGROUND ELECTRICAL DUCT
 - 1.2m HIGH POST AND RAIL FENCE
 - 2.4m HIGH PALISADE SITE SECURITY FENCE
 - ROAD / HARDSTAND SURFACE
 - BELOW GROUND STRUCTURES
 - CCTV DROP DOWN POLE

OSI Sheet No's:
3325-A.

F02	FINAL FOR PLANNING	AP	MG	SW	Dec. 2025
F01	FINAL FOR PLANNING	AP	MG	SW	Dec. 2025
Rev	Description	Drawn	Chkd	App'd	Date

This drawing is the property of Uisce Éireann and must not be copied or used for any purpose other than that for which it is supplied without the written consent of Uisce Éireann.



Uisce Éireann
Irish Water

UISCE ÉIREANN
COLVILL HOUSE,
TALBOT STREET,
DUBLIN 1,
IRELAND

Call 1890 278 278
Int: 00 353 1 707 2828

Jacobs TOBIN

Originated By JMC	Drawn By AP	Checked By MG	Approved By SW
Date 17.01.18	Date 17.01.18	Date 01.12.2025	Date 01.12.2025

Scale: 1:500 @ A1 FINAL

Project Title
WATER SUPPLY PROJECT
EASTERN AND MIDLANDS REGION

Drawing Title
TERMINATION POINT RESERVOIR
PROPOSED ELECTRICAL SERVICE PLAN
SHEET 03

Drawing Status: FINAL FOR PLANNING
Jacobs Tobin No. 32105801 | Client No. 9318

Drawing No.
32105801-850-06028

