




ELEVATION 1 – Facing North West  
(Scale 1:100)

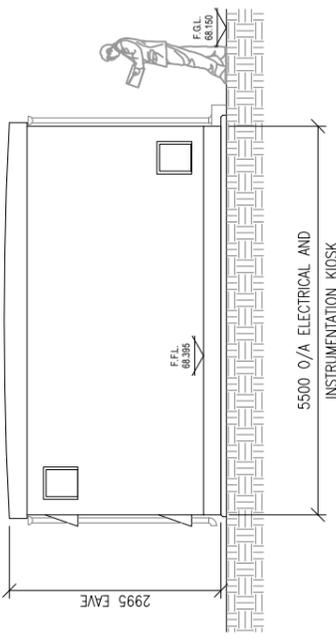


ELEVATION 2 – Facing North East  
(Scale 1:100)

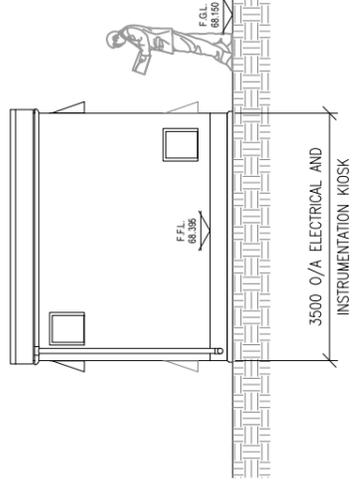

ELEVATION 3 – Facing South East  
(Scale 1:100)

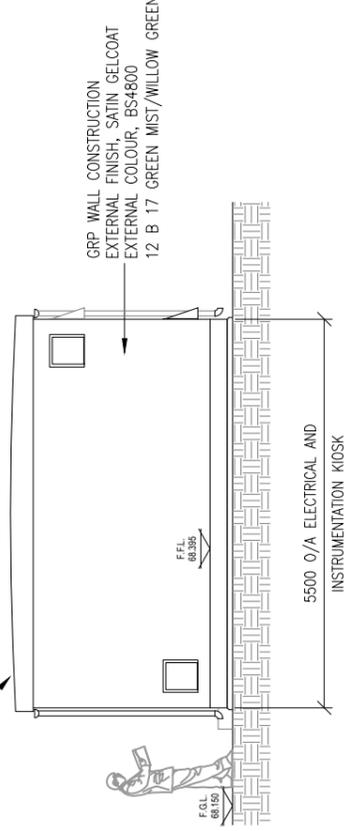

ELEVATION 4 – Facing South West  
(Scale 1:100)

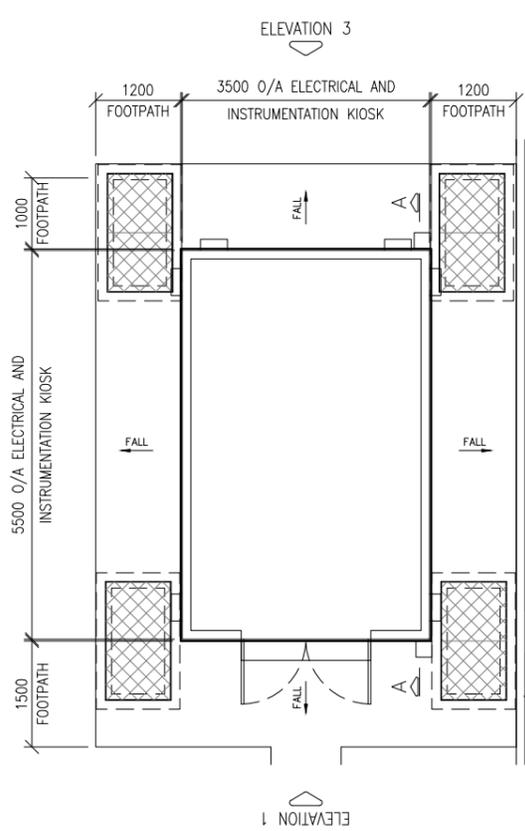

- NOTES:**
1. THIS DRAWING IS FOR PLANNING APPLICATION PURPOSES ONLY.
  2. ALL DIMENSIONS ARE IN MILLIMETRES, UNLESS OTHERWISE STATED.
  3. ALL ELEVATIONS ARE IN METRES, AND REFER TO MALIN HEAD DATUM.
  4. INTERNAL PLANT LAYOUT SUBJECT TO DETAILED DESIGN SPECIFICATION.

**PLANNING ISSUE**

REV.	DATE	REVISION	BY	CHKD.	APPR.
2	7/10/25	REVISED AS PER CLIENT COMMENTS	DC	TM	JL
1	8/9/25	REVISED AS PER CLIENT COMMENTS	TM	MAH	JL
0	20/8/25	PLANNING ISSUE	DC	TM	JL

Client  
**Gas Networks Ireland**  
 P.O. Box 51,  
 Gasworks Road,  
 Cork,  
 Rep of Ireland  
 T +353 21 4534000

**Fingleton White**  
 Bridge Street Centre  
 Perlisise  
 Co. Louth  
 R32 W0CC  
 Ireland  
 T:(00353)057 866 5400  
 www.fingleton.ie

Project  
**Gas to BGE Cashla**  
 FLOOR PLAN, SECTION & ELEVATIONS OF  
 ELECTRICAL AND INSTRUMENTATION KIOSK

Drawn	Scale	Drawing Number	Rev.
D.MALEY	1:100/A3		
Chk. T.MALONE	Date 30/07/2025	<b>2183-DG-1005</b>	<b>2</b>
Appr. J.LENNON	Status PLANNING	sheet 1 of 1	