




0 10 100  
Millimetres

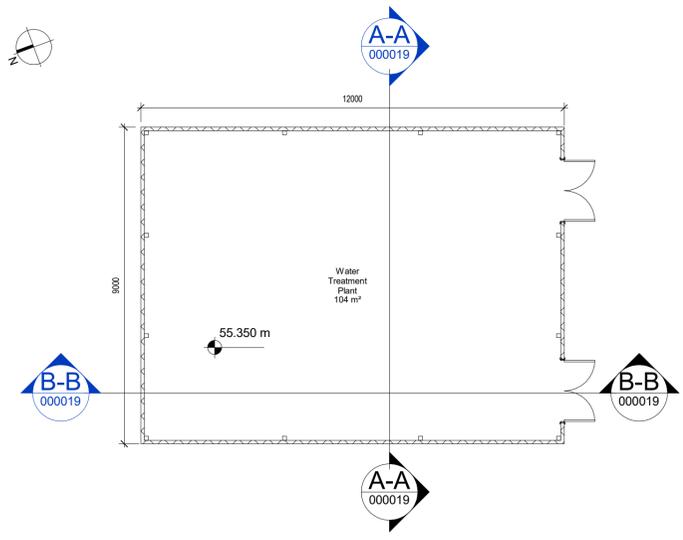


1 00 - Level - Water Treatment Plant  
SCALE 1 : 100

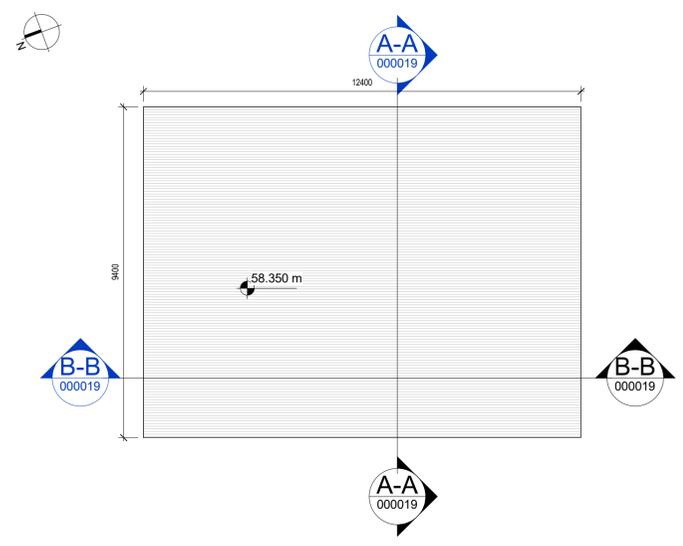


2 01 - Level - 01 - Roof Level Water Treatment Plant  
SCALE 1 : 100

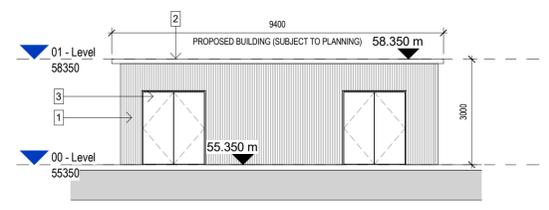


3 South Elevation  
SCALE 1 : 100

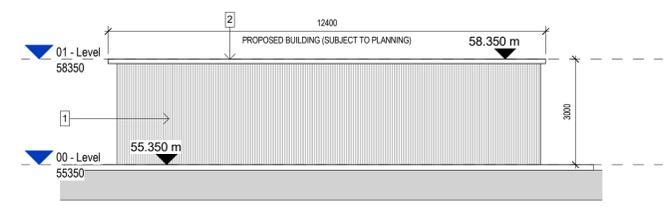


4 East Elevation  
SCALE 1 : 100

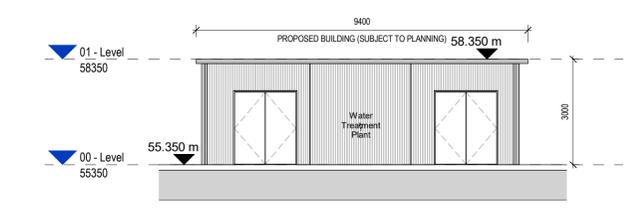


A-A Section A-A  
SCALE 1 : 100

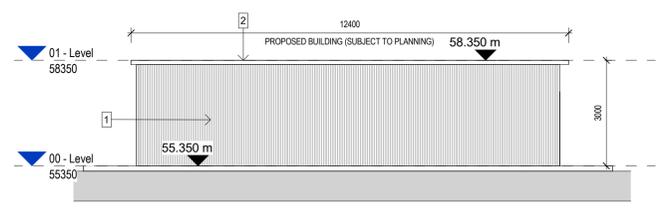

5 West Elevation  
SCALE 1 : 100

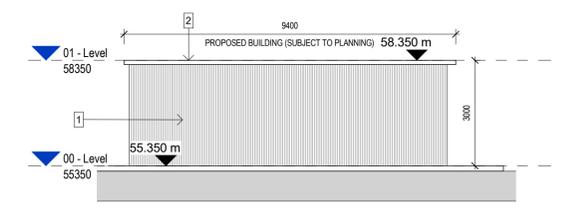


6 North Elevation  
SCALE 1 : 100

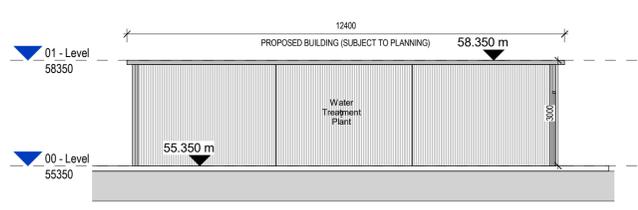

B-B Section B-B  
SCALE 1 : 100

- GENERAL NOTES**
- ALL DIMENSIONS ARE IN MILLIMETRES UNLESS NOTED OTHERWISE
  - ONLY WRITTEN DIMENSIONS SHALL BE USED. NO DIMENSIONS SHALL BE SCALED FROM THE DRAWINGS
  - ALL LEVELS ARE IN METRES AND ARE TO MALIN HEAD DATUM
  - ALL COORDINATES ARE IN METRES AND ARE TO IRISH TRANSVERSE MERCATOR
  - DRAWINGS ARE TO BE READ IN CONJUNCTION WITH THE SPECIFICATION

- FINISHES LEGEND:**
- Kingspan Panel KS1000 MR to selected Neutral RAL colour
  - Kingspan Panel Lo Pitch Roof Panel to selected Neutral RAL colour
  - Steel door to selected RAL colour

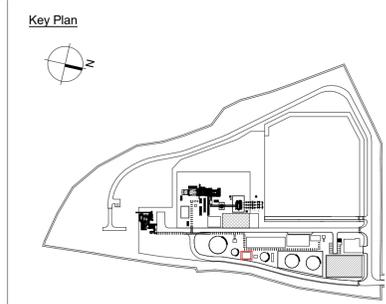

Rev.	Date	Description	By	Rev'd	Chkd	App'd
P00	14/01/2026	Planning Issue	AH	JM	AJ	

Drawing Suitability	FOR PLANNING	Status	P	Project Title	Cashla Peaker Plant, Rathmorrissy and Pollnagroagh (Townlands), Athenry, Co. Galway				
<p>DUBLIN   CORK   GALWAY   DUNDALK</p> <p>ATKINS HOUSE, 150 AIRSIDE BUSINESS PARK, SWORDS, DUBLIN, K67 K5W4. Tel : +353 1 810 8000 Email : info.ie@atkinsrealis.com</p>				Drawing Title	Water Treatment Plant				
				Client	BORD GÁIS ENERGY				
Scale	As indicated	Drawn	AH	Checked	JM	Reviewed	AJB	Authorised	AJB
Original Size	A1	Date	25-06-2025	Date	25-06-2025	Date	26-06-2025	Date	26-06-2025
Drawing Number	PEK3-ATK-ZZ-ZZ-DR-A-ATK-000019							Revision	P00