




100
0 10
Millimetres

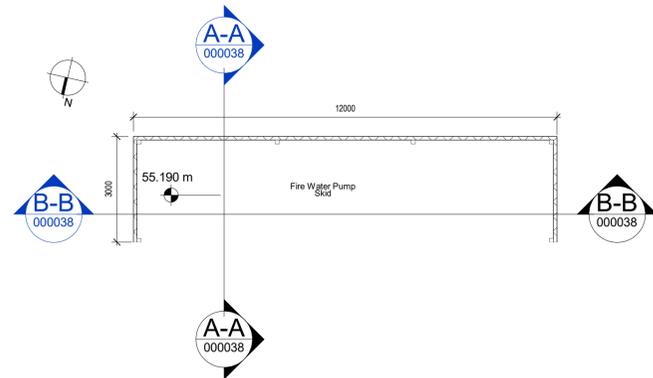


1 00 - Level - Fire Water Pump Skid
SCALE 1 : 100

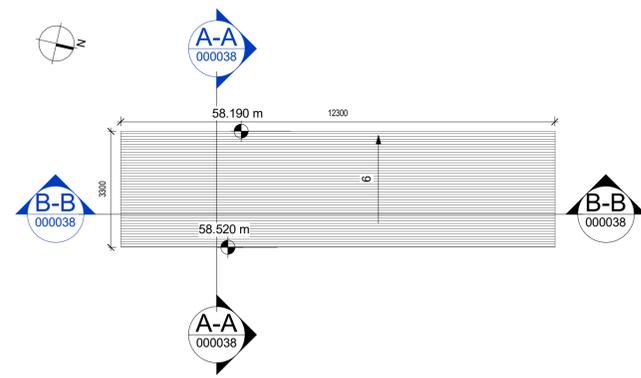


2 02 - Level - 02 - Level
SCALE 1 : 100

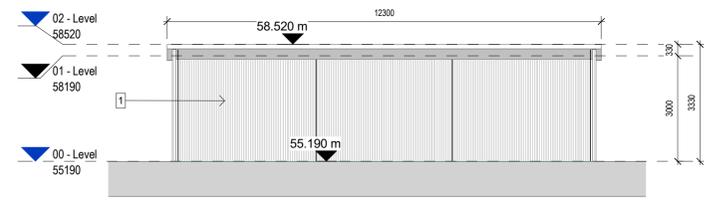


3 North Elevation
SCALE 1 : 100

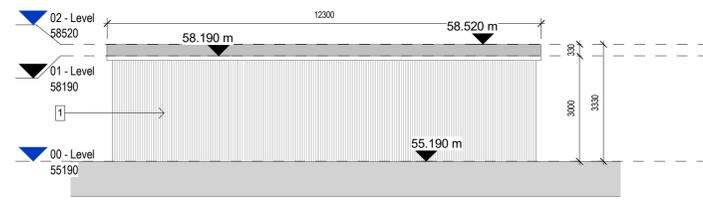


4 South Elevation
SCALE 1 : 100

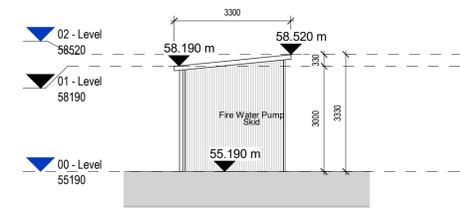


A-A Section A-A
SCALE 1 : 100

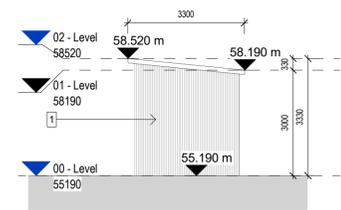

5 East Elevation
SCALE 1 : 100

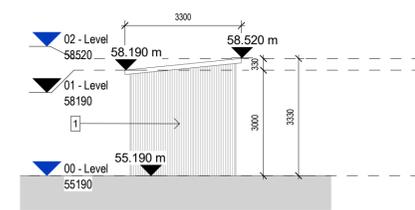

6 West Elevation
SCALE 1 : 100

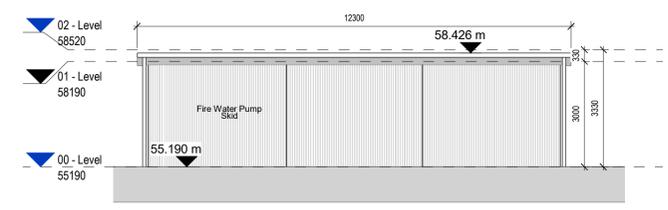

B-B Section B-B
SCALE 1 : 100


GENERAL NOTES

- ALL DIMENSIONS ARE IN MILLIMETRES UNLESS NOTED OTHERWISE
- ONLY WRITTEN DIMENSIONS SHALL BE USED. NO DIMENSIONS SHALL BE SCALED FROM THE DRAWINGS
- ALL LEVELS ARE IN METRES AND ARE TO MALIN HEAD DATUM
- ALL COORDINATES ARE IN METRES AND ARE TO IRISH TRANSVERSE MERCATOR
- DRAWINGS ARE TO BE READ IN CONJUNCTION WITH THE SPECIFICATION

FINISHES LEGEND:

- 1 Steel Panel to selected Neutral RAL colour

Key Plan

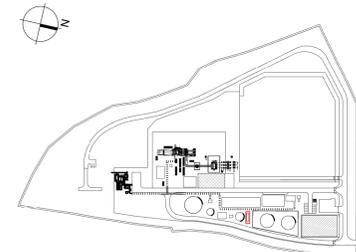

Drawing Suitability	FOR PLANNING	Status	P	Project Title	Cashla Peaker Plant, Rathmorrissey and Pollnagroagh (Townlands), Athenry, Co. Galway								
<p>DUBLIN CORK GALWAY DUNDALK</p> <p>ATKINS HOUSE, 150 AIRSIDE BUSINESS PARK, SWORDS, DUBLIN, K67 K5W4. Tel : +353 1 810 8000 Email : info.ie@atkinsrealis.com</p>				Drawing Title					Fire Water Pump Skid - Plan, Elevations & Sections				
				Scale	As indicated	Drawn	AH	Checked	JM	Reviewed	AJB	Authorised	AJB
Original Size	A1	Date	25-06-2025	Date	25-06-2025	Date	26-06-2025	Date	26-06-2025				
Drawing Number	PEK3-ATK-ZZ-ZZ-DR-A-ATK-000038								Revision		P00		
Client	BORD GÁIS ENERGY												
Rev.	Date	Description	By	Rev'd	Chk'd	App'd							
P00	14/01/2026	Planning Issue	AH	JM	AJ								