


A1

DO NOT SCALE

- GENERAL NOTES**
1. ALL DIMENSIONS ARE IN METERS UNLESS NOTED OTHERWISE
  2. ONLY WRITTEN DIMENSIONS SHALL BE USED. NO DIMENSIONS SHALL BE SCALED FROM THE DRAWINGS
  3. ALL LEVELS ARE IN METERS AND ARE TO MALIN HEAD DATUM
  4. ALL COORDINATES ARE IN METERS AND ARE TO IRISH TRANSVERSE MERCATOR
  5. DRAWINGS ARE TO BE READ IN CONJUNCTION WITH THE SPECIFICATION
  6. THIS DRAWING IS TO BE USED ONLY FOR THE PURPOSES OF THE PLANNING APPLICATION AND IS SUBJECT TO DETAILED DESIGN.

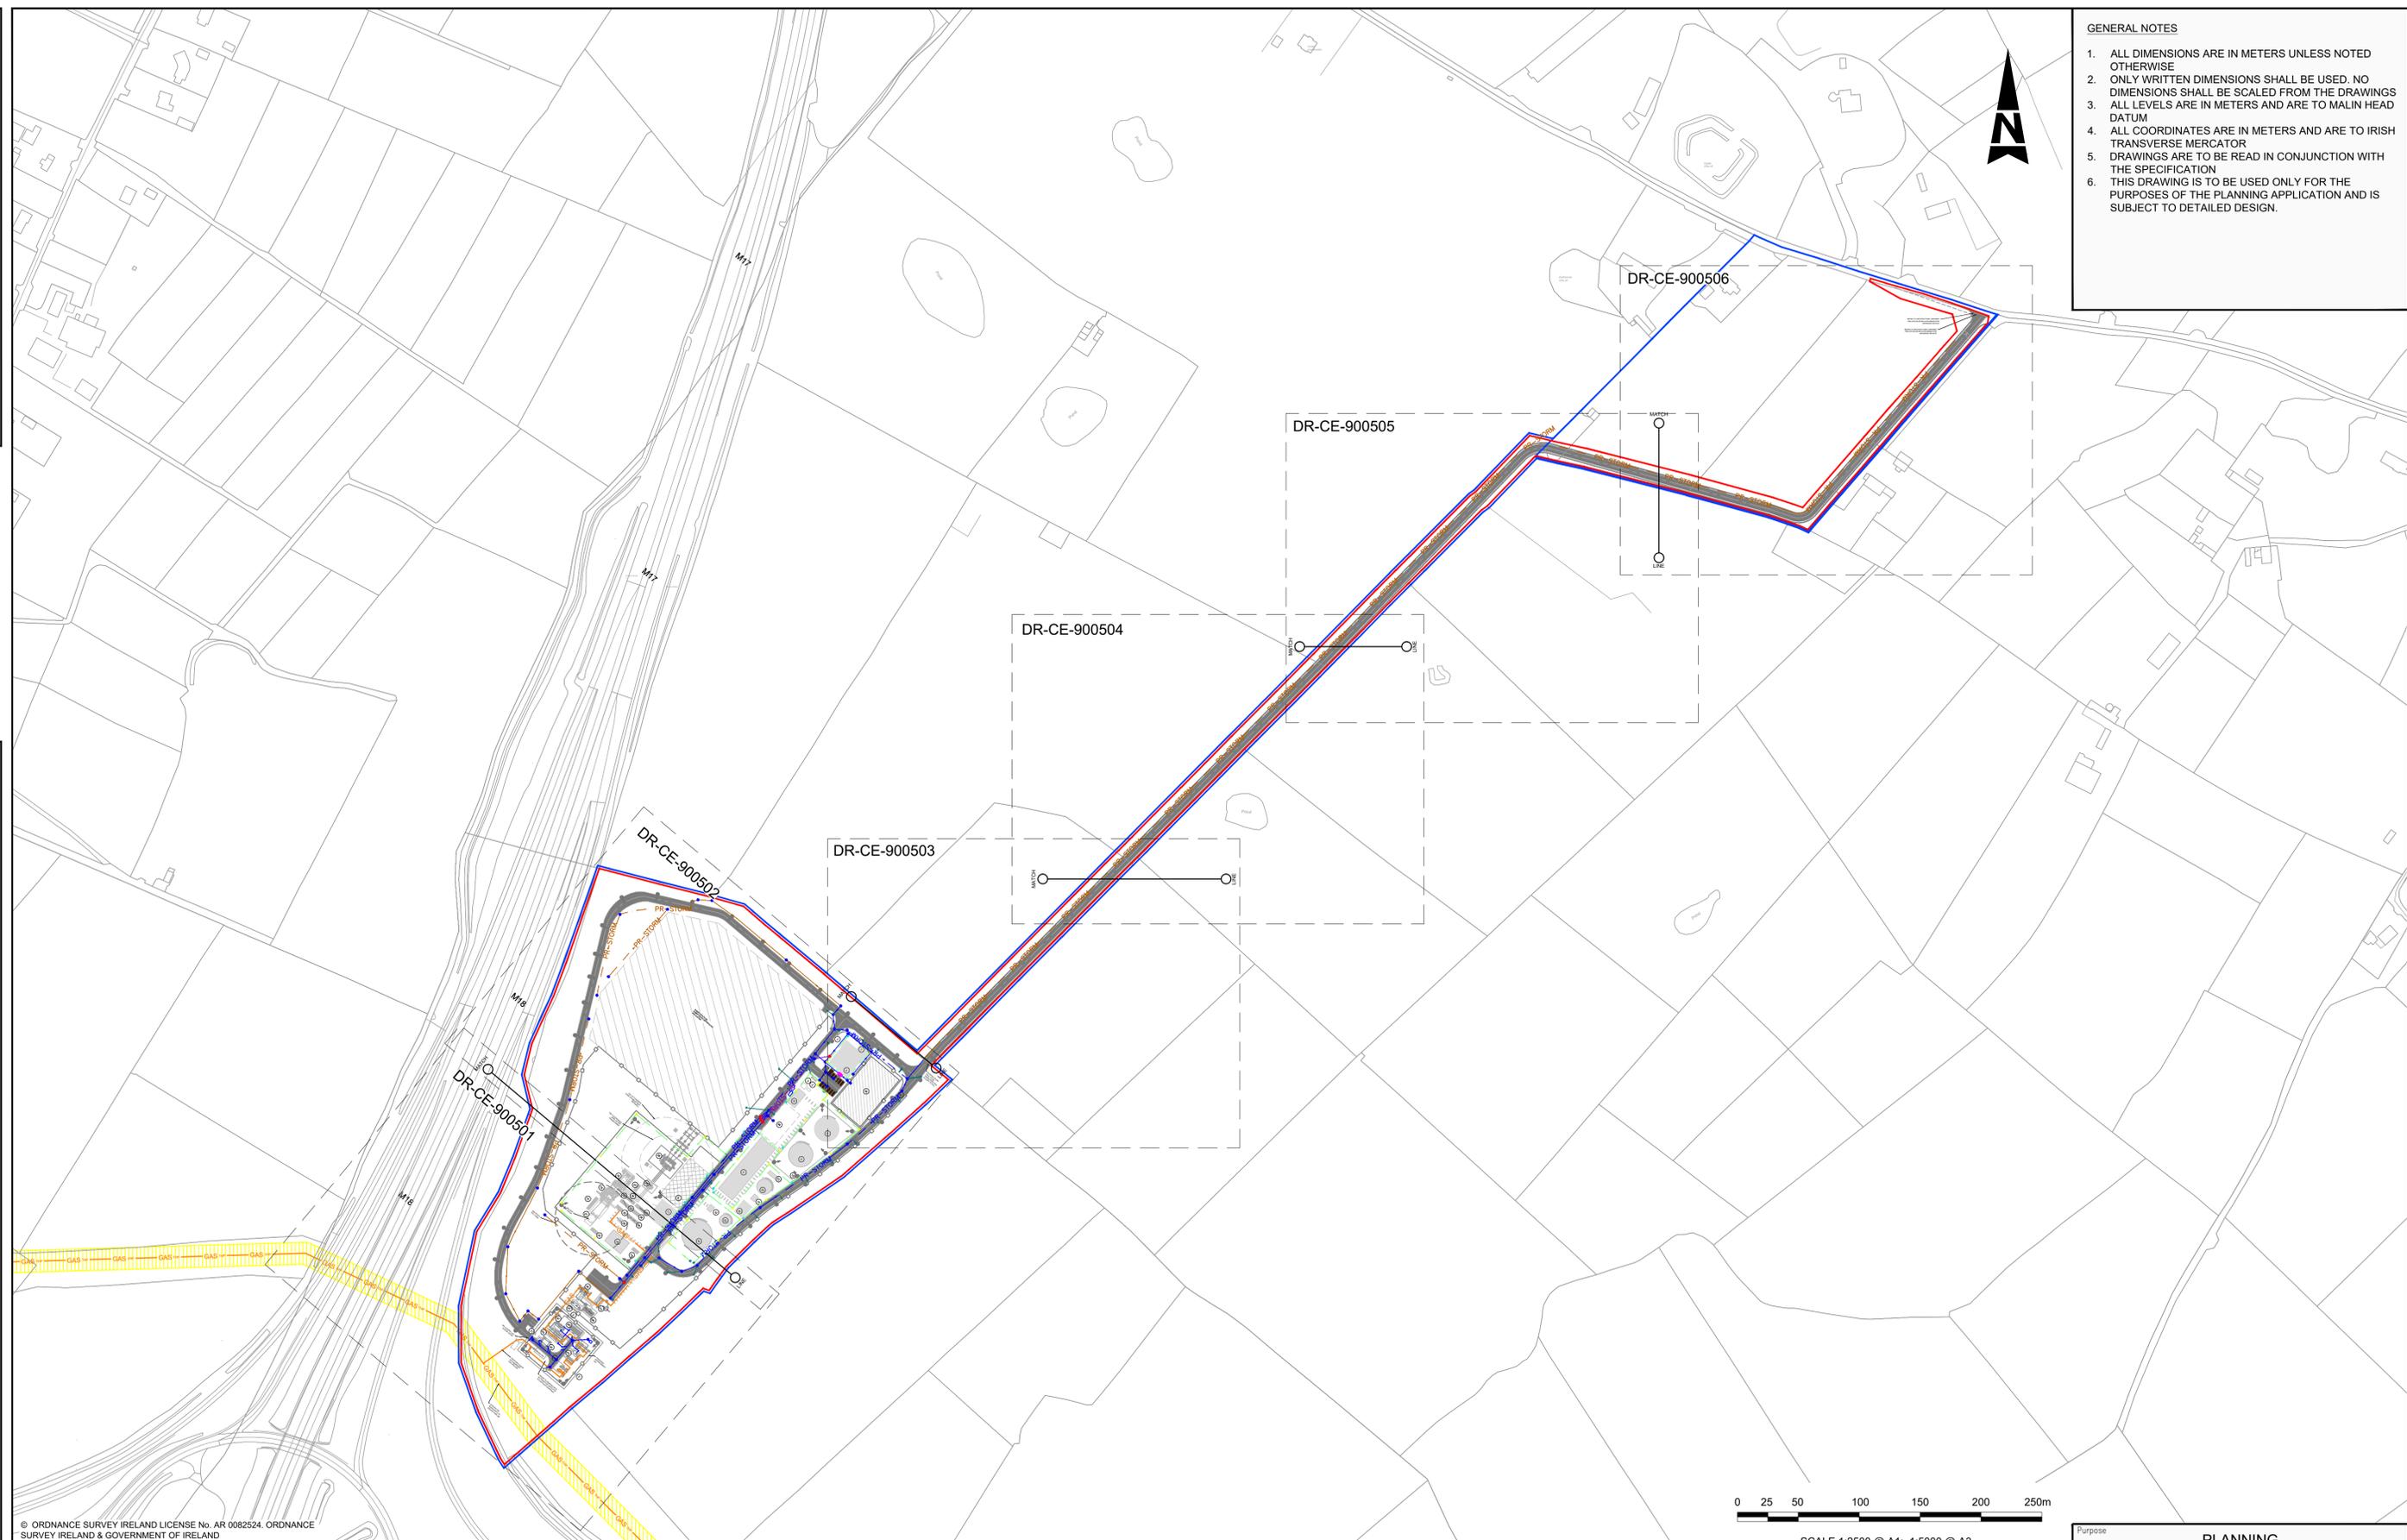

© ORDNANCE SURVEY IRELAND LICENSE No. AR 0082524. ORDNANCE SURVEY IRELAND & GOVERNMENT OF IRELAND REFER TO OSI SHEETS 3220-B, 3220-D, 3221-A, 3221-B, 3221-C & 3221-D

**LEGEND**

|  |                               |  |          |  |   |  |                        |
|--|-------------------------------|--|----------|--|---|--|------------------------|
|  | PROJECT BOUNDARY FOR PLANNING |  | PR-STORM |  | LIGHTNING MAST  |  | HIGH PRESSURE GAS LINE |
|  | LAND OWNERSHIP BOUNDARY       |  | PR-STORM |  | TELECOMMUNICATION MAST  |  | LOW PRESSURE GAS LINE  |
|  | SLEEPER / OH PIPE RACK        |  | PR-STORM |  | PROPOSED CARRIER DRAIN  |  |                        |
|  | PROPOSED STRUCTURES           |  | PR-STORM |  | PROPOSED FILTER DRAIN   |  |                        |
|  | ATTENUATION POND / SOAKAWAY   |  | PR-STORM |  | PROPOSED STORM MANHOLE  |  |                        |
|  | SETDOWN AREAS                 |  | PR-STORM |  | ACTUATOR MANHOLE CONTAINING SENSORS TO DIVERT THE FLOW BASED ON CONTAMINATION LEVEL |  |                        |
|  |                               |  |          |  | PROPOSED LINEAR DRAIN AND SUMP  |  |                        |

| Rev | Description         | By | Date     | Chk'd | Auth |
|-----|---------------------|----|----------|-------|------|
| 0   | ISSUED FOR PLANNING | PS | 01.12.25 | ND    | AJB  |

**AtkinsRéalis**  
 DUBLIN | CORK | GALWAY | DUNDALK  
 ATKINS HOUSE, 150 AIRSIDE BUSINESS PARK,  
 SWORDS, DUBLIN, K67 K5W4.  
 Tel : +353 1 810 8000 Email : info.ie@atkinsrealis.com

**Bord Gáis Energy**  
 CASHLA PEAKER PLANT  
 Rathmorrisy and Pollnagroagh  
 (Townlands), Atheryn, Co. Galway.

|                |                             |                               |          |            |     |
|----------------|-----------------------------|-------------------------------|----------|------------|-----|
| Purpose        |                             | PLANNING                      |          |            |     |
| Title          |                             | STORM DRAINAGE LAYOUT KEYPLAN |          |            |     |
| Original Scale | Design/Drawn                | Checked                       | ND       | Authorized | AJB |
| 1:2500 at A1   | PS                          | 01.12.25                      | 01.12.25 | 01.12.25   |     |
| Status         | Drawing Number              |                               |          | Rev        |     |
| A2             | PEK3-ATK-ZZ-01-DR-CE-900500 |                               |          | 0          |     |

File: PEK3-ATK-ZZ-01-DR-CE-900500-900502.dwg  
 Date: Feb 06, 2026 - 2:59pm  
 Plotted by: SHER8400