


100
0 10
A1

DO NOT SCALE

File: PEK3-ATK-ZZ-01-DR-CE-900500-900502.dwg
Date: Jan 29, 2026 - 4:27pm
Printed by: SHER8400

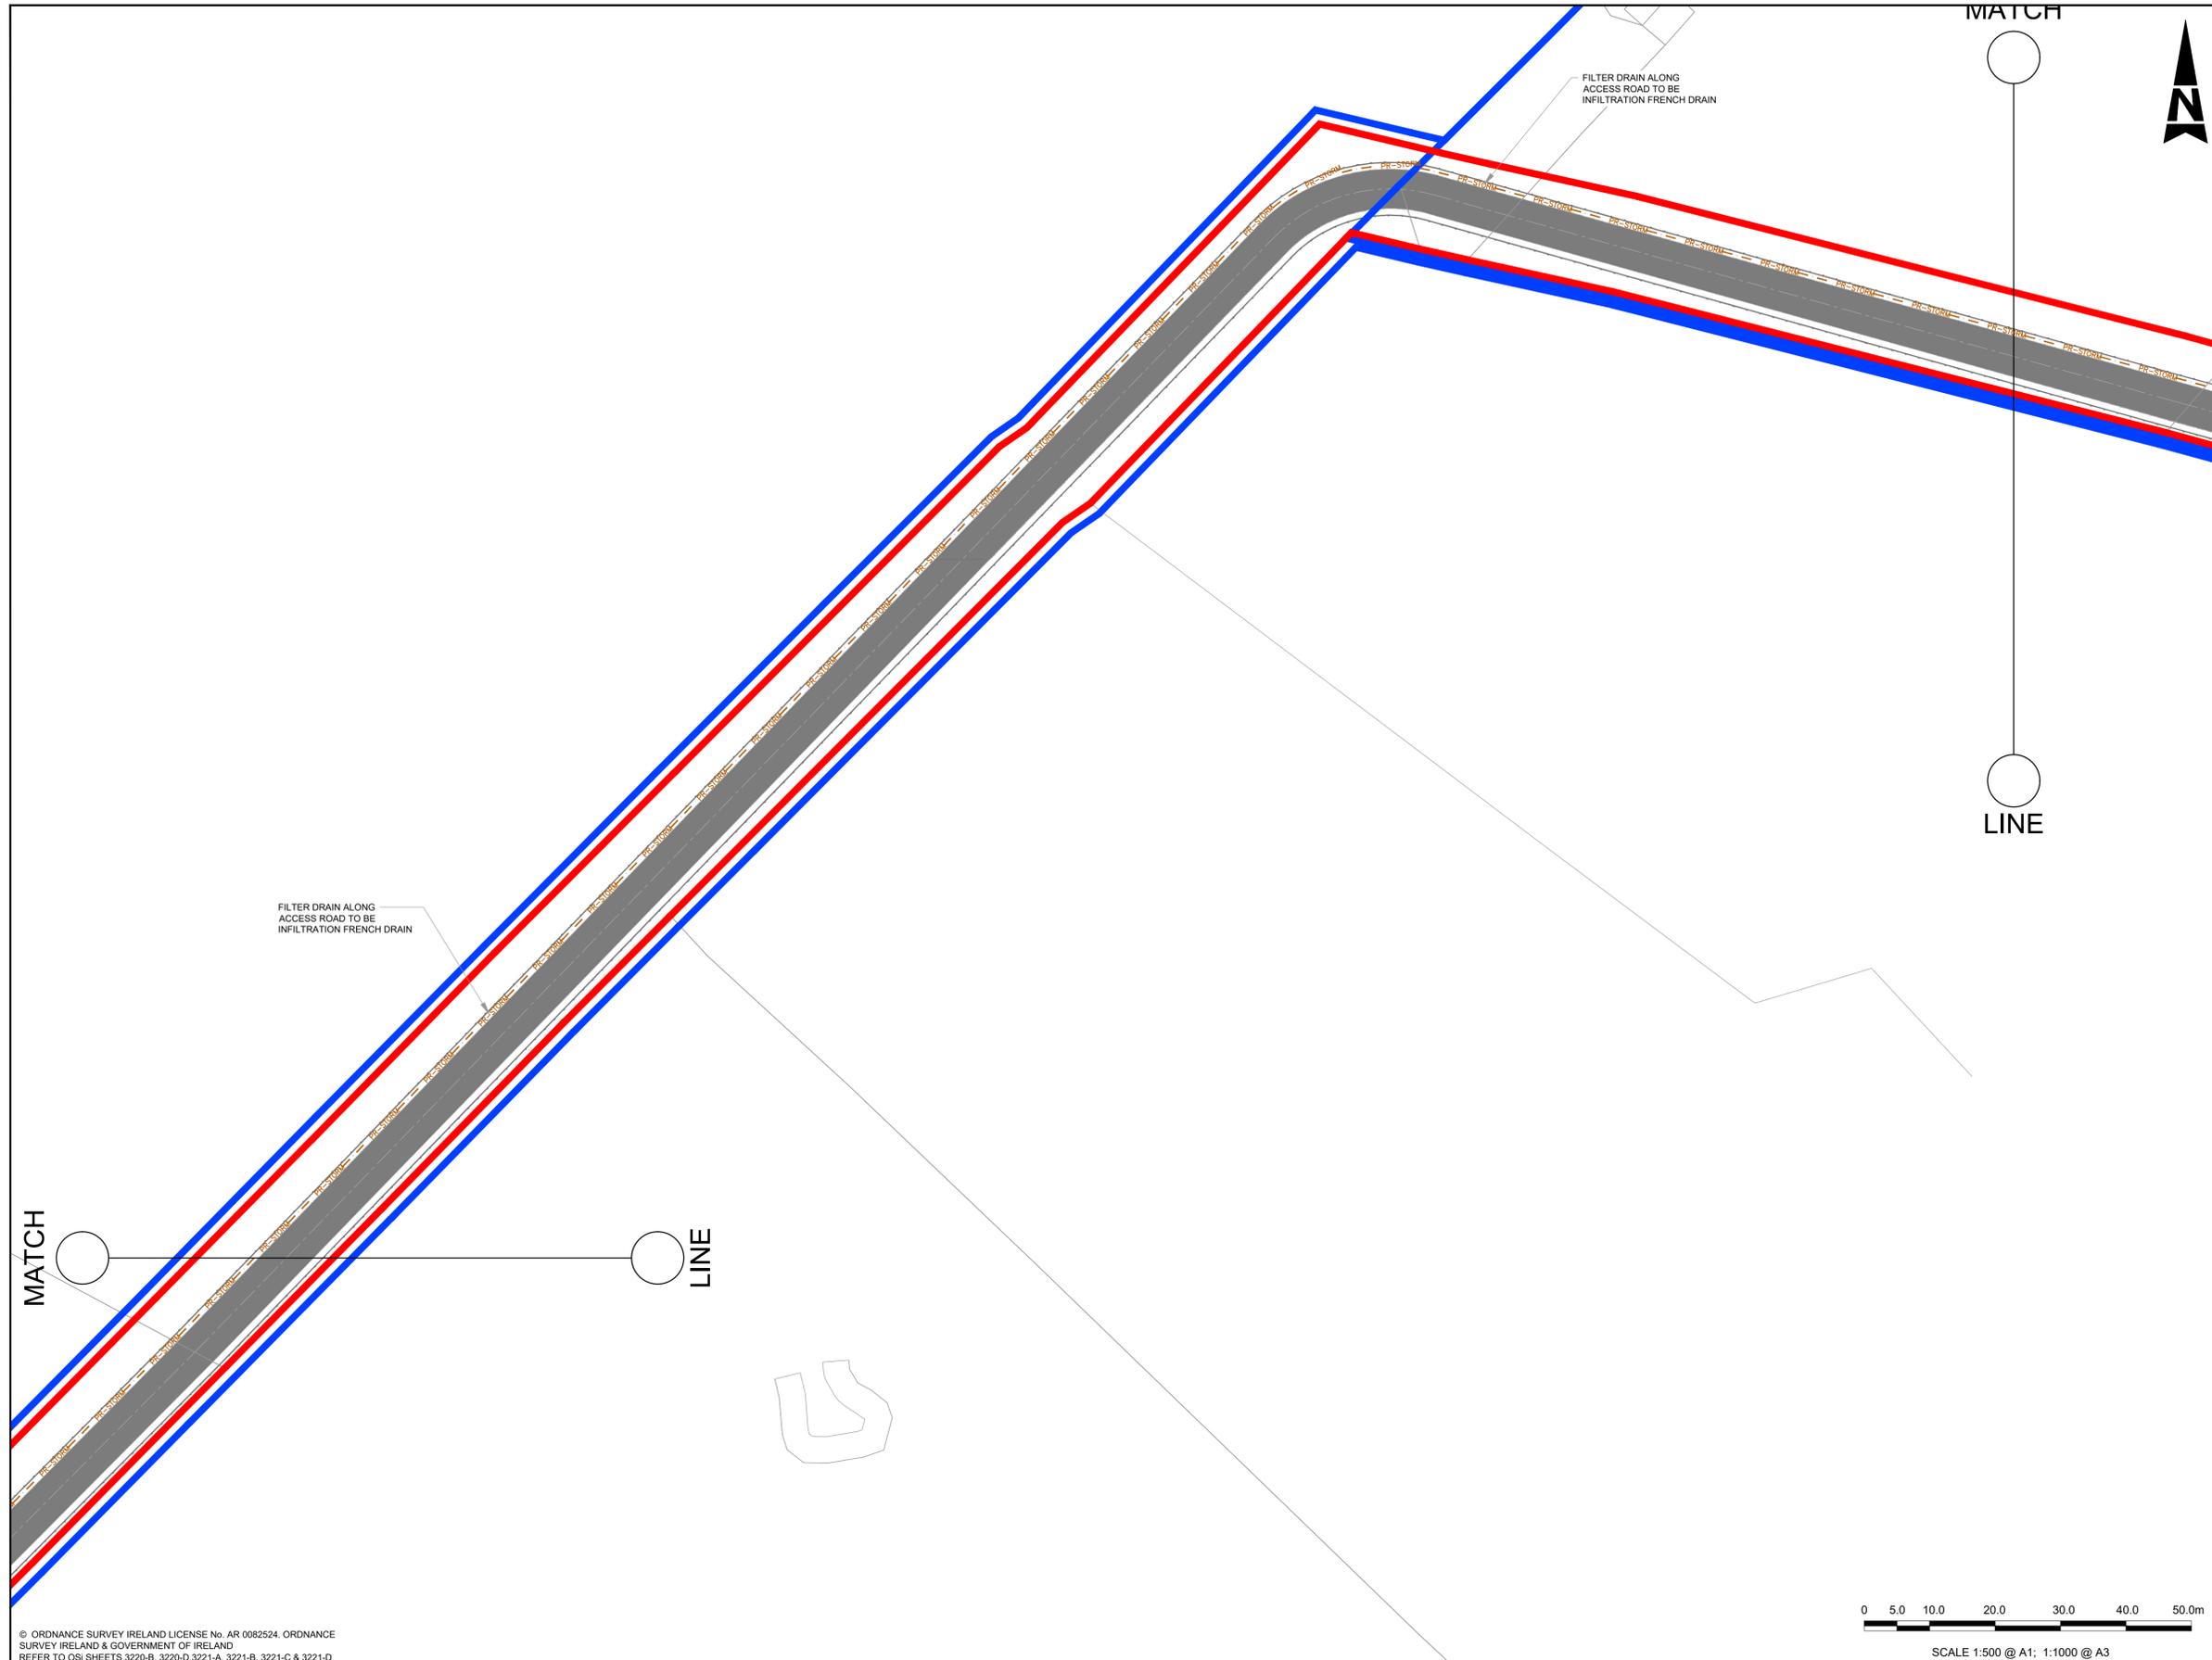

- GENERAL NOTES**
1. ALL DIMENSIONS ARE IN METERS UNLESS NOTED OTHERWISE
 2. ONLY WRITTEN DIMENSIONS SHALL BE USED. NO DIMENSIONS SHALL BE SCALED FROM THE DRAWINGS
 3. ALL LEVELS ARE IN METERS AND ARE TO MALIN HEAD DATUM
 4. ALL COORDINATES ARE IN METERS AND ARE TO IRISH TRANSVERSE MERCATOR
 5. DRAWINGS ARE TO BE READ IN CONJUNCTION WITH THE SPECIFICATION
 6. THIS DRAWING IS TO BE USED ONLY FOR THE PURPOSES OF THE PLANNING APPLICATION AND IS SUBJECT TO DETAILED DESIGN.

- LEGEND**
- PROJECT BOUNDARY FOR PLANNING
 - LAND OWNERSHIP BOUNDARY
 - - - PR-STORM - - - PROPOSED FILTER DRAIN

© ORDNANCE SURVEY IRELAND LICENSE No. AR 0082524. ORDNANCE SURVEY IRELAND & GOVERNMENT OF IRELAND REFER TO OSI SHEETS 3220-B, 3220-D, 3221-A, 3221-B, 3221-C & 3221-D



Rev	Description	By	Date	Chk'd	Auth
0	ISSUED FOR PLANNING	PS	01.12.25	ND	AJB

AtkinsRéalis
DUBLIN | CORK | GALWAY | DUNDALK
ATKINS HOUSE, 150 AIRSIDE BUSINESS PARK,
SWORDS, DUBLIN, K67 K5W4.
Tel : +353 1 810 8000 Email : info.ie@atkinsrealis.com

Bord Gáis Energy
Project: **CASHLA PEAKER PLANT**
Rathmorrisy and Pollnagroagh
(Townlands), Atherry, Co. Galway.

Purpose		PLANNING			
Title		STORM DRAINAGE LAYOUT SHEET 05			
Original Scale	Design/Drawn	Checked	Authorized		
1:500 at A1	PS	ND	AJB		
Date	Date	Date	Date		
01.12.25	01.12.25	01.12.25	01.12.25		
Status	Drawing Number	Rev			
A2	PEK3-ATK-ZZ-01-DR-CE-900505	0			