


A1

 
DO NOT SCALE

File: PEK3-ATK-ZZ-01-DR-CE-900550-900551.dwg
Date: Jan 29, 2026 - 4:28pm
Plotted by: SHER8400

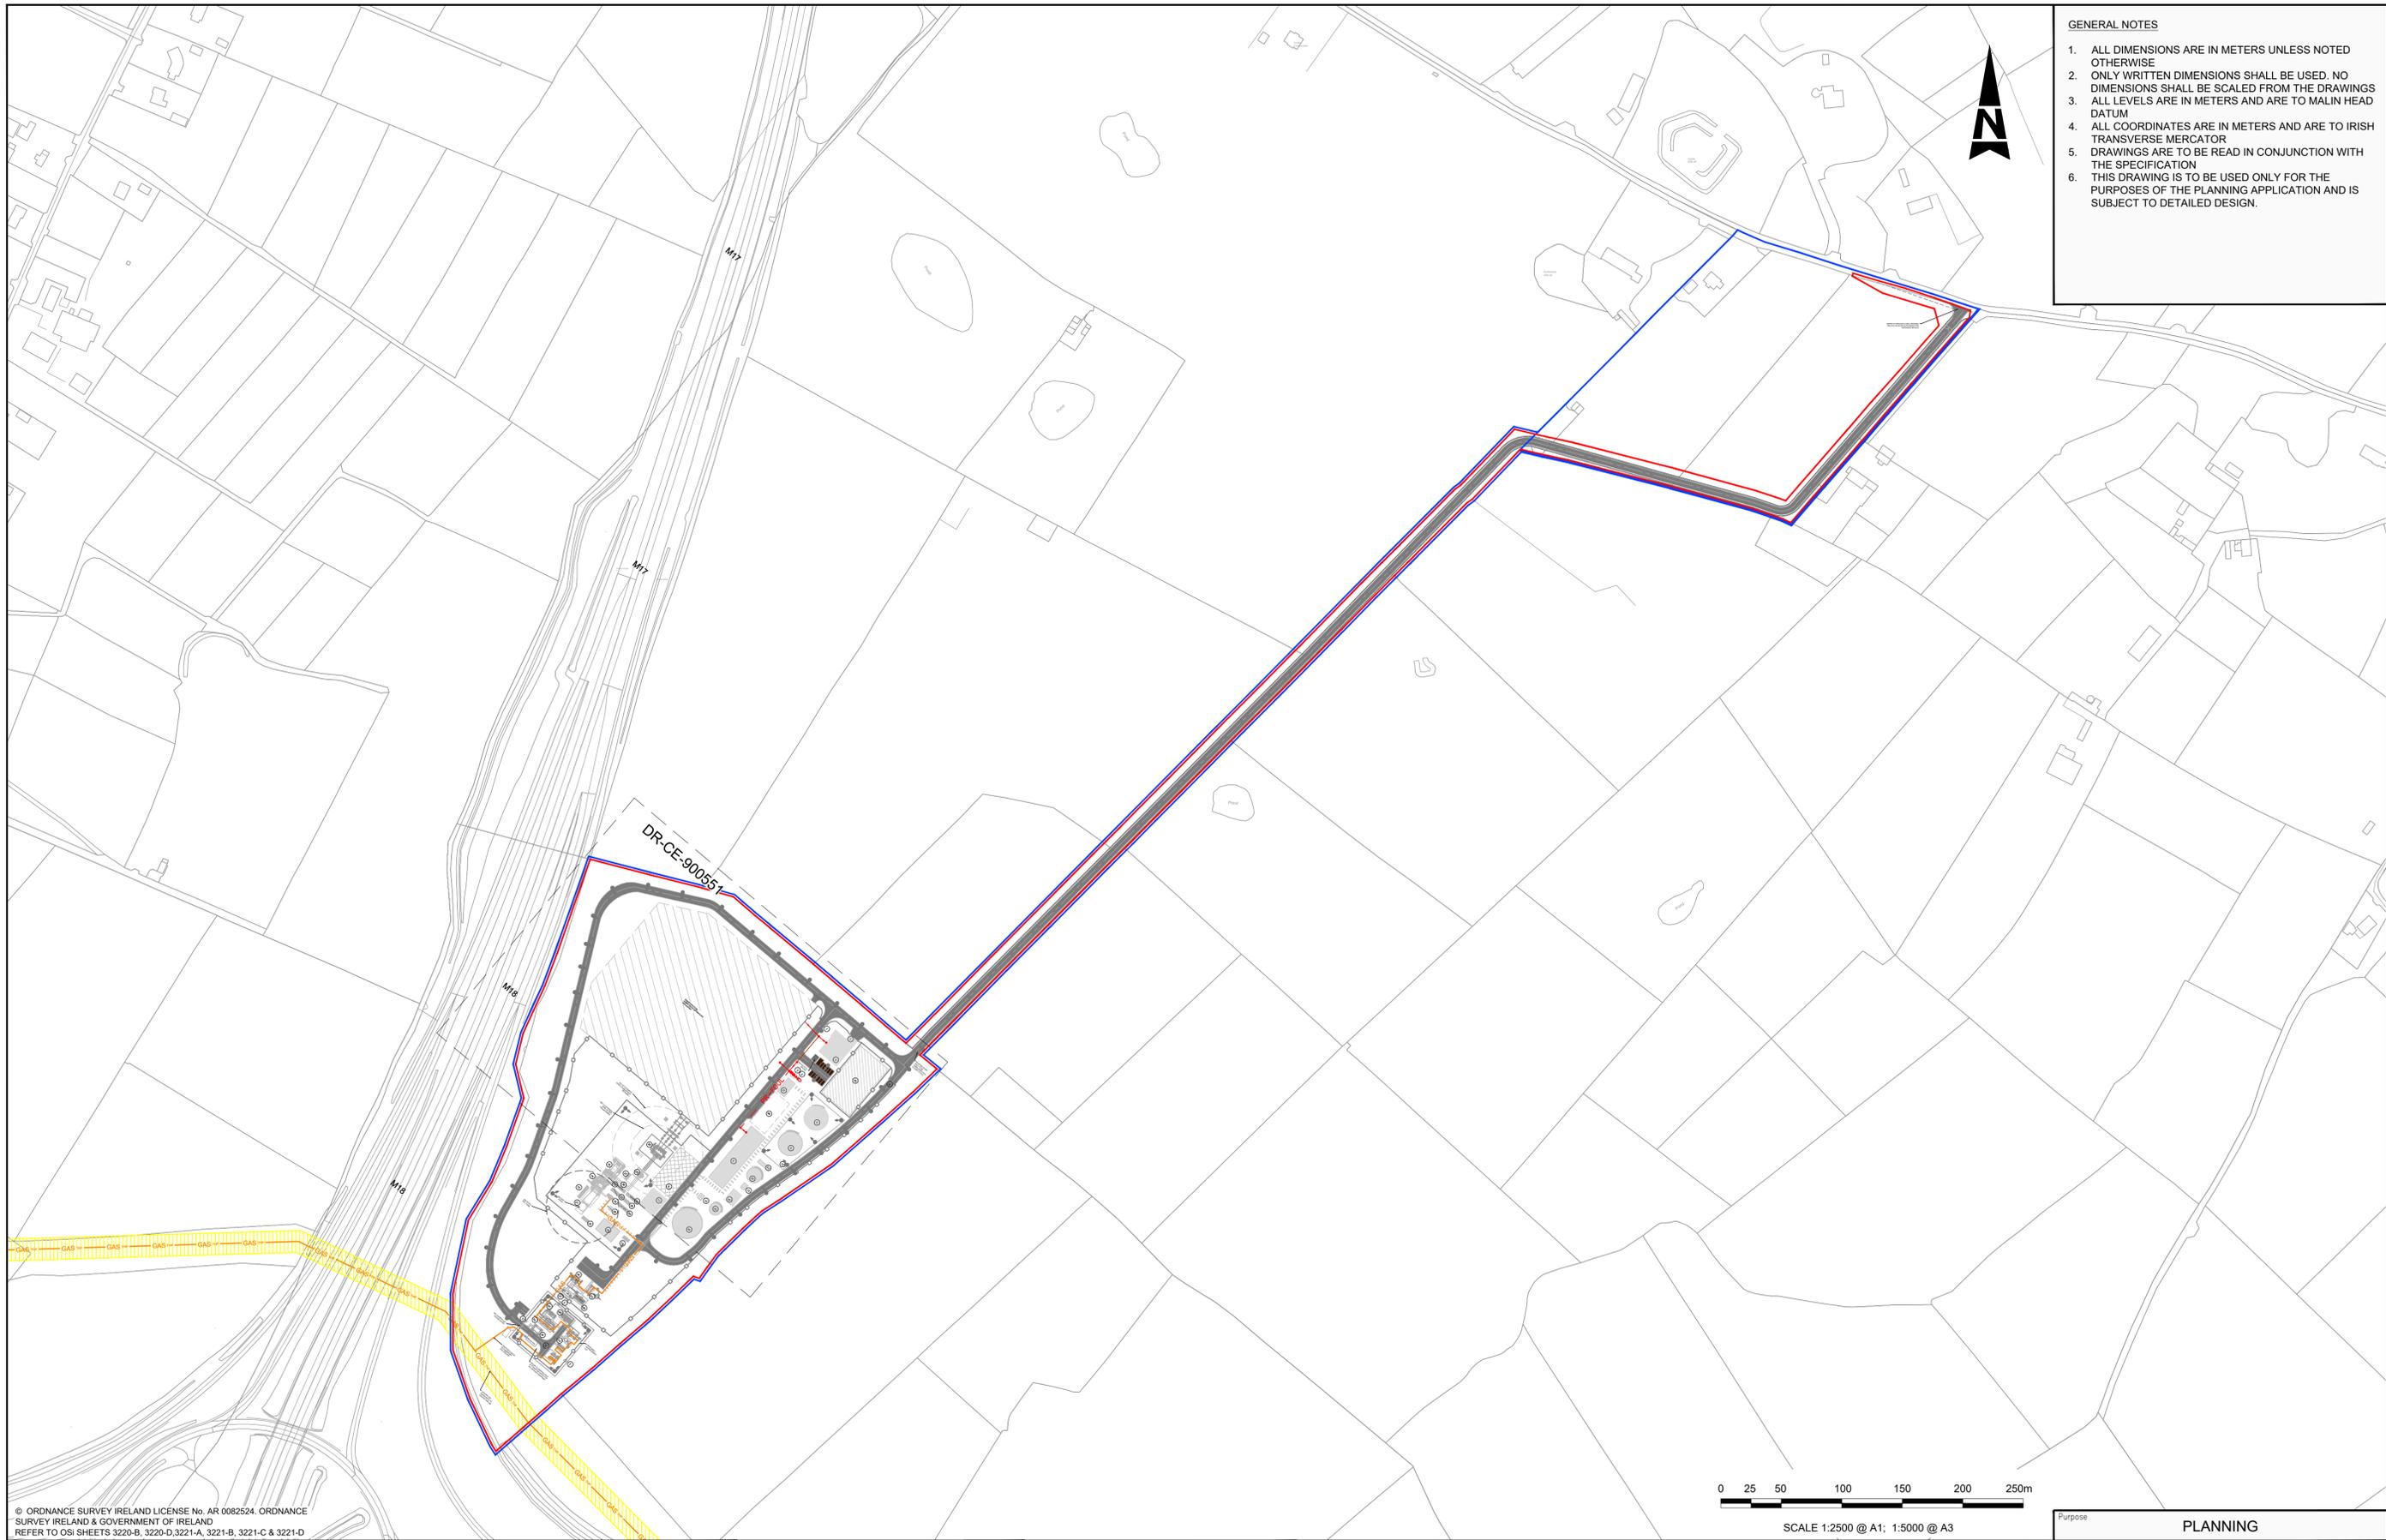

- GENERAL NOTES**
1. ALL DIMENSIONS ARE IN METERS UNLESS NOTED OTHERWISE
 2. ONLY WRITTEN DIMENSIONS SHALL BE USED. NO DIMENSIONS SHALL BE SCALED FROM THE DRAWINGS
 3. ALL LEVELS ARE IN METERS AND ARE TO MALIN HEAD DATUM
 4. ALL COORDINATES ARE IN METERS AND ARE TO IRISH TRANSVERSE MERCATOR
 5. DRAWINGS ARE TO BE READ IN CONJUNCTION WITH THE SPECIFICATION
 6. THIS DRAWING IS TO BE USED ONLY FOR THE PURPOSES OF THE PLANNING APPLICATION AND IS SUBJECT TO DETAILED DESIGN.

© ORDNANCE SURVEY IRELAND LICENSE No. AR 0082524. ORDNANCE SURVEY IRELAND & GOVERNMENT OF IRELAND REFER TO OSI SHEETS 3220-B, 3220-D, 3221-A, 3221-B, 3221-C & 3221-D



- LEGEND**
- PROJECT BOUNDARY FOR PLANNING
 - LAND OWNERSHIP BOUNDARY
 - WAYLEAVE

Rev	Description	By	Date	Chk'd	Auth
0	ISSUED FOR PLANNING	PS	01.12.25	ND	AJB

AtkinsRéalis
DUBLIN | CORK | GALWAY | DUNDALK
ATKINS HOUSE, 150 AIRSIDE BUSINESS PARK,
SWORDS, DUBLIN, K67 K5W4.
Tel : +353 1 810 8000 Email : info.ie@atkinsrealis.com

Bord Gáis Energy
Project: **CASHLA PEAKER PLANT**
Rathmorrisy and Pollnagroagh
(Townlands), Atherry, Co. Galway.

Purpose		PLANNING			
Title		FOUL DRAINAGE LAYOUTS KEYPLAN			
Original Scale	Design/Drawn	Checked	ND	Authorized	AJB
1:2500 at A1	PS	01.12.25	01.12.25	01.12.25	
Status	Drawing Number	Rev			
A2	PEK3-ATK-ZZ-01-DR-CE-900550	0			