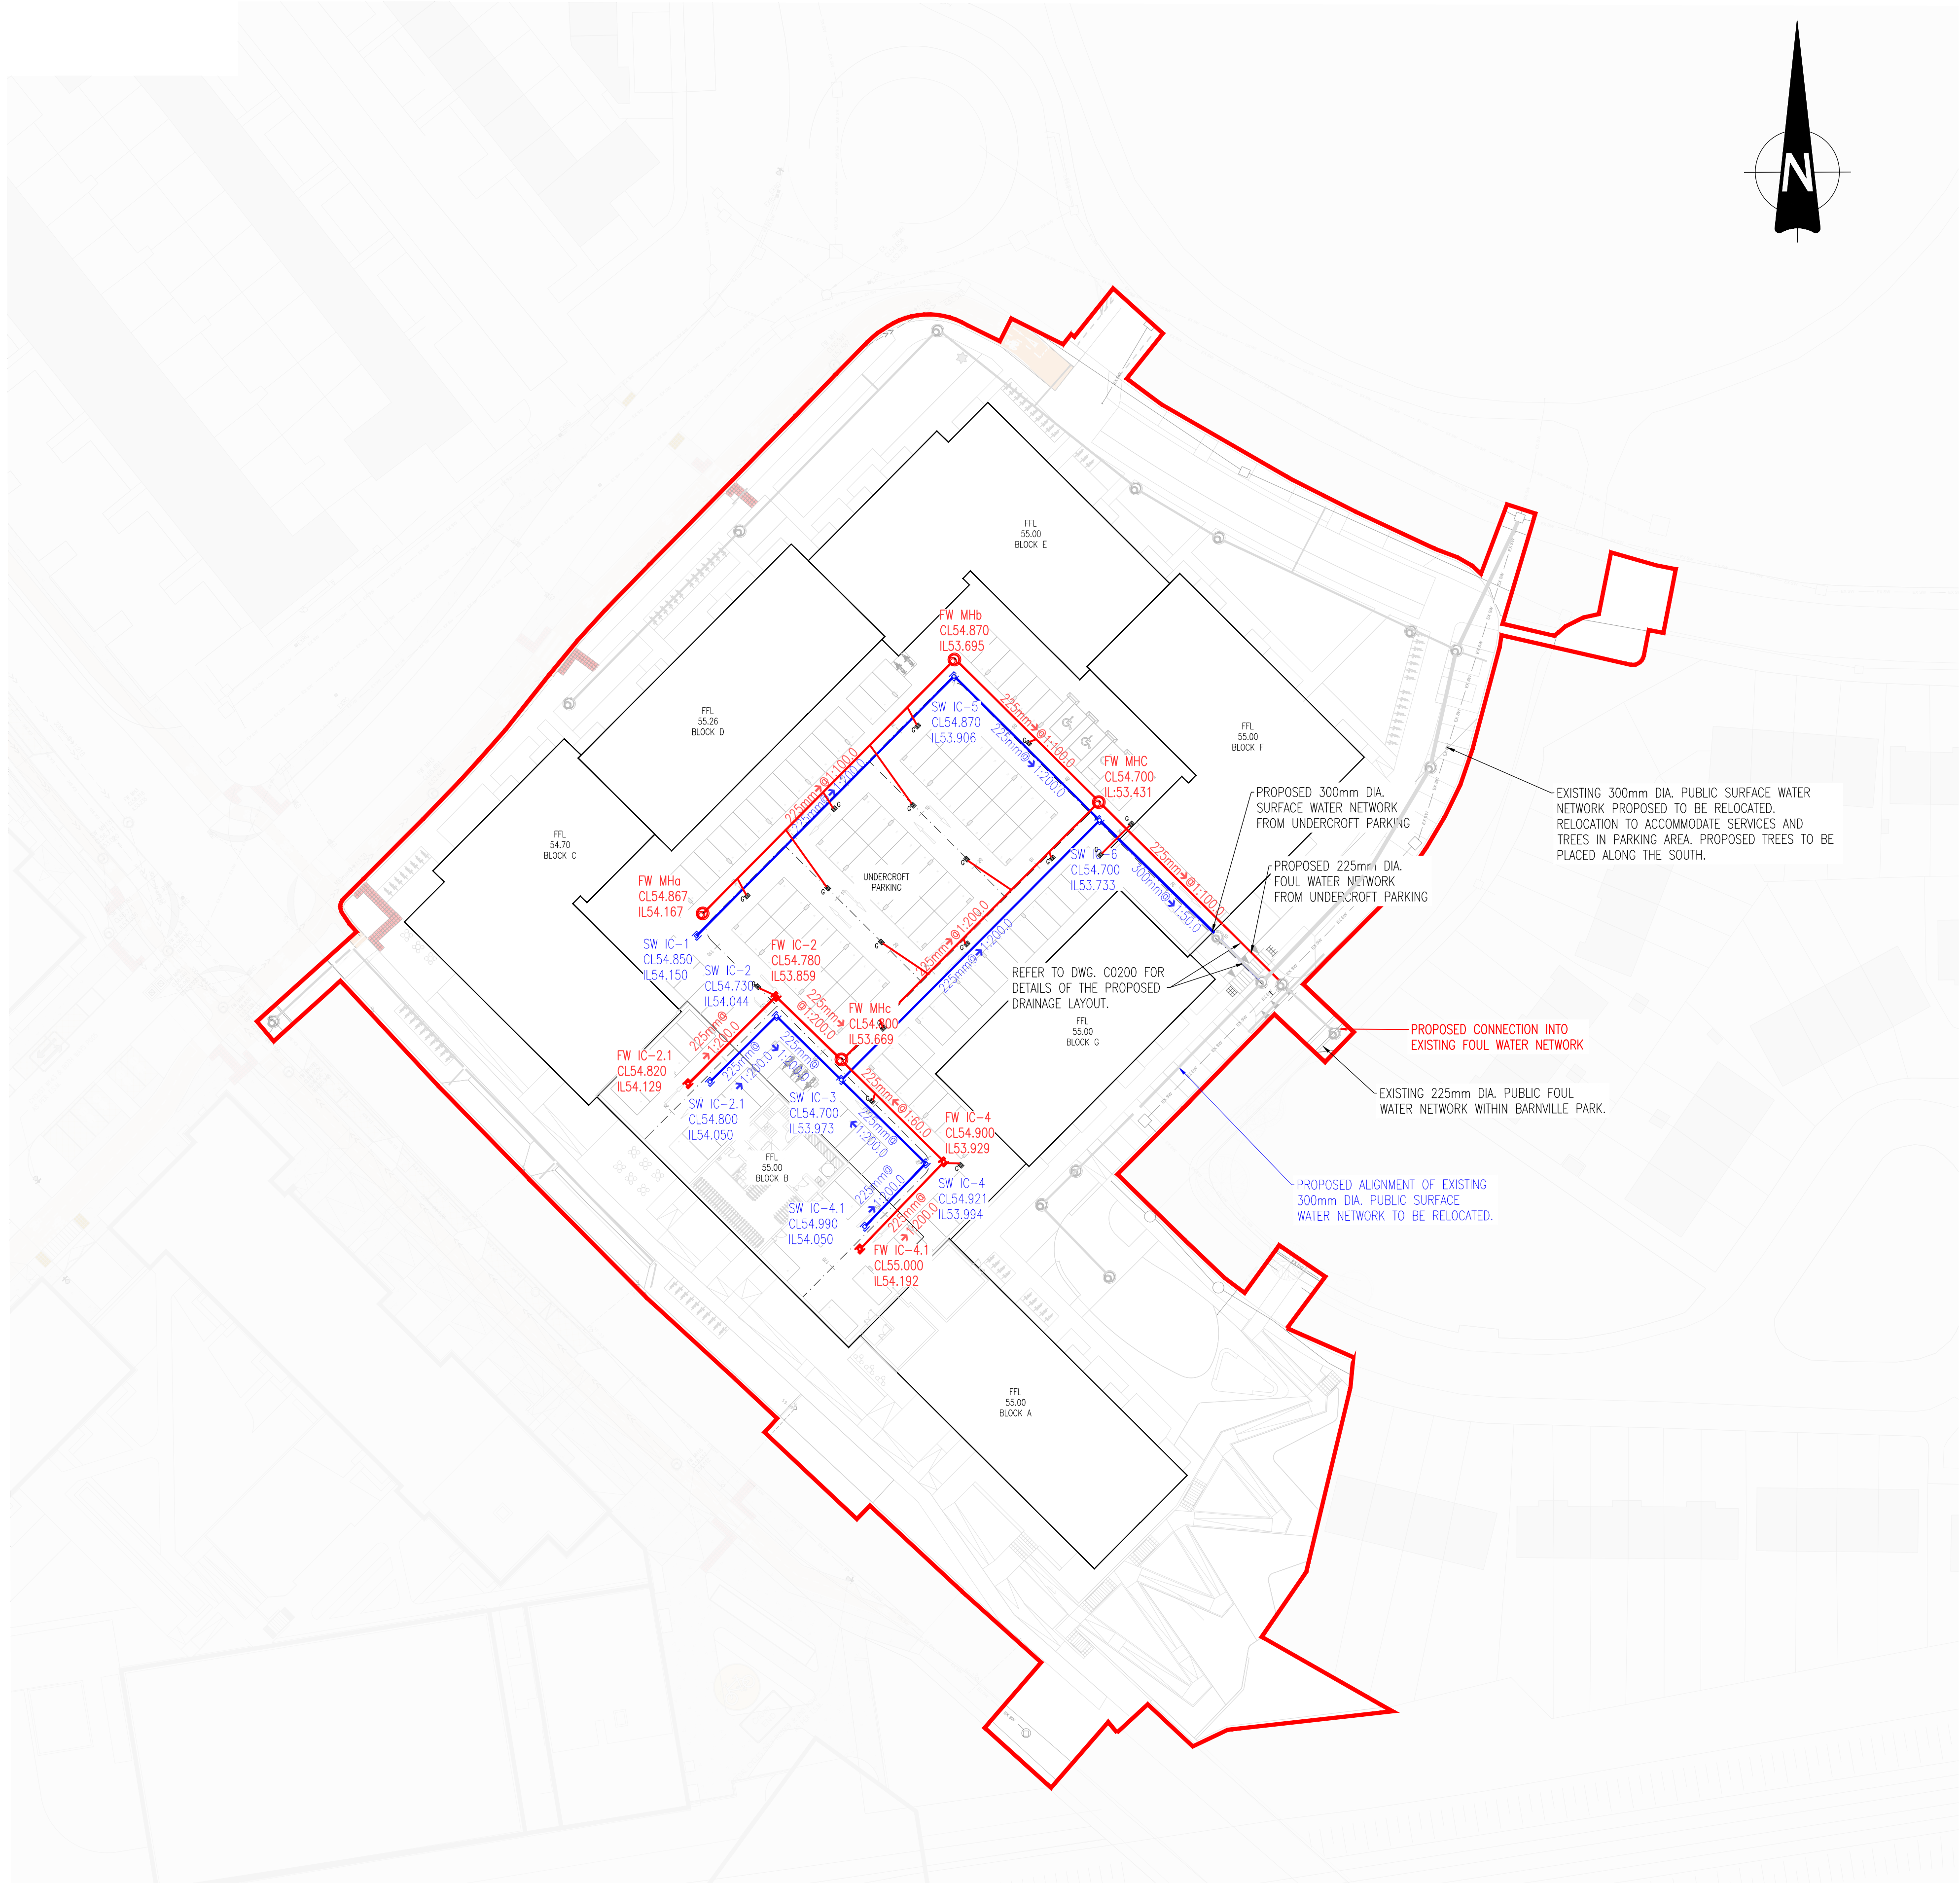


LEGEND:

- PHASE 3 BOUNDARY LINE
- Ex XXXmm EX-FWH
CL XX
IL XX EXISTING FOUL SEWER & MANHOLE
(IRISH WATER RECORDS)
- Ex XXXmm EX-SWH
CL XX
IL XX EXISTING SURFACE WATER SEWER & MANHOLE
(IRISH WATER RECORDS)
- ØXXXmm MH-FWXX
CL XX.XX
IL XX.XX PROPOSED FOUL WATER SEWER WITH PIPE SIZE,
GRADE, MANHOLE REF. AND INVERT LEVEL
- ØXXXmm MH-SWXX
CL XX.XX
IL XX.XX PROPOSED SURFACE WATER SEWER WITH PIPE
SIZE, GRADE, MANHOLE REF. AND INVERT LEVEL
- ØXXXmm IC-FWXX
CL XX.XX
IL XX.XX PROPOSED FOUL WATER SEWER WITH PIPE SIZE,
GRADE, INSPECTION CHAMBER REF. AND
INVERT LEVEL
- ØXXXmm IC-SWXX
CL XX.XX
IL XX.XX PROPOSED SURFACE WATER SEWER WITH PIPE
SIZE, GRADE, INSPECTION CHAMBER REF. AND
INVERT LEVEL

This drawing should not be scaled. Dimensions to be verified on site.
Any discrepancies should be referred to the Engineer prior to work being put in hand.
This drawing is the property of Waterman Moylan Consulting Engineers Limited and is
issued on the condition that it is not copied, reproduced, retained or disclosed to any unauthorized person, either
wholly or in part without the consent in writing of
Waterman Moylan Consulting Engineers Limited
Block S East Point Business Park Dublin D03 H3F4 Ireland t+353 1 864 8900

NOTES:

- DO NOT SCALE. USE FIGURED DIMENSIONS ONLY.
- THIS DRAWING IS TO BE READ IN CONJUNCTION WITH ALL
OTHER RELEVANT ARCHITECTURAL AND ENGINEERING
DRAWINGS.

PD1	14/09/25	ISSUED FOR PLANNING	IG	IW	
Rev	Date	Description	By	Chk	
Amendments					
Project					
CHERRY ORCHARD POINT PHASE 3					
Title					
PROPOSED UNDERCROFT DRAINAGE LAYOUT					
Client					
LAND DEVELOPMENT AGENCY					
Status					
PLANNING					
Designed By	PI	Approved	IW	Waterman Ref	22-010
Drawn By	IG	Date	SEPT. 2026	Scales @ A1	1:500
Project - Originator - Volume - Level - Type - Role - Number					Revision
COP-WMC-PH3-00- DR- C - P0201					P01

