




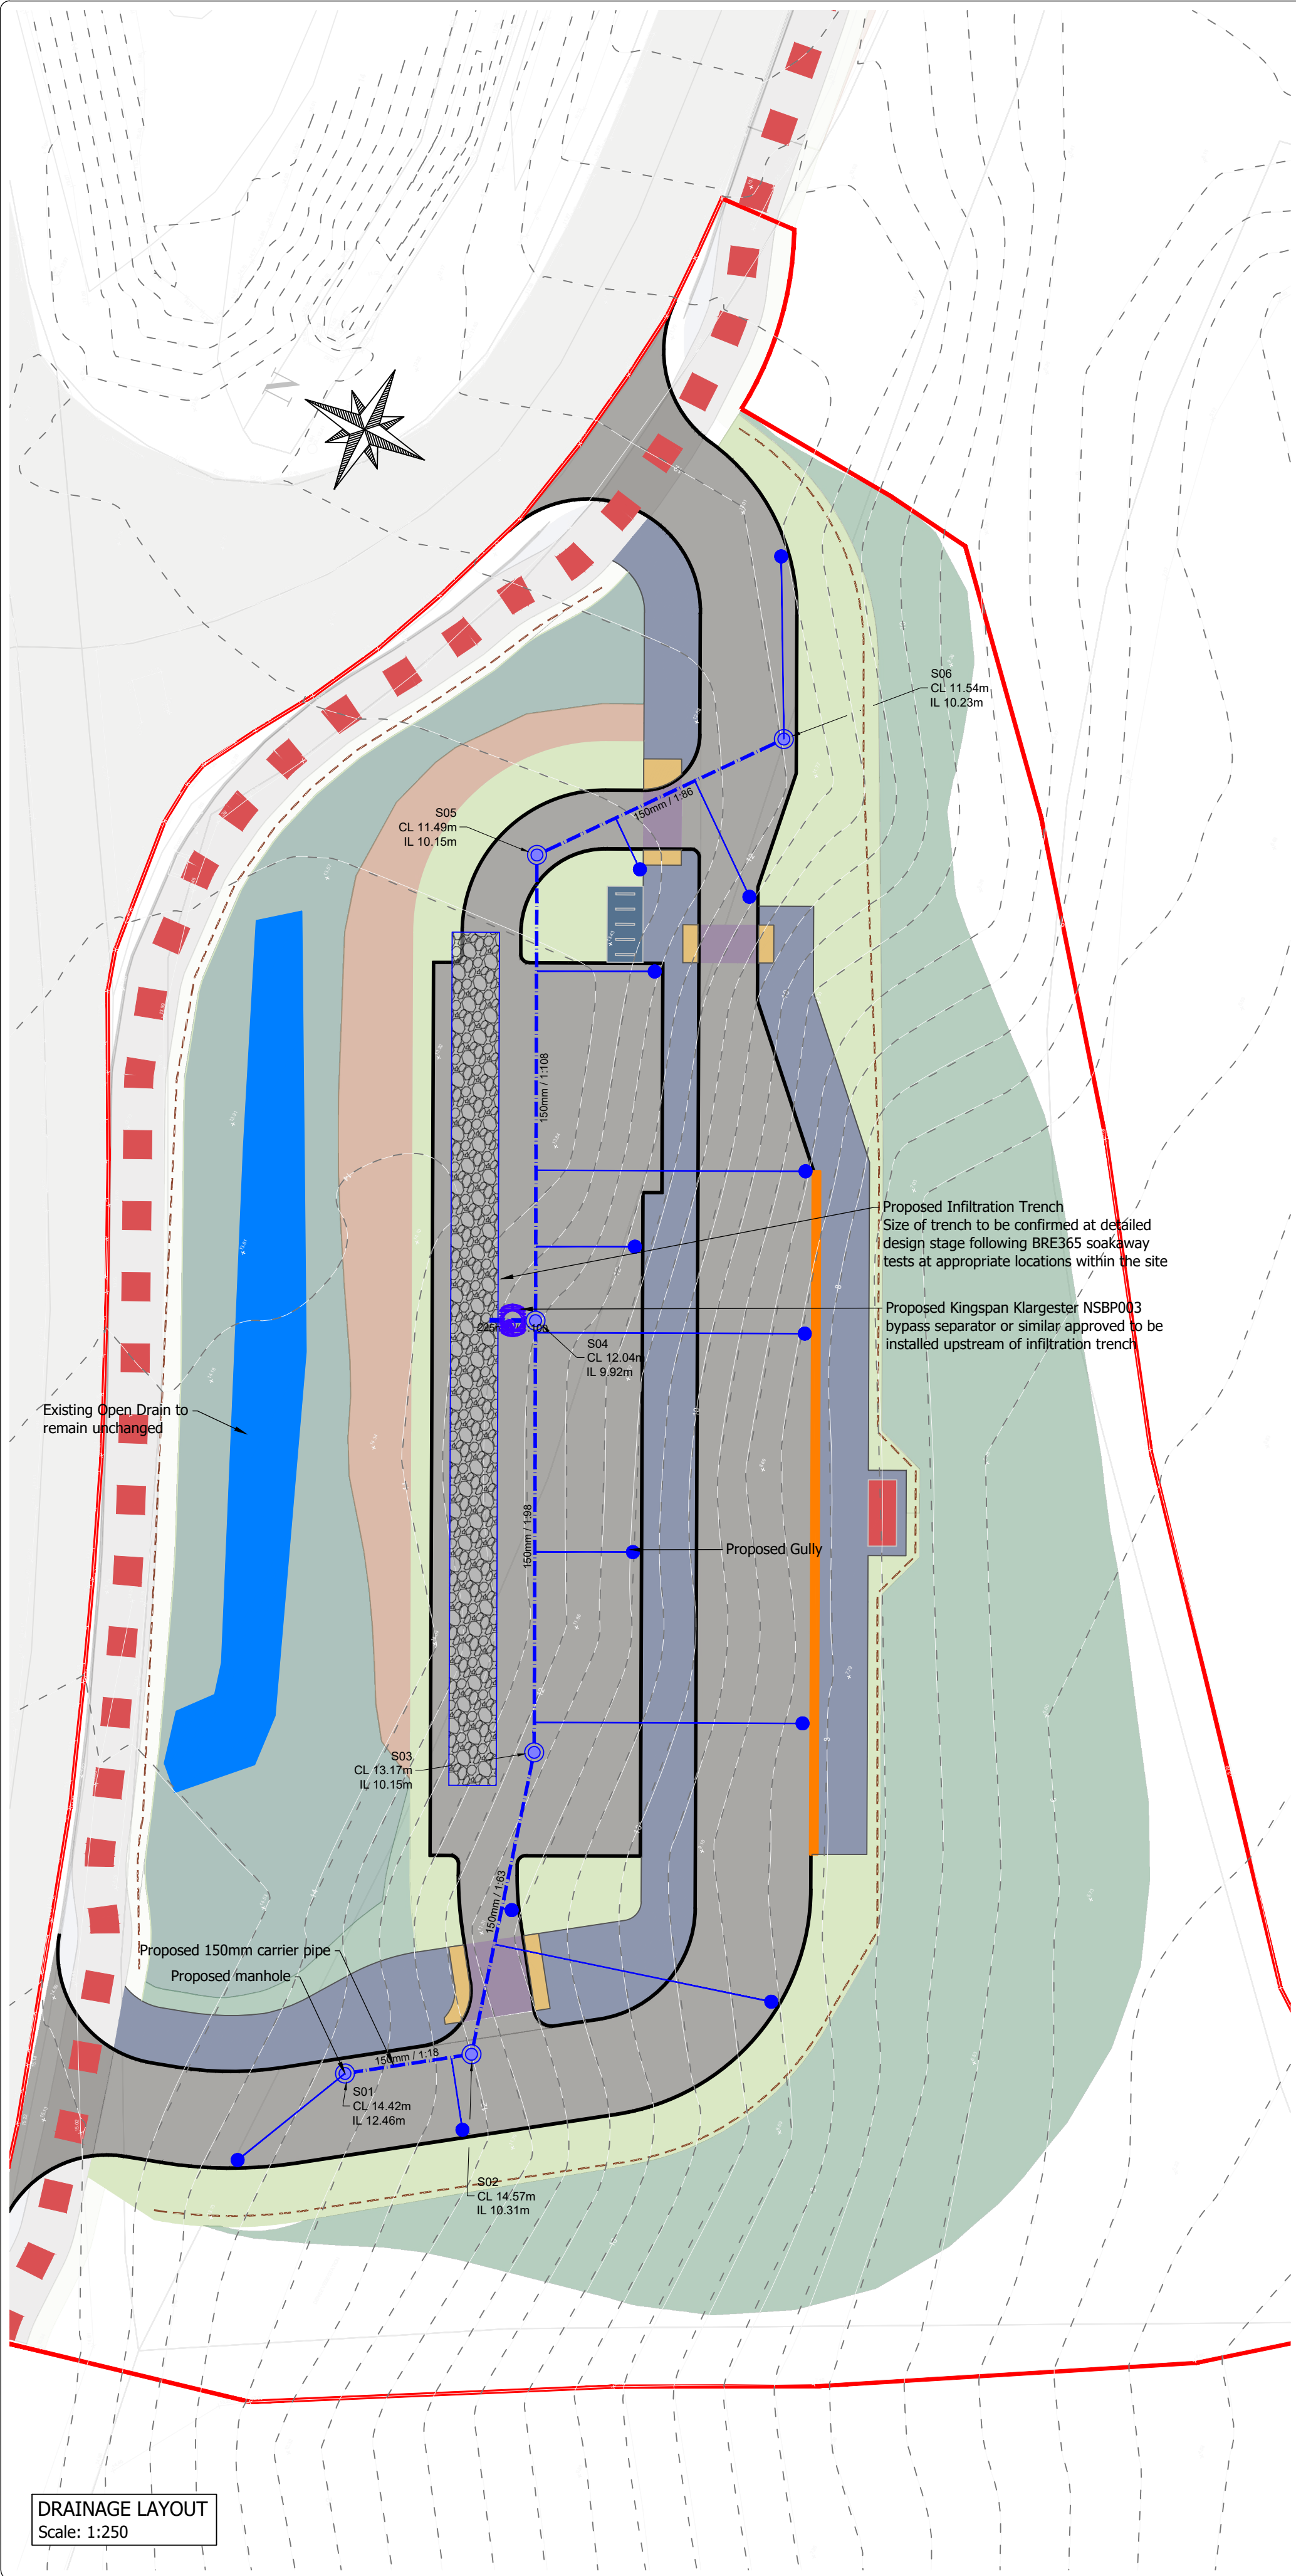

DRAINAGE LAYOUT
Scale: 1:250

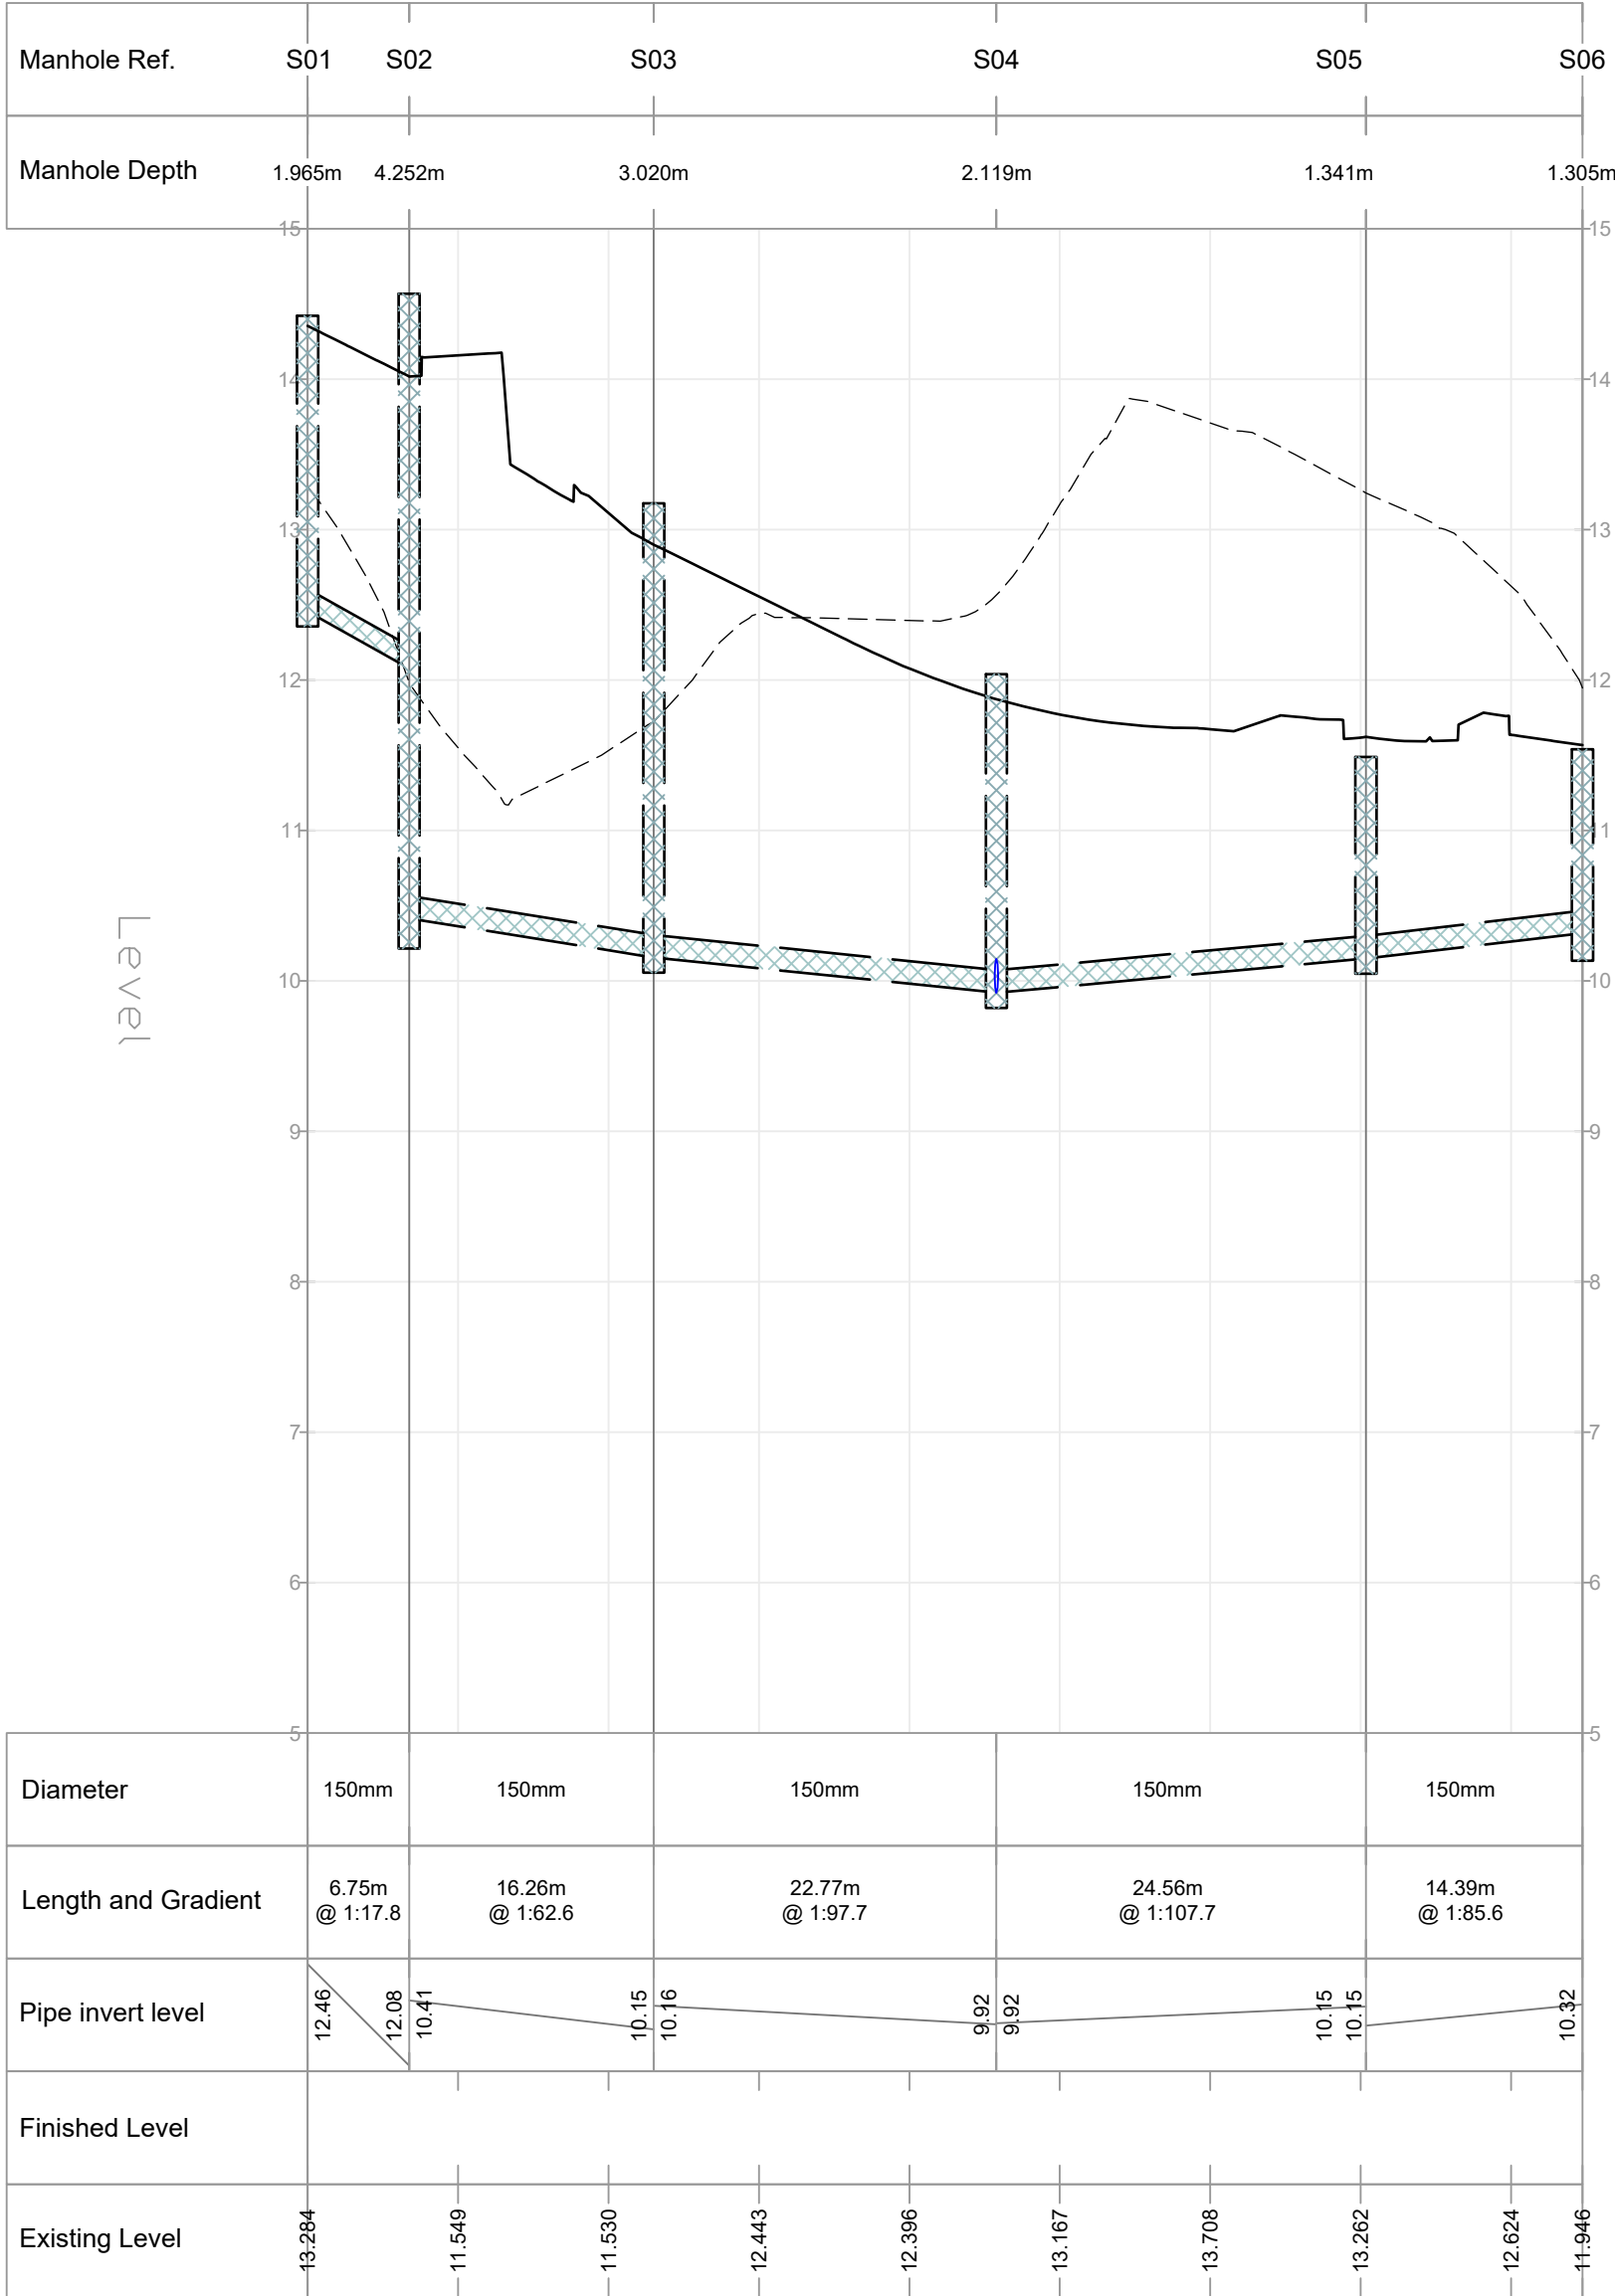

LONGITUDINAL SECTION THROUGH SURFACE WATER NETWORK
Scale: 1:500H, 1:50V

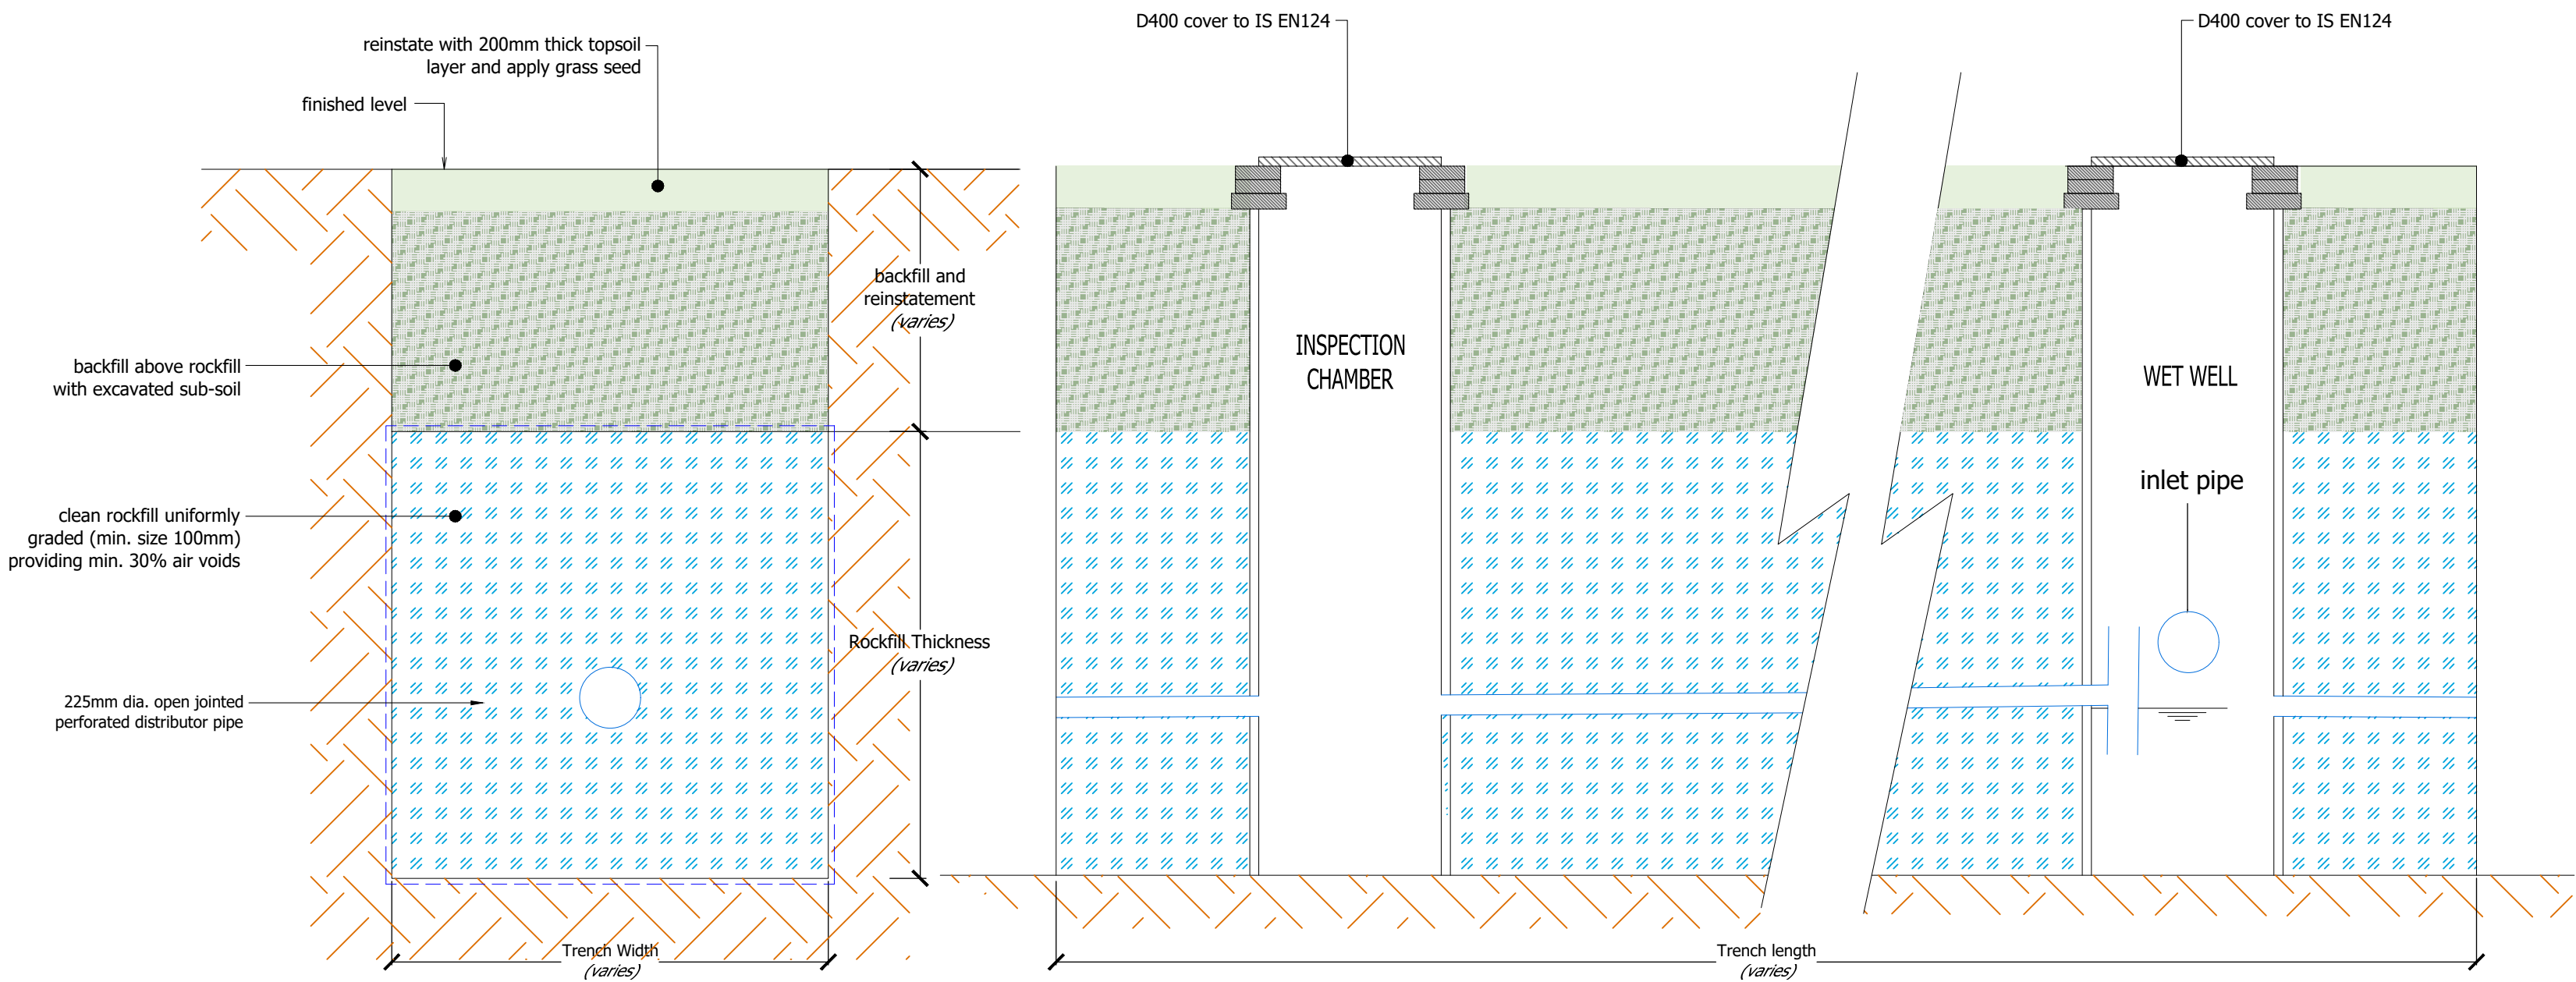

DETAIL SW15
INFILTRATION TRENCH
(Scale 1:20)

- GENERAL
- Datum for levels is OS Malin Head.
 - The locations shown for existing services are indicative only and may not be accurate. Furthermore, uncharted services may also be present.
- Specification
- All works to comply with the TII Specification for Roadworks unless otherwise noted.
 - Public lighting will be installed across the bus park in accordance with Kilkenny County Council Public Lighting Manual and Product Specification. The lighting will be considerate of the surrounding area and habitats and there will be no light overspill.

OS mapping reproduced under licence.

This drawing is not to be reproduced without the written permission of Kilgallen & Partners. Copyright.

PR5	17/07/26	AB	ADJUSTED VEHICLE RESTRAINT BARRIER LOCATION
PR4	13/07/26	AB	REVISED IN RESPONSE TO RSA
PR3	04/06/26	AB	REVISED FOLLOWING KCC COMMENTS
REV	DATE	BY	DETAILS

STATUS
PRELIMINARY. NOT TO BE USED FOR ANY OTHER PURPOSE.

CLIENT
KILKENNY COUNTY COUNCIL

PROJECT
GLENMORE BUS STOP RELOCATION

TITLE
DRAINAGE GENERAL LAYOUT AND DETAILS

KILGALLEN & PARTNERS
CONSULTING ENGINEERS
E-mail: Info@kilgallen.ie, Web: www.kilgallen.ie

KYLEUPROE
WELL ROAD
PORTLADISE
T +353 56 866 2860

UNIT 3
DANVILLE BUSINESS PARK
KILKENNY
+353 56 777 01090

DRN: AB	DRAWING NO.: 25024-B5-DR-0501	REV: PR5
CHWD: RK	SCALE: AS SHOWN @ A1	SIZE: A1
	DATE: 17/07/2026	