


© COPYRIGHT OF THIS DRAWING IS RESERVED BY DBFL CONSULTING ENGINEERS. NO PART SHALL BE REPRODUCED OR TRANSMITTED WITHOUT THEIR WRITTEN PERMISSION.

NO CHANGES OF WHATSOEVER NATURE ARE TO BE MADE TO ANY DETAILS SET OUT OR CONTAINED IN ANY DBFL SPECIFICATIONS OR DRAWINGS UNLESS THE EXPRESS CONSENT HAS BEEN OBTAINED IN ADVANCE, IN WRITING, FROM DBFL.

- NOTES:
- LEGEND:
- INDICATIVE PROPOSED FILTER DRAIN
 - SURFACE RUN OFF
 - PROPOSED ROYAL CANAL GREENWAY

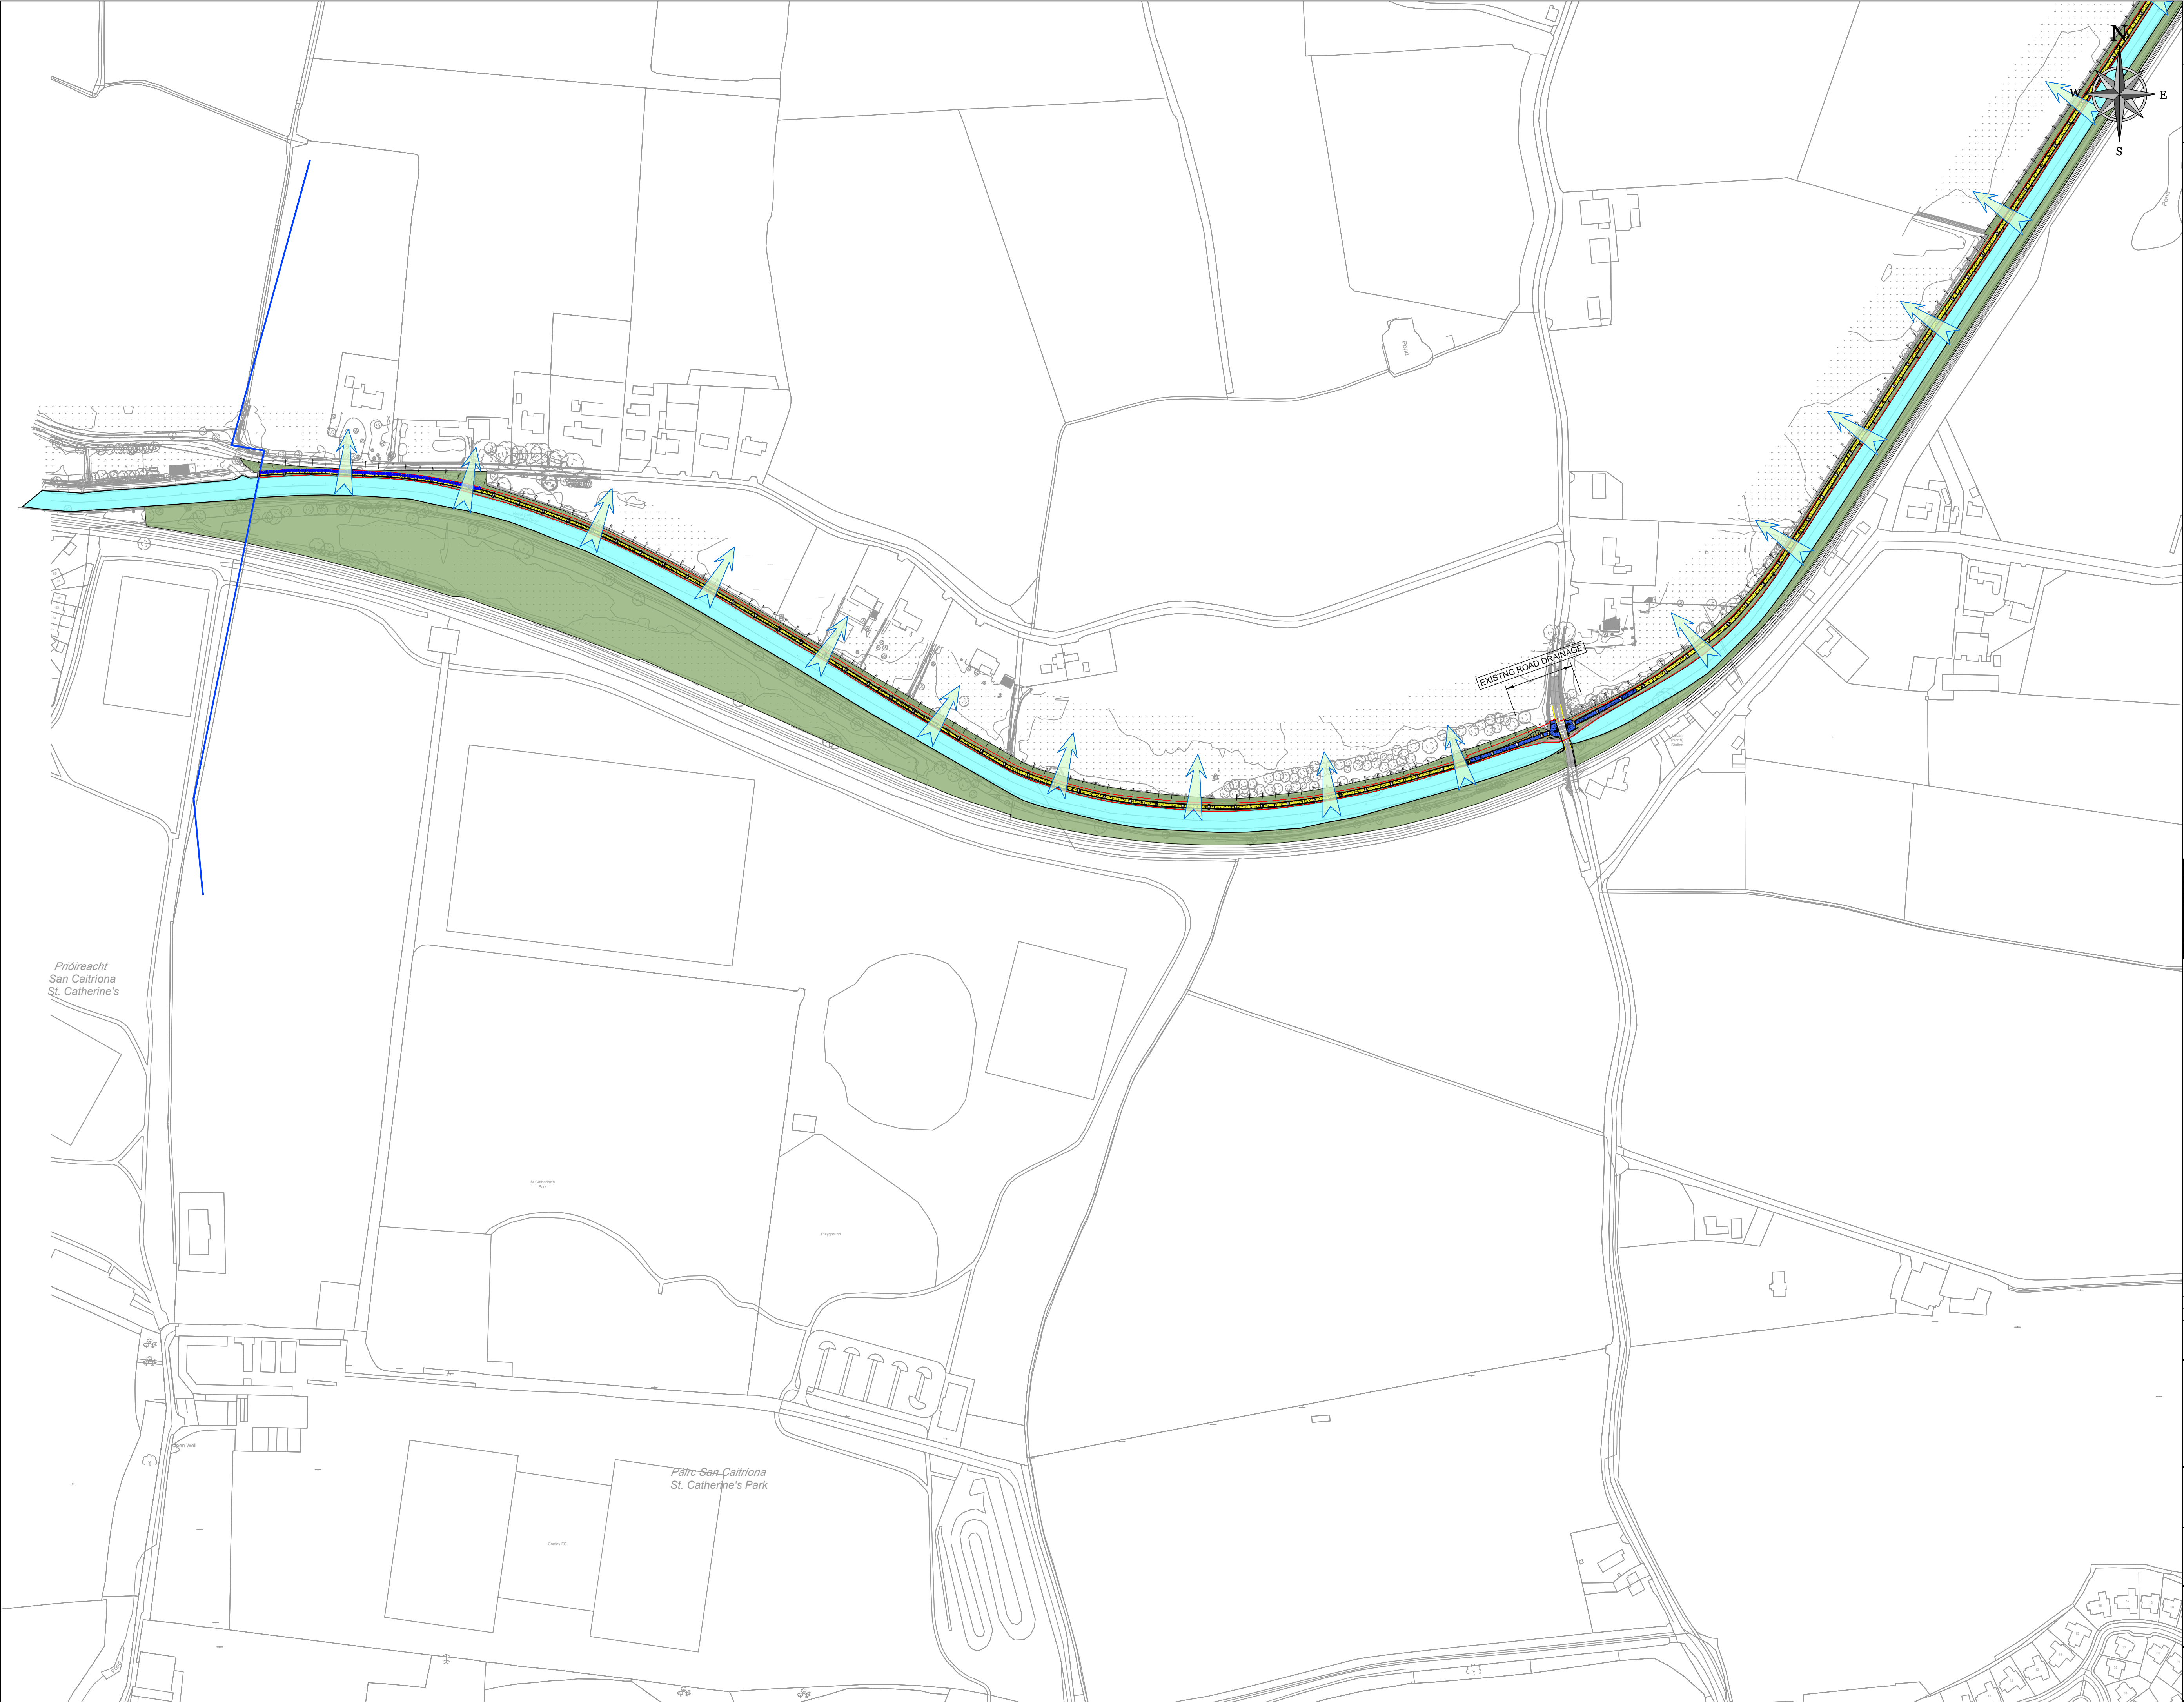

ORDNANCE SURVEY IRELAND LICENCE
No EN CYAL50276885 © ORDNANCE
SURVEY IRELAND GOVERNMENT OF
IRELAND

0	30-09-26	PLANNING ISSUE	VDK	MK
rev	date	description	by	chkd.
STATUS CODES				
purpose	acceptance			
P3 - PLANNING PERMISSION	S - ISSUED			
DBFL CONSULTING ENGINEERS				
T: + 353 1 400 4000 E: info@dbfl.ie W: www.dbfl.ie				
DUBLIN CORK GALWAY WATERFORD				
project ref.				
ROYAL CANAL URBAN GREENWAY				
drawing title				
DRAINAGE LAYOUT - SHEET 1				
client				
FINGAL COUNTY COUNCIL				
designed by	author	scale	sheet size	
MK	JP	1:2250	A1	
drawing no.	revision			
170239-X-05-X-XXX-DR-DBFL-CE-1301	0			