


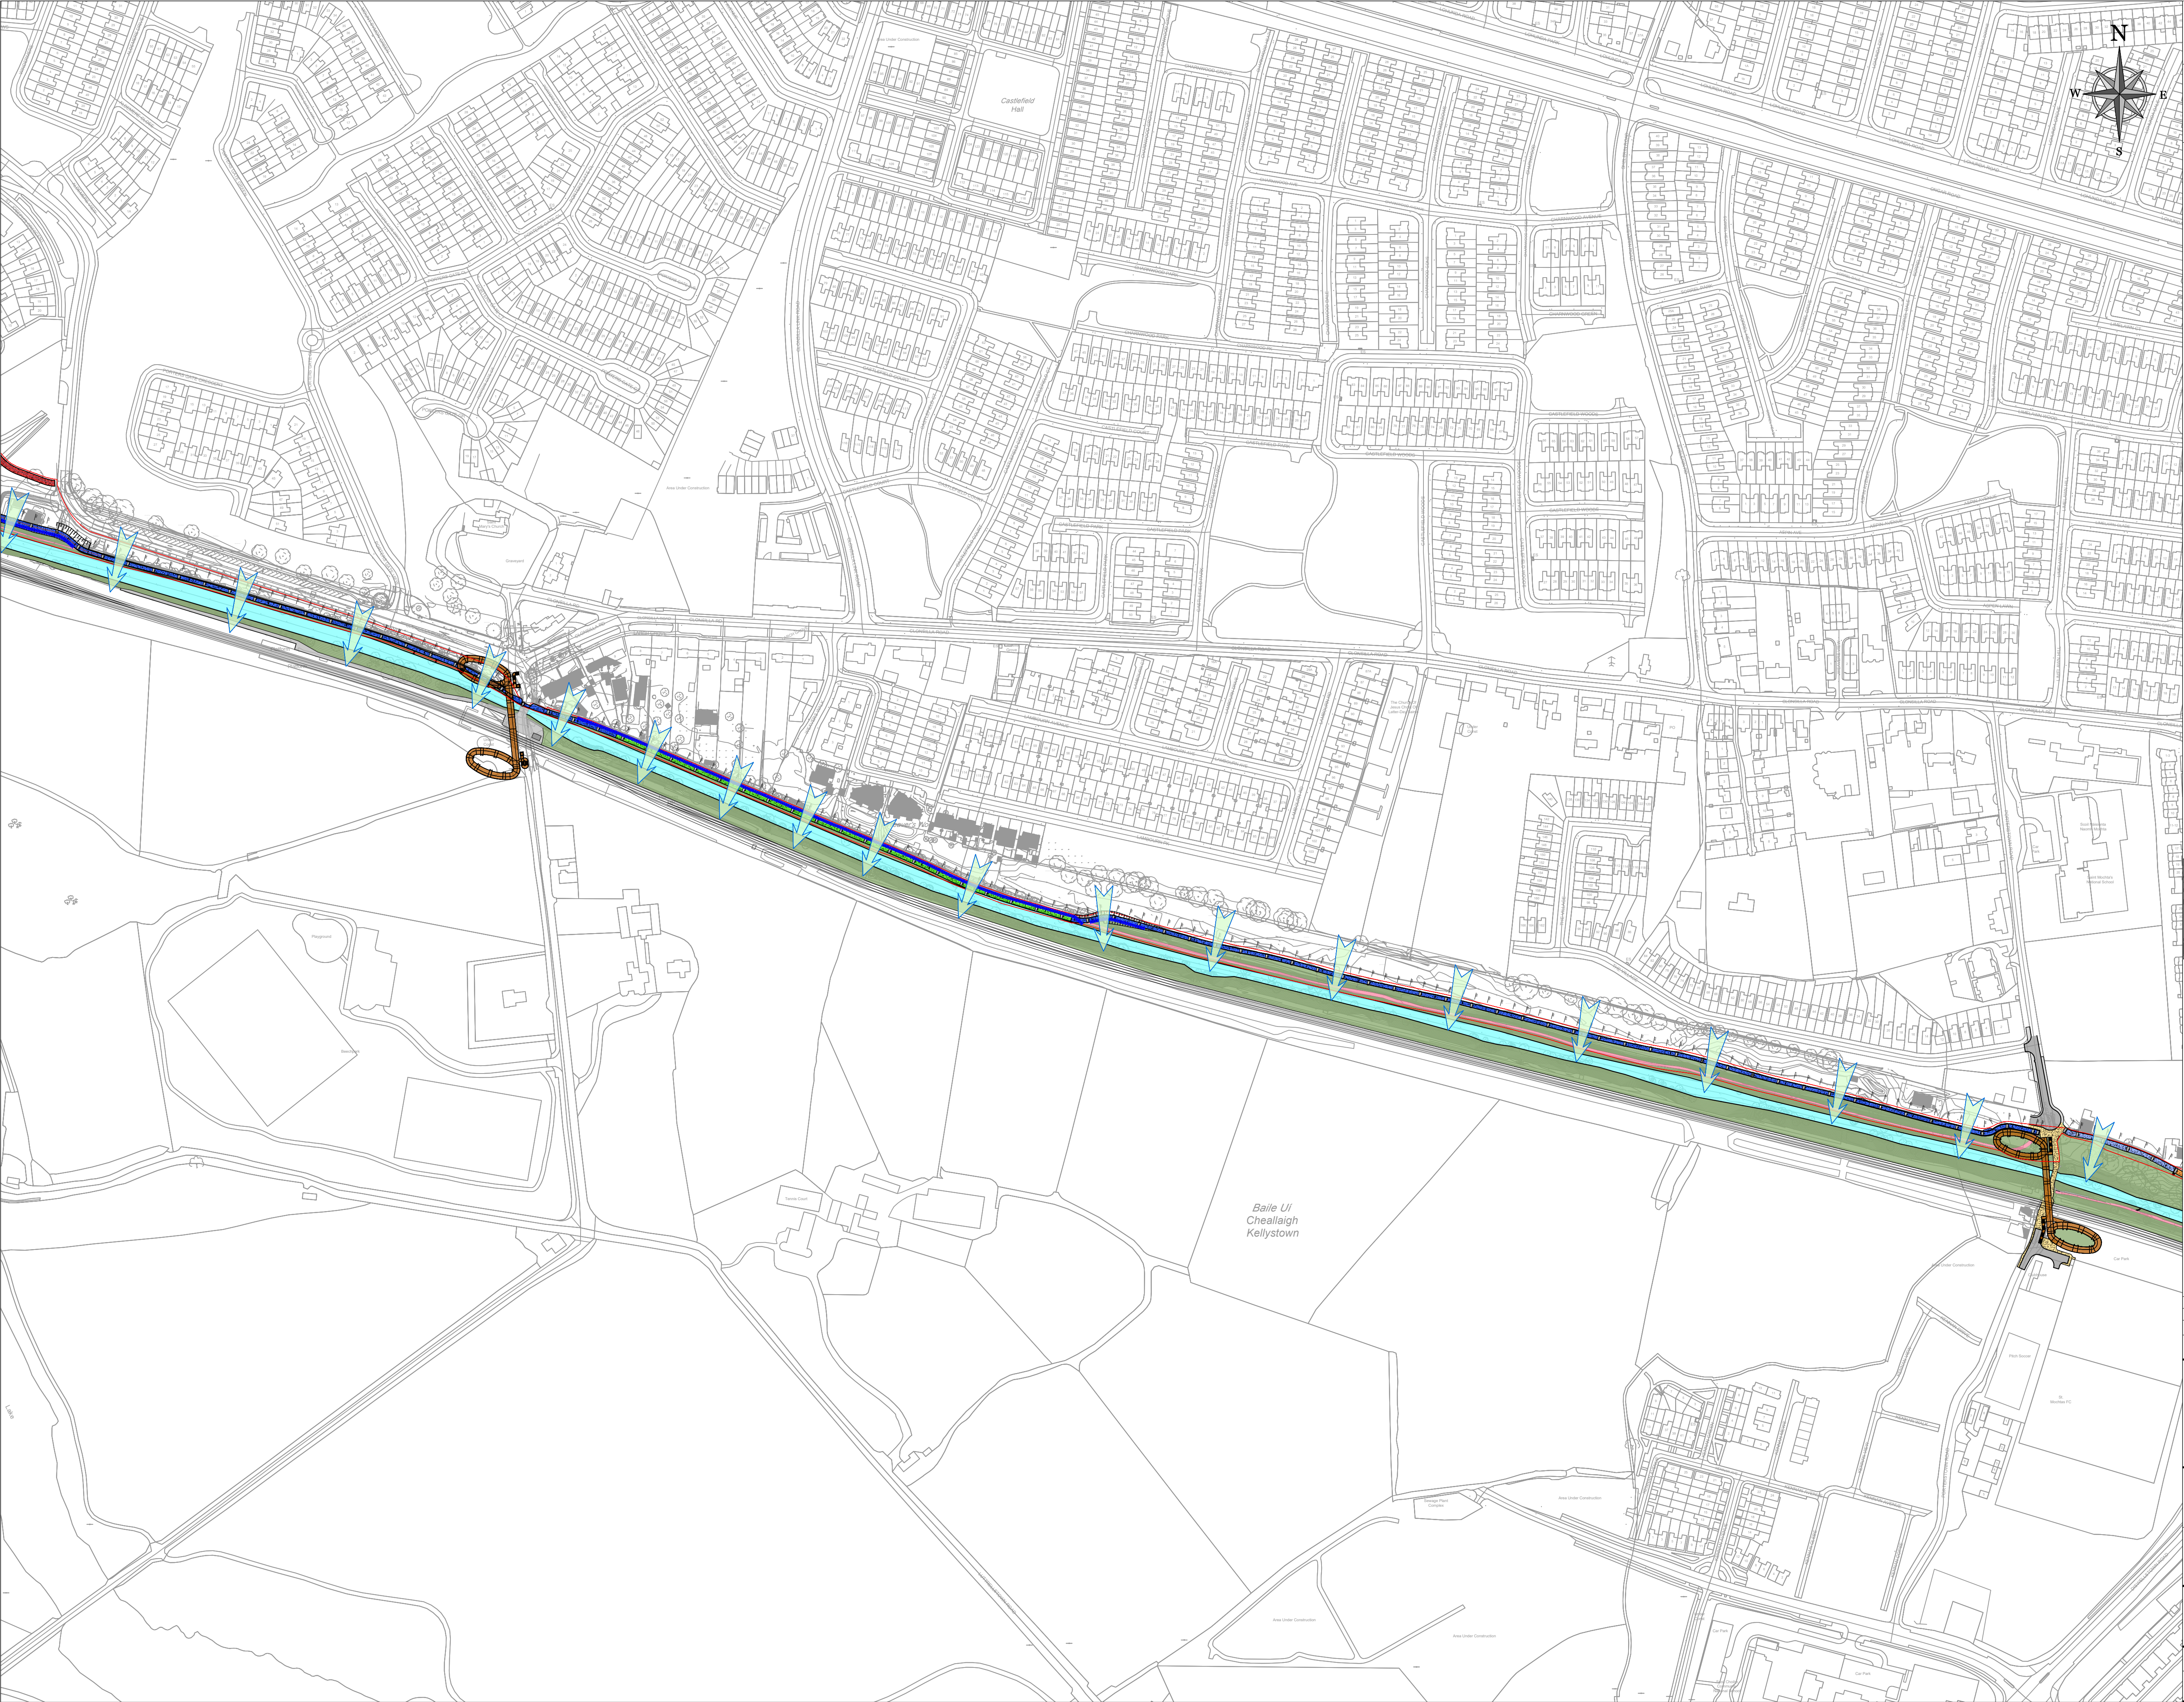

ON ORIGINAL

051020304050mm

© COPYRIGHT OF THIS DRAWING IS RESERVED BY DBFL CONSULTING ENGINEERS. NO PART SHALL BE REPRODUCED OR TRANSMITTED WITHOUT THEIR WRITTEN PERMISSION.

NO CHANGES OF WHATSOEVER NATURE ARE TO BE MADE TO ANY DETAILS SET OUT OR CONTAINED IN ANY DBFL SPECIFICATIONS OR DRAWINGS UNLESS THE EXPRESS CONSENT HAS BEEN OBTAINED IN ADVANCE, IN WRITING, FROM DBFL.

NOTES:

LEGEND:

INDICATIVE PROPOSED FILTER DRAIN

SURFACE RUN OFF

PROPOSED ROYAL CANAL GREENWAY

KEYPLAN:

12345

ORDNANCE SURVEY IRELAND LICENCE
No EN CYAL50276885© ORDNANCE
SURVEY IRELAND GOVERNMENT OF
IRELAND

0	30-09-26	PLANNING ISSUE		VOK	MK
rev	date		description	by	chkd.
STATUS CODES					
purpose			acceptance		
P3 - PLANNING PERMISSION			S - ISSUED		

DBFL

CONSULTING ENGINEERS

T: + 353 1 400 4000 | E: info@dbfl.ie | W: www.dbfl.ie

DUBLIN | CORK | GALWAY | WATERFORD

project ref:

ROYAL CANAL URBAN GREENWAY

drawing title:

DRAINAGE LAYOUT - SHEET 3

client:

FINGAL COUNTY COUNCIL

designed by	author	scale	sheet size
MK	JP	1:2250	A1

drawing no.	revision
170239-X-05-X-XXX-DR-DBFL-CE-1303	0