


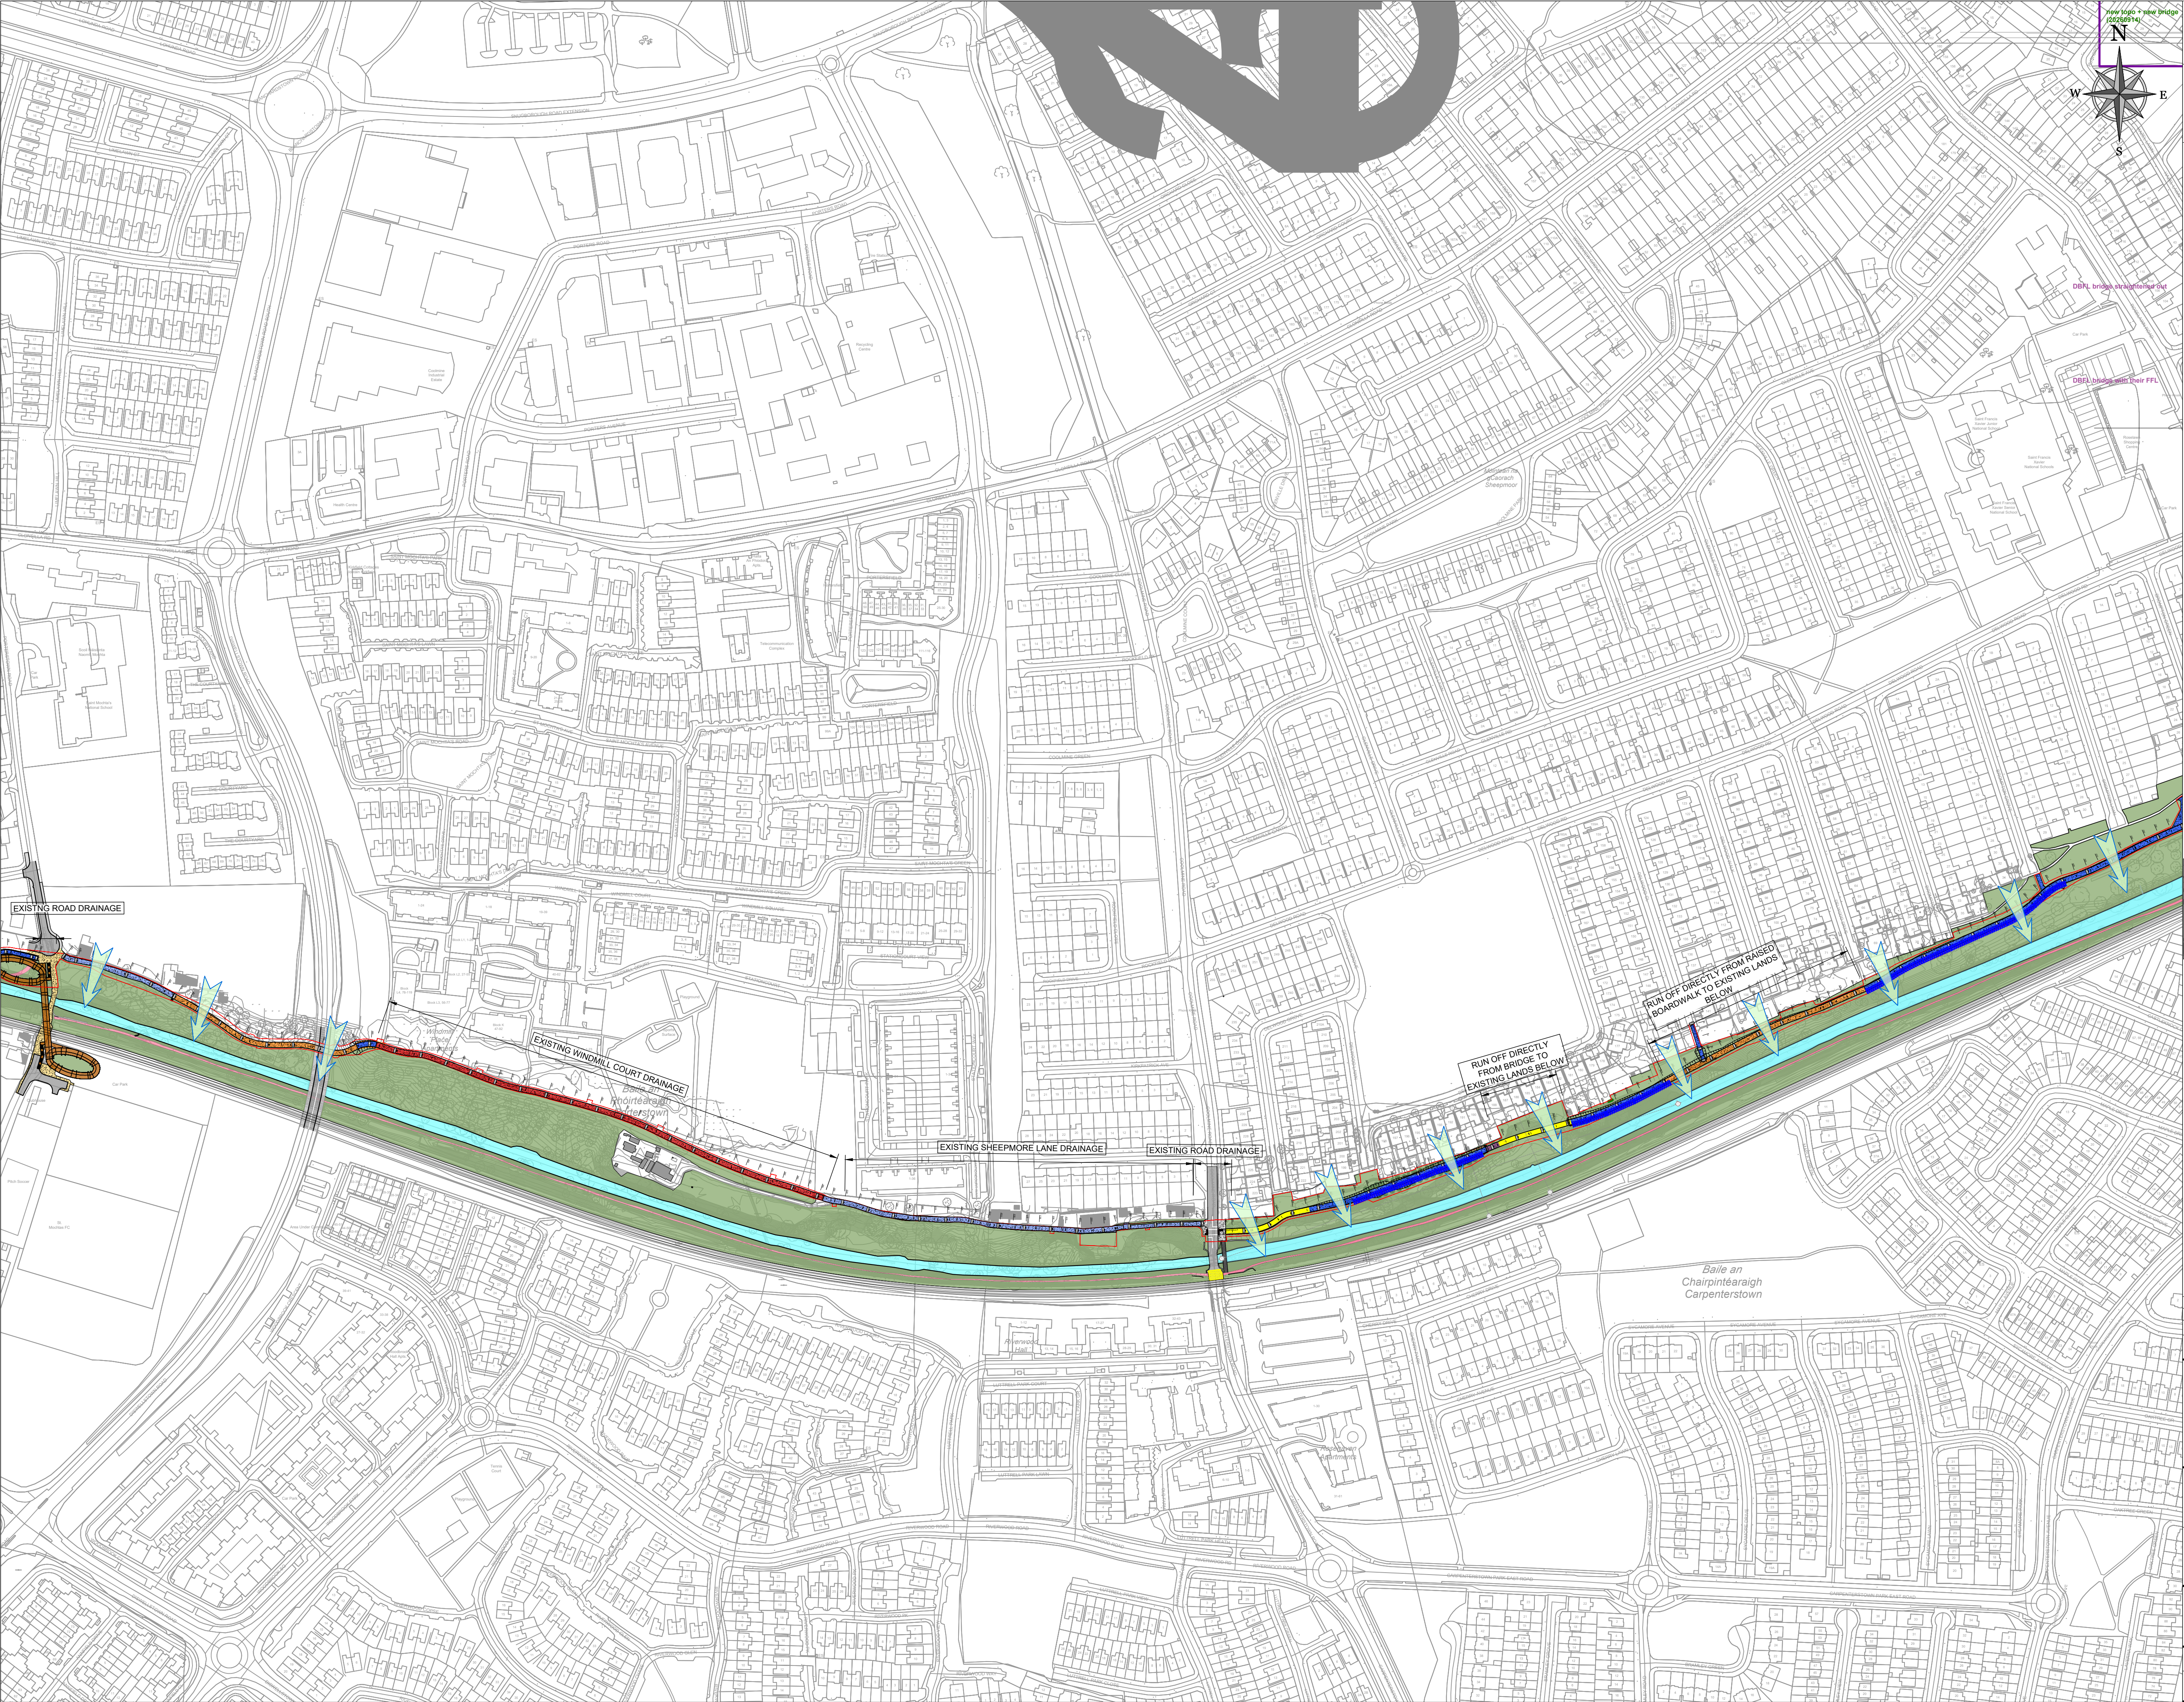

0 5 10 20 30 40 50mm

ON ORIGINAL

© COPYRIGHT OF THIS DRAWING IS RESERVED BY DBFL CONSULTING ENGINEERS. NO PART SHALL BE REPRODUCED OR TRANSMITTED WITHOUT THEIR WRITTEN PERMISSION.

NO CHANGES OF WHATSOEVER NATURE ARE TO BE MADE TO ANY DETAILS SET OUT OR CONTAINED IN ANY DBFL SPECIFICATIONS OR DRAWINGS UNLESS THE EXPRESS CONSENT HAS BEEN OBTAINED IN ADVANCE, IN WRITING, FROM DBFL.

NOTES:

LEGEND:

INDICATIVE PROPOSED FILTER DRAIN

SURFACE RUN OFF

PROPOSED ROYAL CANAL GREENWAY

KEYPLAN:

1 2 3 4 5

ORDNANCE SURVEY IRELAND LICENCE
No EN CYAL50276885© ORDNANCE
SURVEY IRELAND GOVERNMENT OF
IRELAND

0	30-09-26	PLANNING ISSUE	VOK	MK
rev	date	description	by	chkd.
STATUS CODES				
purpose	acceptance			
P3 - PLANNING PERMISSION	S - ISSUED			

DBFL

CONSULTING ENGINEERS

T: +353 1 400 4000 | E: info@dbfl.ie | W: www.dbfl.ie

DUBLIN | CORK | GALWAY | WATERFORD

project ref.

ROYAL CANAL URBAN GREENWAY

drawing title

DRAINAGE LAYOUT - SHEET 4

client

FINGAL COUNTY COUNCIL

designed by	author	scale	sheet size
MK	JP	1:2250	A1
drawing no.	revision		
170239-X-05-X-XXX-DR-DBFL-CE-1304			0