
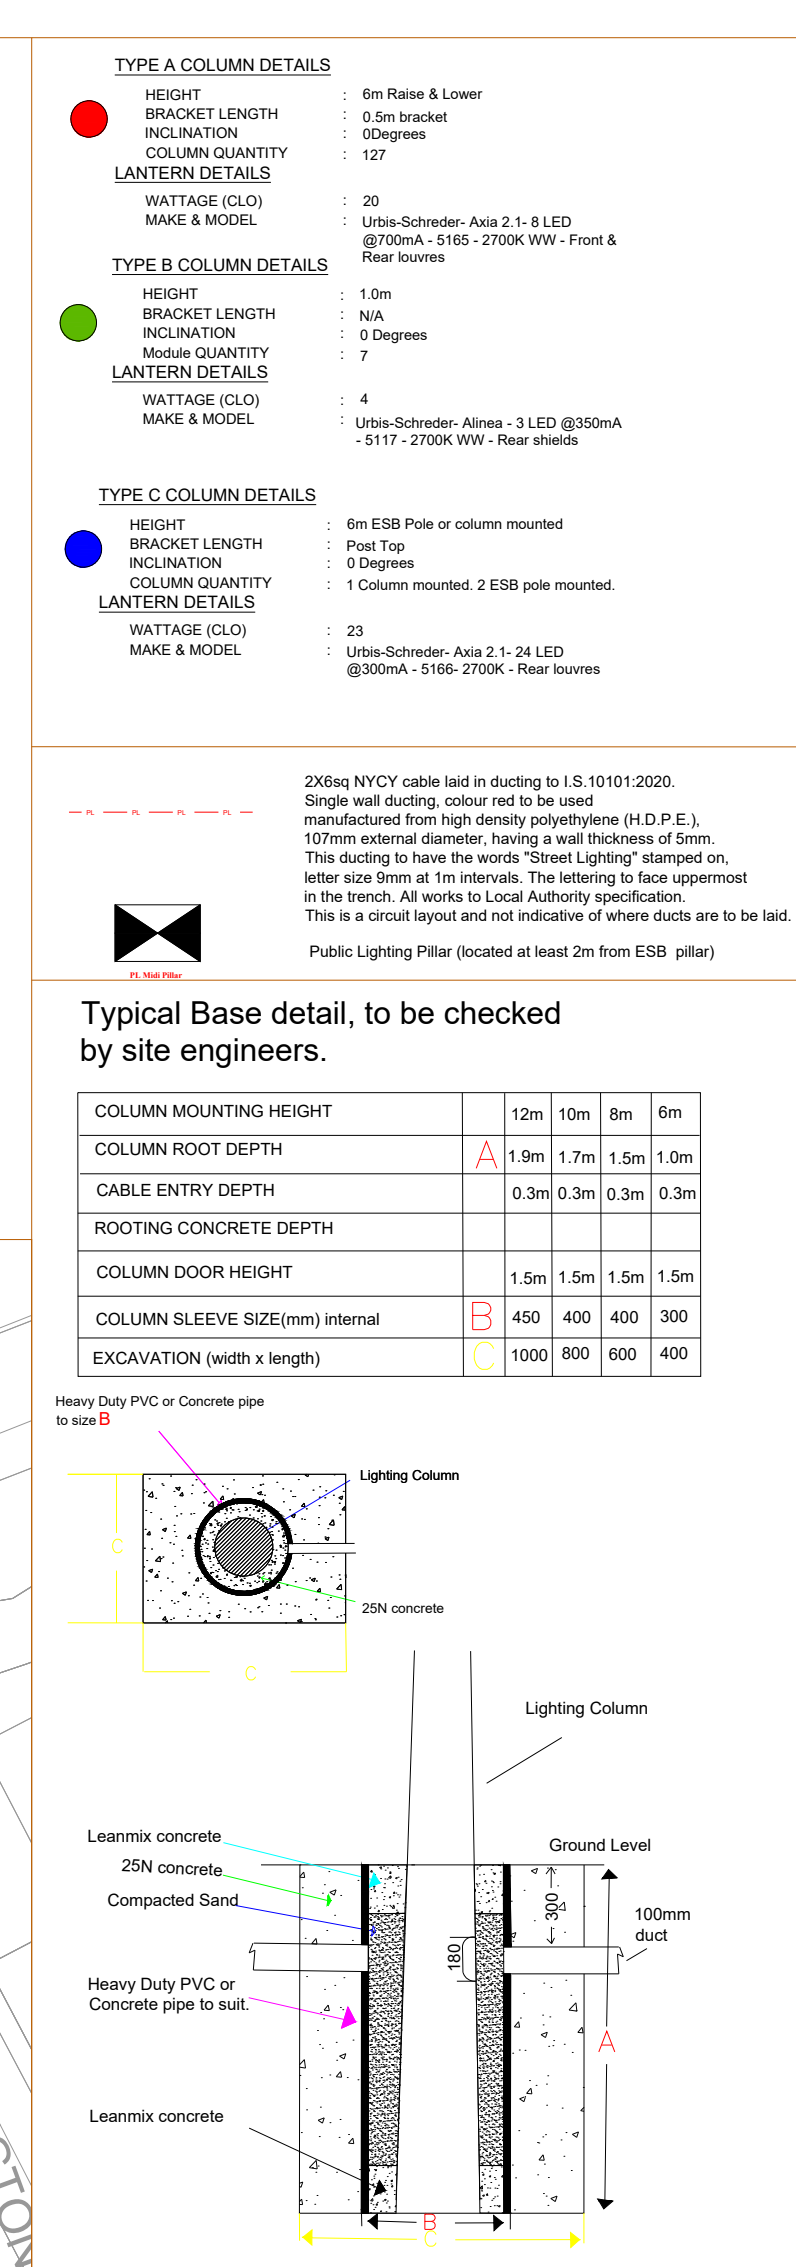


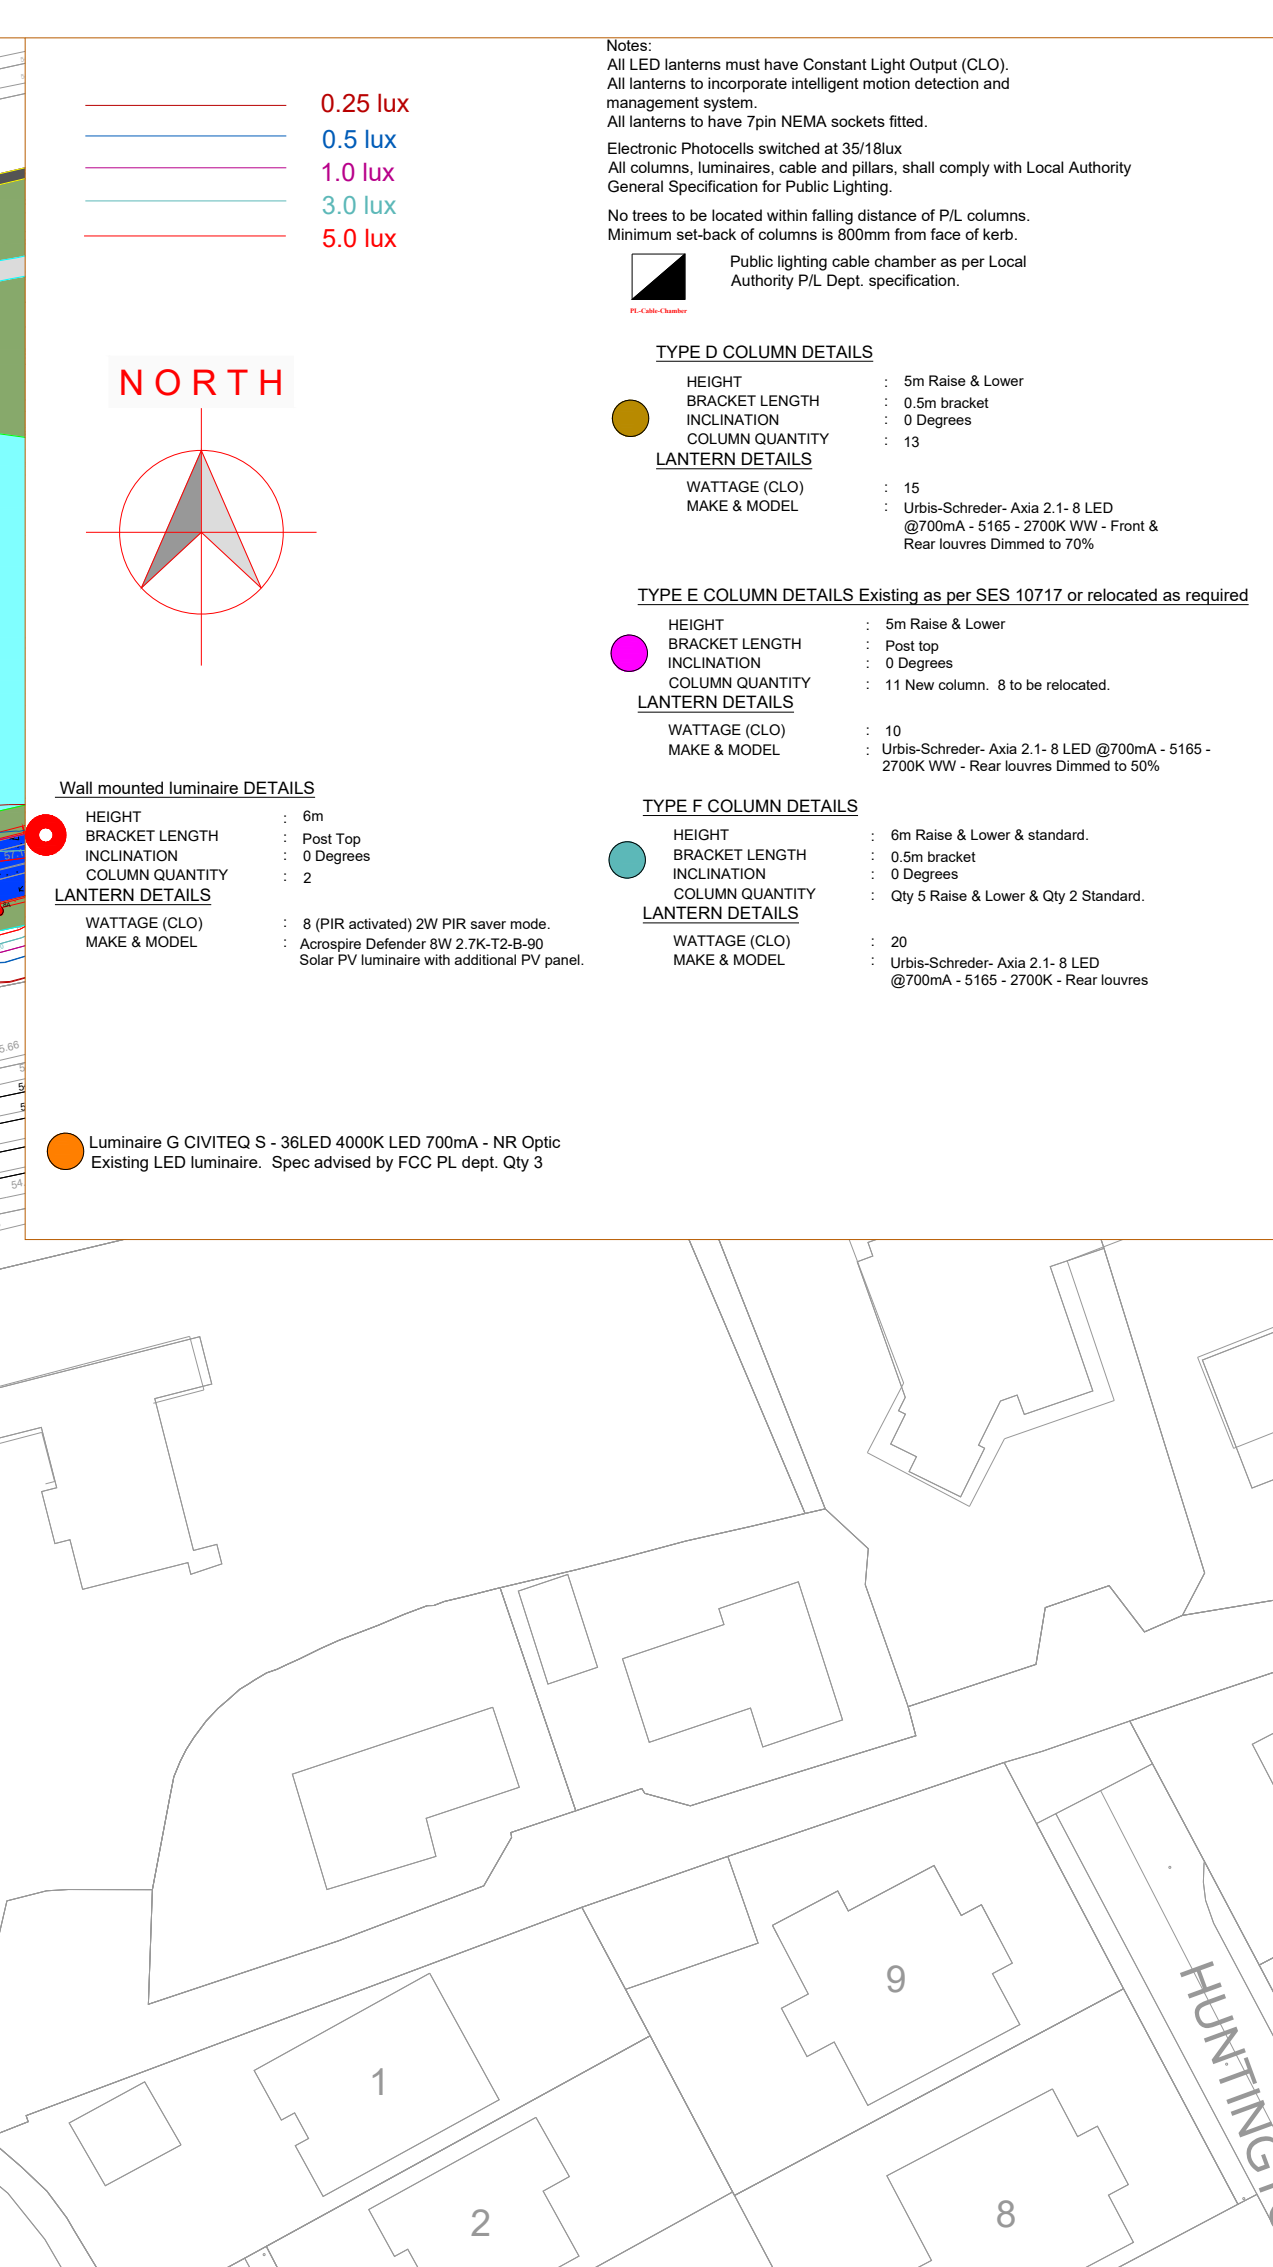

NOTES

THIS DRAWING IS THE INTELLECTUAL PROPERTY OF **Sabre** LIGHTING DESIGN GROUP AND IS COPYRIGHT © AND CAN NOT BE USED WITHOUT PRIOR CONSENT.

NO ACCOUNT IS TAKEN FOR THE BLOCKING EFFECT CAUSED BY BUILDINGS, TREES ETC. THE CALCULATION SHOWN BY THIS DRAWING ASSUMES THAT THE WHOLE AREA BEING CONSIDERED IS IN THE SAME PLANE, I.E. THERE ARE NO CHANGES IN GRADIENT OR ELEVATION.

This drawing layout is based on calculated lighting levels, produced by Sabre Electrical Services Ltd., using Lightplan Reality software. Any alterations to the layout or luminaire type used for the lighting design calculations, will require a revised lighting design to be carried out. A redesign may require approval from the Local Authority Public Lighting Dept, prior to any alterations/modifications being implemented on site.

ELECTRICAL SERVICES LTD.

Specialist Contractors

PUBLIC LIGHTING - FLOOD LIGHTING - SPORTS LIGHTING

UNIT 11,
BELLVUE INDUSTRIAL ESTATE,
FINGLAS,
DUBLIN 11.
E - MAIL: graham@sabrelighting.ie

PH: 01-811 0875

I	Crossing added at Mallowtown Rd	AN	CHK	14-08
J	Additional luminaires updated at crossing points.	ANN	CHK	03-09-26
		AN	CHK	
		AN	CHK	
		AN	CHK	
		AN	CHK	
		AN	CHK	

REV	DESCRIPTION	INITS	CHK'D	DATE
-----	-------------	-------	-------	------

CLIENT/CUSTOMER

DBFL

PROJECT

Royal Canal Greenway CH 3200-CH8100

TITLE

Public Lighting Layout

DRAWN A.N	SCALE 1:500 @A1	DATE 06-07-22
--------------	--------------------	------------------

DRAWING NUMBER SES 08322 Sheet 2	ISSUE 10
-------------------------------------	-------------

BASE DRAWING NUMBER

DRAWING ORIGIN **DBFL**

DO NOT SCALE FROM THIS DRAWING