

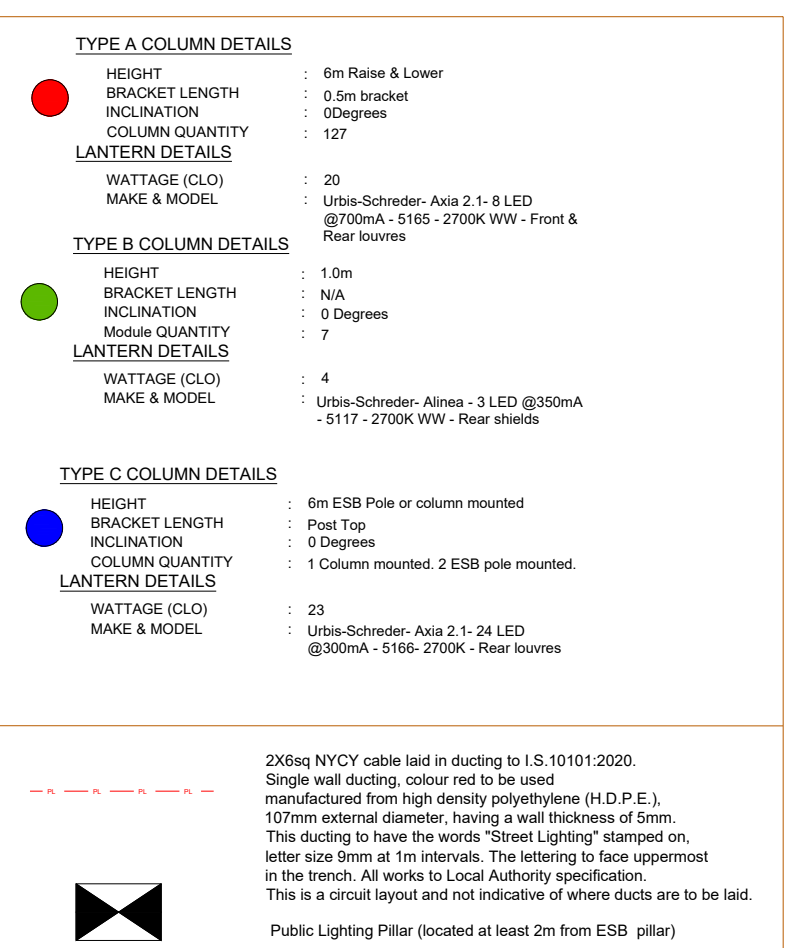
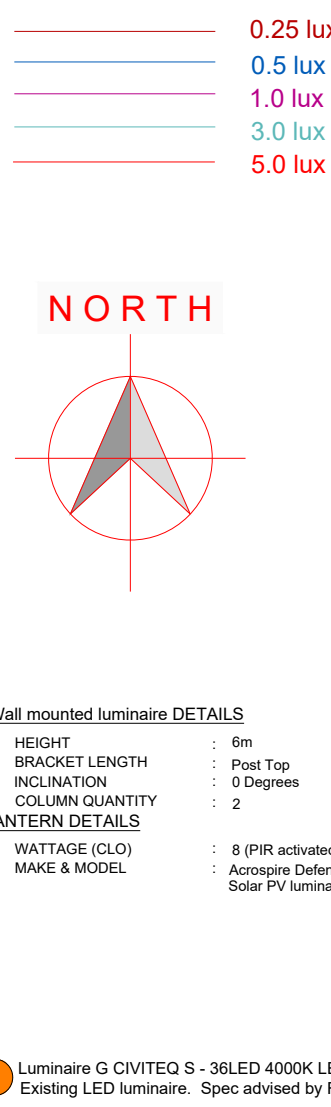


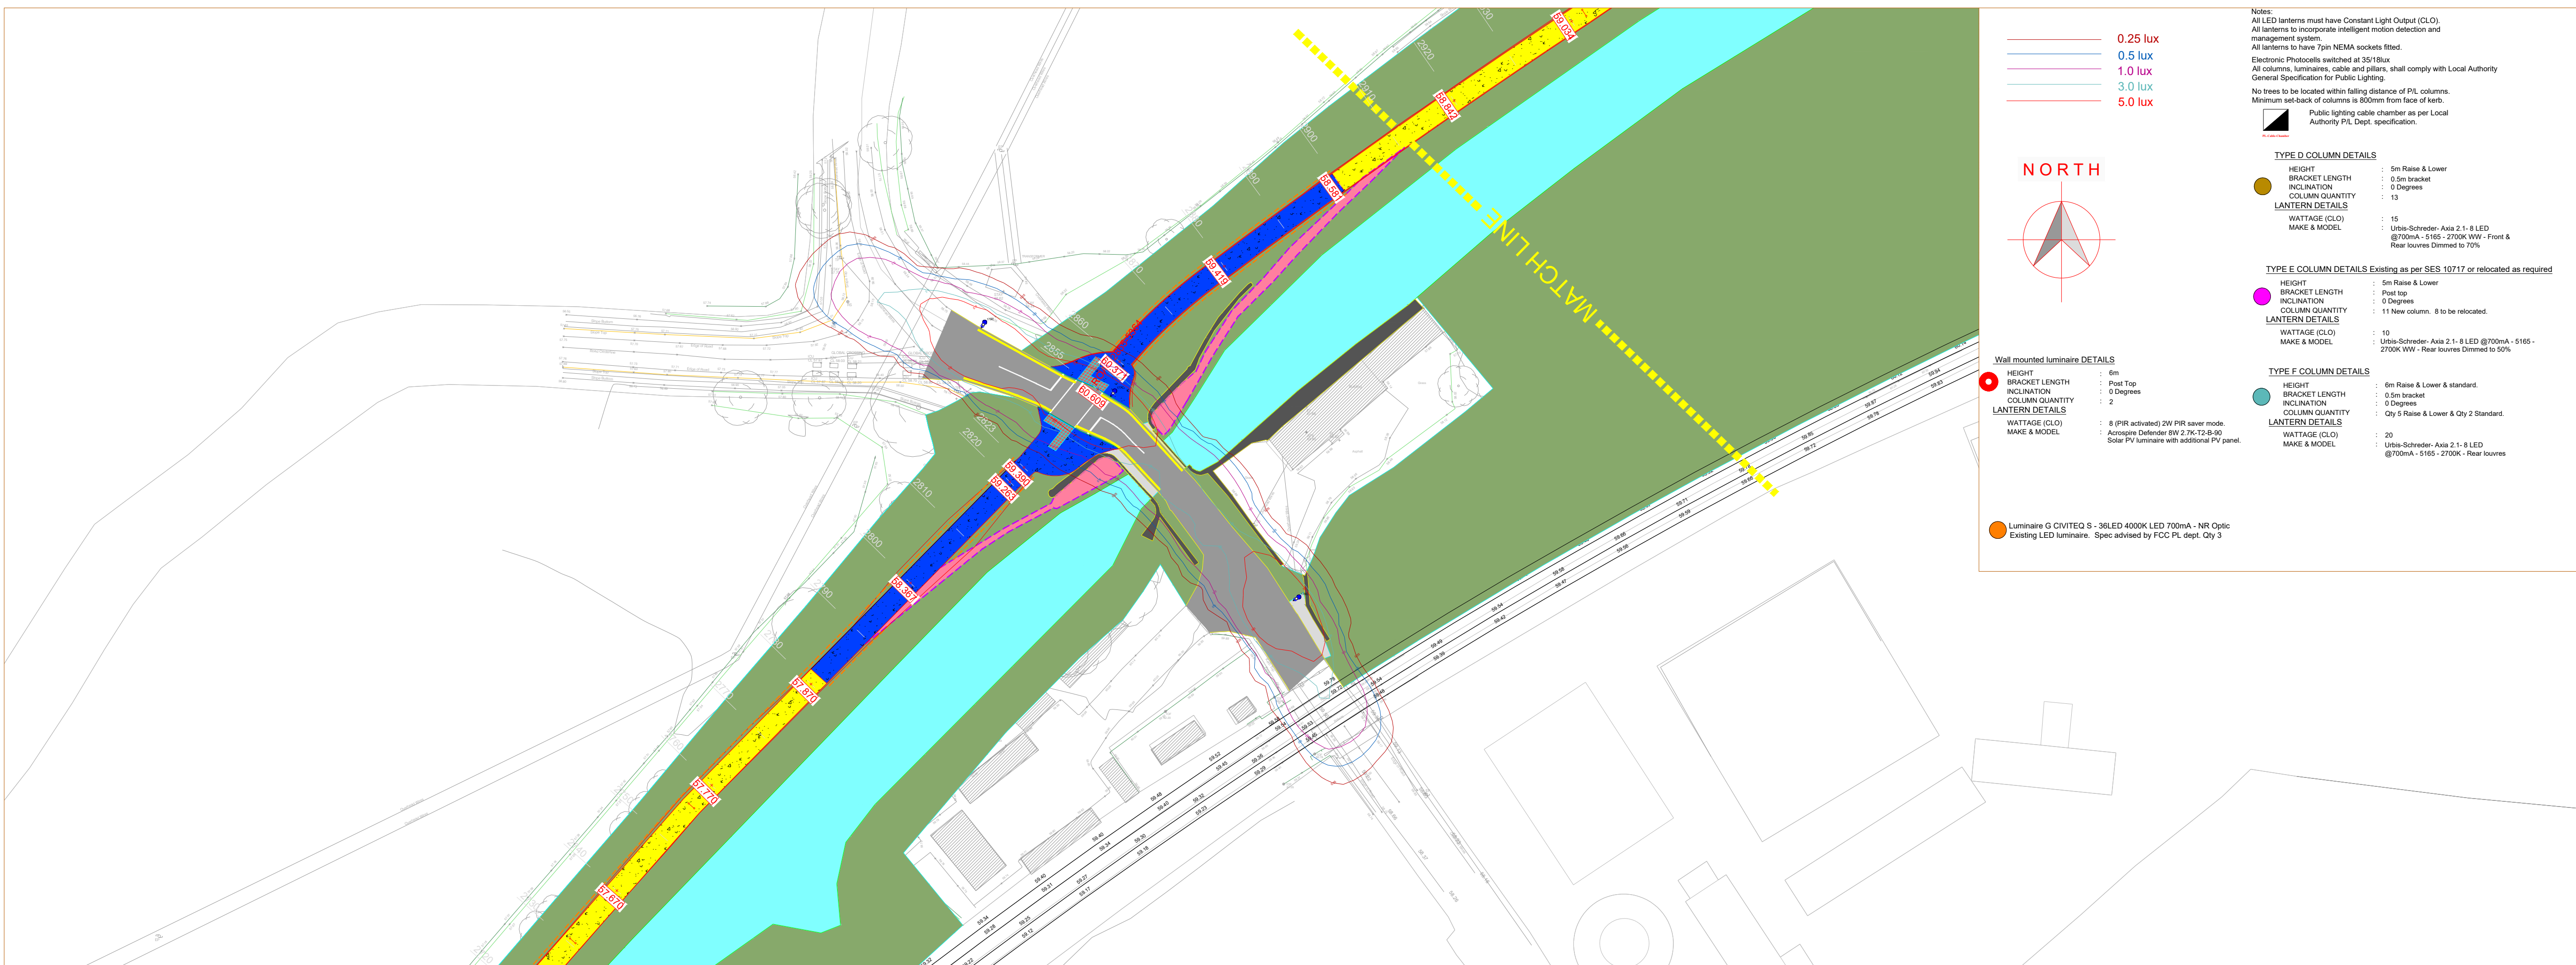

Typical Base detail, to be checked by site engineers.

COLUMN MOUNTING HEIGHT	12m	10m	8m	6m
COLUMN ROOT DEPTH	1.9m	1.7m	1.5m	1.0m
CABLE ENTRY DEPTH	0.3m	0.3m	0.3m	0.3m
ROOTING CONCRETE DEPTH				
COLUMN DOOR HEIGHT	1.5m	1.5m	1.5m	1.5m
COLUMN SLEEVE SIZE(mm) internal	450	400	400	300
EXCAVATION (width x length)	1000	800	600	400

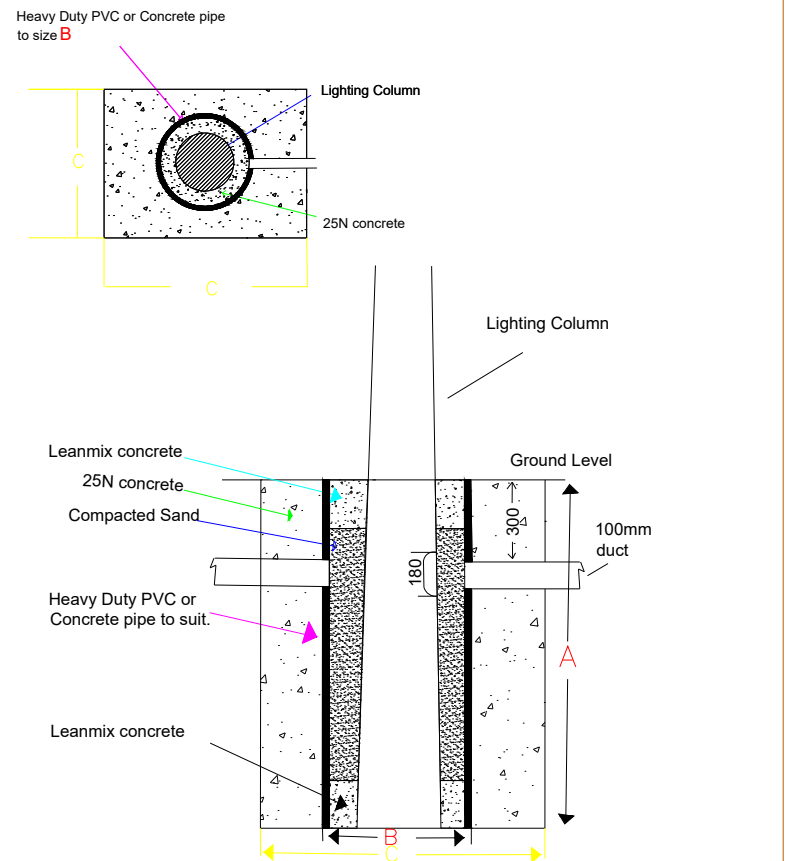

NOTES

THIS DRAWING IS THE INTELLECTUAL PROPERTY OF Sabre LIGHTING DESIGN DEPT. AND IS COPYRIGHT (C) AND CAN NOT BE USED WITHOUT PRIOR CONSENT.

NO ACCOUNT IS TAKEN FOR THE BLOCKING EFFECT CAUSED BY BUILDINGS, TREES ETC. THE CALCULATION SHOWN BY THIS DRAWING ASSUMES THAT THE WHOLE AREA BEING CONSIDERED IS IN THE SAME PLANE, I.E. THERE ARE NO CHANGES IN GRADIENT OR ELEVATION.

This drawing layout is based on calculated lighting levels, produced by Sabre Electrical Services Ltd., using Lighting Reality software. Any alterations to the layout or luminaire type used for the lighting design calculations, will require a revised lighting design to be carried-out. A redesign may require approval from the Local Authority Public Lighting Dept. prior to any alterations/modifications being implemented on site.

Sabre

ELECTRICAL SERVICES LTD.

Specialist Contractors

PUBLIC LIGHTING - FLOOD LIGHTING - SPORTS LIGHTING

UNIT 11,
BELLVUE INDUSTRIAL ESTATE,
FINGLAS,
DUBLIN 11.
E - MAIL: graham@sabrelighting.ie PH: 01-811 0875

I	Crossing added at Milltown Rd	AN	CHK	14-08-26
J	Additional luminaires updated at crossing points.	AN	CHK	03-09-26
			CHK	
			CHK	
			CHK	
			CHK	
			CHK	

REV	DESCRIPTION	INITS	CHKD	DATE
-----	-------------	-------	------	------

CLIENT/CUSTOMER

DBFL

PROJECT

Royal Canal Greenway CH 3200-CH8100

TITLE

Public Lighting Layout

DRAWN

A.N

SCALE

1:500 @A1

DATE

06-07-22

DRAWING NUMBER

SES 08322 Sheet 9

ISSUE

10

BASE DRAWING NUMBER

DBFL

DRAWING ORIGIN

DBFL

DO NOT SCALE FROM THIS DRAWING

