



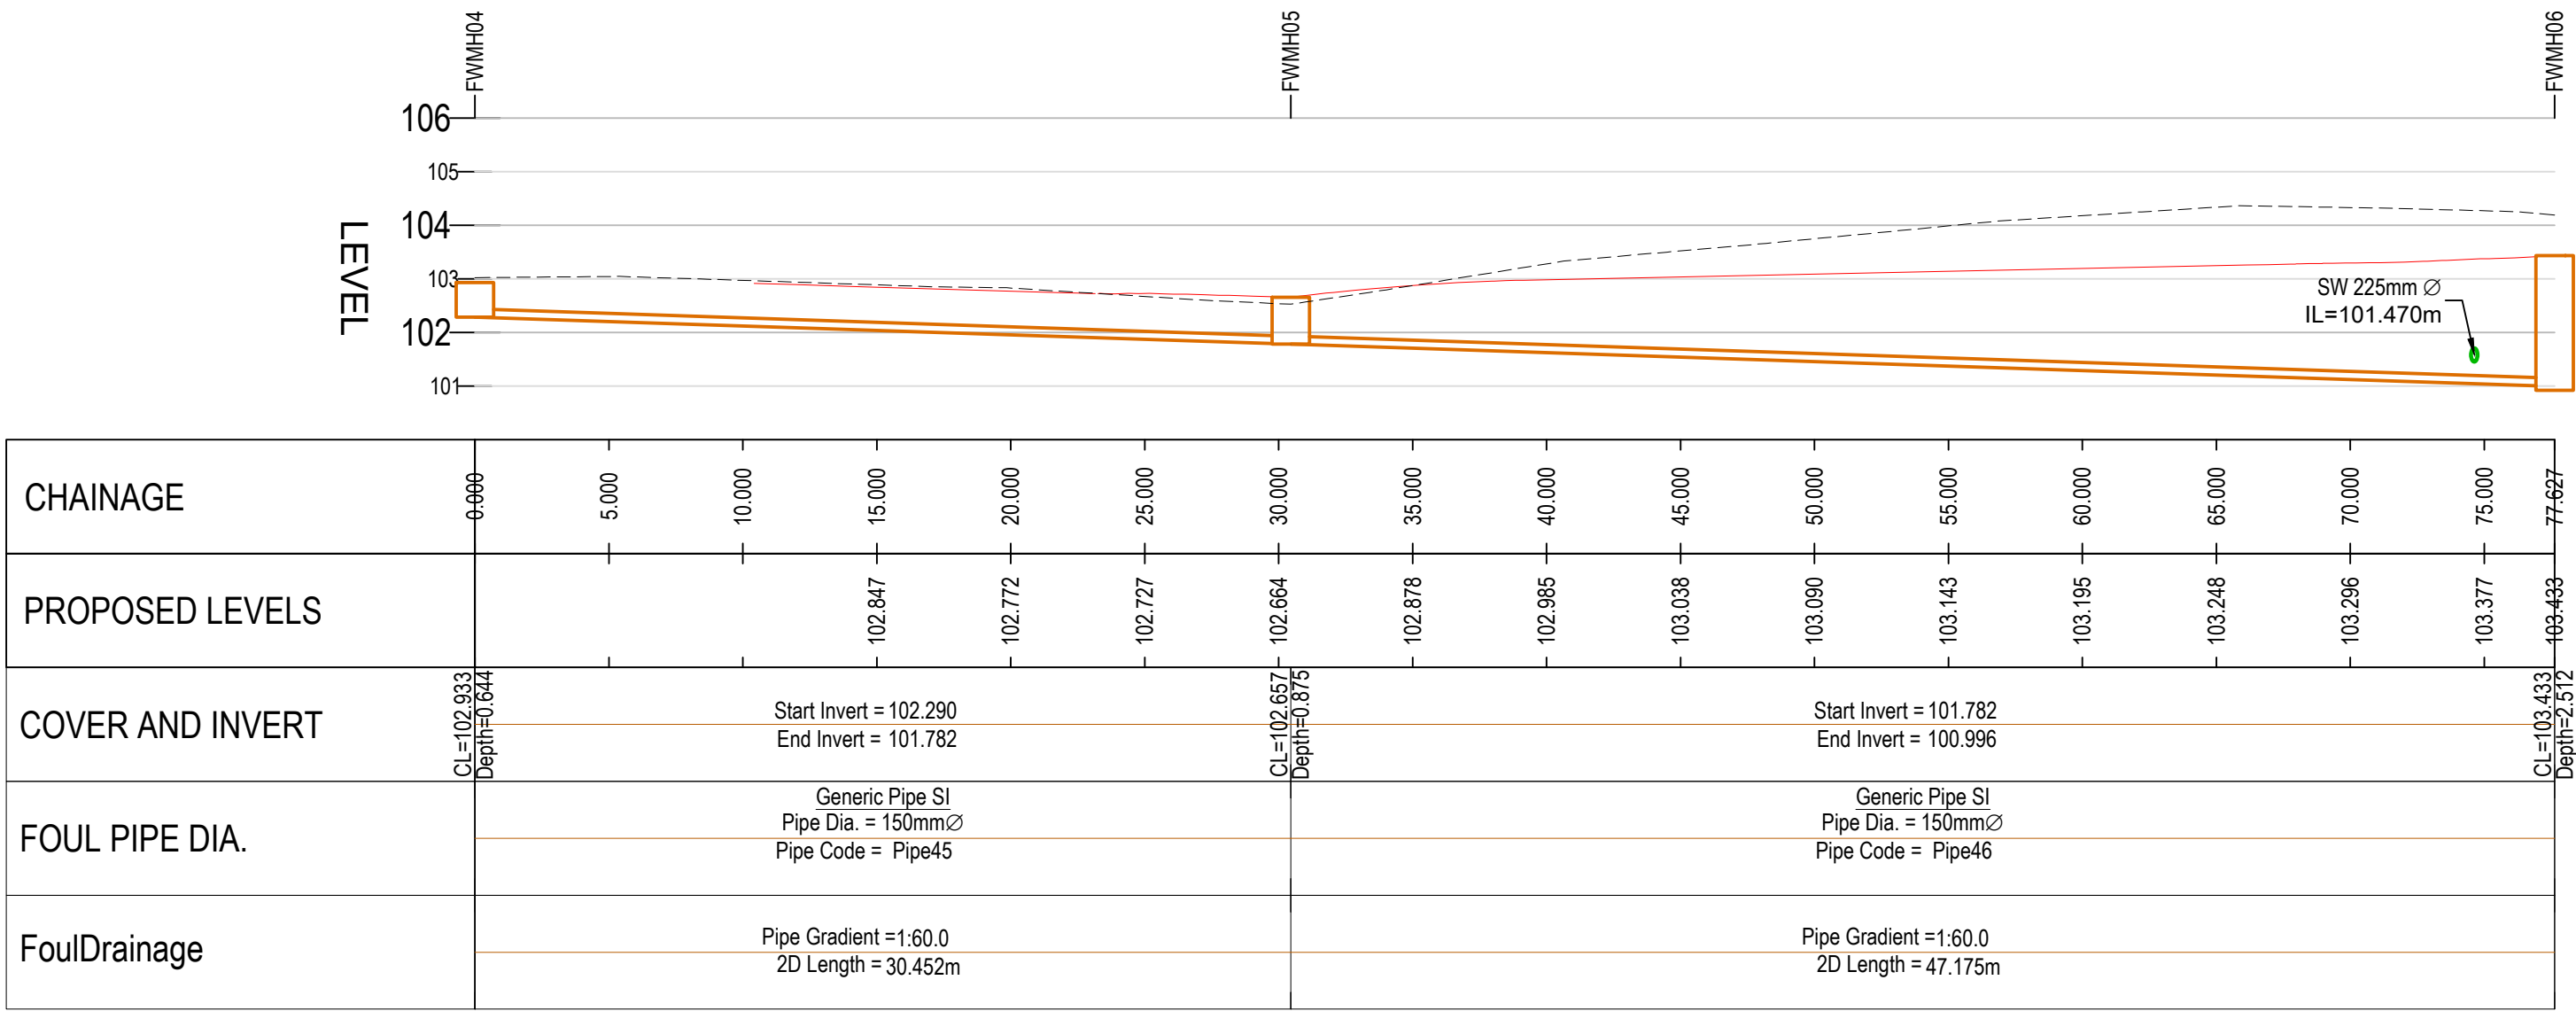

FWMH04-FWMH06 - LONGSECTION
SCALE: H 1:500,V 1:250. DATUM: 100.000

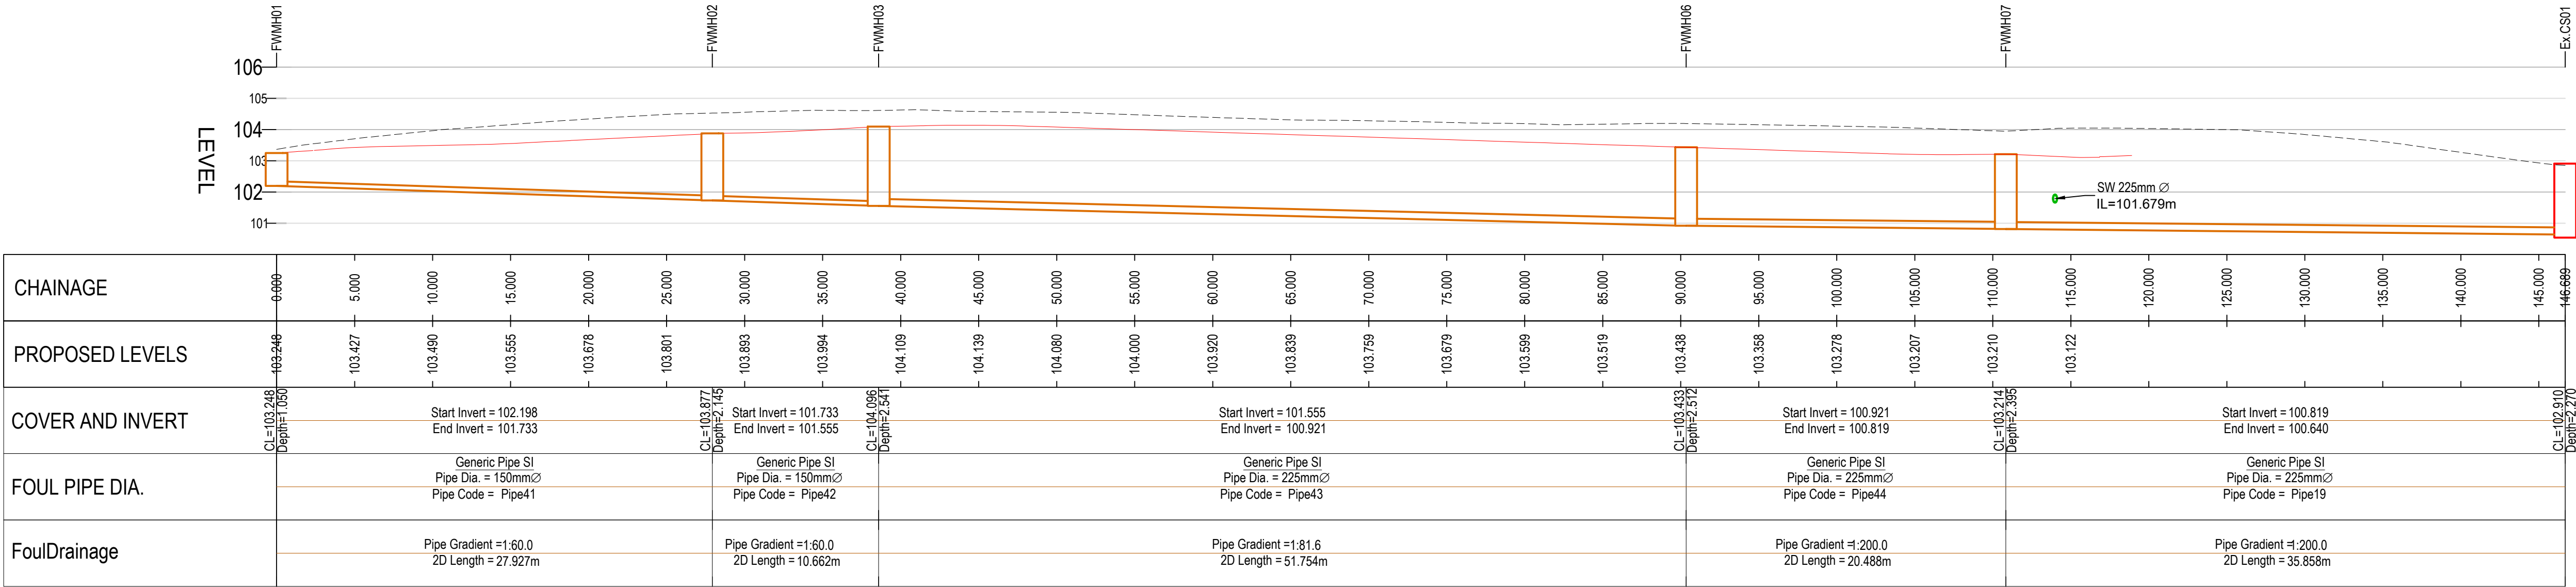

FWMH01-Ex.CS01 - LONGSECTION
SCALE: H 1:500,V 1:250. DATUM: 100.000

DRAWING REFERENCES

FOR PROPOSED DRAINAGE LAYOUT, REFER TO DRG
G09900-WRD-EX-ZZ-DR-C-50001.

FOR DRAINAGE DETAILS, SHEET 1, REFER TO DRG
G09900-WRD-EX-ZZ-DR-C-50011.

FOR DRAINAGE DETAILS, SHEET 2, REFER TO DRG
G09900-WRD-EX-ZZ-DR-C-50012.

FOR DRAINAGE DETAILS, SHEET 3, REFER TO DRG
G09900-WRD-EX-ZZ-DR-C-50013.

FOR MANHOLE SCHEDULES, REFER TO DRG
G09900-WRD-EX-ZZ-DR-C-50002.

GENERAL NOTES

- DO NOT SCALE FROM THIS DRAWING - IF IN DOUBT CONTACT PROJECT ENGINEER.
- ALL DIMENSIONS ARE IN METRES UNLESS STATED OTHERWISE.
- ALL LEVELS AND COORDINATES ARE IN METRES REFERENCED TO IRISH TRANSVERSE MERCATOR GRID (ITM)
- THIS DRAWING IS TO BE READ IN CONJUNCTION WITH ALL RELEVANT ARCHITECTURAL, STRUCTURAL AND SERVICES DRAWINGS
- THE CONTRACTOR IS TO VERIFY ALL DIMENSIONS ON SITE AND IS RESPONSIBLE FOR ACCURATE SETTING OUT.
- THE CONTRACTOR IS TO CONFIRM THE EXISTING BOUNDARY AND SITE STRUCTURES ETC. PRIOR TO COMMENCING THE WORKS AND IMMEDIATELY INFORM THE SUPERVISING OFFICER SHOULD THESE BE AT VARIANCE WITH THE ASSUMPTIONS SHOWN ON THE DRAWING.

ALL DIMENSIONS SHOWN ON THIS DRAWING ARE TO BE VERIFIED BY THE ARCHITECT PRIOR TO FABRICATION / MANUFACTURE / CONSTRUCTION

CONSTRUCTION (DESIGN AND MANAGEMENT) REGULATIONS 2015

THE DESIGNS ON THIS DRAWING ARE PREPARED WITH CONSIDERATION OF THE NEED TO IDENTIFY HAZARDS AND GIVE REGARD TO THEIR ELIMINATION OR MINIMISATION. REFERENCE MUST BE MADE TO HEALTH AND SAFETY INFORMATION PREPARED BY THE PRINCIPAL DESIGNER.

LEGEND

- DENOTES EXISTING GROUND LEVELS
- DENOTES PROPOSED GROUND LEVELS
- DENOTES FOUL SEWER
- DENOTES STORM SEWER

P02	TCC comments	13/07/26	AO	KD
P01	Issued for Planning	04/06/26	AO	ES
ISSUE	DETAILS	DATE	BY	CHK

STATUS:

PLANNING

Will Rudd

Will Rudd Davidson (Ireland)
Consulting Civil & Structural Engineers
South Point, Herbert House, Harmony Row,
Grand Canal Dock, Dublin D02 H120
T: 01 910 3278
E: dublin@ruddconsult.com
www.ruddconsult.com

CLIENT:
TIPPERARY COUNTY COUNCIL

PROJECT TITLE:
HOUSING DEVELOPMENT AT GLEAN CAOIN,
BORRISOLEIGH CO. TIPPERARY

DRG TITLE:
DRAINAGE LONGITUDINAL SECTIONS SHEET 02

DRAWN BY:	AO	DATE DRAWN:	29/05/2026
CHECKED BY:	ES	DATE CHECKED:	29/05/2026
SCALES:	AS NOTED	SHEET SIZE:	A1
PROJECT - ORIGINATOR - VOLUME - LEVEL - TYPE - ROLE - NUMBER			REV:
G09900 - WRD - EX - ZZ - DR - C - 50022			P02