



NOTE

MAINTENANCE RESPONSIBILITY OF THE WATER SERVICE CONNECTIONS FROM THE WATERMAIN TO THE BOUNDARY IS SET OUT IN THE PIPE MAINTENANCE RESPONSIBILITY DIAGRAMS INCLUDED ON THE IW WEBSITE @WWW.WATER.IE.

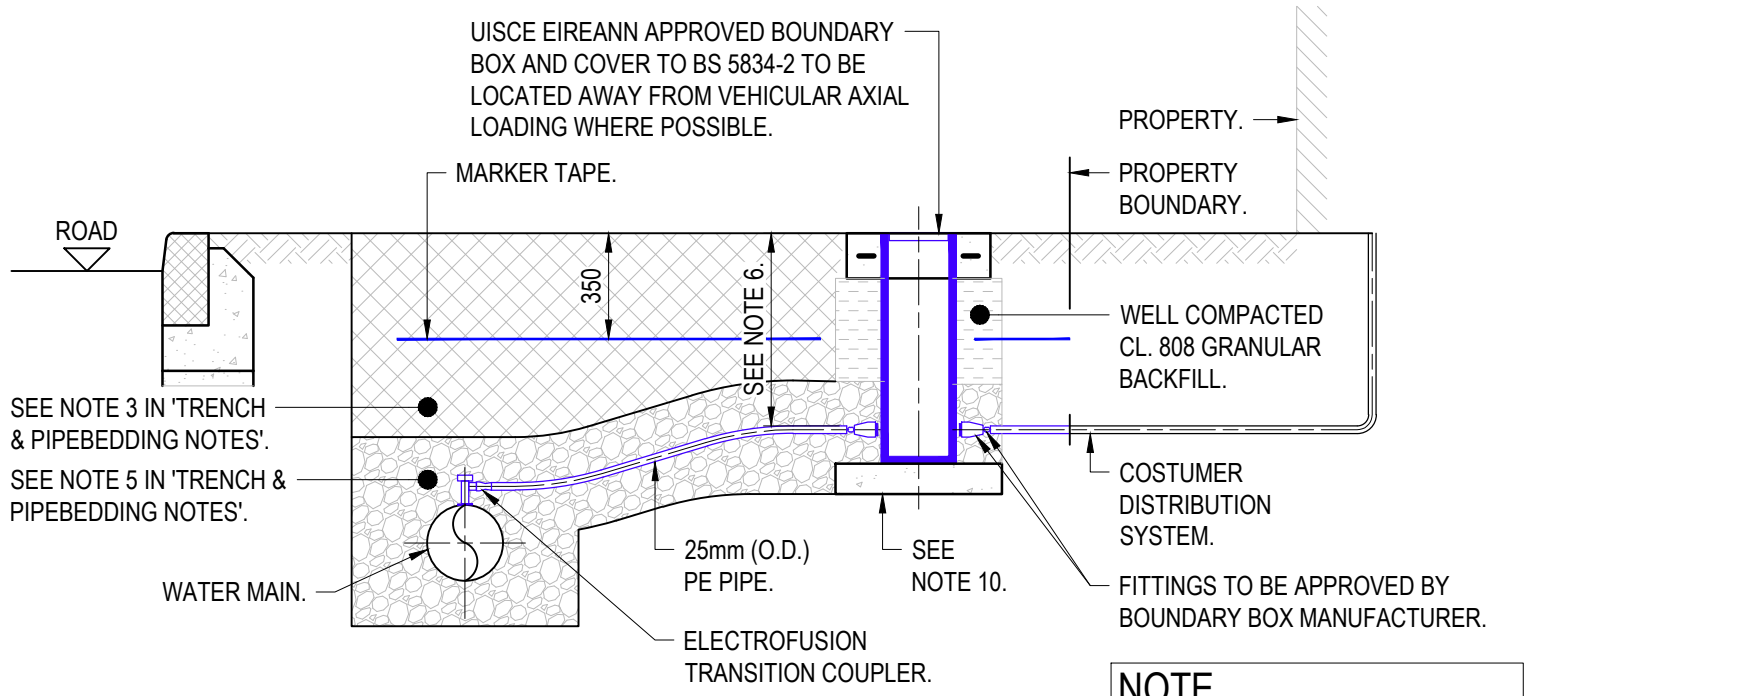

WATER MAIN - COSTUMER CONNECTION & BOUNDARY BOX

25mm OD PE PIPE.
SCALE 1 : 25

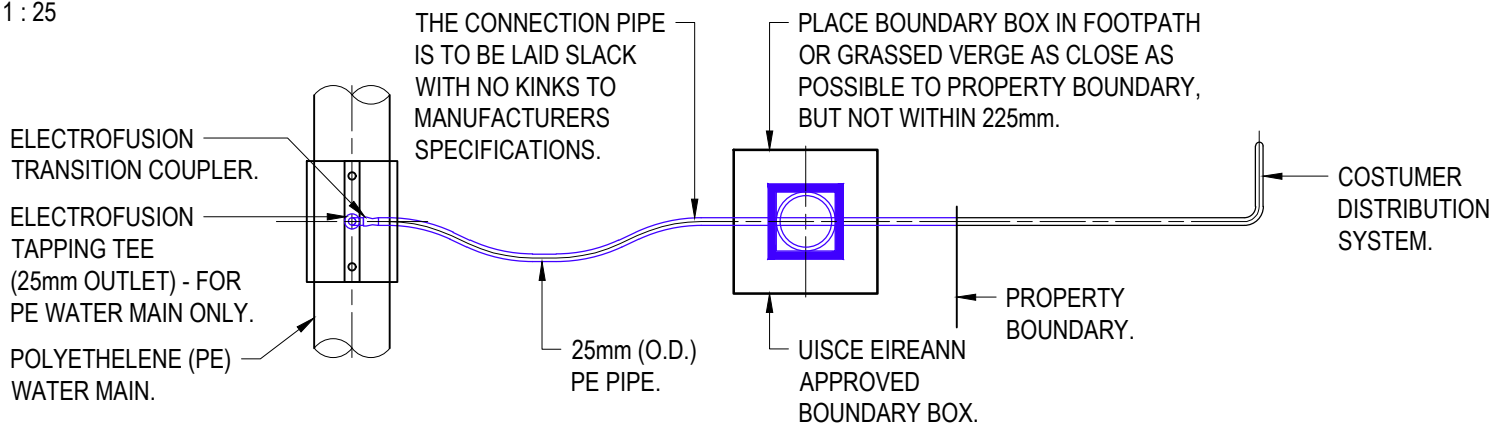


GENERAL NOTES

- WATER MAIN LAYOUTS SHALL BE ARRANGED IN LOOPS OR RINGS SO AS TO AVOID "DEAD ENDS" OR TERMINAL POINTS. ALL MAINS SHALL TERMINATE IN A LOOP OR RING TO ACCOMMODATE ONE-DIRECTIONAL FLUSHING OF THE NETWORK. LOOPS SHALL HAVE A MINIMUM OF 4 HOUSES AND 1 HYDRANT.
- THE MINIMUM PIPE SIZE SHALL BE 100mm INTERNAL DIAMETER IN HOUSING DEVELOPMENTS OF 40 AND UP TO 100 HOUSES. DEVELOPMENTS OF 100 HOUSES AND ABOVE SHALL HAVE A MINIMUM PIPE SIZE OF 150mm INTERNAL DIAMETER SPINE AND 100mm BRANCH MAINS. NOMINAL INTERNAL DIAMETERS OF 80mm AND LESS MAY BE ALLOWED IN SMALLER DEVELOPMENTS BUT NOT WHERE HYDRANTS ARE LOCATED AND ONLY AFTER PRIOR WRITTEN AGREEMENT FROM UISCE EIREANN.
- THE MINIMUM PIPE SIZE SHALL BE 150mm IN INDUSTRIAL OR COMMERCIAL DEVELOPMENTS.
- EVERY PREMISE SHOULD HAVE A SEPARATE SERVICE CONNECTION. THE USE OF COMMON SERVICE PIPES IS NOT ALLOWED. SERVICE CONNECTIONS SHALL BE AS SHORT AS REASONABLY POSSIBLE. LONG SERVICE CONNECTIONS (IN EXCESS OF 15m) WILL NOT BE ALLOWED. A RIDER MAIN AT THE OPPOSITE SIDE OF THE ROAD TO THE MAIN WATER MAIN MAY BE REQUIRED SUBJECT TO APPROVAL FROM IRISH SERVICE CONNECTIONS SHALL BE A MINIMUM PIPE SIZE OF 25mm OUTSIDE DIAMETER, 20mm INTERNAL DIAMETER.
- WATER MAINS SHOULD BE LAID TO PROVIDE THE OPTIMUM CIRCULATION IN THE LOCAL WATER NETWORK. WATER MAINS MAY TERMINATE IN A DEAD END ONLY WITH UISCE EIREANN APPROVAL, IN WHICH CASE AN ON-LINE WASHOUT HYDRANT SHALL BE PROVIDED AT THE DEAD END, LOCATED WITHIN A CHAMBER OR KIOSK.
- VALVES SHALL BE ARRANGED IN SUCH A MANNER TO ALLOW THE NETWORK TO BE MANAGED TO ENSURE THAT NO MORE THAN 40 PROPERTIES LOSE WATER FROM A BURST ON THE SYSTEM, AT ANY ONE TIME.
- NO DOMESTIC PROPERTY SHALL BE MORE THAN 46m FROM A HYDRANT. HYDRANT DETAILS AND LOCATIONS SHALL BE SUBJECT TO THE APPROVAL OF THE RELEVANT LOCAL AUTHORITY FIRE DEPARTMENT.
- WATER SUPPLY MAINS SHALL BE LAID IN COMMON AREAS AND NOT THROUGH INDIVIDUAL PRIVATE GARDENS OR DRIVEWAYS ETC.
- A THREE-WAY VALVE ARRANGEMENT SHALL BE PROVIDED AT ALL JUNCTIONS, AS A MINIMUM.
- THE WATER MAIN PIPEWORK TO NEW DEVELOPMENTS SHOULD BE LOCATED AT THE RIGHT HAND SIDE OF THE ENTRANCE TO THE NEW DEVELOPMENT FROM A VIEW FACING INTO THE DEVELOPMENT IF POSSIBLE AND WHERE THE PROPERTIES ARE EQUALLY AND REASONABLY DISTRIBUTED AT BOTH SIDES OF THE ESTATE ROADWAY.
- AIR VALVES TO BE LOCATED AT POINTS WHERE AIR IS LIKELY TO BUILD UP.
- THE DEVELOPER IS TO LIAISE WITH THE FIRE SERVICES AUTHORITY IN ORDER TO ENSURE FIRE FLOWS ARE AVAILABLE THROUGHOUT THE DEVELOPMENT.
- BULK FLOW METERS SHALL BE FITTED IN ALL DEVELOPMENTS WITH A DEMAND IN EXCESS OF 20m³ PER DAY. BULK FLOW METERS SHALL HAVE A FACTORY FITTED AMR AND INSTALLED IN A SUITABLY SIZED CHAMBER. DEVELOPMENTS WITH DEMAND LESS THAN 20m³ PER DAY SHALL BE PROVIDED WITH A DEDICATED BYPASS PIPEWORK AND CHAMBER IN ACCORDANCE WITH STD-W-26F TO ACCOMMODATE THE RECORDING OF NIGHT FLOWS.
- WATERMANS TO BE LOCATED IN GRASS VERGE, IF GRASS VERGE IS NOT AVAILABLE, WATERMANS TO BE LOCATED UNDER FOOTPATH AWAY FROM KERB. REFER TO STD-W-11 FOR TYPICAL UTILITY LAYOUT.
- WHERE A GRASS VERGE IS NOT AVAILABLE AND A FOOTPATH IS LESS THAN 1.2m WIDE, THE WATERMAIN IS PERMITTED ON THE ROADWAY.

SCOUR CHAMBER NOTES

- ALL DIMENSIONS ARE IN MILLIMETRES (mm) UNLESS NOTED OTHERWISE.
- STRUCTURAL REINFORCEMENT AND DESIGN DETAIL TO BE PROVIDED BY THE DEVELOPER AND SUBMITTED TO UISCE EIREANN FOR REVIEW. ROOF SLABS SHALL BE DESIGNED TO CARRY ALL LIVE LOADS & DEAD LOADS, & CONSIST OF A REINFORCED CONCRETE SLAB OF IN-SITU CONCRETE, GRADE C30/37, WITH A MINIMUM THICKNESS OF 225mm. ALTERNATIVELY, PRE-CAST CONCRETE ROOFS MAY BE USED, SUBJECT TO UISCE EIREANN REVIEW, & COMPLIANCE WITH IS EN 1719 & IS 420.
- CONCRETE FOR SCOUR CHAMBER AND HEADWALL TO BE C30 / 37.
- APPROVAL TO BE OBTAINED FROM LOCAL AUTHORITY FOR CONNECTION TO THE EXISTING STORM SEWER.
- SCOUR CHAMBER SHALL BE COVERED WITH APPROVED HEAVY DUTY METAL COVERS TO IS EN 124 RATING D400. COVER AND FRAME SHALL BE SUITABLE FOR ROAD AND TRAFFIC CONDITIONS AND IS SUBJECT TO REVIEW UISCE EIREANN.
- 200mm ALL ROUND, 100mm DEEP CONCRETE PLINTH AROUND COVERS IN GRASS AREAS.
- FINAL DETAIL TO BE REVIEWED BY UISCE EIREANN AND RELEVANT REGULATORY AUTHORITIES.
- THRUST BLOCKS (NOT SHOWN ON DRAWING), TO BE PROVIDED AS PER DRAWING G09900-WRD-EX-ZZ-DR-C-50017 ALL TEES, BENDS, TAPERS, DEAD ENDS AND PIPES AT STEEP SLOPES.
- ANTI CORROSION TAPE TO BE PROVIDED AROUND BURIED FLANGES.
- ALL PIPEWORK AND FITTINGS TO BE IN ACCORDANCE WITH IS EN 545. PE PIPES AND FITTINGS TO BE IN ACCORDANCE WITH IS EN 12201:2011.
- ALL CHAMBERS TO BE CHECKED FOR UPLIFT BY THE DEVELOPER BASED ON GROUND CONDITIONS WITHIN THE SITE. SHOULD ANTI FLOATATION MEASURES BE REQUIRED THEY SHALL BE SUBJECT TO AGREEMENT WITH UISCE EIREANN.
- ALL CONCRETE TO BE IN ACCORDANCE WITH IS EN 206.
- BACKFILL AND REINSTATEMENT OF RIVER BED AND BANK TO BE SUBJECT TO AGREEMENT WITH UISCE EIREANN & RELEVANT AUTHORITIES.

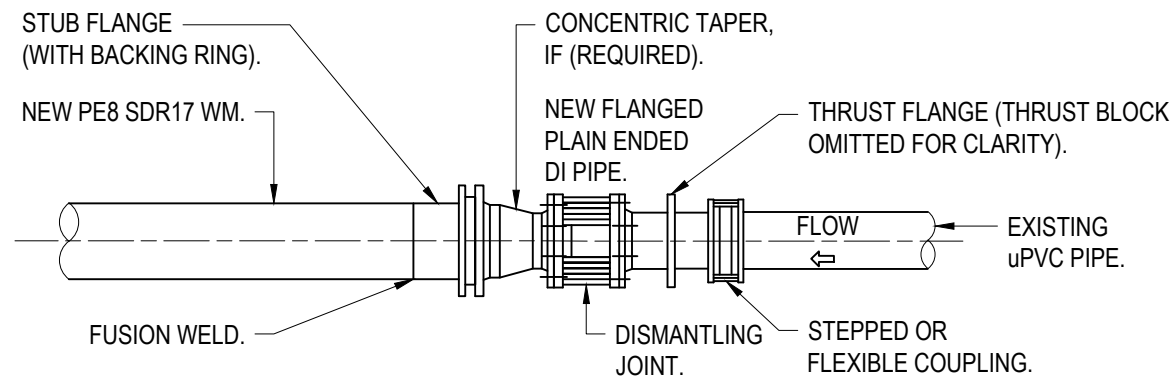

NEW PE TO EXISTING uPVC (DIFFERENT SIZE TO NEW) DETAIL

SCALE 1 : 25

BOUNDARY BOX NOTES

- ALL DIMENSIONS ARE IN MILLIMETRES (mm) UNLESS NOTED OTHERWISE.
- FOR CONNECTION TO AN EXISTING MAIN THE CONNECTION SHALL BE AS PER THE PIPE MANUFACTURER'S SPECIFICATION.
- ELECTRO FUSION COUPLING TO BE INSTALLED IN ACCORDANCE WITH MANUFACTURER'S INSTRUCTIONS.
- ALL CONCRETE TO BE IN ACCORDANCE WITH IS EN 206.
- THE BOUNDARY BOX IS TO BE IN ACCORDANCE WITH THE UISCE EIREANN SPECIFICATION, INCORPORATING A G1.5 MANIFOLD, STOP-TAP, FROST PLUG & NON-RETURN VALVE.
- THE BOUNDARY BOX SHALL BE POSITIONED IN PUBLIC SPACE & AS CLOSE AS POSSIBLE TO THE PROPERTY BOUNDARY BUT NO PART OR FITTING TO BE WITHIN 225mm OF THE PROPERTY.
- THE BOUNDARY BOX SHALL BE LOCATED WHERE IT IS SAFE TO OPEN THE COVER & ACCESS THE STOP TAP OR VISUALLY READ THE METER, i.e. ON A FOOTPATH OR VERGE, & NOT IN A CARRIAGEWAY.
- THE SURFACE BOX COVER ON THE BOUNDARY BOX SHOULD BE NOT LESS THAN GRADE C (BS 5834:2-2011), & THE BOUNDARY BOX SHOULD BE LOCATED SUCH THAT HEAVIER GRADES OF COVER WOULD NOT BE REQUIRED.
- THE SHAFT OF THE BOUNDARY BOX IS TO BE INSTALLED VERTICALLY, & THE SURFACE BOX/COVER INCLINED TO MATCH THE SURFACE GRADIENT.
- THE BOUNDARY BOX IS TO BE INSTALLED AT A MINIMUM DEPTH OF 600mm (+/- 25mm) TO THE CROWN OF THE INLET & OUTLET FITTINGS ON THE OUTSIDE OF THE BOX.
- THE SERVICE CONNECTION PIPE SHALL NOT BE WRAPPED AROUND THE SHAFT OF THE BOUNDARY BOX OR BENT IN ANY RADIUS LESS THAN THAT APPROVED BY THE MANUFACTURER.
- THE PIPE FITTINGS TO THE BOUNDARY BOX SHALL BE APPROVED BY THE BOUNDARY BOX MANUFACTURER.
- THE BOUNDARY BOX SHALL BE INSTALLED HYGIENICALLY & LEFT CLEAN & FREE OF CONSTRUCTION WASTE OR DIRT FOR LATER METER INSTALLATION BY UISCE EIREANN.
- BOX TO BE FOUNDED ON 100mm DEPTH OF C12/15 CONCRETE AND SURROUNDED WITH CLAUSE 808 GRANULAR MATERIAL.
- THE DESIRABLE MINIMUM COVER FROM THE FINISHED GROUND LEVEL TO THE EXTERNAL CROWN OF A SERVICE CONNECTION SHALL BE 750mm WITH AN ABSOLUTE MINIMUM DEPTH OF 600mm FOR SHORT DISTANCES (SUBJECT TO UISCE EIREANN AGREEMENT). THE DESIRABLE MAXIMUM COVER FOR A SERVICE CONNECTION PIPE SHOULD BE 1200mm, WHERE PRACTICABLE.
- CUSTOMER'S DISTRIBUTION PIPEWORK WITHIN THE PREMISES SHOULD BE SUITABLY SIZED TO ACCOMMODATE FLOW FROM 20mm INTERNAL DIAMETER SERVICE PIPE.
- WHERE A GRASS VERGE IS NOT AVAILABLE AND A FOOTPATH IS LESS THAN 1.5m WIDE, THE WATERMAIN IS PERMITTED ON THE ROADWAY.
- THE POSITION OF THE METER DOES NOT REPRESENT THE CHANGE OF OWNERSHIP IN THE SERVICE PIPE. THAT POINT IS NORMALLY AT THE PROPERTY BOUNDARY.
- THE BOUNDARY BOX ACCOMMODATES DN15, DN20 AND DN25 CONCENTRIC METERS. A G1 ½ MANIFOLD IS TO BE USED FOR DN15 & DN20 METERS. A G2 MANIFOLD IS TO BE USED FOR DN25 METERS.

BY-PASS FLOW METER CHAMBER NOTES

- ALL DIMENSIONS ARE IN MILLIMETRES (mm) UNLESS NOTED OTHERWISE.
- STRUCTURAL DESIGN AND REINFORCEMENT DETAIL TO BE PROVIDED BY THE DEVELOPER AND SUBMITTED TO UISCE EIREANN FOR REVIEW. ROOF SLABS SHALL BE DESIGNED TO CARRY ALL LIVE LOADS & DEAD LOADS, & CONSIST OF A REINFORCED CONCRETE SLAB OF IN-SITU CONCRETE, GRADE 30/37, WITH A MINIMUM THICKNESS OF 150mm. ALTERNATIVELY, PRE-CAST CONCRETE ROOFS MAY BE USED, SUBJECT TO UISCE EIREANN APPROVAL & COMPLIANCE WITH IS EN 1917 & IS 420.
- SLUICE VALVE CHAMBERS SHALL BE COVERED WITH APPROVED HEAVY DUTY METAL COVERS TO IS 261 OR BS 5834. COVER AND FRAME SHALL BE SUITABLE FOR ROAD AND TRAFFIC CONDITIONS AND IS SUBJECT TO REVIEW BY UISCE EIREANN.
- 200mm ALL AROUND, 100mm DEEP CONCRETE PLINTH AROUND COVERS IN GREEN AREAS.
- ANTI CORROSION TAPE TO BE PROVIDED AROUND ALL BURIED FLANGES.
- ALL CHAMBERS TO BE CHECKED FOR UPLIFT BY THE DEVELOPER BASED ON GROUND CONDITIONS WITHIN THE SITE. SHOULD ANTI FLOATATION MEASURES BE REQUIRED THEY SHALL BE SUBJECT TO REVIEW BY UISCE EIREANN.
- ALL CONCRETE TO BE IN ACCORDANCE WITH IS EN 206.
- ANY SPECIAL ROAD REINSTATEMENT AROUND COVER & FRAME SHALL BE TO ROAD AUTHORITY'S REQUIREMENTS.
- NEW ROAD CONSTRUCTION & SURFACE FINISH TO BE TO ROAD AUTHORITY'S REQUIREMENTS.
- EXISTING ROAD REINSTATEMENT TO COMPLY WITH CURRENT VERSION OF 'GUIDELINES FOR MANAGING OPENINGS IN PUBLIC ROADS' BY THE DEPT. OF TRANSPORT, TOURISM & SPORT, OR TRANSPORT INFRASTRUCTURE IRELAND REQUIREMENTS.
- 200mm ALL AROUND x 100mm DEEP, C20/25 CONCRETE PLINTH COMPLETE WITH BULL NOSE FINISH AND MILD STEEL REINFORCEMENT LINK AROUND COVERS IN GREEN AREAS.

PIPE CONNECTION NOTES

- ALL DIMENSIONS ARE IN MILLIMETRES (mm) UNLESS NOTED OTHERWISE.
- ALL BENDS, TEES, DEAD ENDS, ETC. OF PIPELINES TO BE ADEQUATELY RESTRAINED BY THRUST BLOCKS AS PER DRAWING No. STD-W-28. THRUST BLOCKS NOT SHOWN FOR CLARITY.
- BUTT FUSION WELDING AND ELECTRO FUSION JOINTING OF PIPES SHALL ONLY BE CARRIED OUT BY TRAINED OPERATIVES IN POSSESSION OF A CURRENT TRAINING CERTIFICATE, USING FULLY AUTOMATIC APPROVED JOINTING MACHINE/RIGS IN ACCORDANCE WITH THE MANUFACTURER'S INSTRUCTIONS. THE IDENTITY OF THE PE PIPELINE MANUFACTURER SHALL BE MADE KNOWN TO UISCE EIREANN PRIOR TO COMMENCEMENT OF THE INSTALLATION. CERTIFICATION AND TESTING (INCLUDING INDEPENDENT THIRD PARTY CERTIFICATION) SHALL BE PROVIDED TO CONFIRM QUALITY ASSURANCE COMPLIANCE. EACH JOINT SHALL BE CLEARLY MARKED WITH THE JOINT LOGGED AUTOMATICALLY ON THE JOINTING MACHINE. A PRINTOUT OF THE JOINT DETAILS, WITH A GPS LOCATION OF EACH JOINT, SHALL BE PROVIDED AND RETAINED FOR QUALITY ASSURANCE PURPOSES.
- CONNECTING TO EXISTING MAINS IS TO BE CARRIED OUT BY UISCE EIREANN OR AN APPROVED UISCE EIREANN AGENT.
- WHEN EXISTING AC WATERMANS ARE PRESENT A SPECIFIC METHOD STATEMENT SHALL BE SUBMITTED TO UISCE EIREANN PRIOR TO WORKS TAKING PLACE AND SUBJECT TO WRITTEN APPROVAL. DETAILING THE PROTECTION TO BE PUT IN PLACE TO EXISTING MAINS, METHOD OF REMOVAL OF EXISTING AC, METHOD OF DISPOSAL OF EXISTING AC AND METHOD OF CONNECTION TO EXISTING AC.
- PIPE MATERIAL REFERENCES AS FOLLOWS:
AC - ASBESTOS CEMENT
CI - CAST IRON
uPVC - UNPLASTICISED POLY VINYL CHLORIDE
OTHER - REFERS TO ALL EXISTING PIPE MATERIALS OTHER THAN PE (TYPICALLY AC, DI, CI, uPVC & ST).
DI - DUCTILE IRON
PE - POLYETHYLENE
ST - STEEL
- SLUICE VALVE CHAMBERS TO BE IN ACCORDANCE WITH STD-W-14 (DI) AND STD-W-15 (PE). CHAMBERS NOT SHOWN FOR CLARITY.
- ALL THRUST FLANGES TO BE ADEQUATELY RESTRAINED BY THRUST BLOCKS AS PER DRAWING No. STD-W-28. THRUST BLOCKS NOT SHOWN FOR CLARITY.
- A HIGH LEVEL OF HEALTH & SAFETY PROCEDURES IS REQUIRED WHEN WORKING ON AC MAINS, & THE OPERATION OF DISMANTLING/REMOVAL OF AC PIPES & JOINTS.
- VALVES SHALL BE ARRANGED IN SUCH A MANNER TO ALLOW FOR THE NETWORK TO BE MANAGED TO ENSURE THAT NO MORE THAN 40 PROPERTIES LOSE WATER FROM A BURST ON THE SYSTEM AT ANY ONE TIME.

NOTE

DETAILS AND SPECIFICATIONS BASED ON UISCE EIREANN'S CURRENT STANDARDS. CONTRACTOR TO ENSURE LATEST STATUTORY BODY GUIDELINES, DETAILS AND SPECIFICATIONS ARE FOLLOWED.

GENERAL NOTES

- DO NOT SCALE FROM THIS DRAWING - IF IN DOUBT CONTACT PROJECT ENGINEER.
- ALL DIMENSIONS ARE IN METRES UNLESS STATED OTHERWISE.
- ALL LEVELS AND COORDINATES ARE IN METRES REFERENCED TO IRISH TRANSVERSE MERCATOR GRID (ITM)
- THIS DRAWING IS TO BE READ IN CONJUNCTION WITH ALL RELEVANT ARCHITECTURAL, STRUCTURAL AND SERVICES DRAWINGS.
- THE CONTRACTOR IS TO VERIFY ALL DIMENSIONS ON SITE AND IS RESPONSIBLE FOR ACCURATE SETTING OUT.
- THE CONTRACTOR IS TO CONFIRM THE EXISTING BOUNDARY AND SITE STRUCTURES ETC. PRIOR TO COMMENCING THE WORKS AND IMMEDIATELY INFORM THE SUPERVISING OFFICER SHOULD THESE BE AT VARIANCE WITH THE ASSUMPTIONS SHOWN ON THE DRAWING.

ALL DIMENSIONS SHOWN ON THIS DRAWING ARE TO BE VERIFIED BY THE ARCHITECT PRIOR TO FABRICATION / MANUFACTURE / CONSTRUCTION

CONSTRUCTION (DESIGN AND MANAGEMENT) REGULATIONS 2015

THE DESIGNS ON THIS DRAWING ARE PREPARED WITH CONSIDERATION OF THE NEED TO IDENTIFY HAZARDS AND GIVE REGARD TO THEIR ELIMINATION OR MINIMISATION. REFERENCE MUST BE MADE TO HEALTH AND SAFETY INFORMATION PREPARED BY THE PRINCIPAL DESIGNER.

P01	Issued for Planning	04/06/26	AO	ES
ISSUE	DETAILS	DATE	BY	CHK

STATUS:

PLANNING

Will Rudd

Will Rudd Davidson (Ireland)
Consulting Civil & Structural Engineers
South Point, Herbert House, Harmony Row,
Grand Canal Dock, Dublin D02 H270
T: 01 910 3278
E: dublin@ruddconsult.com
www.ruddconsult.com

CLIENT:
TIPPERARY COUNTY COUNCIL

PROJECT TITLE:
HOUSING DEVELOPMENT AT GLEAN CAOIN,
BORRISOLEIGH CO. TIPPERARY

DRG TITLE:
WATERMAIN DETAILS,
SHEET 01

DRAWN BY:	AO	DATE DRAWN:	28/05/2026
CHECKED BY:	ES	DATE CHECKED:	28/05/2026
SCALES:	AS NOTED	SHEET SIZE:	A1
PROJECT - ORIGINATOR - VOLUME - LEVEL - TYPE - ROLE - NUMBER			REV:
G09900 - WRD - EX - ZZ - DR - C - 50035			P01