


Note: Typical arrangement shown contractor to adapt to suit the individual pole dimension.


DETAIL 1

TYPICAL LIGHT POLE ARRANGEMENT DETAIL

SCALE 1:25

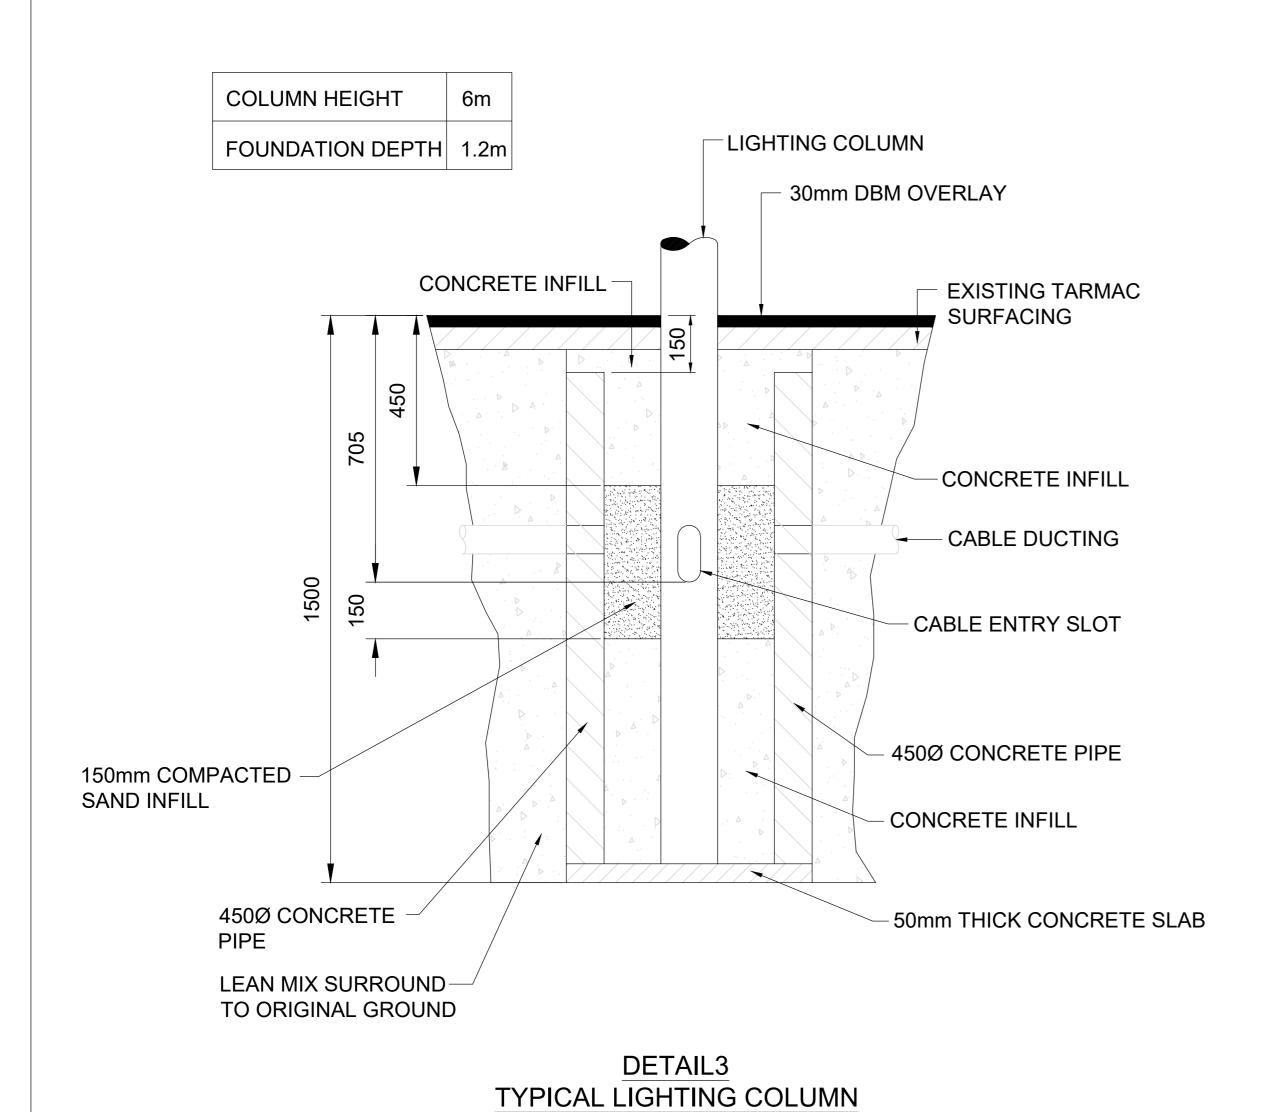

FOUNDATION DETAIL

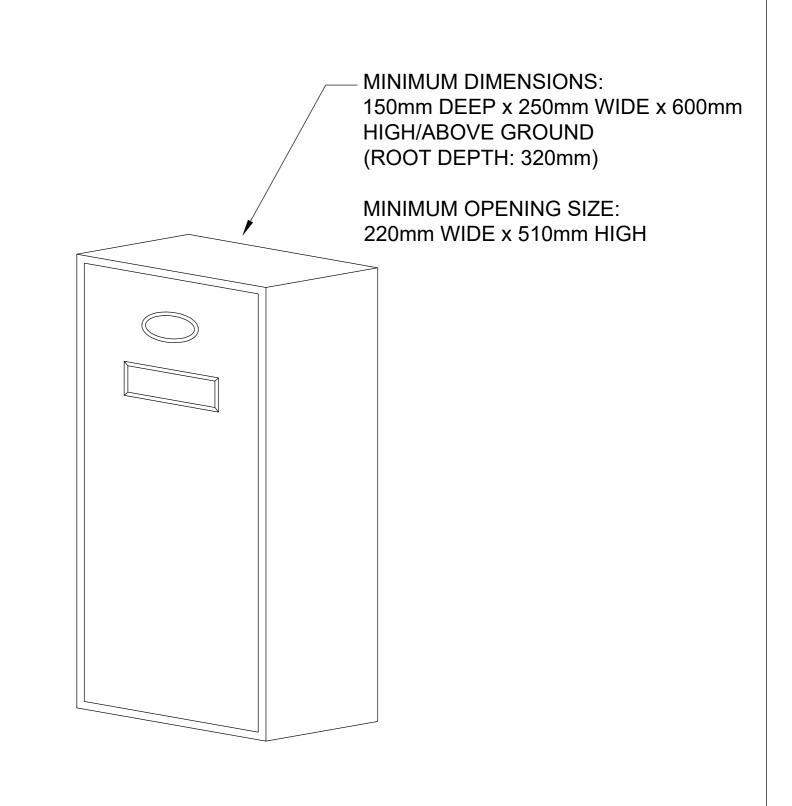

DETAIL 4

TYPICAL UNMETERED SINGLE PHASE PILLAR

SCALE 1:5



PL1	19/12/19	JT	KC	VA







www.arup.com

Job No Drawing Status 265545 Planning	Job No Drawing Status	Drawing No KIFRS-E-310		
		265545	Planning	
Electrical Details	Electrical Details	Job No	Drawing Status	
		Electrical Details		