


NOTES:

1. THE ENCLOSED DESIGN IS FOR PLANNING PURPOSES ONLY AND NOT FOR CONSTRUCTION. EQUIPMENT LOCATIONS ARE INDICATIVE ONLY AND ARE SUBJECT TO CHANGE WITHIN BUILDING.
2. AIR COOLER CONDENSER, COLLECTION TANK, CONDENSATE POLISHER ENCLOSURE AND POWER DISTRIBUTION CENTER (PDC) TO BE COLOUR GREY-OLIVE, RAL 6006. AIR COOLER STEAM DUCK PIPING TO BE COLOUR TRAFFIC GREY, RAL 7043.

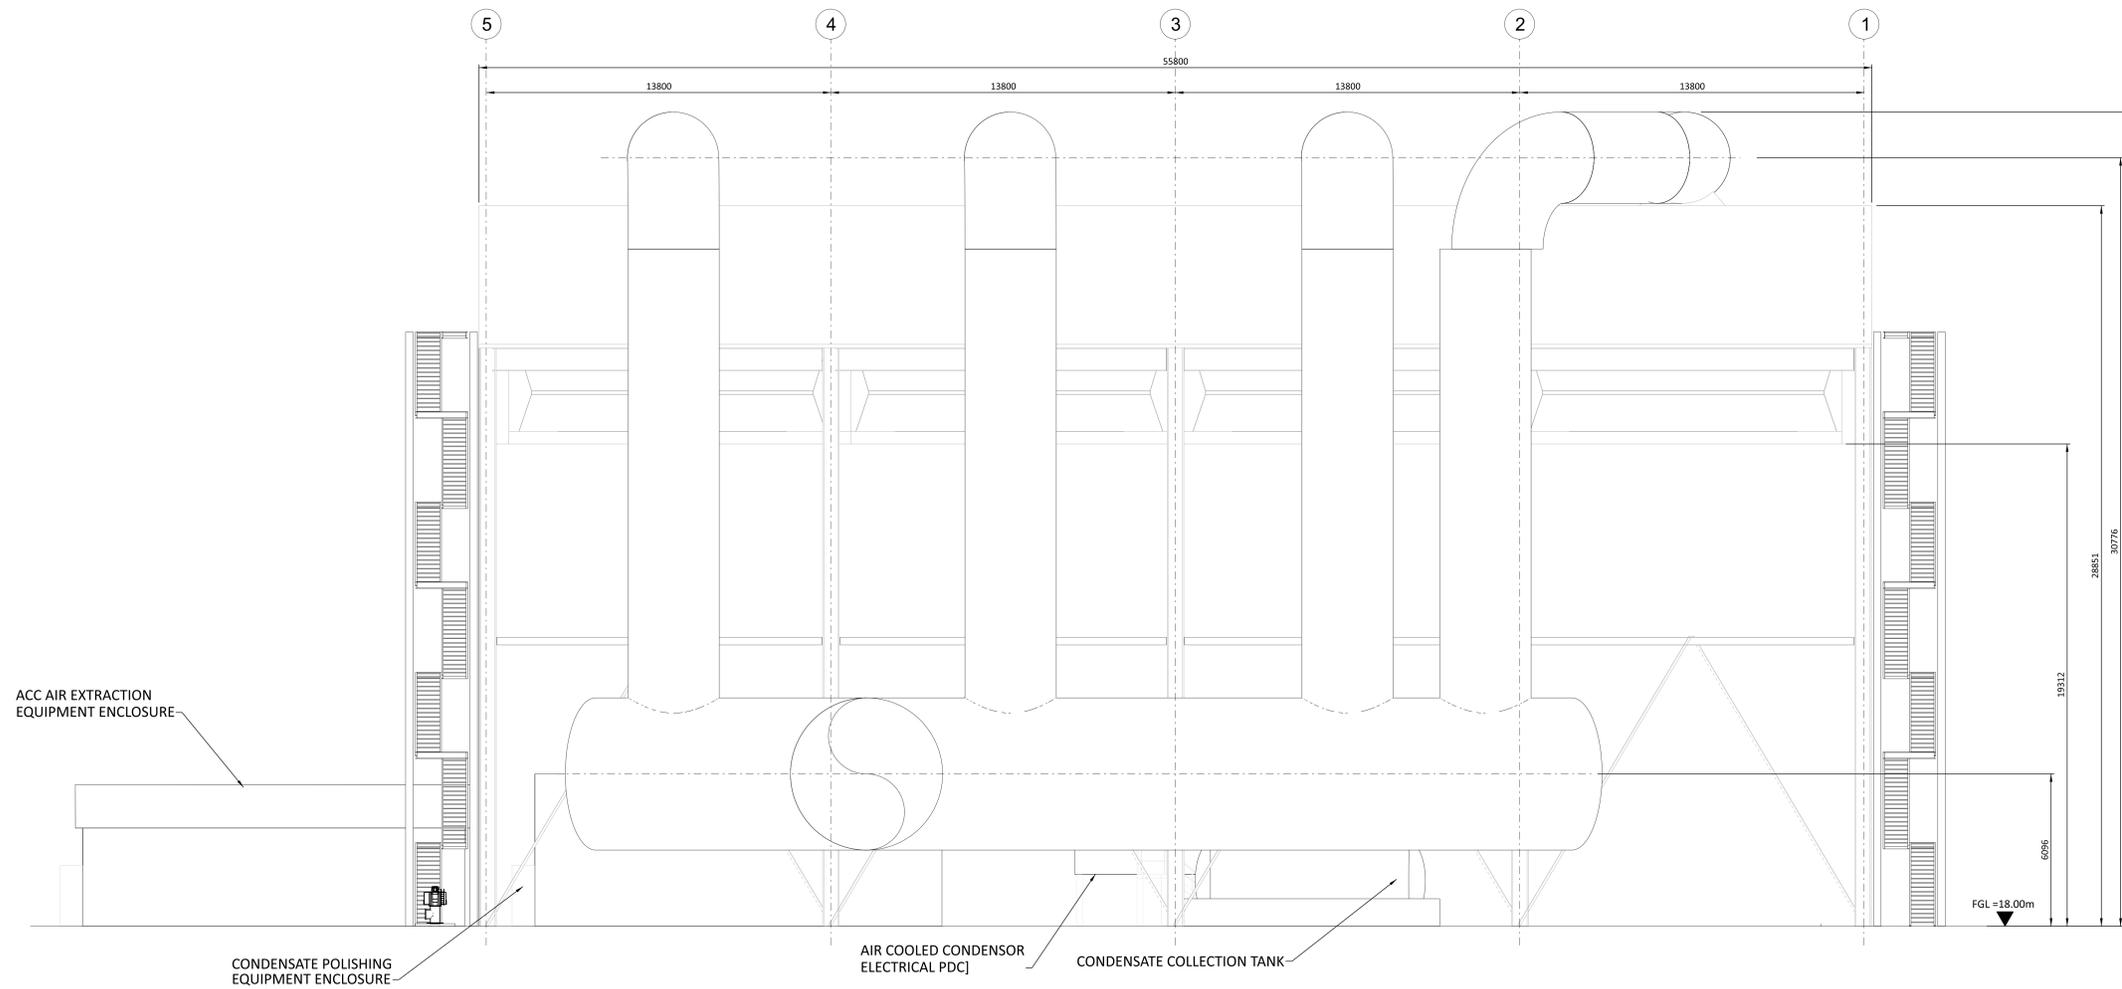


SOUTH ELEVATION
SEE DRAWING 198291-SS-A4075A

NOT TO BE USED FOR CONSTRUCTION

THE DISTRIBUTION AND USE OF THE NATIVE FORMAT CAD FILE OF THIS DRAWING IS UNCONTROLLED. THE USER SHALL VERIFY TRACEABILITY OF THIS DRAWING TO THE LATEST CONTROLLED VERSION.

19/07/2021 10:15:07.4
 19/07/2021 10:15:07.4
 19/07/2021 10:15:07.4

| NO | DATE | ISSUED FOR PLANNING | REVISIONS AND RECORD OF ISSUE | TMC | DIL | DAC | DRN | DES | CHK | PDE | APP |
|----|-------------|---------------------|-------------------------------|-----|-----|-----|-----|-----|-----|-----|-----|
| 0 | 18/JUN/2010 | ISSUED FOR PLANNING | | | | | | | | | |

 

BLACK & VEATCH CORP HEADQUARTERS:
11401 LAMAR AVENUE, OVERLAND PARK,
KANSAS, USA

BLACK & VEATCH

CHECKED: _____ DATE: _____

DRAWN: _____

SHANNON LNG LIMITED
SHANNON TECHNOLOGY AND ENERGY PARK (STEP)
AIR COOLED CONDENSER
SOUTH ELEVATION

| | | |
|------------------|----------------|-----|
| PROJECT | DRAWING NUMBER | REV |
| 198291-SS-A4075C | | 0 |