


NOTES:

1. THE ENCLOSED DESIGN IS FOR PLANNING PURPOSES ONLY AND NOT FOR CONSTRUCTION. EQUIPMENT LOCATIONS ARE INDICATIVE ONLY AND ARE SUBJECT TO CHANGE WITHIN BUILDING.
2. AIR COOLER CONDENSER, COLLECTION TANK, CONDENSATE POLISHER ENCLOSURE AND POWER DISTRIBUTION CENTER (PDC) TO BE COLOUR GREY-OLIVE, RAL 6006. AIR COOLER STEAM DUCK PIPING TO BE COLOUR TRAFFIC GREY, RAL 7043.

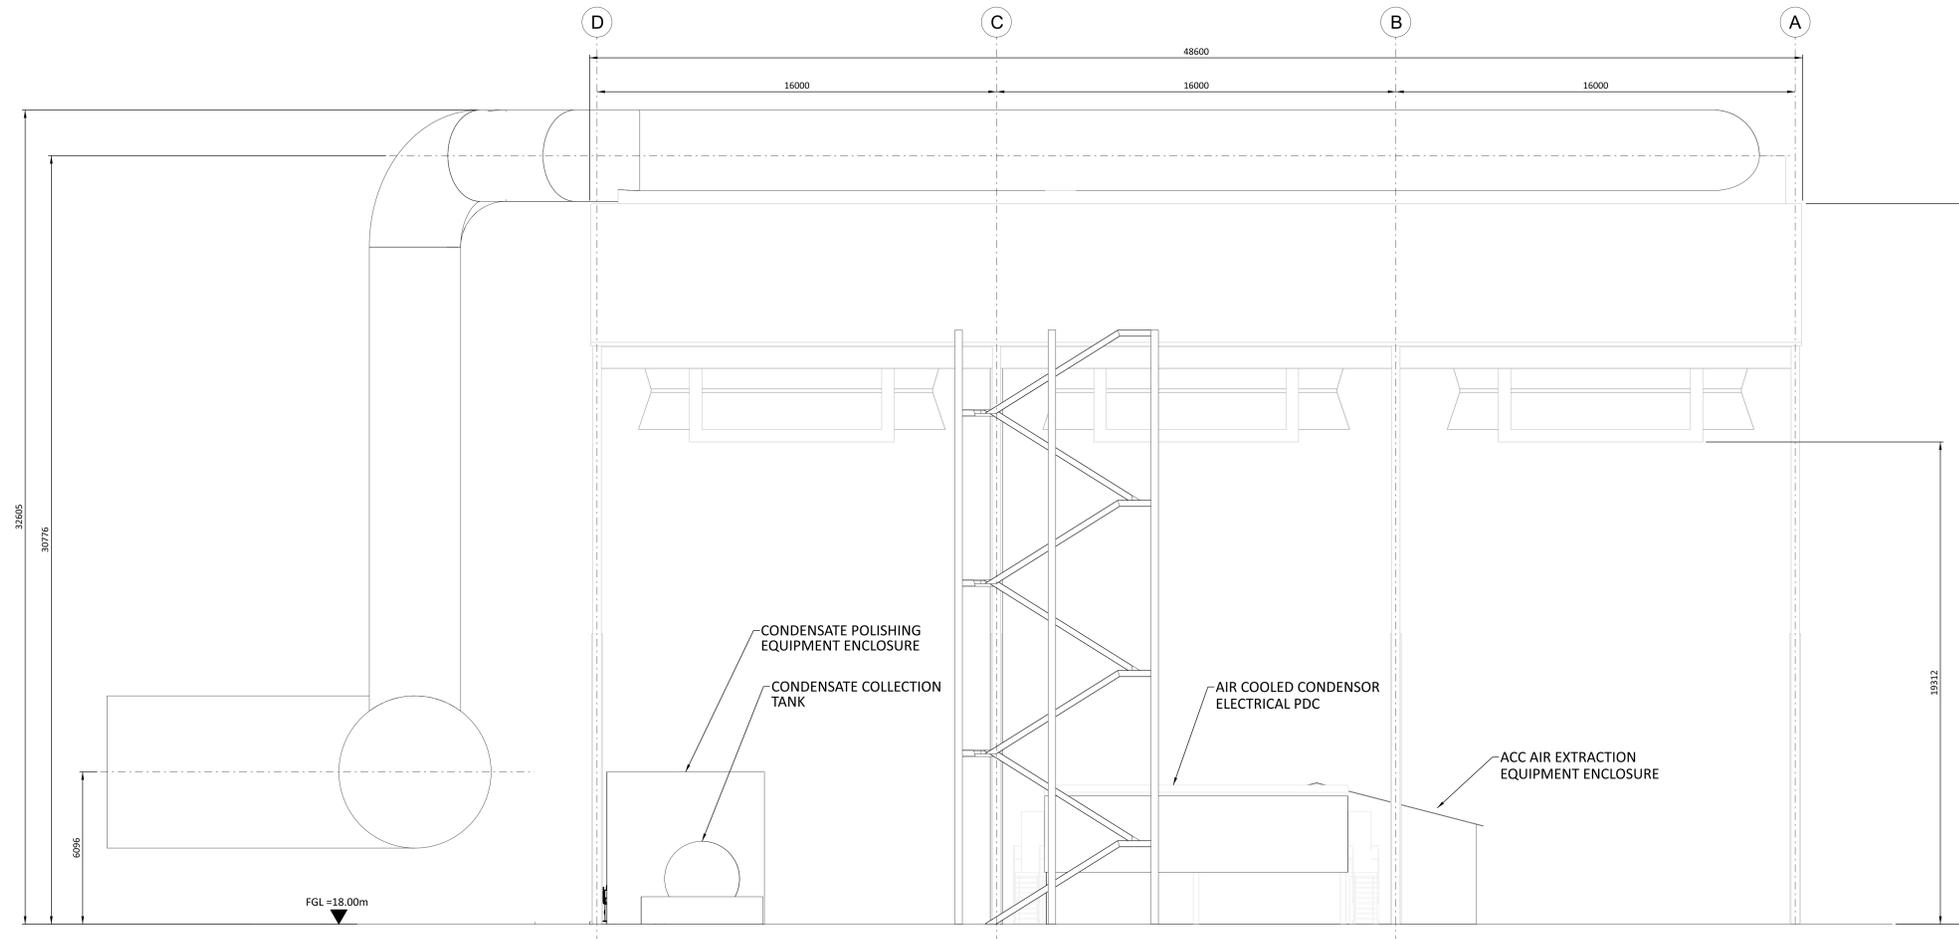


EAST ELEVATION
SEE DRAWING 198291-SS-A4075A

NOT TO BE USED FOR CONSTRUCTION

THE DISTRIBUTION AND USE OF THE NATIVE FORMAT CAD FILE OF THIS DRAWING IS UNCONTROLLED. THE USER SHALL VERIFY TRACEABILITY OF THIS DRAWING TO THE LATEST CONTROLLED VERSION.

19/07/2021 09:48 AM
 198291-SS-A4075A
 198291-SS-A4075A

NO	DATE	ISSUED FOR PLANNING	REVISIONS AND RECORD OF ISSUE	DRN	DES	CHK	PDE	APP
0	18/JUN/2010	ISSUED FOR PLANNING		TMC	DIL		DAC	

 

BLACK & VEATCH CORP HEADQUARTERS:
11401 LAMAR AVENUE, OVERLAND PARK,
KANSAS, USA

BLACK & VEATCH

CHECKED: _____ DATE: _____

DRAWN: _____

SHANNON LNG LIMITED
SHANNON TECHNOLOGY AND ENERGY PARK (STEP)
AIR COOLED CONDENSER
EAST ELEVATION

PROJECT	DRAWING NUMBER	REV
198291-SS-A4075D		0
CODE	AREA	