


PUMP STATION PLAN VIEW

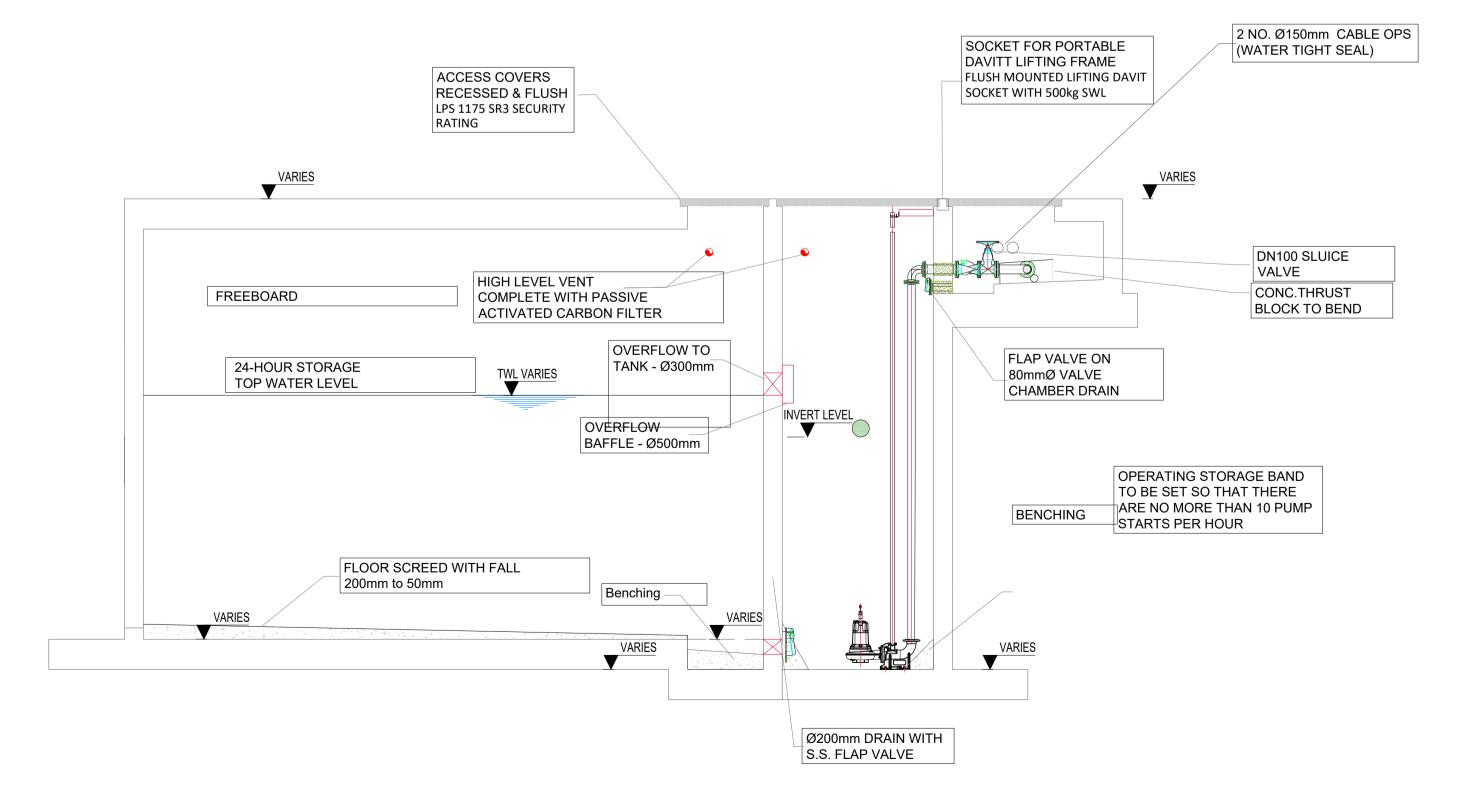

CROSS SECTION 'A' with Mechanical Details

## NOTES:

- 1. FIGURED DIMENSIONS ONLY TO BE TAKEN FROM THIS DRAWING.
- 2. ALL DRAWINGS TO BE CHECKED BY THE CONTRACTOR ON SITE.
- 3. ENGINEER/EMPLOYERS REPRESENTATIVE, AS APPROPRIATE, TO BE INFORMED BY THE CONTRACTOR OF ANY DISCREPANCIES BEFORE ANY WORK COMMENCES.
- 4. THE CONTRACTOR SHALL UNDERTAKE A THOROUGH CHECK FOR THE ACTUAL LOCATION OF ALL SERVICES/UTILITIES, ABOVE AND BELOW
- GROUND, BEFORE ANY WORK COMMENCES. 5. ALL LEVELS SHOWN RELATE TO ORDNANCE SURVEY DATUM AT MALIN HEAD.
- Issued For Planning P01 07.07.2022 Draft Planning MN BH

Description

By Chkd.

Client:

Rev Date



Project:

Residential Development Ennis, Co. Clare,

Typical Pump Station Details

1:50 / @A3 1:100

Checked: Prepared by:

July 2022 BH

Date:

Project Director: Brian Carroll

Drawing Status: Planning

Fairgreen House, Fairgreen Road, Galway, H91 AXK8,

Tel: +353 (0)91 565 211

Ireland.

Drawing No.: 11269-2130 P02