

Map Series:
Prime2 Vector Data - 1:2500
Map Sheets:
3325-B, 3326-A, 3325-D & 3326-C
Ordnance Survey Ireland Licence No.
CYAL50261649
Copyright:
© Suirbhéireacht Ordnáis Éireann, 2023
© Ordnance Survey Ireland, 2023



Head Office
Beenleigh,
Abbeydonney,
Tralee, Co. Kerry
Ireland
Tel: 00353 66 7135710

Regional Office
Basepoint Business Centre
Stroudley Road, Basingstoke,
Hampshire,
RG24 8UP, UK
Tel: 00 44 1256406664

PROJECT

Baldonnell 110kV Substation

CLIENT



CONSULTANTS

- NOTES: -**
- All proposed routes shown are indicative only at this stage and are subject to further assessment.
 - Additional watercourses and services may be encountered.
 - The property boundaries shown (while an accurate representation) are for information purposes only. Precise digital boundaries will be obtained from PRAI & mapped in advance of any formal Section 53 Wayleave or Deed A / Deed B being served on the landowner.

- LEGEND: -**
- Proposed 110kV Grid Connection UGC (0.266km) ---
 - Planning Boundary shown thus ---
 - Lands in Ownership of Applicant or subject to the application shown thus ---
 - Existing Wayleaves shown thus ---
 - Proposed Baldonnell 110kV Substation shown thus █
 - *Approved gas fired Power Plant application reference SD21A/0167 - currently under construction* ▨
 - Barnakyle 110kV Substation shown thus ▨

ISSUE/REVISION

Issue/Revision	Date	Description
P6	31.05.23	Issued for Planning
P5	23.05.23	Issued for Planning
P4	19.05.23	Issued for Planning
P3	23.03.23	Issued for Planning
P2	15.03.23	Issued for Planning
P1	24.02.23	Issued for Planning
I/R	DATE	DESCRIPTION

PROJECT NUMBER


05-868

SHEET TITLE

Site Location Map - Sheet 01 of 02

SHEET NUMBER

05868-DR-003

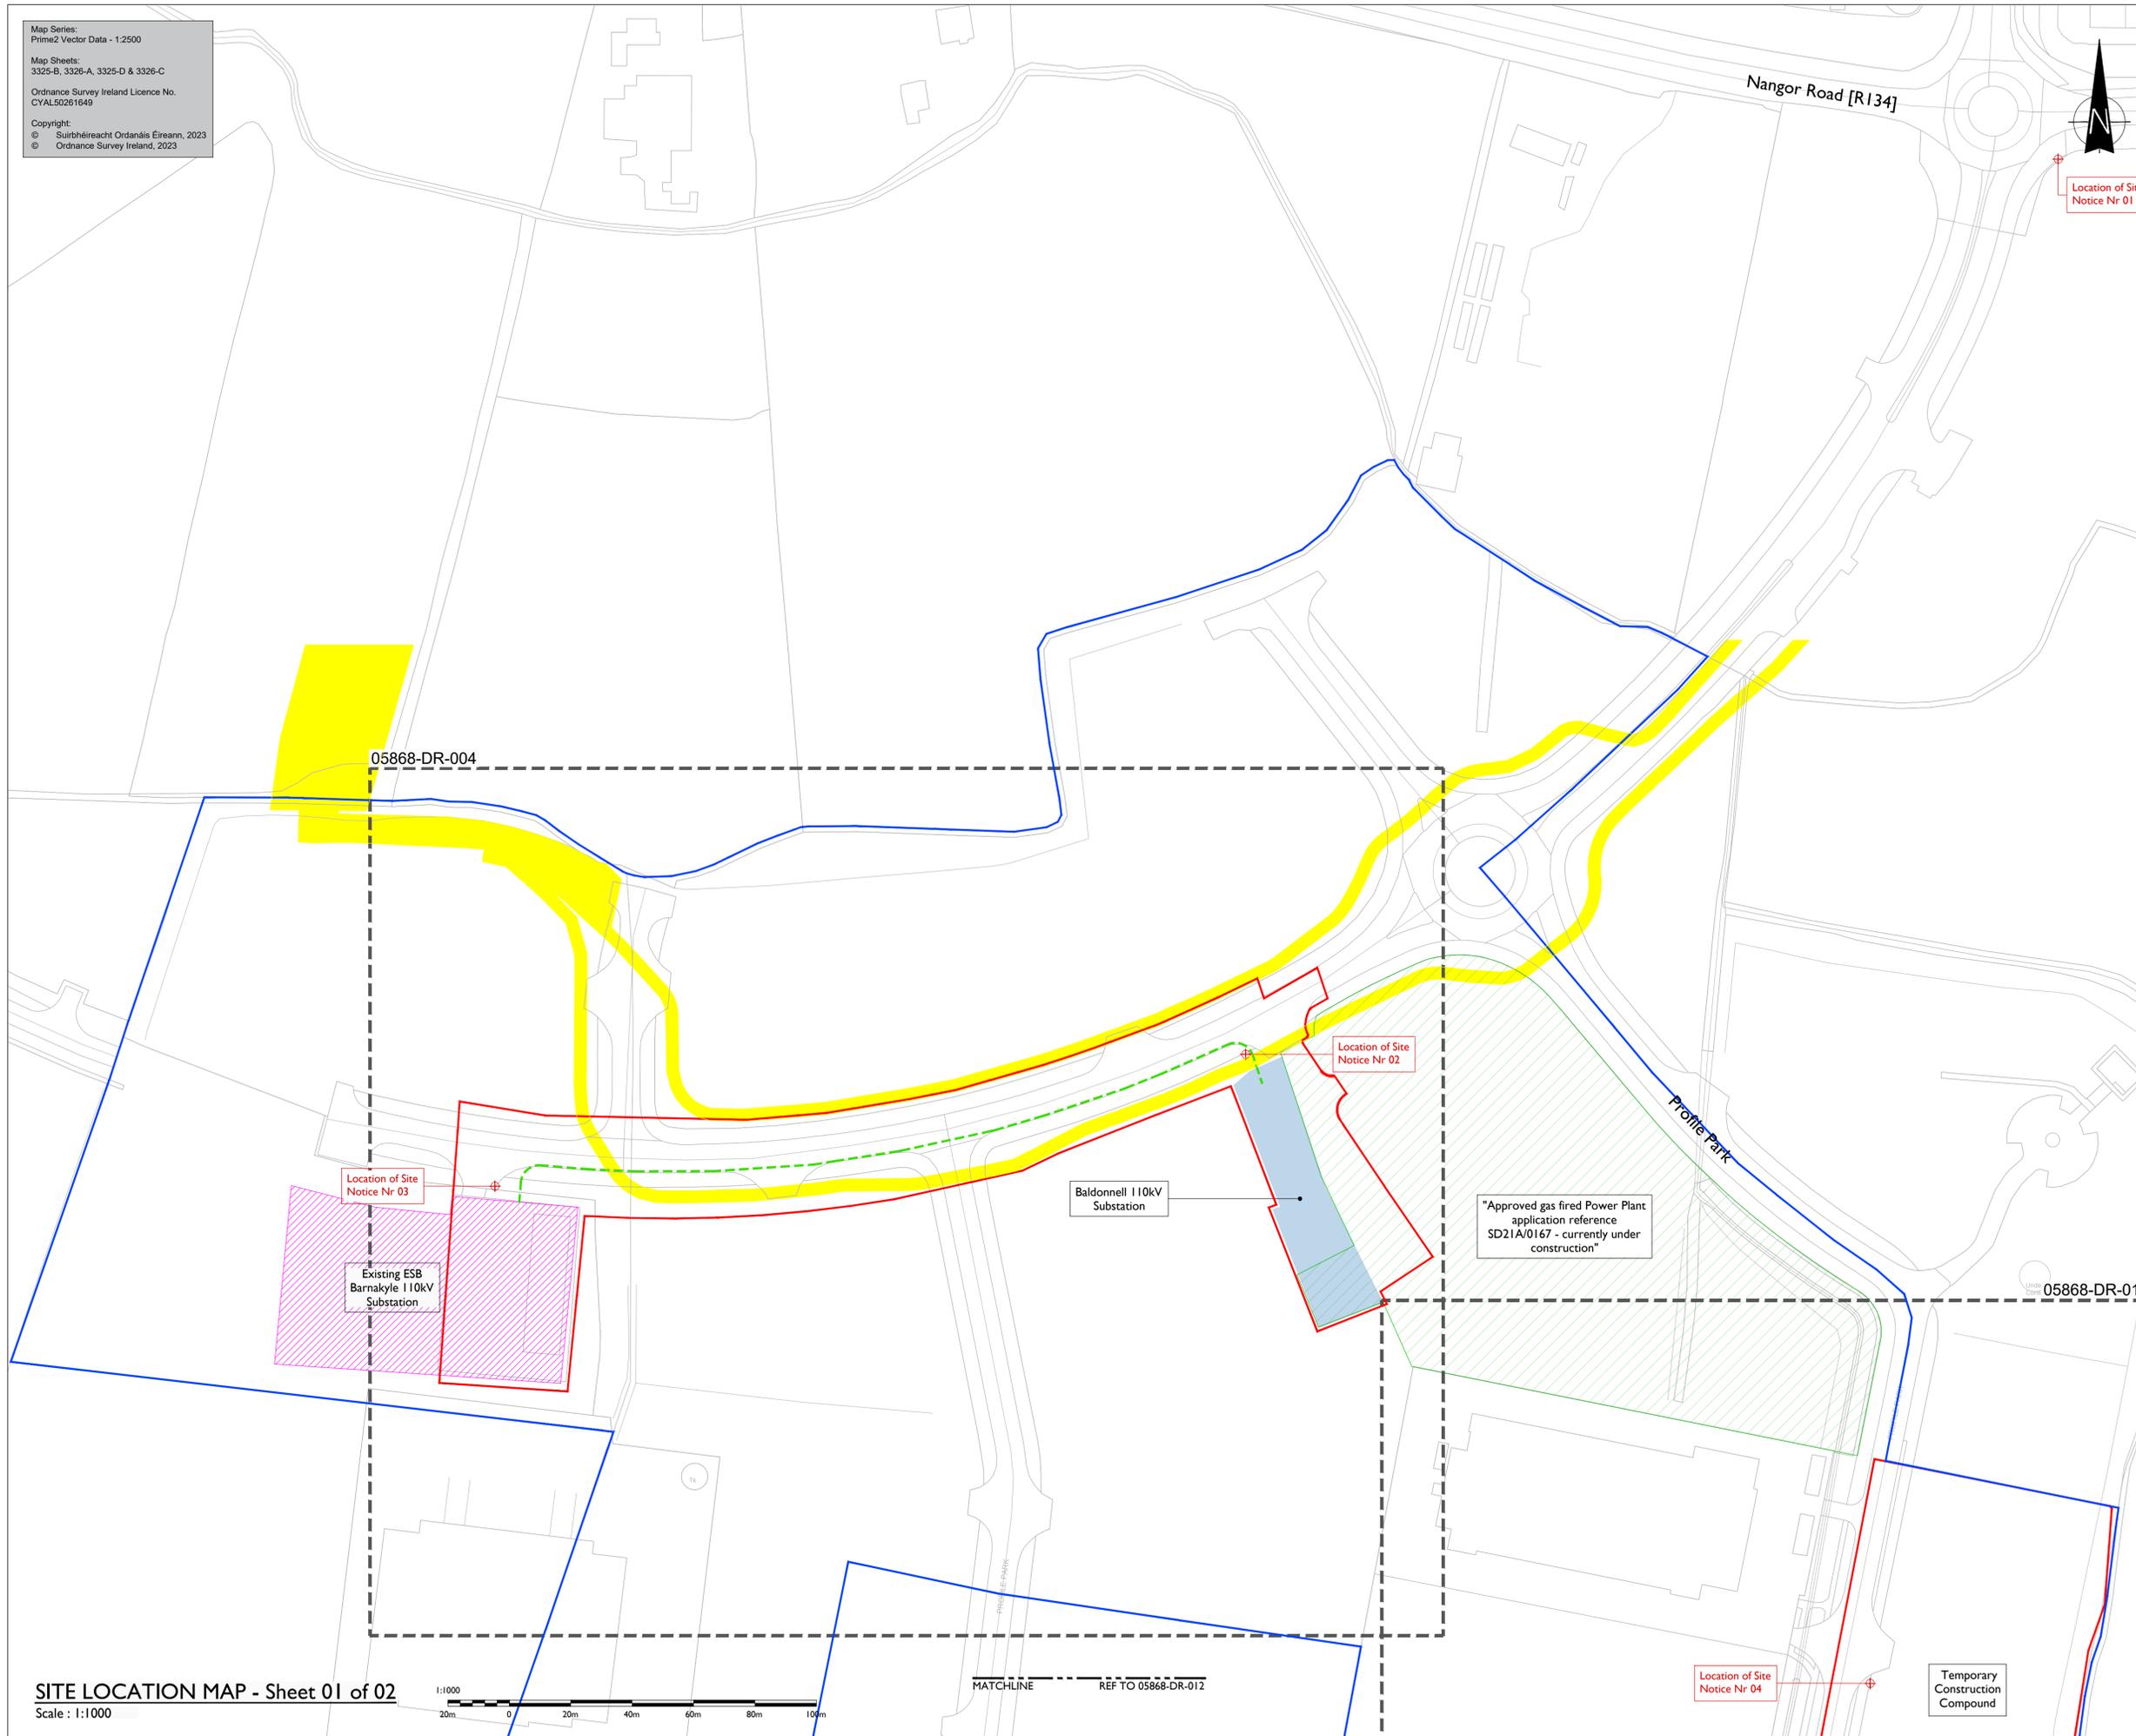

SITE LOCATION MAP - Sheet 01 of 02
Scale : 1:1000



MATCHLINE REF TO 05868-DR-012