
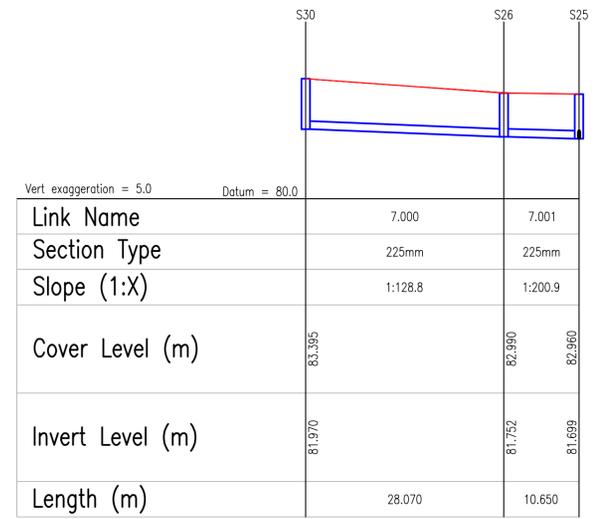
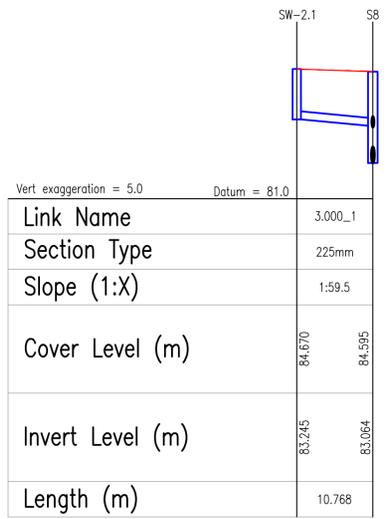
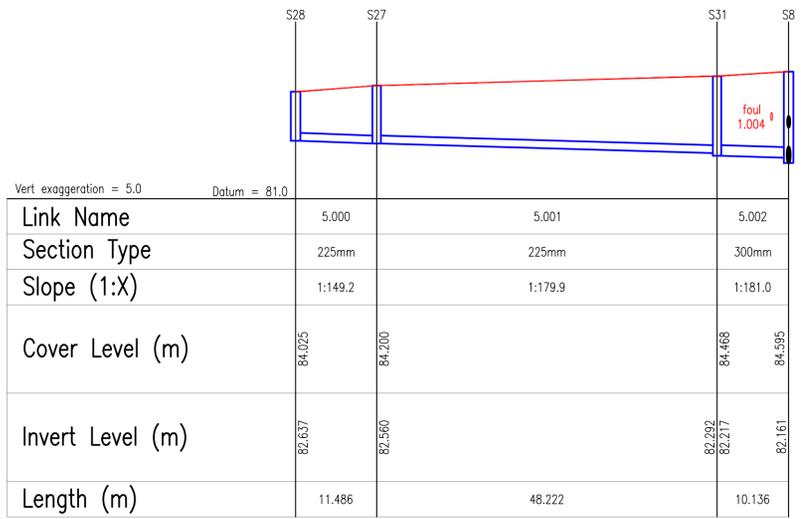


ALL TRENCHES IN EXPOSED ROCK TO BE LINED WITH LIQUID BITUMEN SPRAY IMMEDIATELY AFTER EXPOSURE.

- NOTES:
- DO NOT SCALE. USE FIGURED DIMENSIONS ONLY.
 - THIS DRAWING IS TO BE READ IN CONJUNCTION WITH ALL OTHER RELEVANT ARCHITECTURAL AND ENGINEERING DRAWINGS.

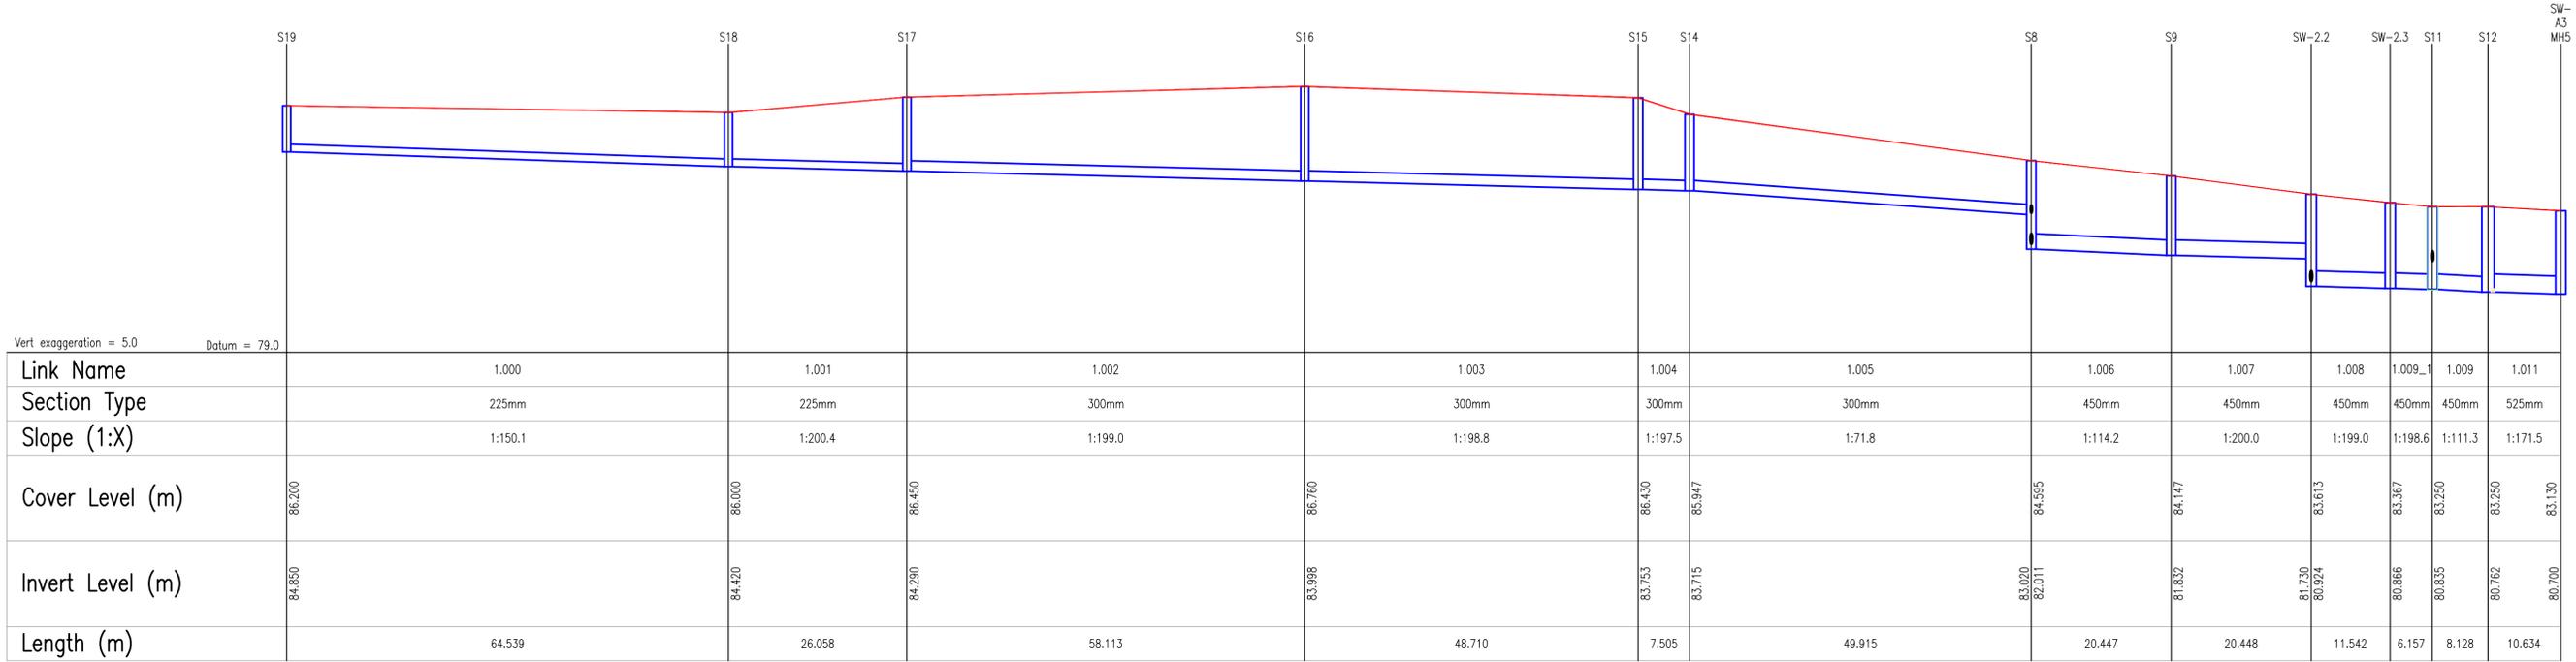

REF:
CDS23001981

REFER TO DRAWING
20-074-T4200 FOR THE PLAN
VIEW OF THE DRAINAGE LAYOUT

REV.	DATE	AMENDMENT	DRN	APPD
-	31/05/23	ISSUED FOR PLANNING	MS	IW

STATUS **FOR PLANNING**

Waterman Moylan
Engineering Consultants

BLOCK 6, EASTPOINT BUSINESS PARK, ALFIE BYRNE ROAD,
DUBLIN D03 H3F4 IRELAND. Tel: (01) 664 8900
Email: info@waterman-moylan.ie www.waterman-moylan.ie

CLIENT **FINGAL COUNTY COUNCIL**
ARCHITECT **WALSH & ASSOCIATES**
PROJECT **CHURCH FIELDS EAST**
TITLE **SURFACE WATER LONG SECTIONS - SHEET 1 OF 2**

DRAWN MS	DESIGNED JB	APPROVED IW	DATE MAY 2023
SCALE 1:500@A1	JOB NO. 20-074	DRG. NO. T4240	REVISION -