
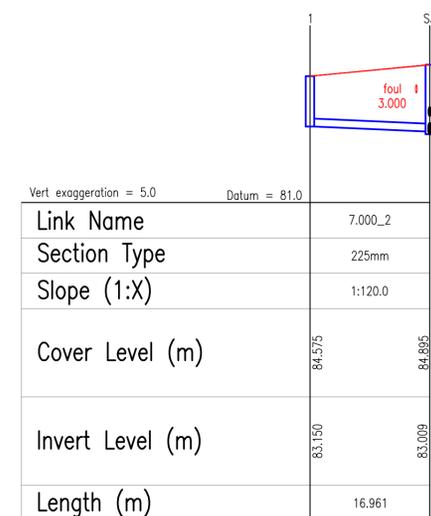
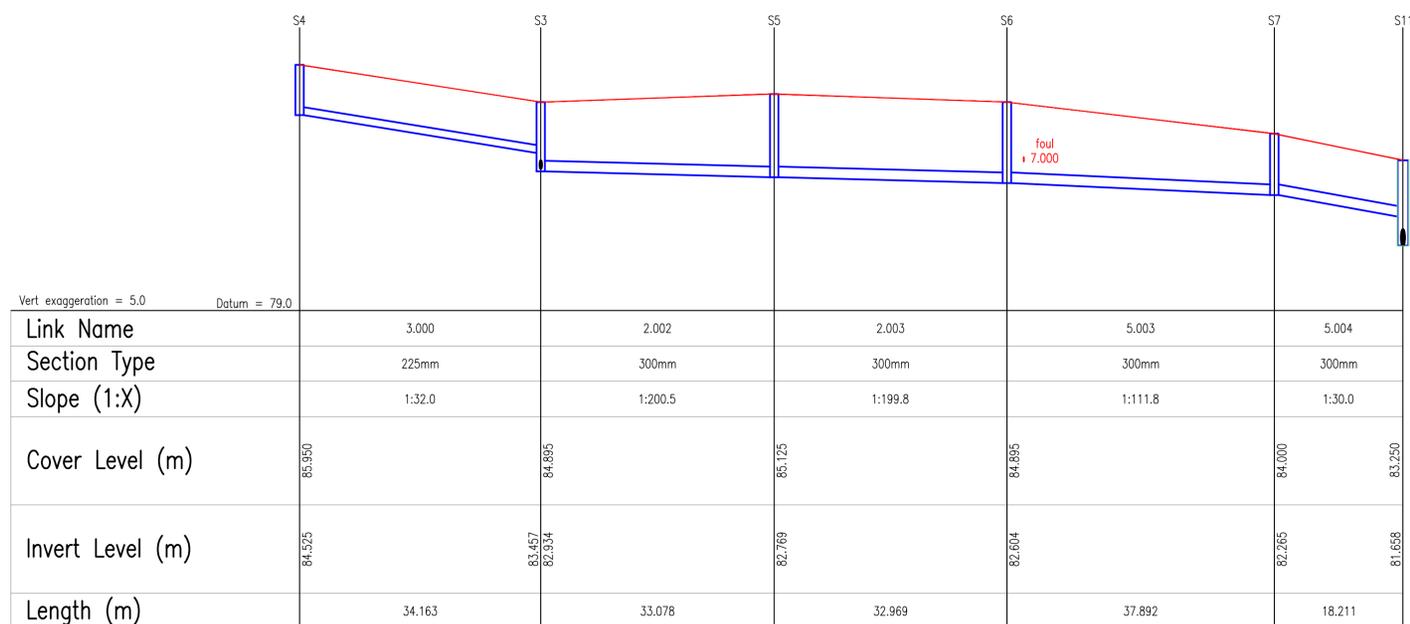
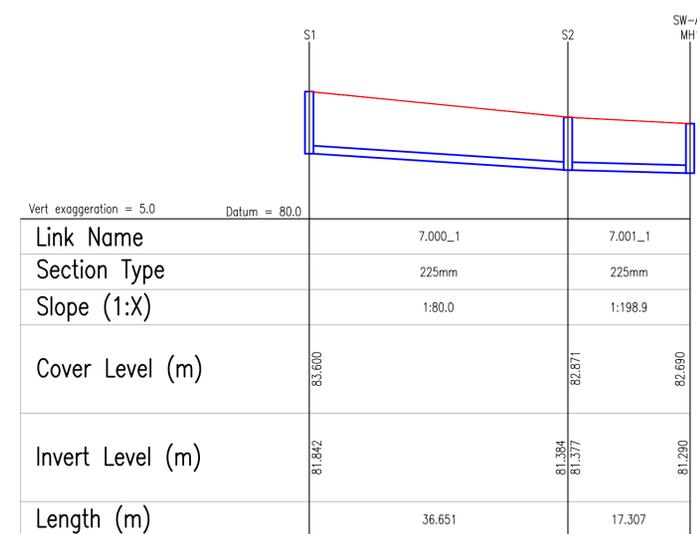


- NOTES:
- DO NOT SCALE. USE FIGURED DIMENSIONS ONLY.
 - THIS DRAWING IS TO BE READ IN CONJUNCTION WITH ALL OTHER RELEVANT ARCHITECTURAL AND ENGINEERING DRAWINGS.

ALL TRENCHES IN EXPOSED ROCK TO BE LINED WITH LIQUID BITUMEN SPRAY IMMEDIATELY AFTER EXPOSURE.

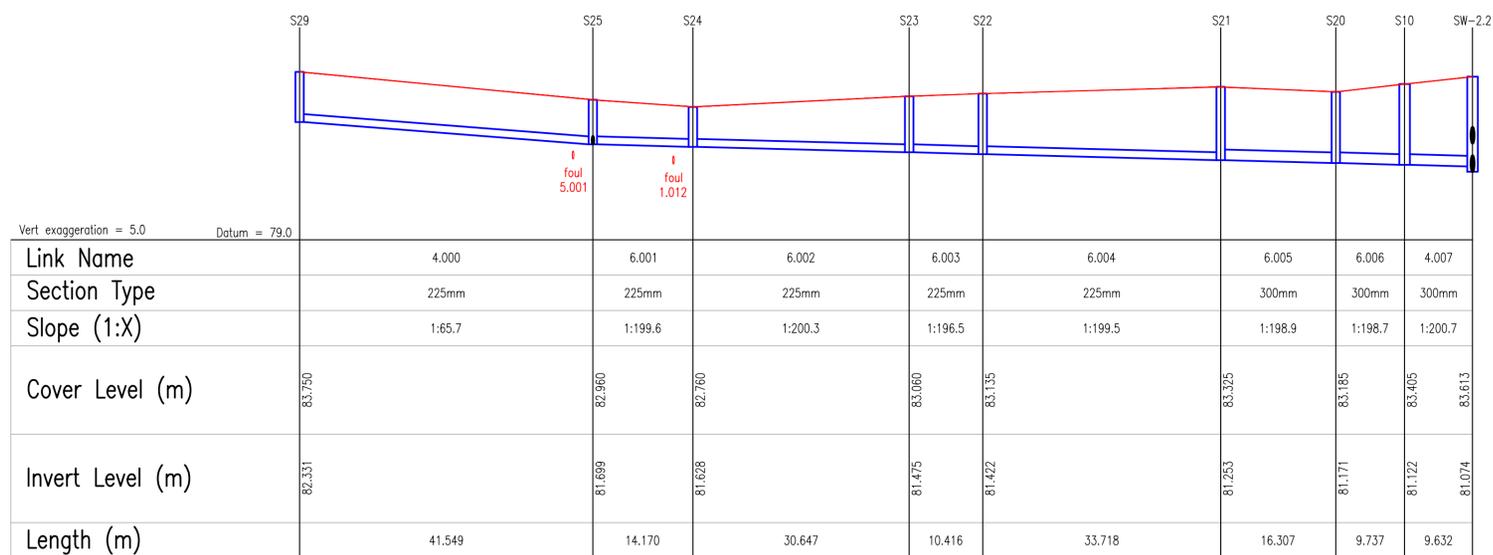

REF:
CDS23001981

REFER TO DRAWING
20-074-T4200 FOR THE PLAN
VIEW OF THE DRAINAGE LAYOUT

REV.	DATE	AMENDMENT	DRN	APPD
-	31/05/23	ISSUED FOR PLANNING	MS	IW

STATUS **FOR PLANNING**

Waterman Moylan
Engineering Consultants

BLOCK 5, EASTPOINT BUSINESS PARK, ALFIE BYRNE ROAD,
DUBLIN D03 H3F4 IRELAND. Tel: (01) 664 8900
Email: info@waterman-moylan.ie www.waterman-moylan.ie

CLIENT **FINGAL COUNTY COUNCIL**
ARCHITECT **WALSH & ASSOCIATES**
PROJECT **CHURCH FIELDS EAST**

TITLE **SURFACE WATER LONG SECTIONS - SHEET 2 OF 2**

DRAWN MS	DESIGNED JB	APPROVED IW	DATE MAY 2023
SCALE 1:500@A1	JOB NO. 20-074	DRG. NO. T4241	REVISION -