

# AECOM

**PROJECT** 

TARBERT OCGT POWER PLANT

CLIENT

SSE GENERATION IRELAND LTD

#### CONSULTANT

2ND FLOOR, 177 BOTHWELL STREET GLASGOW G2 7ER +44 (0) 141 202 0500 www.AECOM.com

#### NOTES

- PROPOSED ELEVATIONS ARE RELATIVE TO ORDNANCE DATUM POOLBEG
- TO BE PRINTED AT A0
- INTERNAL BUILDING LAYOUT IS SUBJECT TO CHANGE AT DETAILED DESIGN PHASE

CONOR COONEY

# ISSUE/REVISION

ρ			
may ı	В	22/11/2023	FOR PLANNING
=	Α	27/10/2023	FOR COMMENT
client	I/R	DATE	DESCRIPTION
//s			

# PROJECT NUMBER


60695232


# SHEET TITLE


Proposed Gas Turbine Unit Plan, Elevations & Sections Sheet 1 of 3


SHEET NUMBER

60695232-TBT-DR-013

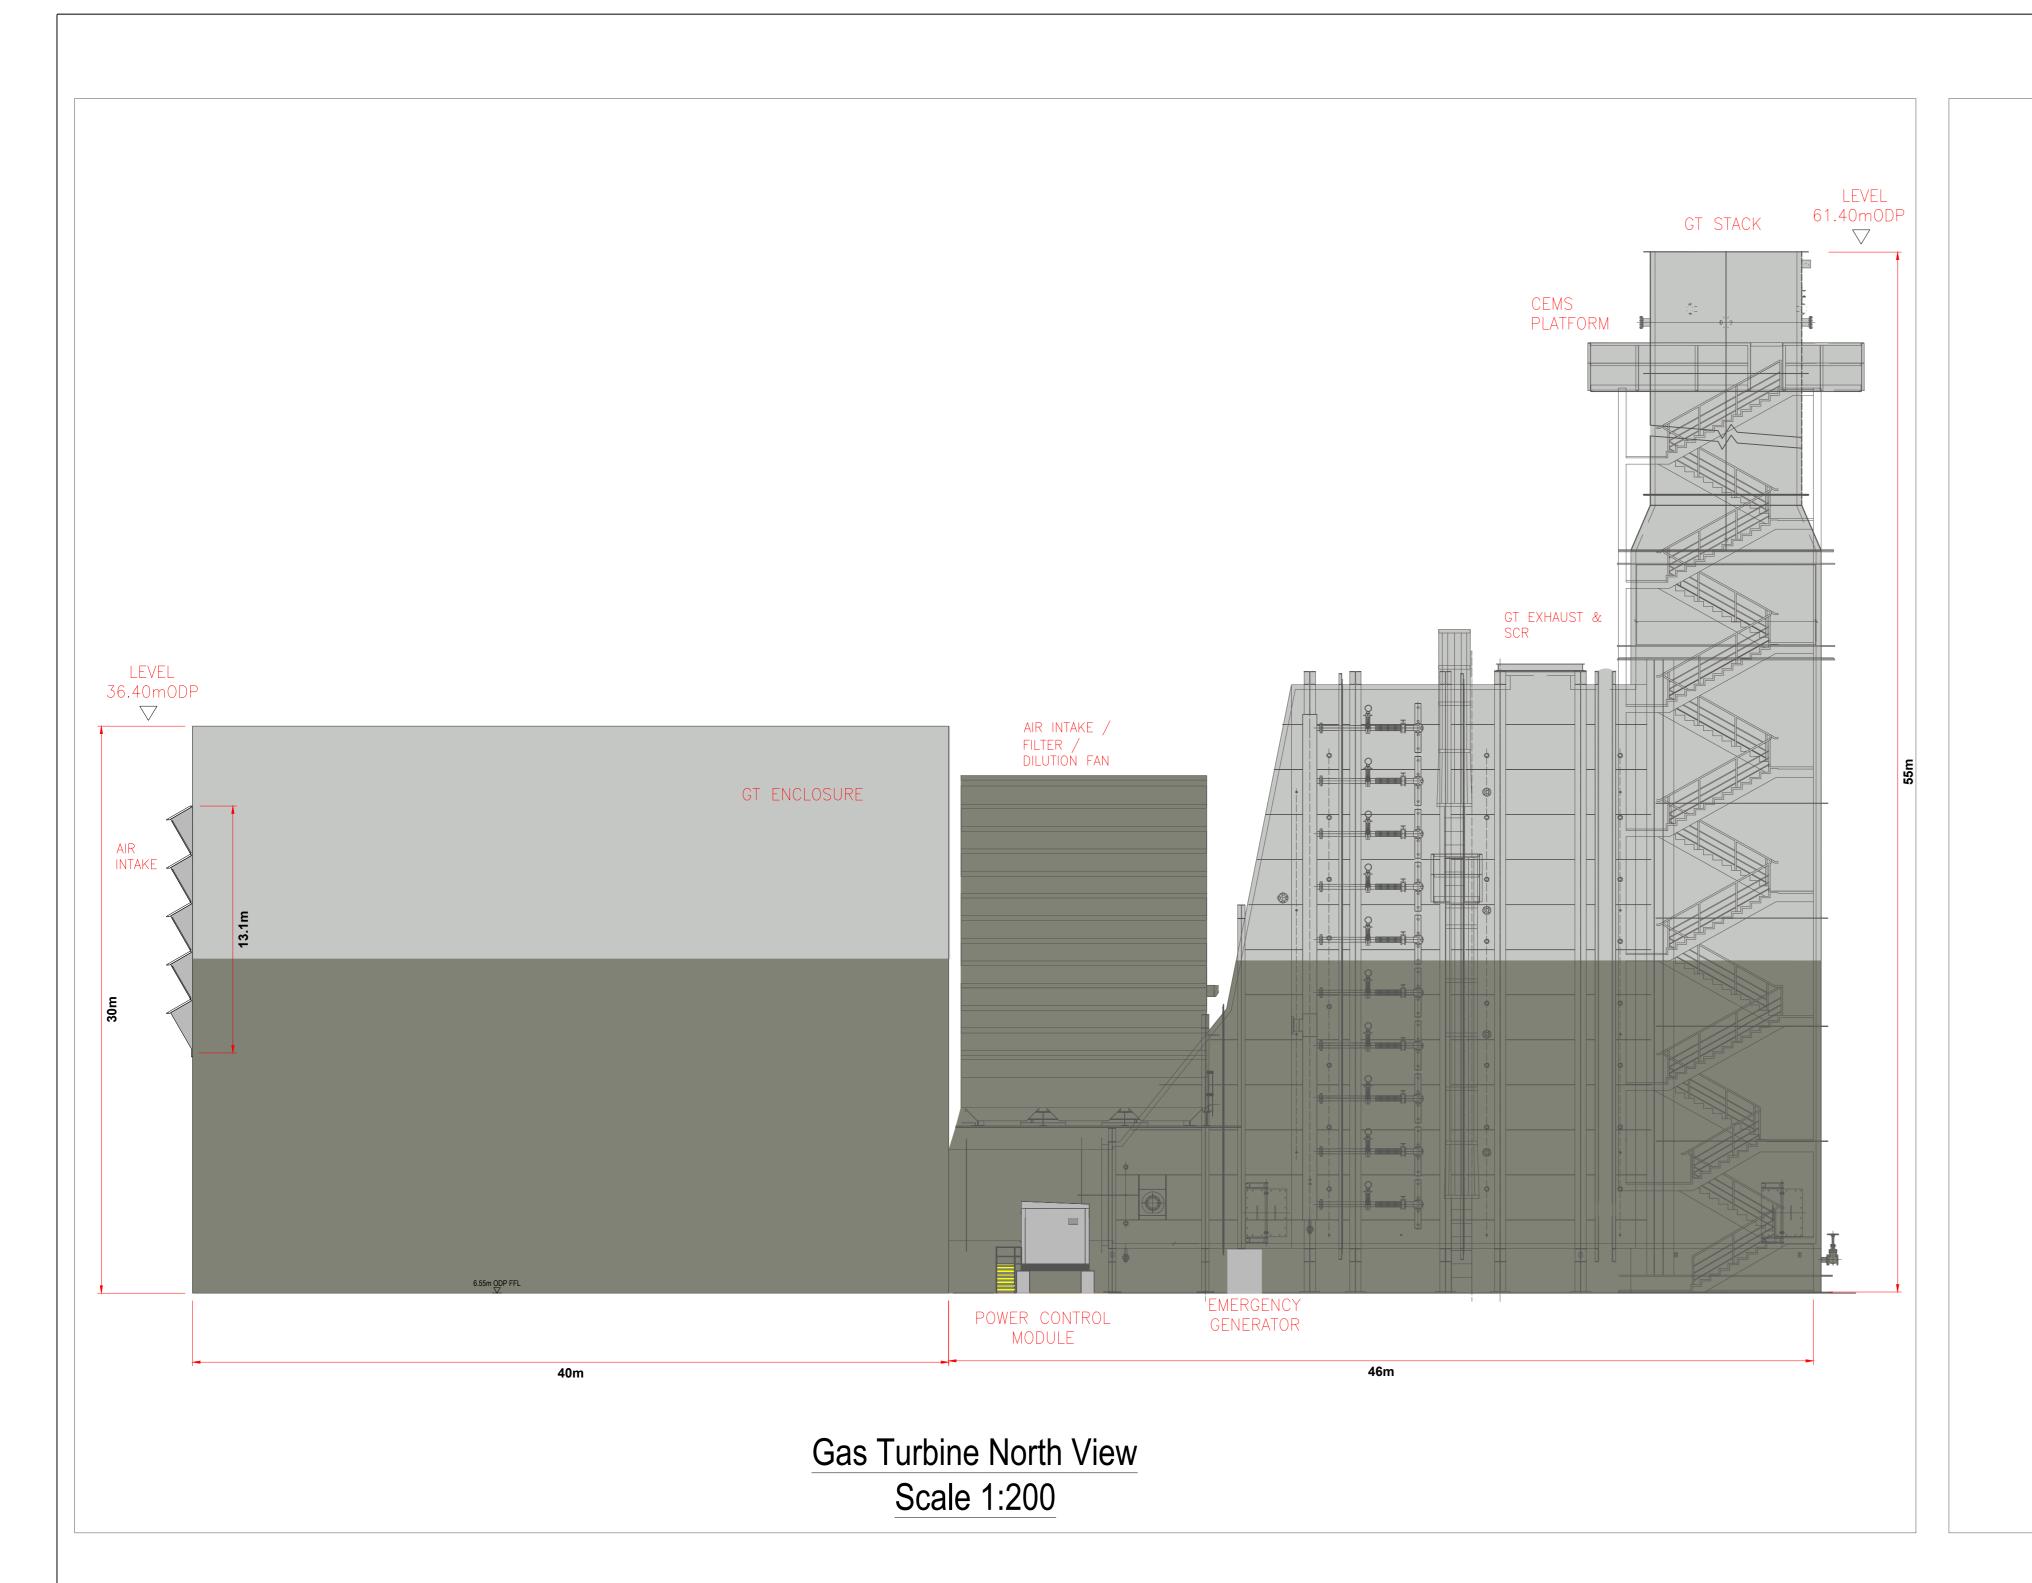

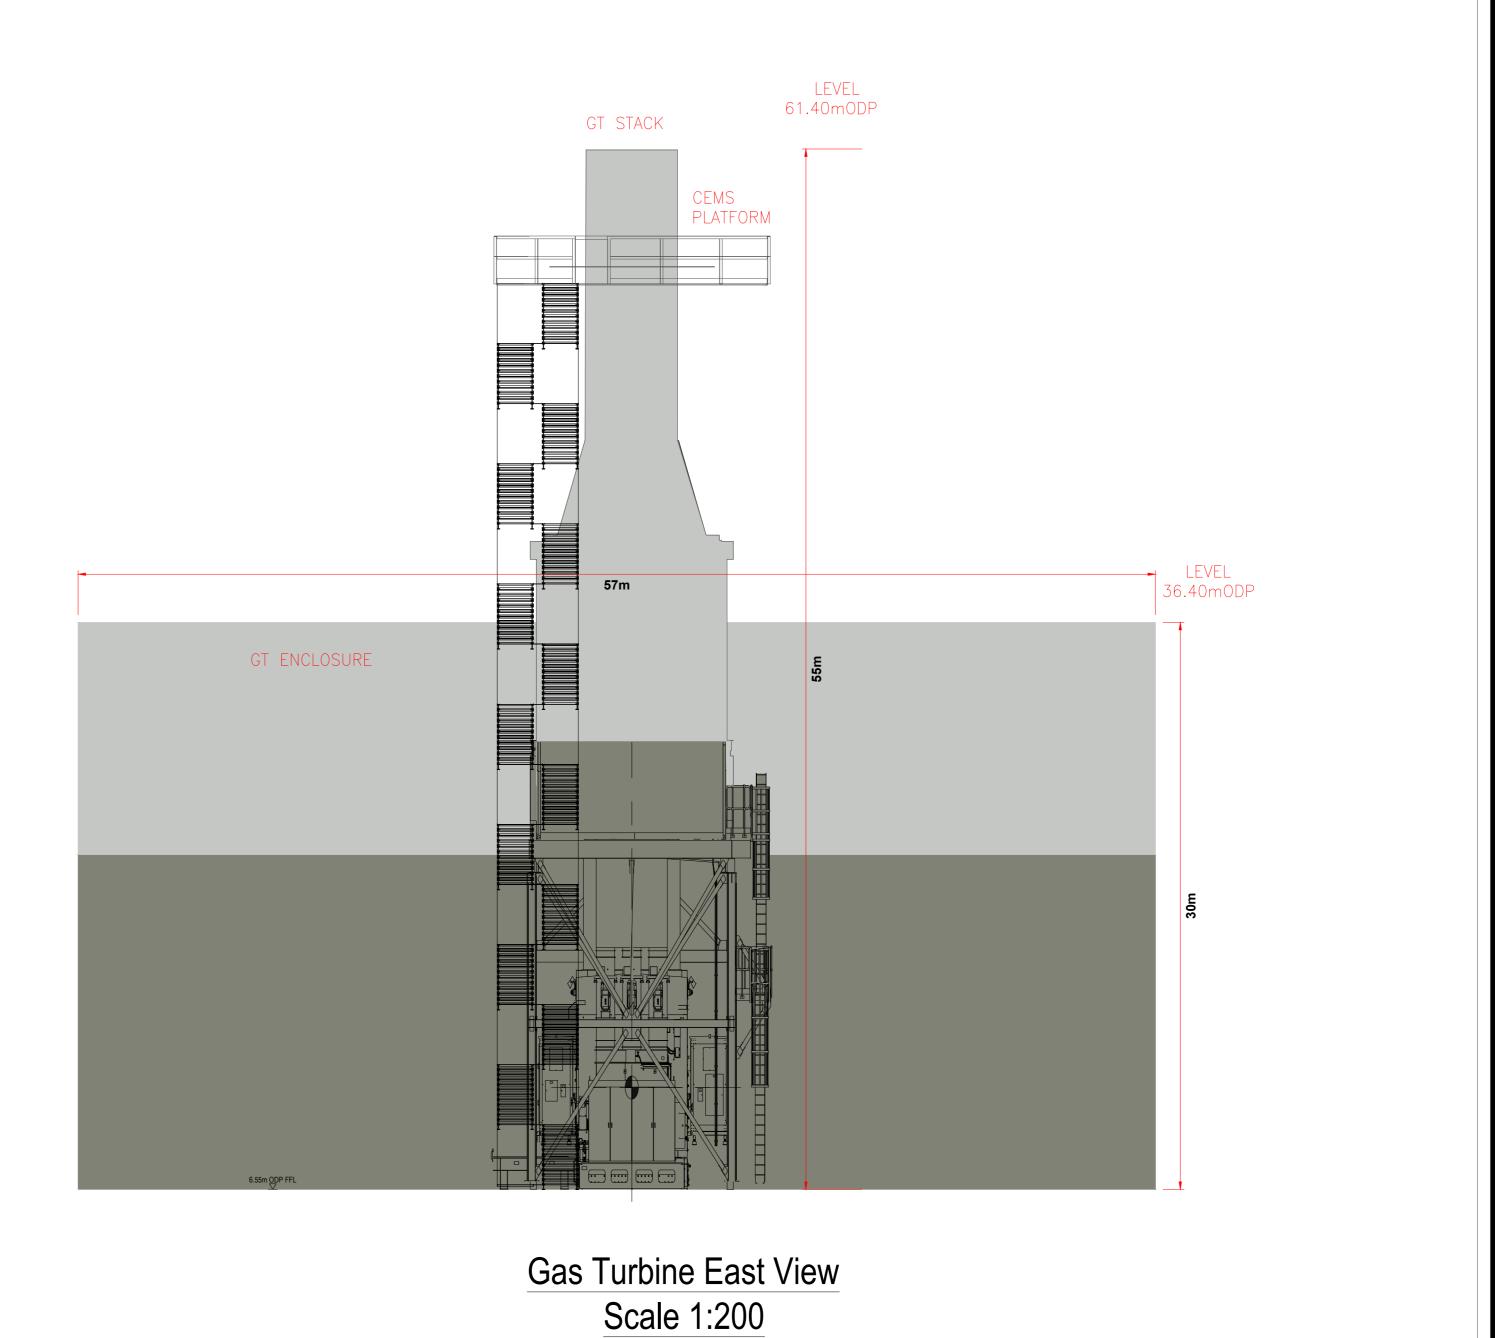

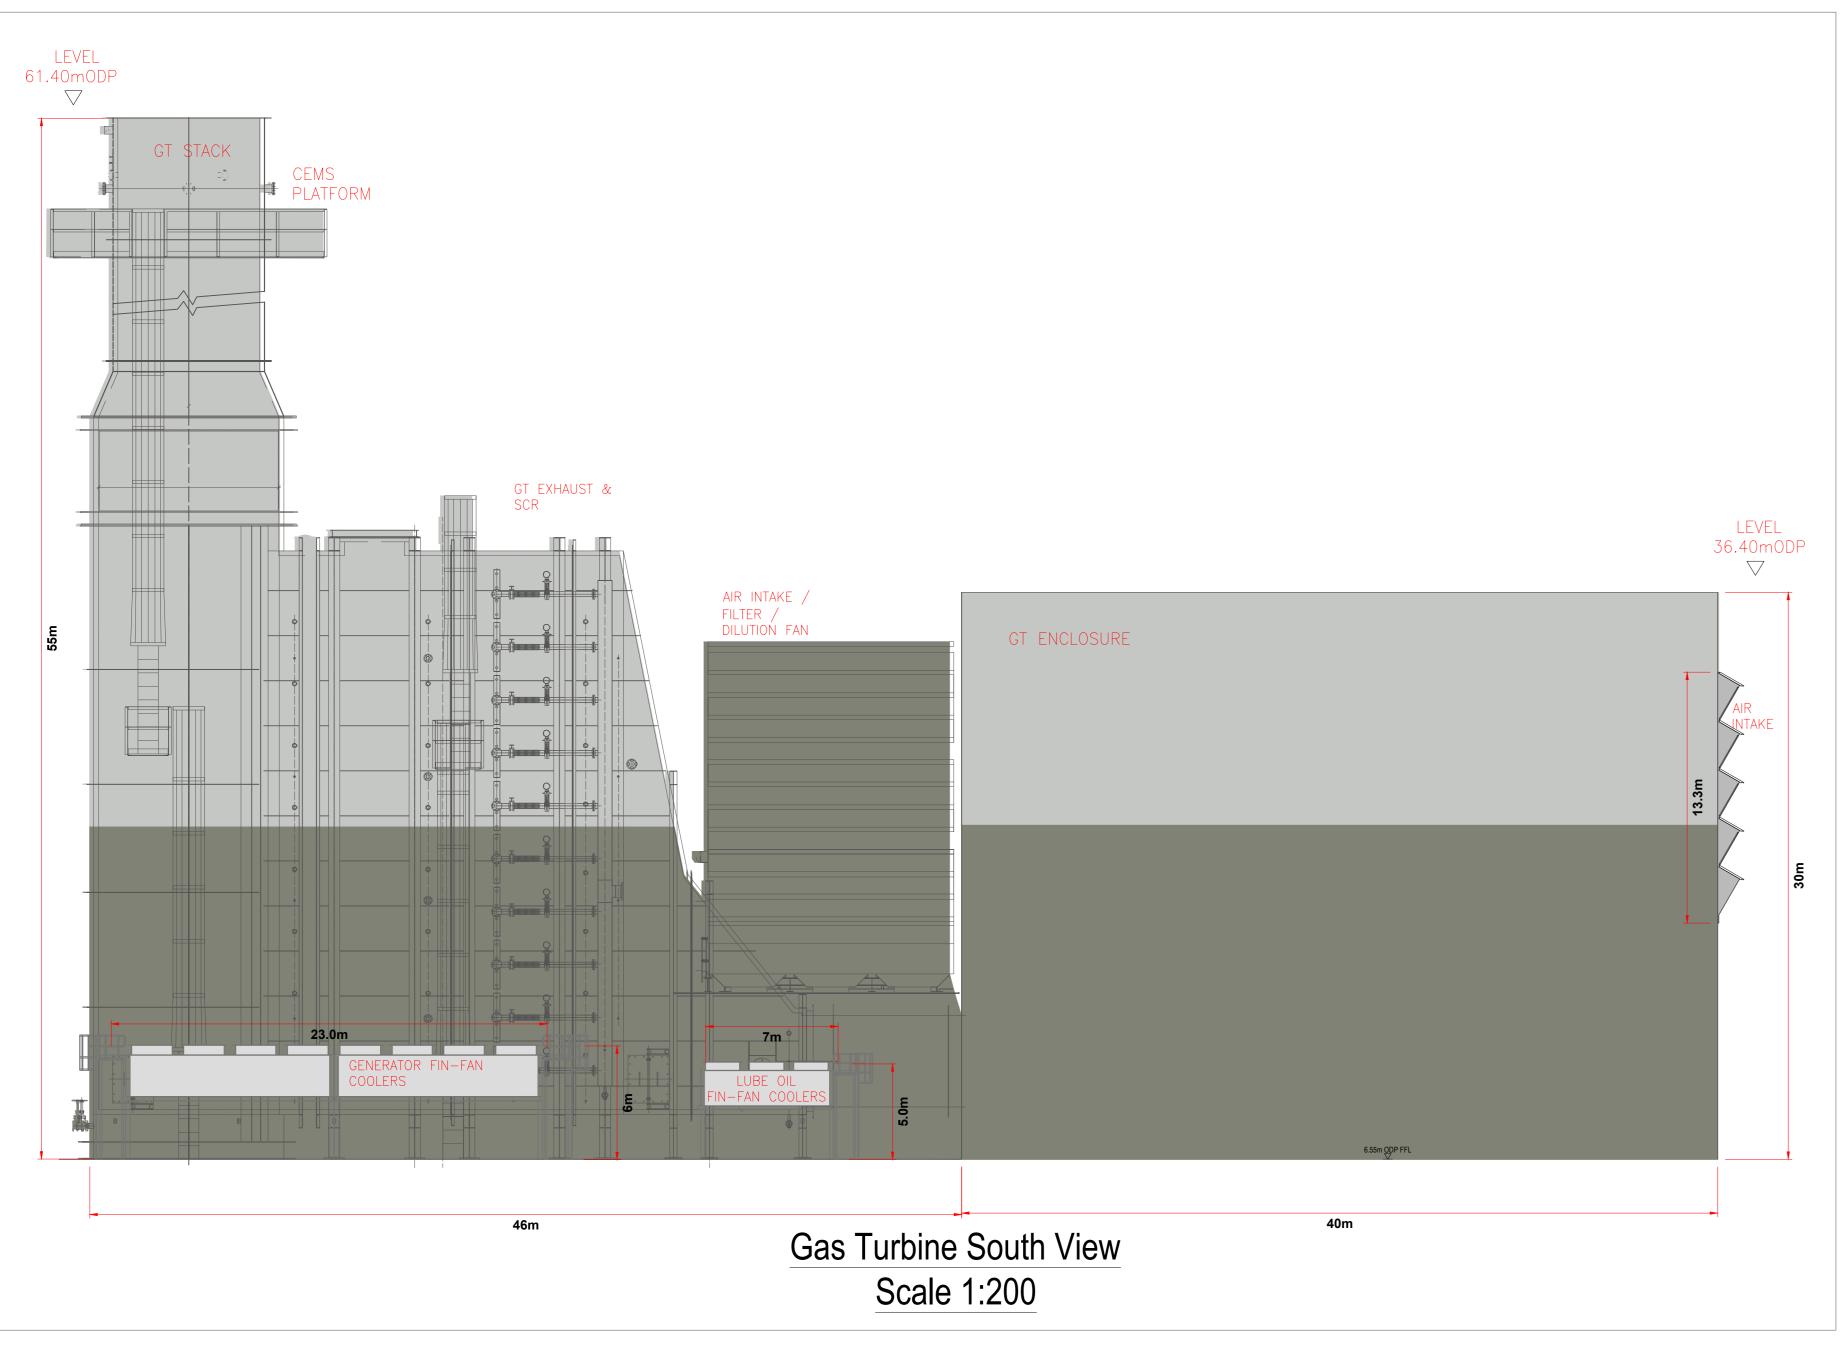

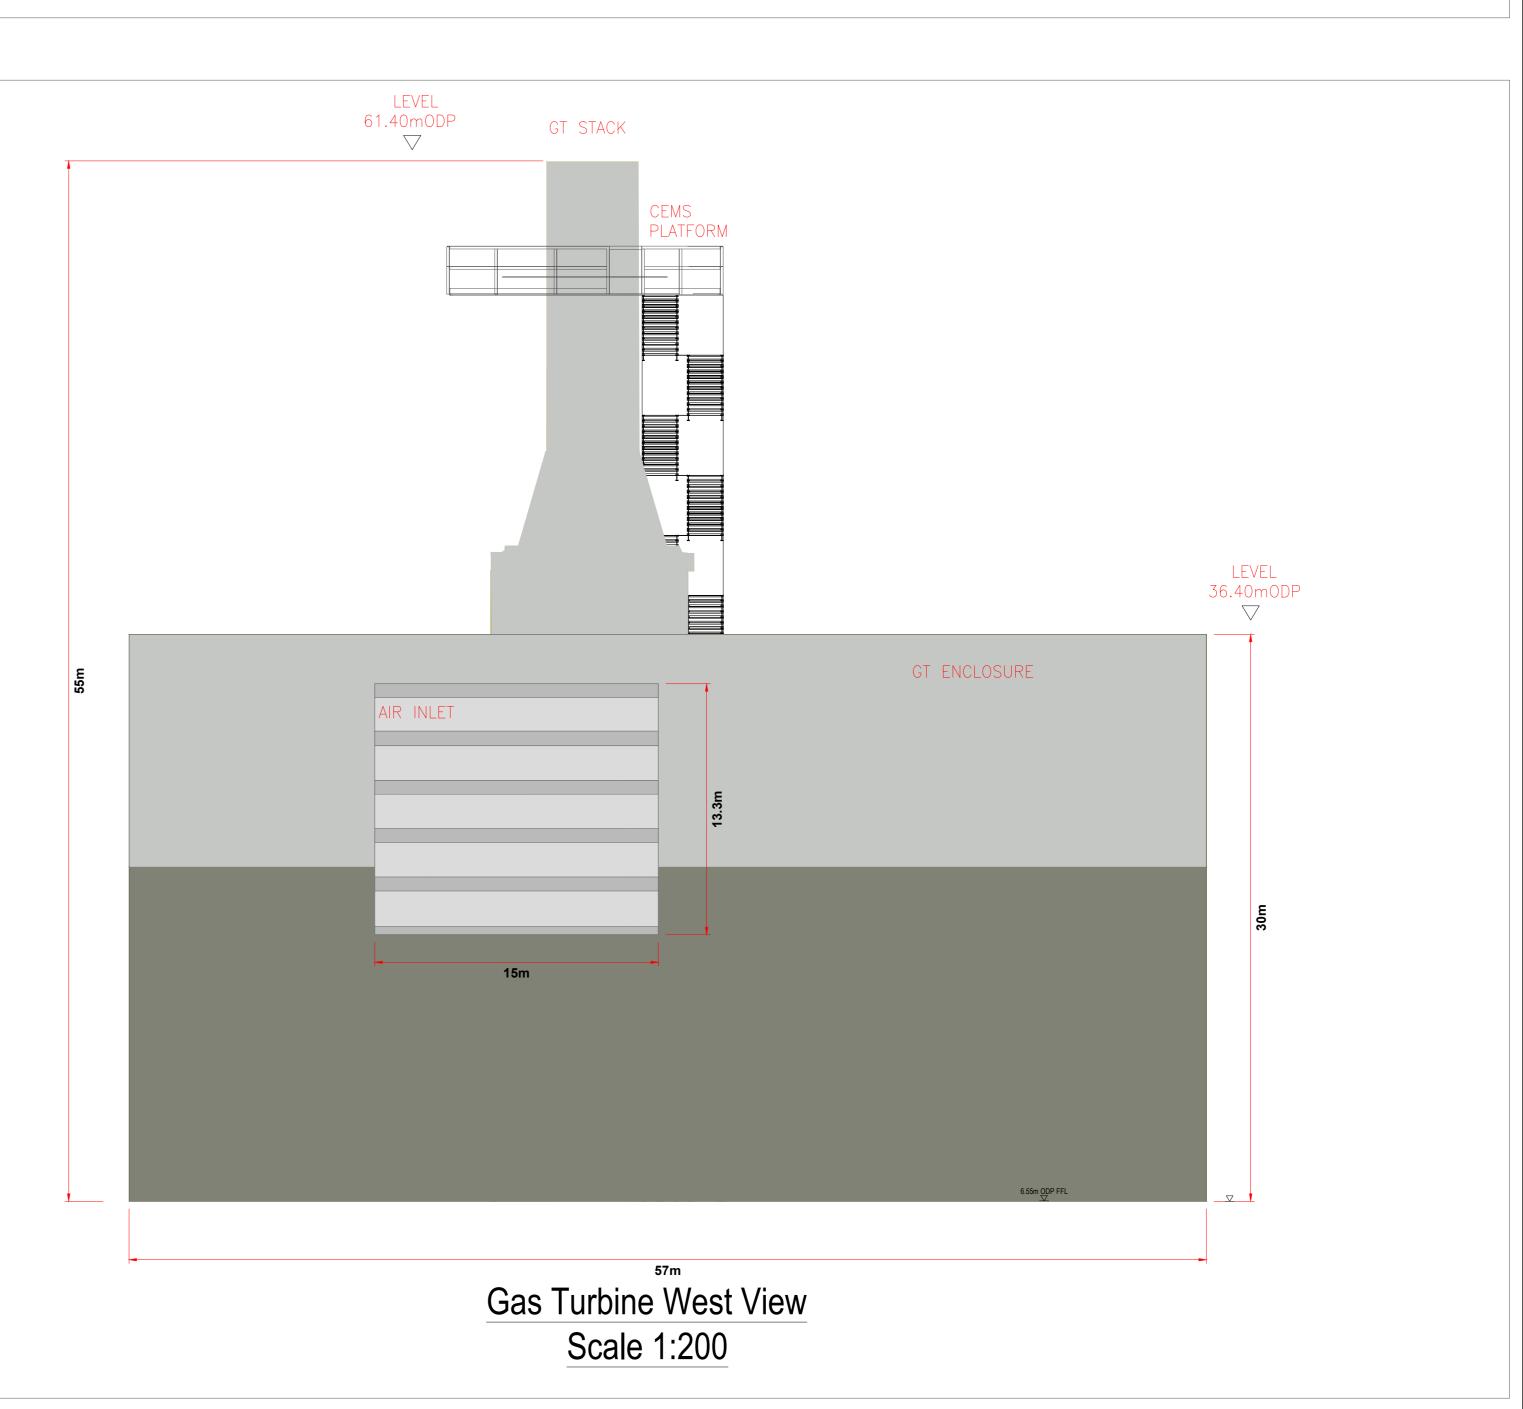

# AECOM

PROJECT

TARBERT OCGT POWER PLANT

CLIENT

SSE GENERATION IRELAND LTD

#### CONSULTANT

AECOM 2ND FLOOR, 177 BOTHWELL STREET GLASGOW G2 7ER +44 (0) 141 202 0500 www.AECOM.com

#### NOT

- PROPOSED ELEVATIONS ARE RELATIVE TO ORDNANCE DATUM POOLBEG
- 2. TO BE PRINTED AT A0
- REFER TO PROPOSED SITE ELEVATIONS FOR CONTIGUOUS DETAIL

DRAWN BY
CONOR COONEY

# ISSUE/REVISION

9			
client. It may no	В	22/11/2023	FOR PLANNING
	Α	27/10/2023	FOR COMMENT
	I/R	DATE	DESCRIPTION
l's			

# PROJECT NUMBER


60695232


# SHEET TITLE

Proposed Gas Turbine Unit Plan, Elevations & Sections Sheet 2 of 3


# SHEET NUMBER

60695232-TBT-DR-013

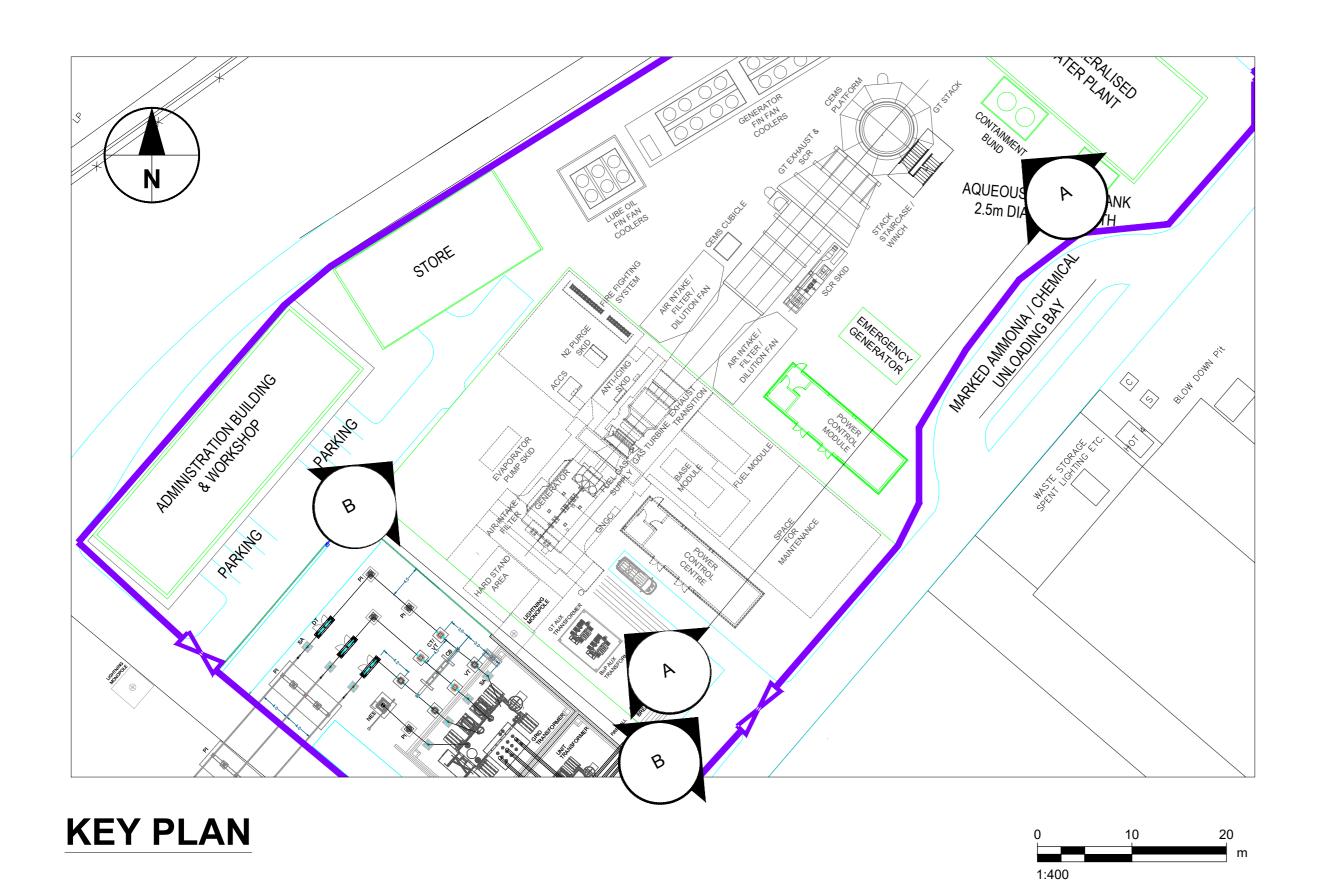

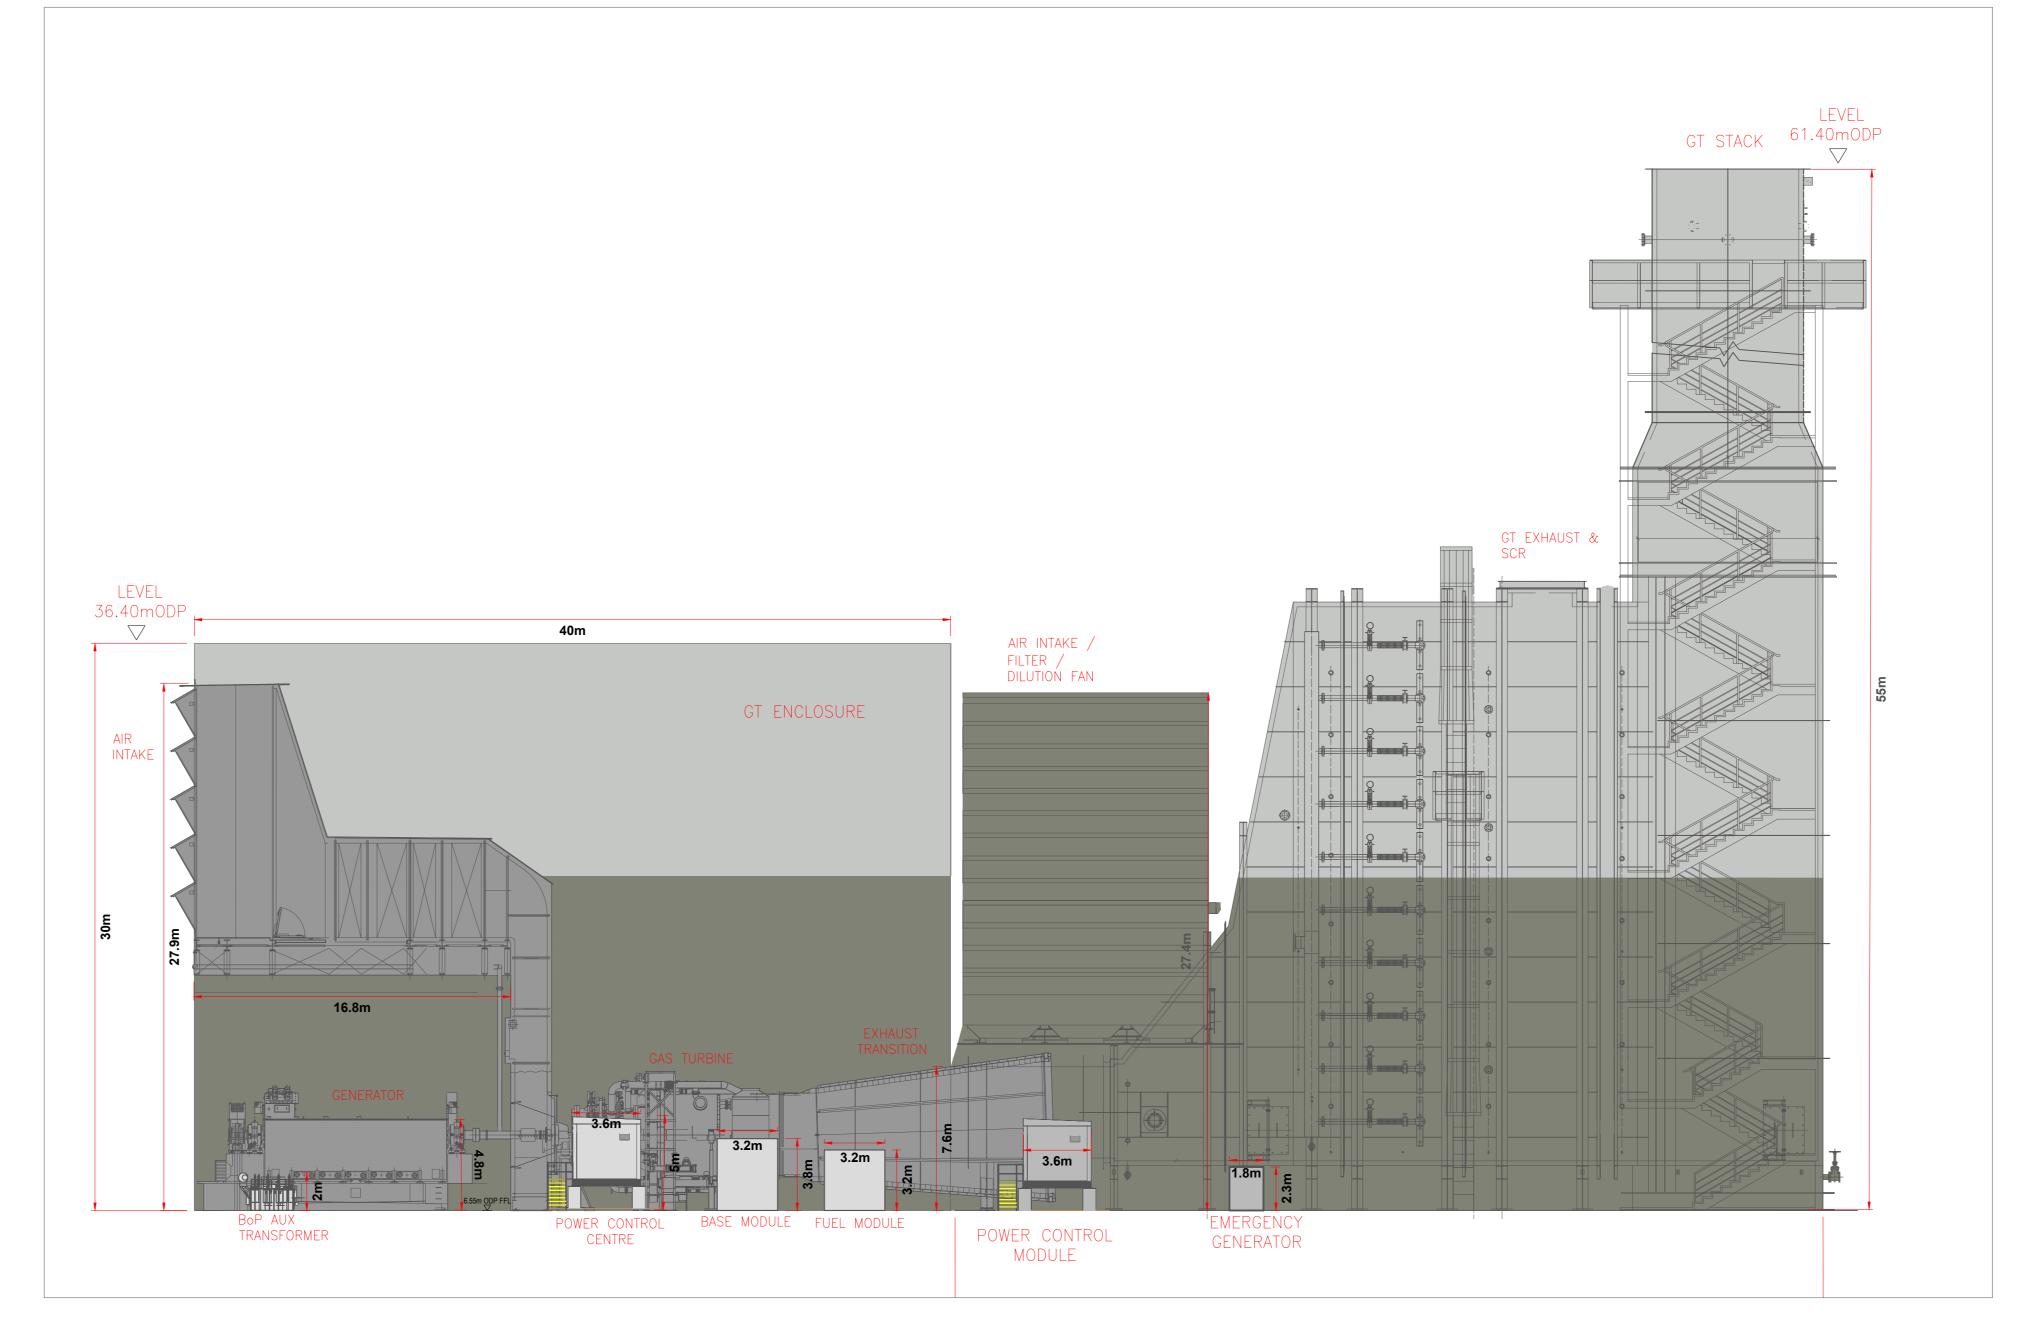



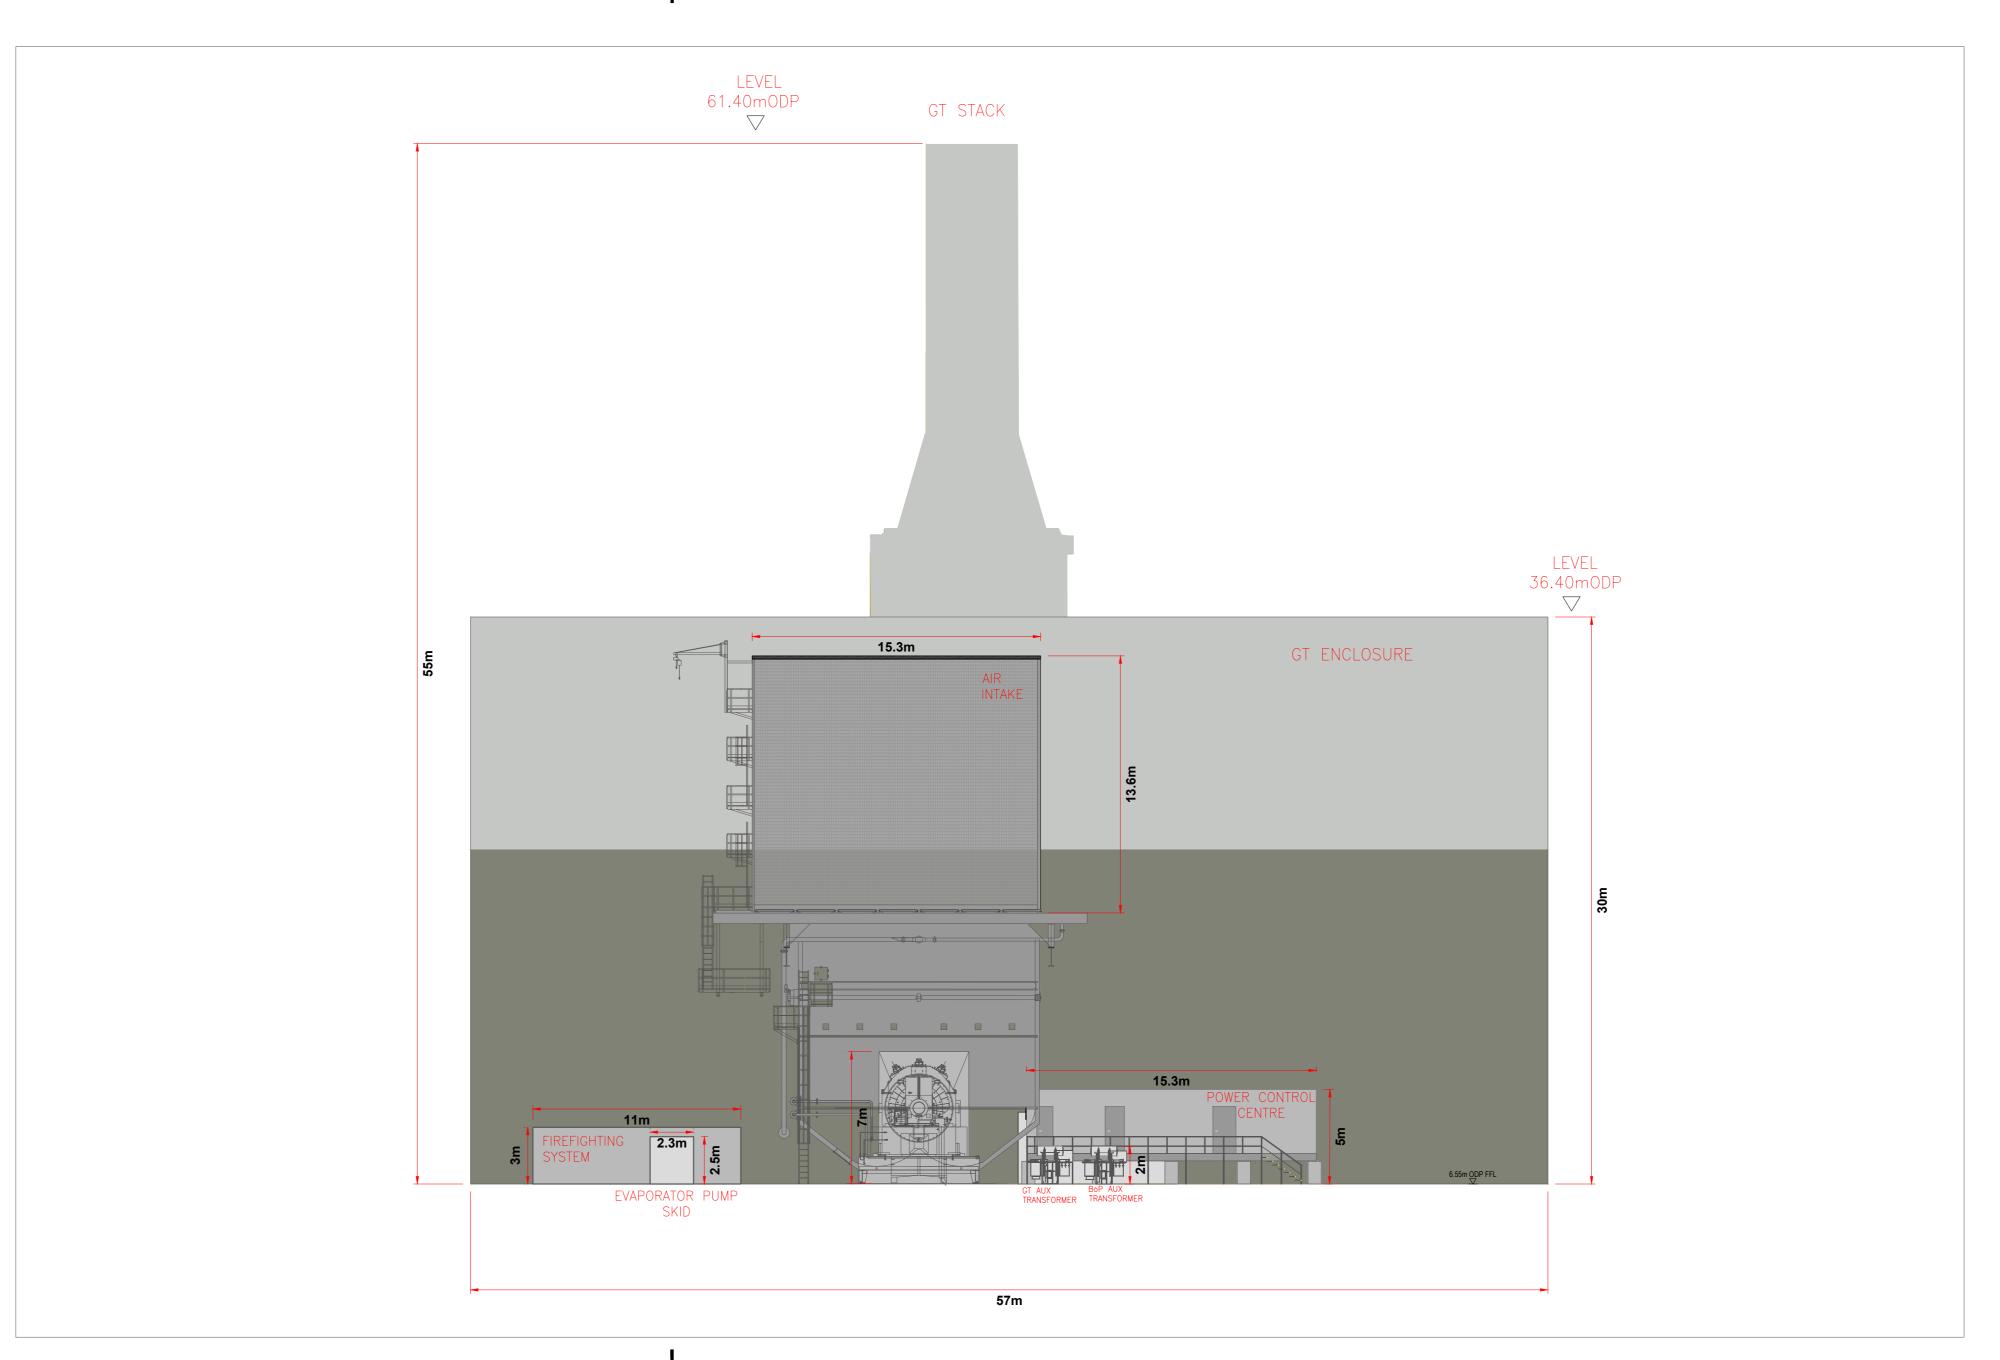

B EAST SECTION
1:200

AECOM

PROJE

TARBERT OCGT POWER PLANT

CLIE

SSE GENERATION IRELAND LTD

#### NOT

- 1. PROPOSED ELEVATIONS ARE RELATIVE TO ORDNANCE DATUM POOLBEG
- 2. TO BE PRINTED AT A0
- 3. INTERNAL BUILDING LAYOUT IS SUBJECT TO CHANGE AT DETAILED DESIGN PHASE

DRAWN BY

CONOR COONEY

# ISSUE/REVISION

client. It may not b			
	В	22/11/2023	FOR PLANNING
	Α	27/10/2023	FOR COMMENT
	I/R	DATE	DESCRIPTION
S			·

PROJECT NUMBER

60695232

SHEET TITLE

Proposed Gas Turbine Unit Plan, Elevations & Sections Sheet 3 of 3

SHEET NUMBER

60695232-TBT-DR-013