


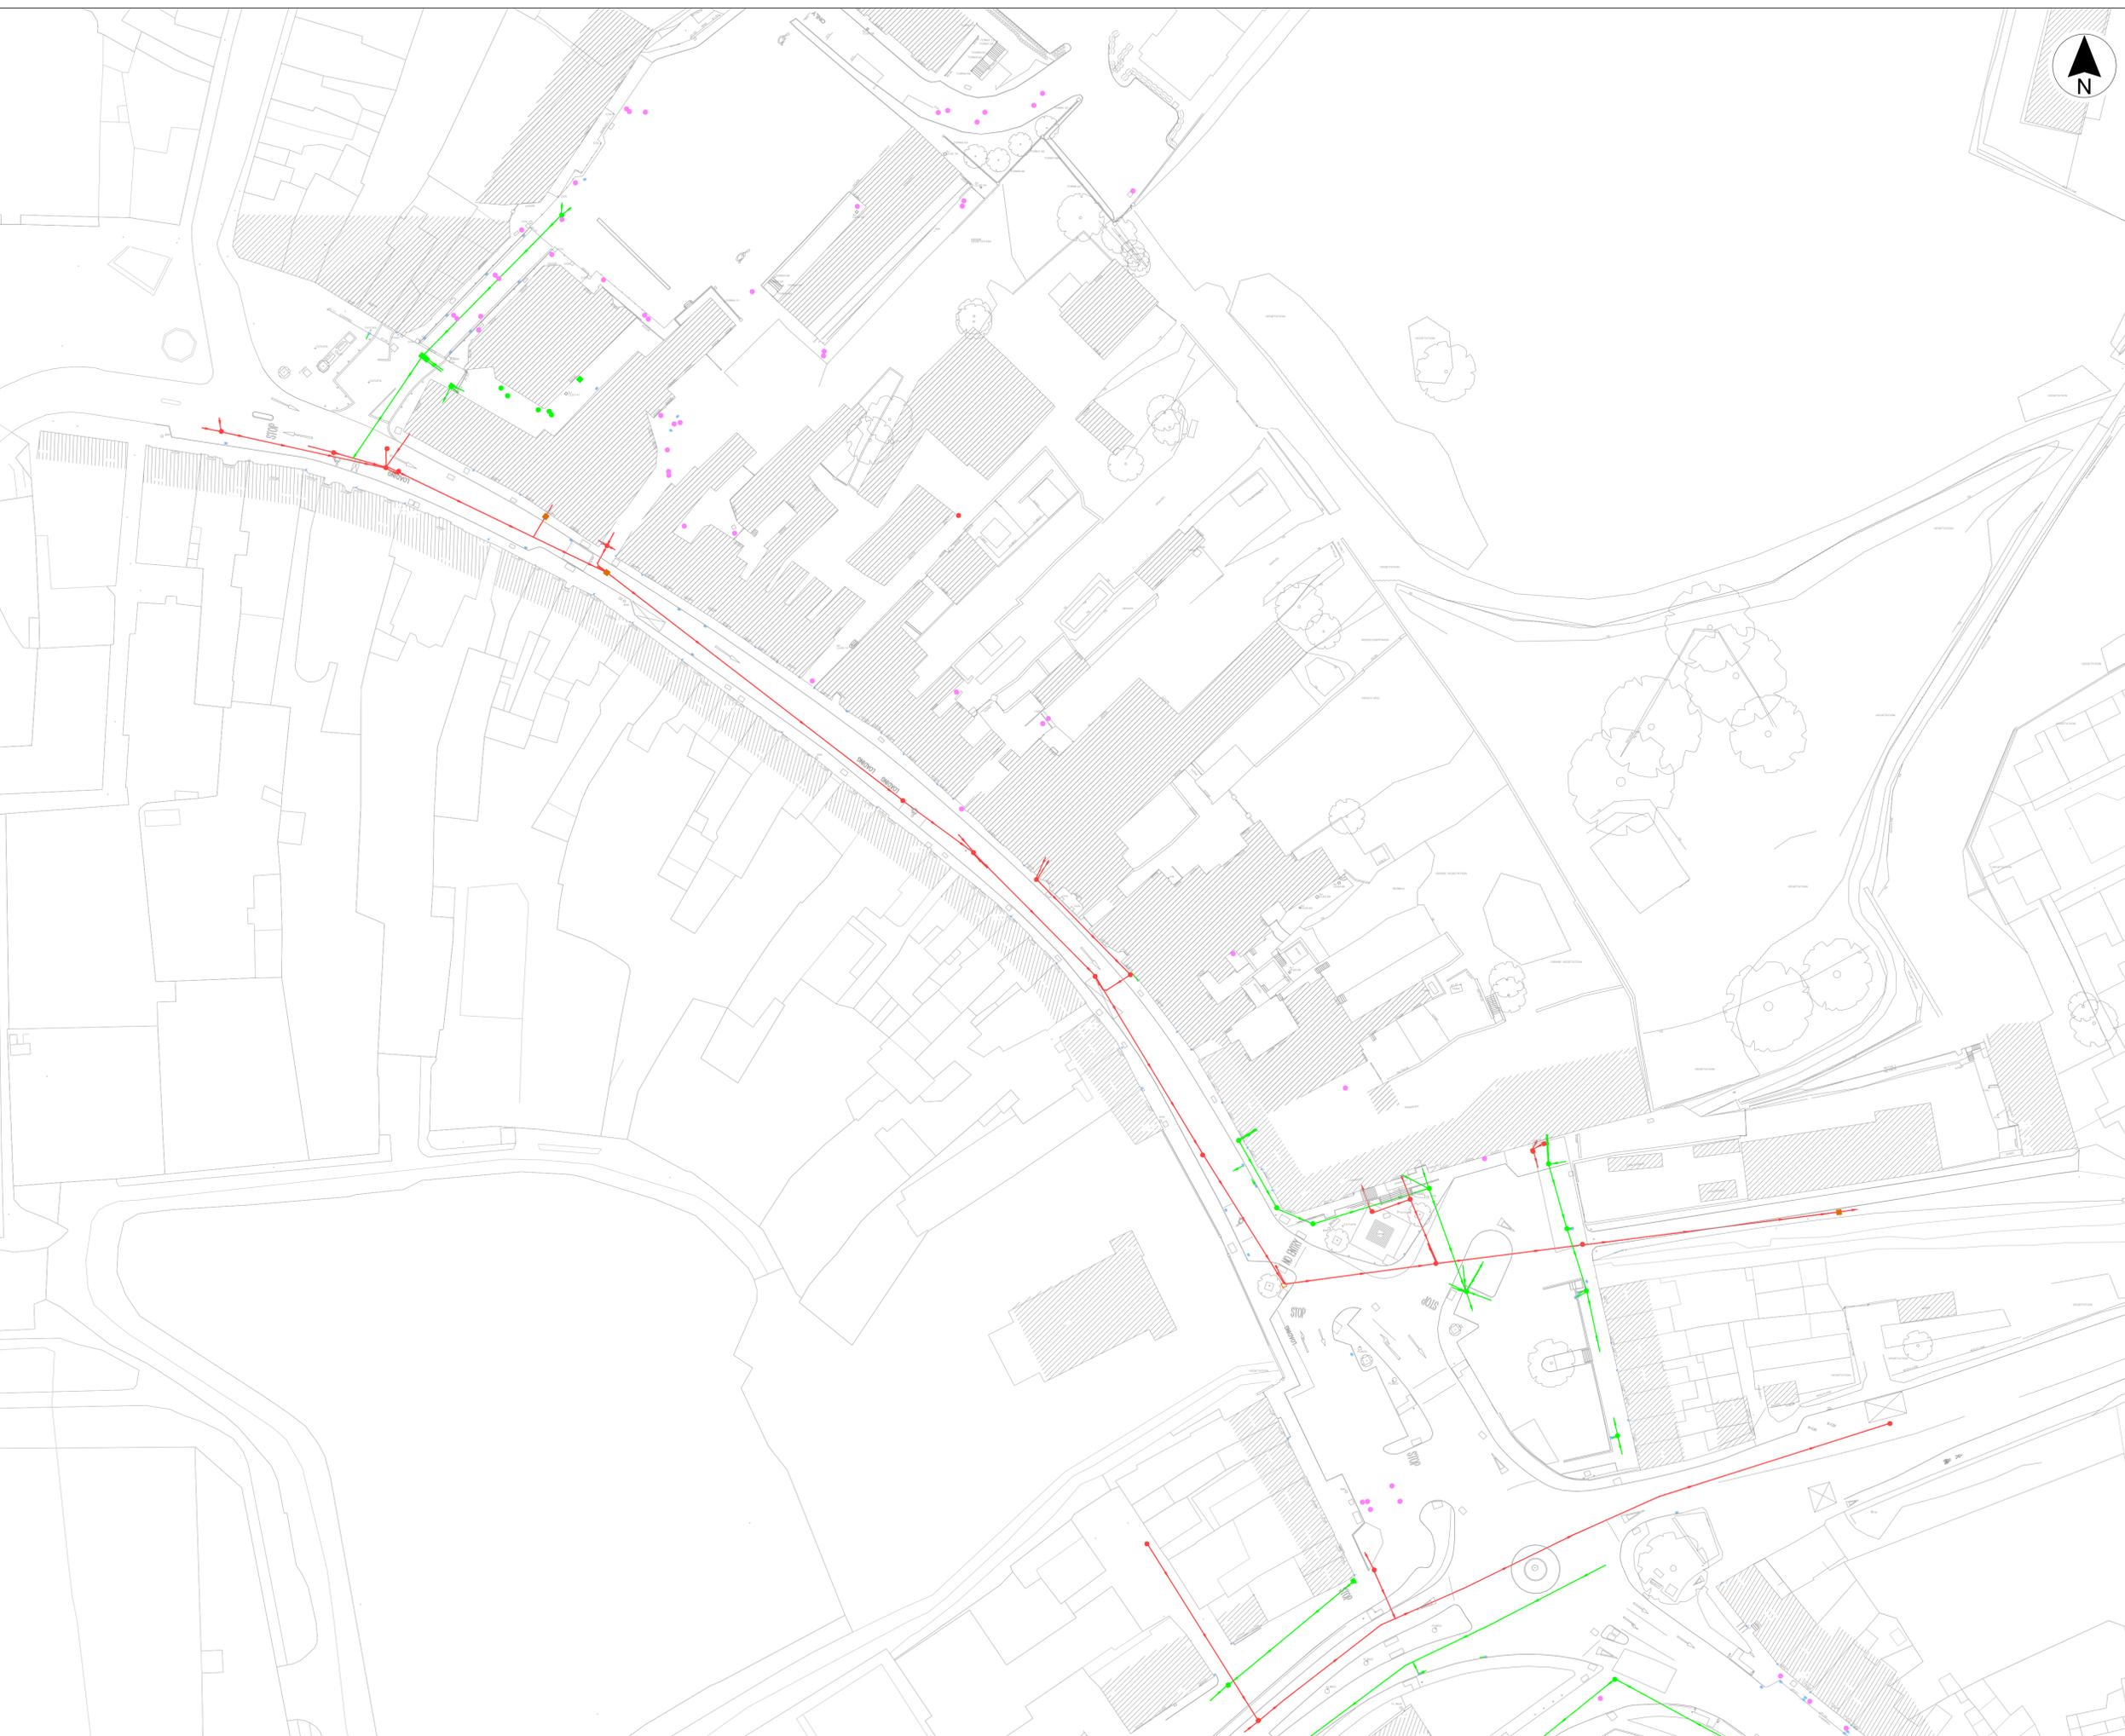

- LEGEND:**
- FOUL / COMBINED SEWER (UISCE EIRRAN)
  - STORM WATER SEWER (MONAGHAN CO. COUNCIL)
  - MANHOLE (UNKNOWN OWNERSHIP / FUNCTION)
  - STORM WATER GULLY
  - BUILDING DOWNPIPE



Includes Ordnance Survey Ireland data reproduced under OSI Licence No. 2020/OSI/ NMA 158 Monaghan County Council. Unauthorised reproduction infringes Ordnance Survey Ireland. Government of Ireland copyright. © Ordnance Survey Ireland, 2023

P01	04.02.25	First Issue for planning	DSA
Rev	Date	Description	App
Project Manager, Civil & Structural Engineers			

**McAdam**  
ENHANCING LOCAL COMMUNITIES  
 1c Montgomery House  
 478 Castlereagh Road  
 Belfast, BT5 6BQ  
 T: 028 9040 2000  
 E: admin@mcadamdesign.co.uk  
 www.mcadamdesign.co.uk

Landscape Architects  
**open**  
optimised environments  
 Optimised Environments Ltd  
 Quartermile two, 2 Lister Square  
 Edinburgh, EH3 9GL  
 T: 0131 221 5920  
 www.op-en.co.uk | info@op-en.co.uk

Client  
 **Comhairle Contae Mhuineacháin**  
 Monaghan County Council

Project Status **STAGE 3 - PLANNING**

Project **NORTH DUBLIN STREET & BACKLANDS REGENERATION PROJECT**

Drawing **EXISTING DRAINAGE PLAN**

Scale **1:500 @ A1**

Drawn	DSA	Checked	KOS	Approved	KOS
Date	04.02.25	Date	04.02.25	Date	04.02.25

Project	Organisation - Zone - Level - Type - Role - Number - Revision
DSN	MCA - ZZ - XX - DR - CE - 1030 - P01

Project Number	Status code & Description
E2442	S2 For Information

All dimensions are in metres. Figured dimensions to be taken in preference to scaled dimensions. Dimensions to be checked on site. © 2023 McAdam Design Ltd.