


10

			1	18/JUN/2021	ISSUED FOR PLANNING	ТАН	JDA		DAC			
			0	30/APR/2021	ISSUED FOR PLANNING	BJR	JDA		DAC		$ \langle N \rangle$	×
			NO	DATE	REVISIONS AND RECORD OF ISSUE	DRN	DES	снк	PDE	APP		

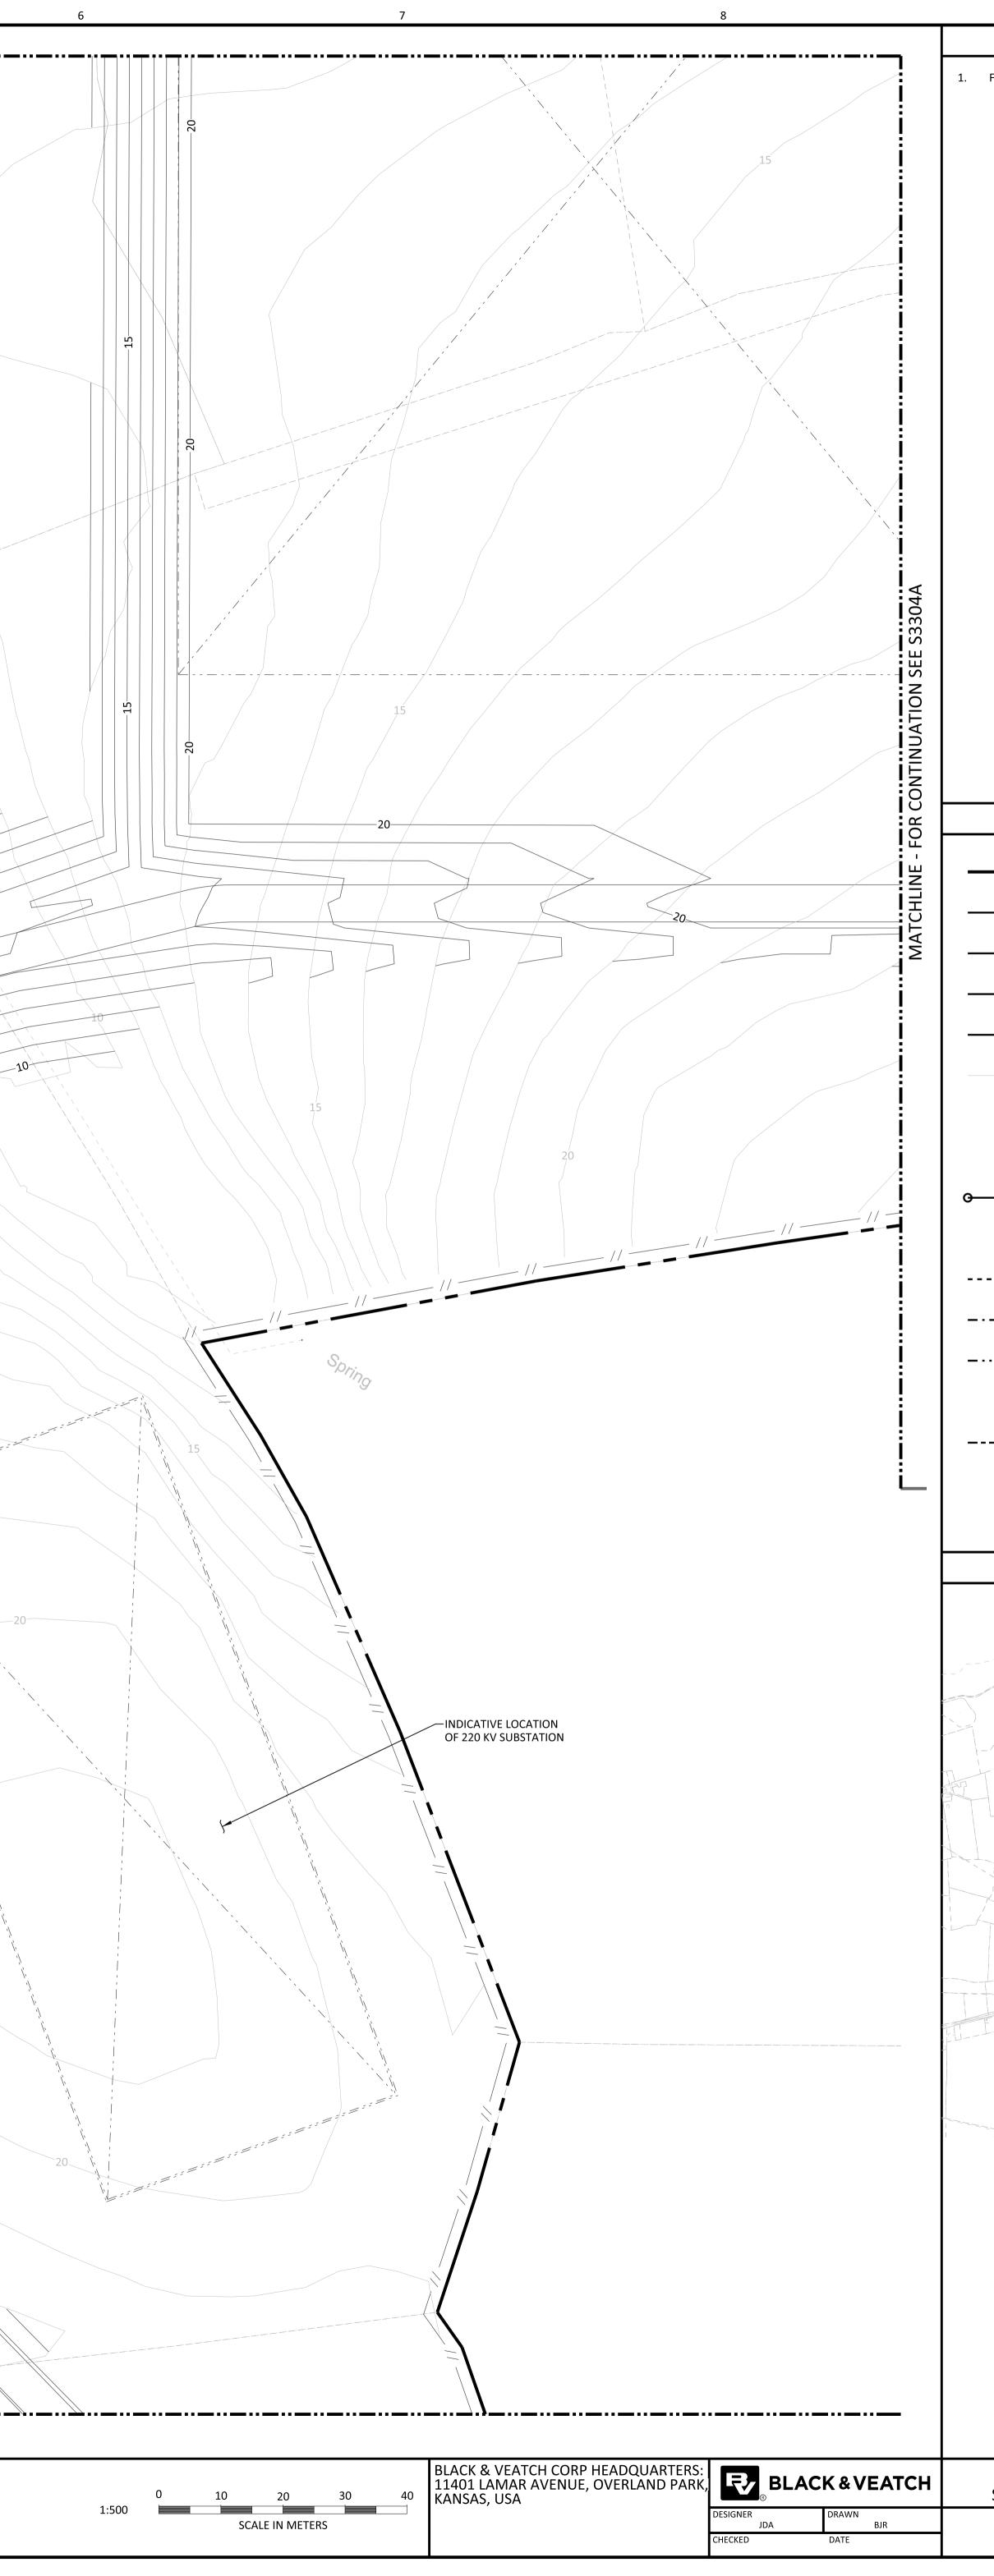

NOT TO BE U FOR CONSTRUCTION THE DISTRIBUTION AND USE OF THE NATIVE FOR FILE OF THIS DRAWING IS UNCONTROLLED. TH SHALL VERIFY TRACEABILITY OF THIS DRAWING LATEST CONTROLLED VERSION.	DRMAT CAD E USER	ON		
SHANNON LNG LIMITED SHANNON TECHNOLOGY AND ENERGY PARK	PROJECT	DRAWING NUMBER		
SANITARY LAYOUT - SITE PLAN - AREA 2	CODE			

	KEY PLAN
M	ELEVATED FIREWATER MONITOR
>	PROPOSED SWALE
71	PETROLEUM INTERCEPTOR
	SANITARY PIPING
	POTABLE WATER PIPING
	FIRE WATER PIPING
8	HYDRANT
Ð	PROPOSED STORMWATER PIPE AND CATCH BASIN
—	NEW CULVERT

S33C

53305A

S3303

S3302A-

S3301A

	LEGEND	
	PROJECT (REDLINE) BOUNDARY	
——————————————————————————————————————	SECURITY FENCE	
// //	2.9 M HIGH CHAIN LINK SECURITY FENCE WITH BARBED WIRE	
— o — _ o –	4.0 M HIGH PALISADE AND ELECTRIC WIRE FENCE	
99	NEW CONTOUR	
99	EXISTING CONTOUR	
	GRADE SURFACE FLOW INDICATOR	
\rightarrow	NEW CULVERT	
ο	PROPOSED STORMWATER PIPE AND CATCH BASIN	
\otimes	HYDRANT	
	FIRE WATER PIPING	1
	POTABLE WATER PIPING	
	SANITARY PIPING	
Ы	PETROLEUM INTERCEPTOR	
>	PROPOSED SWALE	
EM	ELEVATED FIREWATER MONITOR	

1. FOR GENERAL NOTES SEE DRAWING 1STF-S3000.