


| 3 | 4<br>MATCHLINE - FOR CONTIN | 5<br>NUATION SEE S3303C |  |
|---|-----------------------------|-------------------------|--|
|   |                             |                         |  |
|   |                             |                         |  |
|   |                             |                         |  |
|   |                             | 15                      |  |
|   |                             |                         |  |
|   |                             |                         |  |
|   | MATCHLINE - FOR CONTIN      | NUATION SEE \$3301C     |  |

|  |  |  | 1  | 18/JUN/2021 | ISSUED FOR PLANNING           | TAH | JDA |     | DAC |     |                       |   |
|--|--|--|----|-------------|-------------------------------|-----|-----|-----|-----|-----|-----------------------|---|
|  |  |  | 0  | 30/APR/2021 | ISSUED FOR PLANNING           | BJR | JDA |     | DAC |     | $  \langle N \rangle$ | × |
|  |  |  | NO | DATE        | REVISIONS AND RECORD OF ISSUE | DRN | DES | СНК | PDE | APP |                       |   |
|  |  |  |    |             |                               |     |     |     |     |     |                       |   |

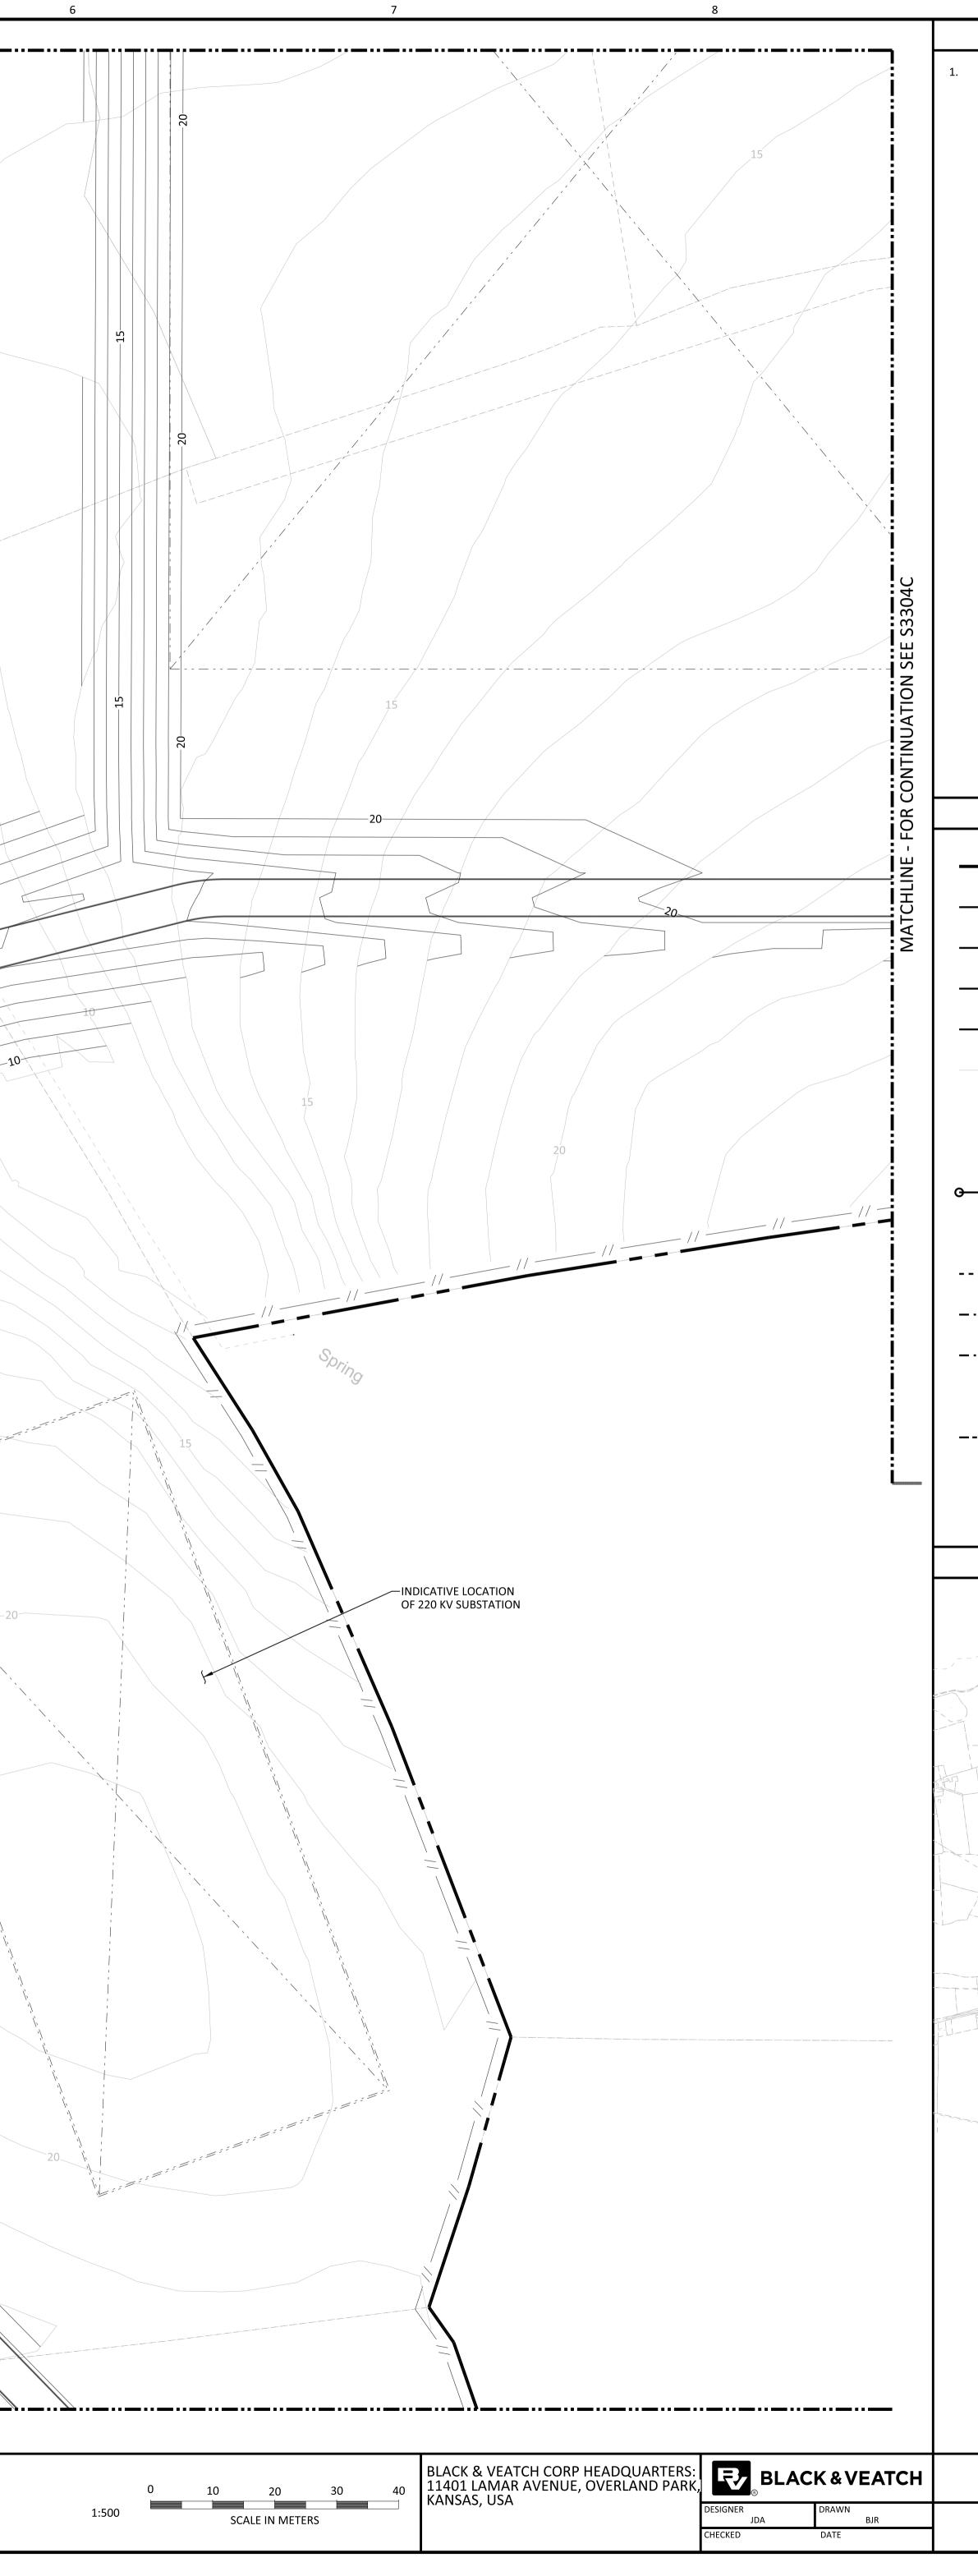

| <b>NOT TO BE U</b><br><b>FOR CONSTRUCTION</b><br>THE DISTRIBUTION AND USE OF THE NATIVE FOR<br>FILE OF THIS DRAWING IS UNCONTROLLED. TH<br>SHALL VERIFY TRACEABILITY OF THIS DRAWING<br>LATEST CONTROLLED VERSION. | UCTI<br>DRMAT CAD<br>E USER | ON             |
|--|-----------------------------|----------------|
| SHANNON LNG LIMITED<br>SHANNON TECHNOLOGY AND ENERGY PARK  | PROJECT<br>198291-1         | DRAWING NUMBER |

FIRE WATER LAYOUT - SITE PLAN - AREA 2

| \$3303C | S3307C S3308C |
|---------|---------------|
| S3302C  | S3304C S3306C |
| S3301C  | \$3305C       |

## KEY PLAN

| LEGEND                                 |   |   |  |
|--|---|---|--|
|  | PROJECT (REDLINE) BOUNDARY                            |   |  |
| —————————————————————————————————————— | SECURITY FENCE  |   |  |
| // //                                  | 2.9 M HIGH CHAIN LINK SECURITY FENCE WITH BARBED WIRE |   |  |
| —— o ——— o –                           | 4.0 M HIGH PALISADE AND ELECTRIC WIRE FENCE           |   |  |
|  | NEW CONTOUR   |   |  |
| 99                                     | EXISTING CONTOUR                                      |   |  |
|  | GRADE SURFACE FLOW INDICATOR                          |   |  |
| $\rightarrow$                          | NEW CULVERT   |   |  |
| θΘ                                     | PROPOSED STORMWATER PIPE AND CATCH BASIN              |   |  |
| $\otimes$                              | HYDRANT   |   |  |
|  | FIRE WATER PIPING                                     | C |  |
|  | POTABLE WATER PIPING                                  |   |  |
|  | SANITARY PIPING                                       |   |  |
| Ы                                      | PETROLEUM INTERCEPTOR                                 |   |  |
|  | PROPOSED SWALE  |   |  |
| EM                                     | ELEVATED FIREWATER MONITOR                            |   |  |
|  |   |   |  |