


3	4 5	
	10	
		/
		/
5		
		/
		/
	_10	
	MATCHLINE - FOR CONTINUATION SEE \$3302C	

									$(\land \land)$
			1	18/JUN/2021	ISSUED FOR PLANNING	ТАН	JDA	DAC	
			0	30/APR/2021	ISSUED FOR PLANNING	BJR	JDA	DAC	$\langle N \rangle$
			NO	DATE	REVISIONS AND RECORD OF ISSUE	DRN	DES C	HK PDE APP	

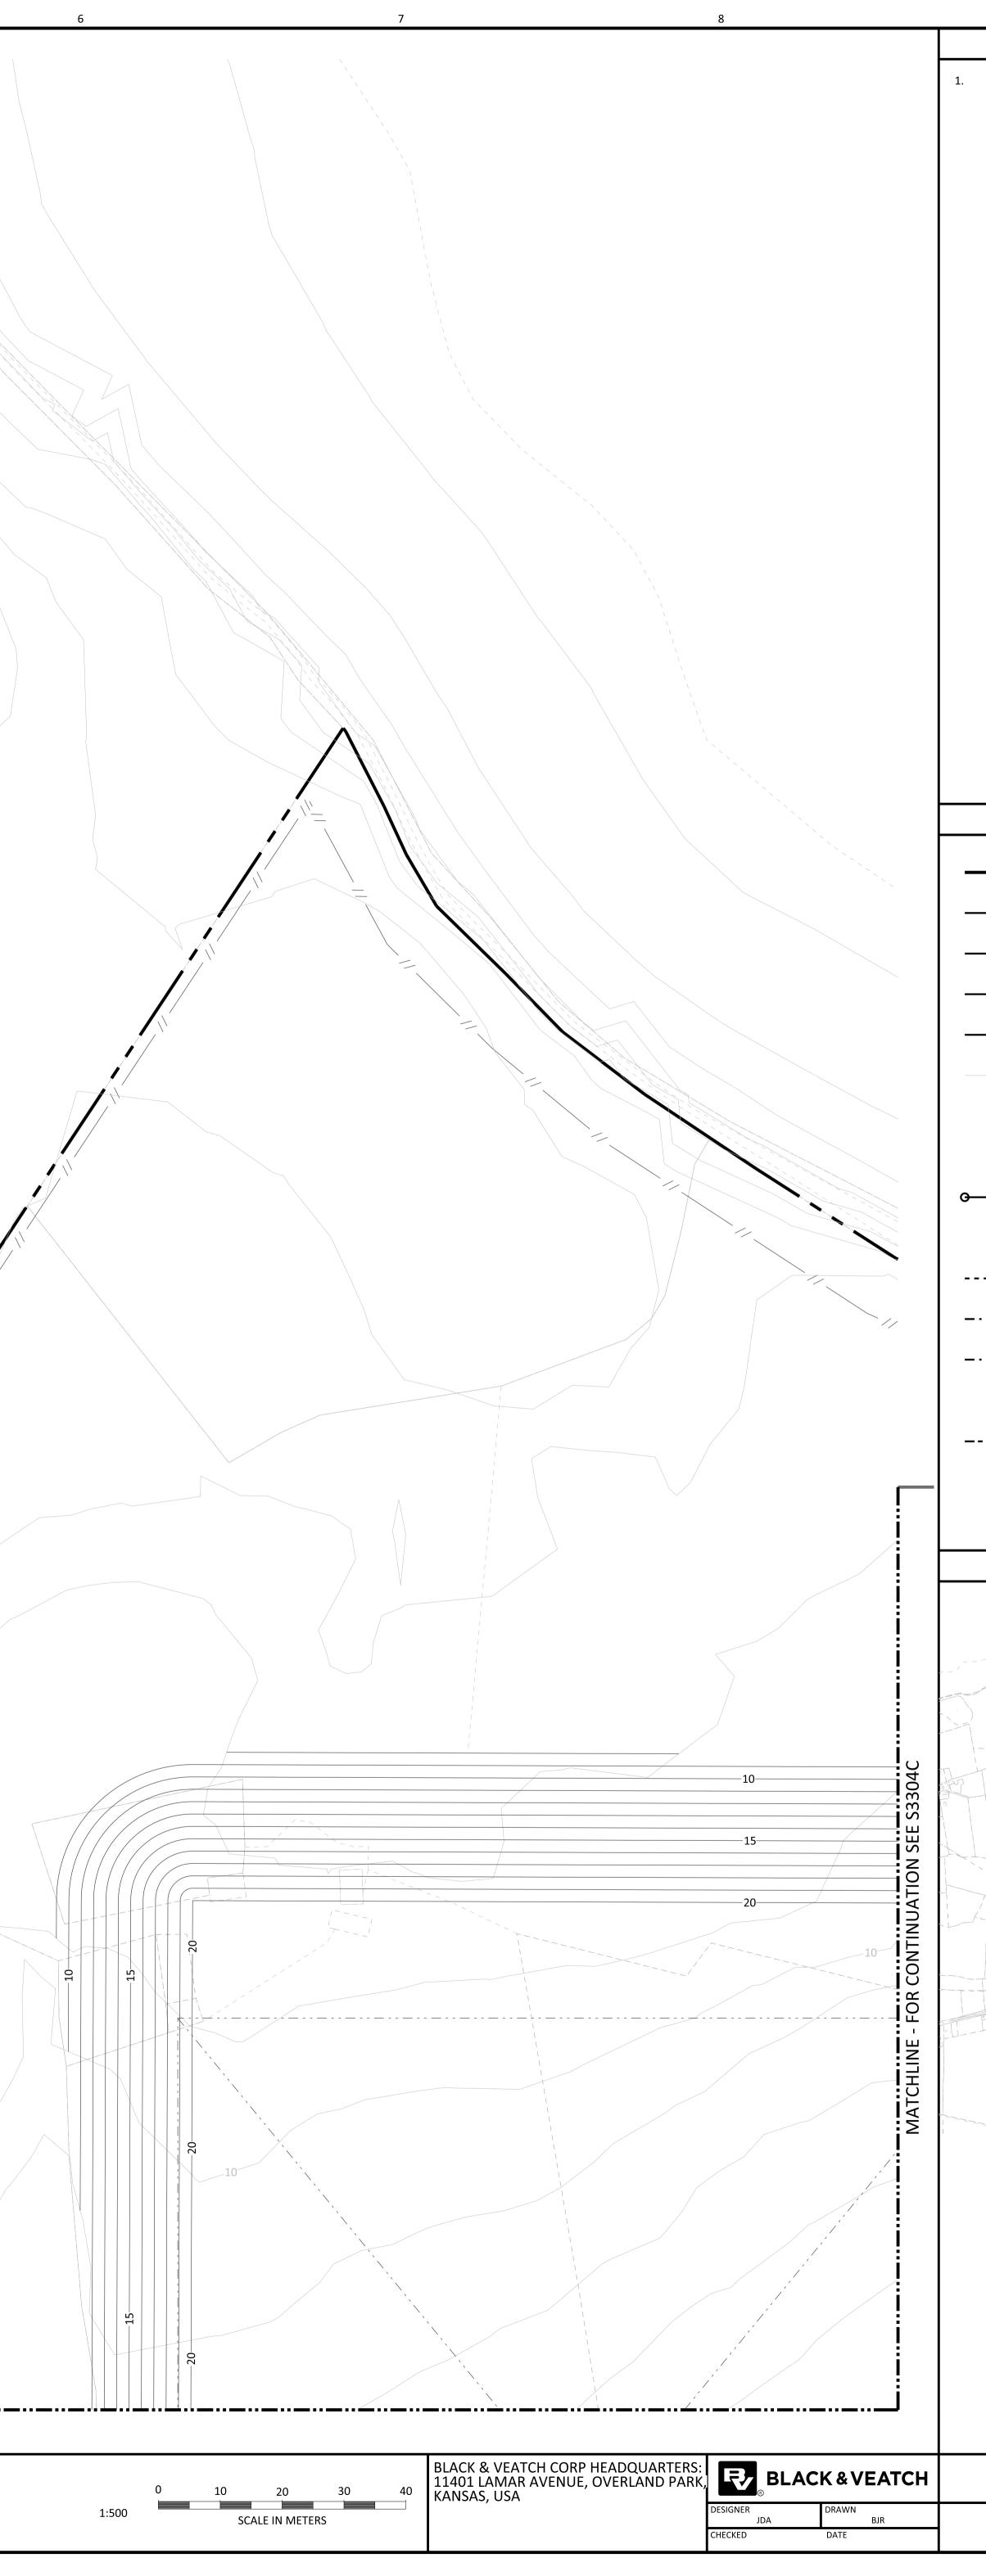

NOT TO BE U FOR CONSTRUCTION THE DISTRIBUTION AND USE OF THE NATIVE FO FILE OF THIS DRAWING IS UNCONTROLLED. TH SHALL VERIFY TRACEABILITY OF THIS DRAWING LATEST CONTROLLED VERSION.	DRMAT CAD E USER	DN
SHANNON LNG LIMITED SHANNON TECHNOLOGY AND ENERGY PARK	PROJECT 198291-15	DRAWING NUMBER

CODE

FIRE WATER LAYOUT - SITE PLAN - AREA 3

S3303C	S3307C S3308C
S3304C	S3306C
S3302C	S3305C
S3301C	

KEY PLAN

LEGEND					
	PROJECT (REDLINE) BOUNDARY				
——————————————————————————————————————	SECURITY FENCE				
// //	2.9 M HIGH CHAIN LINK SECURITY FENCE WITH BARBED WIRE				
—— o —— o –	4.0 M HIGH PALISADE AND ELECTRIC WIRE FENCE				
99	NEW CONTOUR				
99	EXISTING CONTOUR				
-	GRADE SURFACE FLOW INDICATOR				
\rightarrow	NEW CULVERT				
• • • • •	PROPOSED STORMWATER PIPE AND CATCH BASIN				
\otimes	HYDRANT				
	FIRE WATER PIPING	٦			
	POTABLE WATER PIPING				
	SANITARY PIPING				
PI	PETROLEUM INTERCEPTOR				
	PROPOSED SWALE				
EM	ELEVATED FIREWATER MONITOR				