


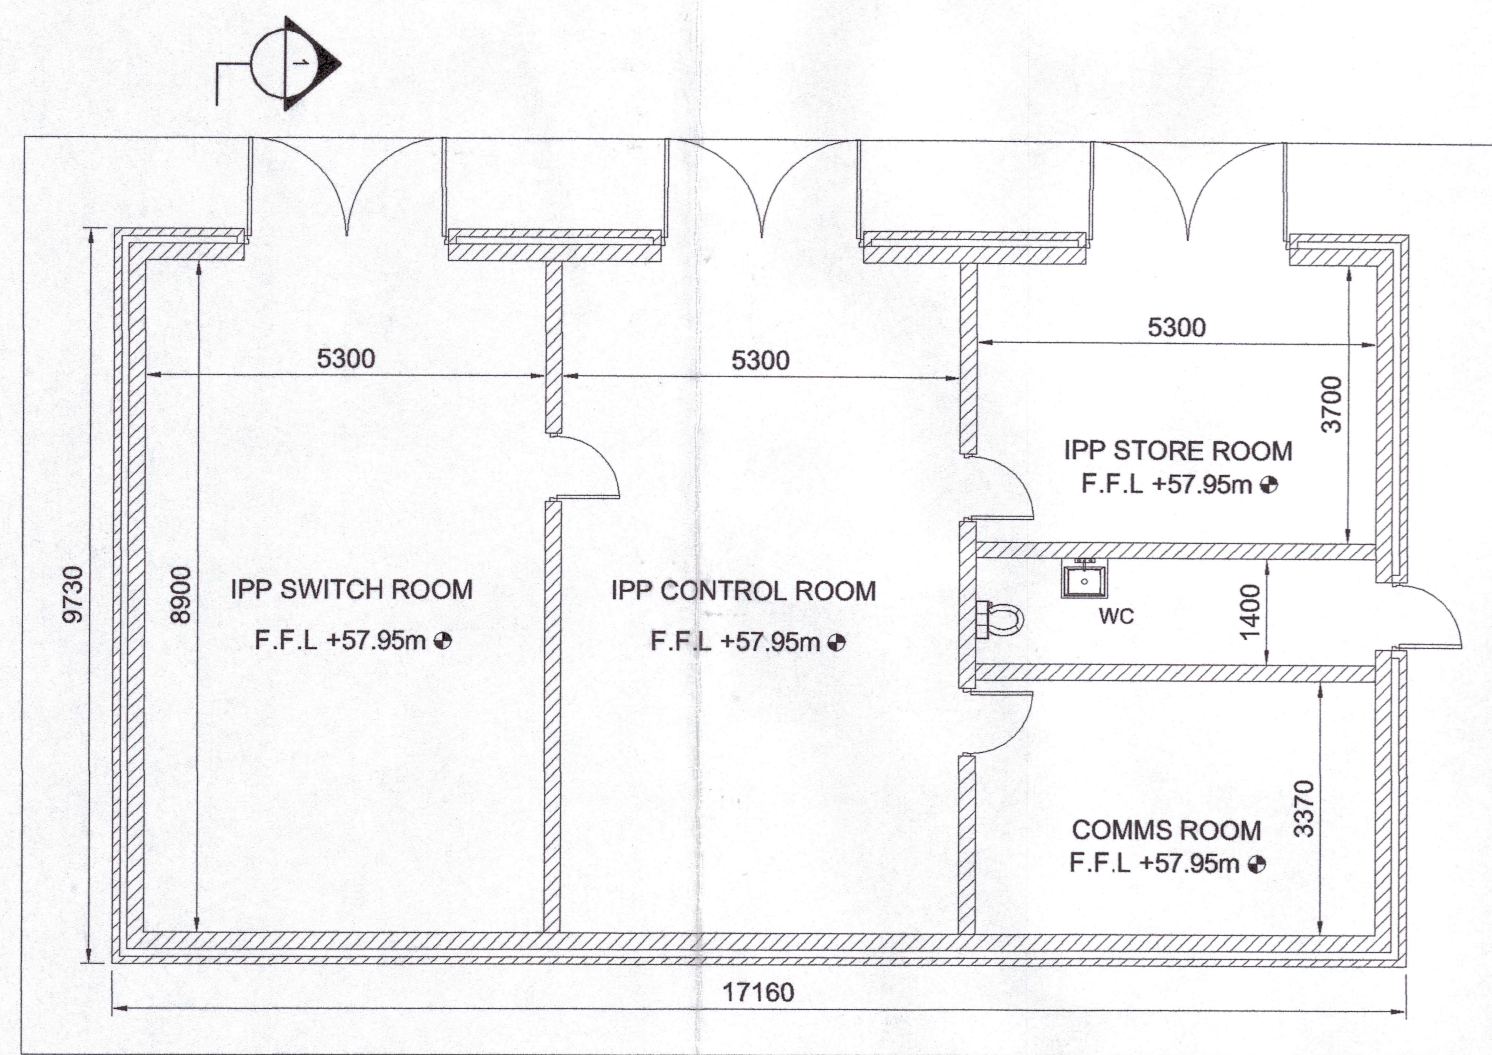


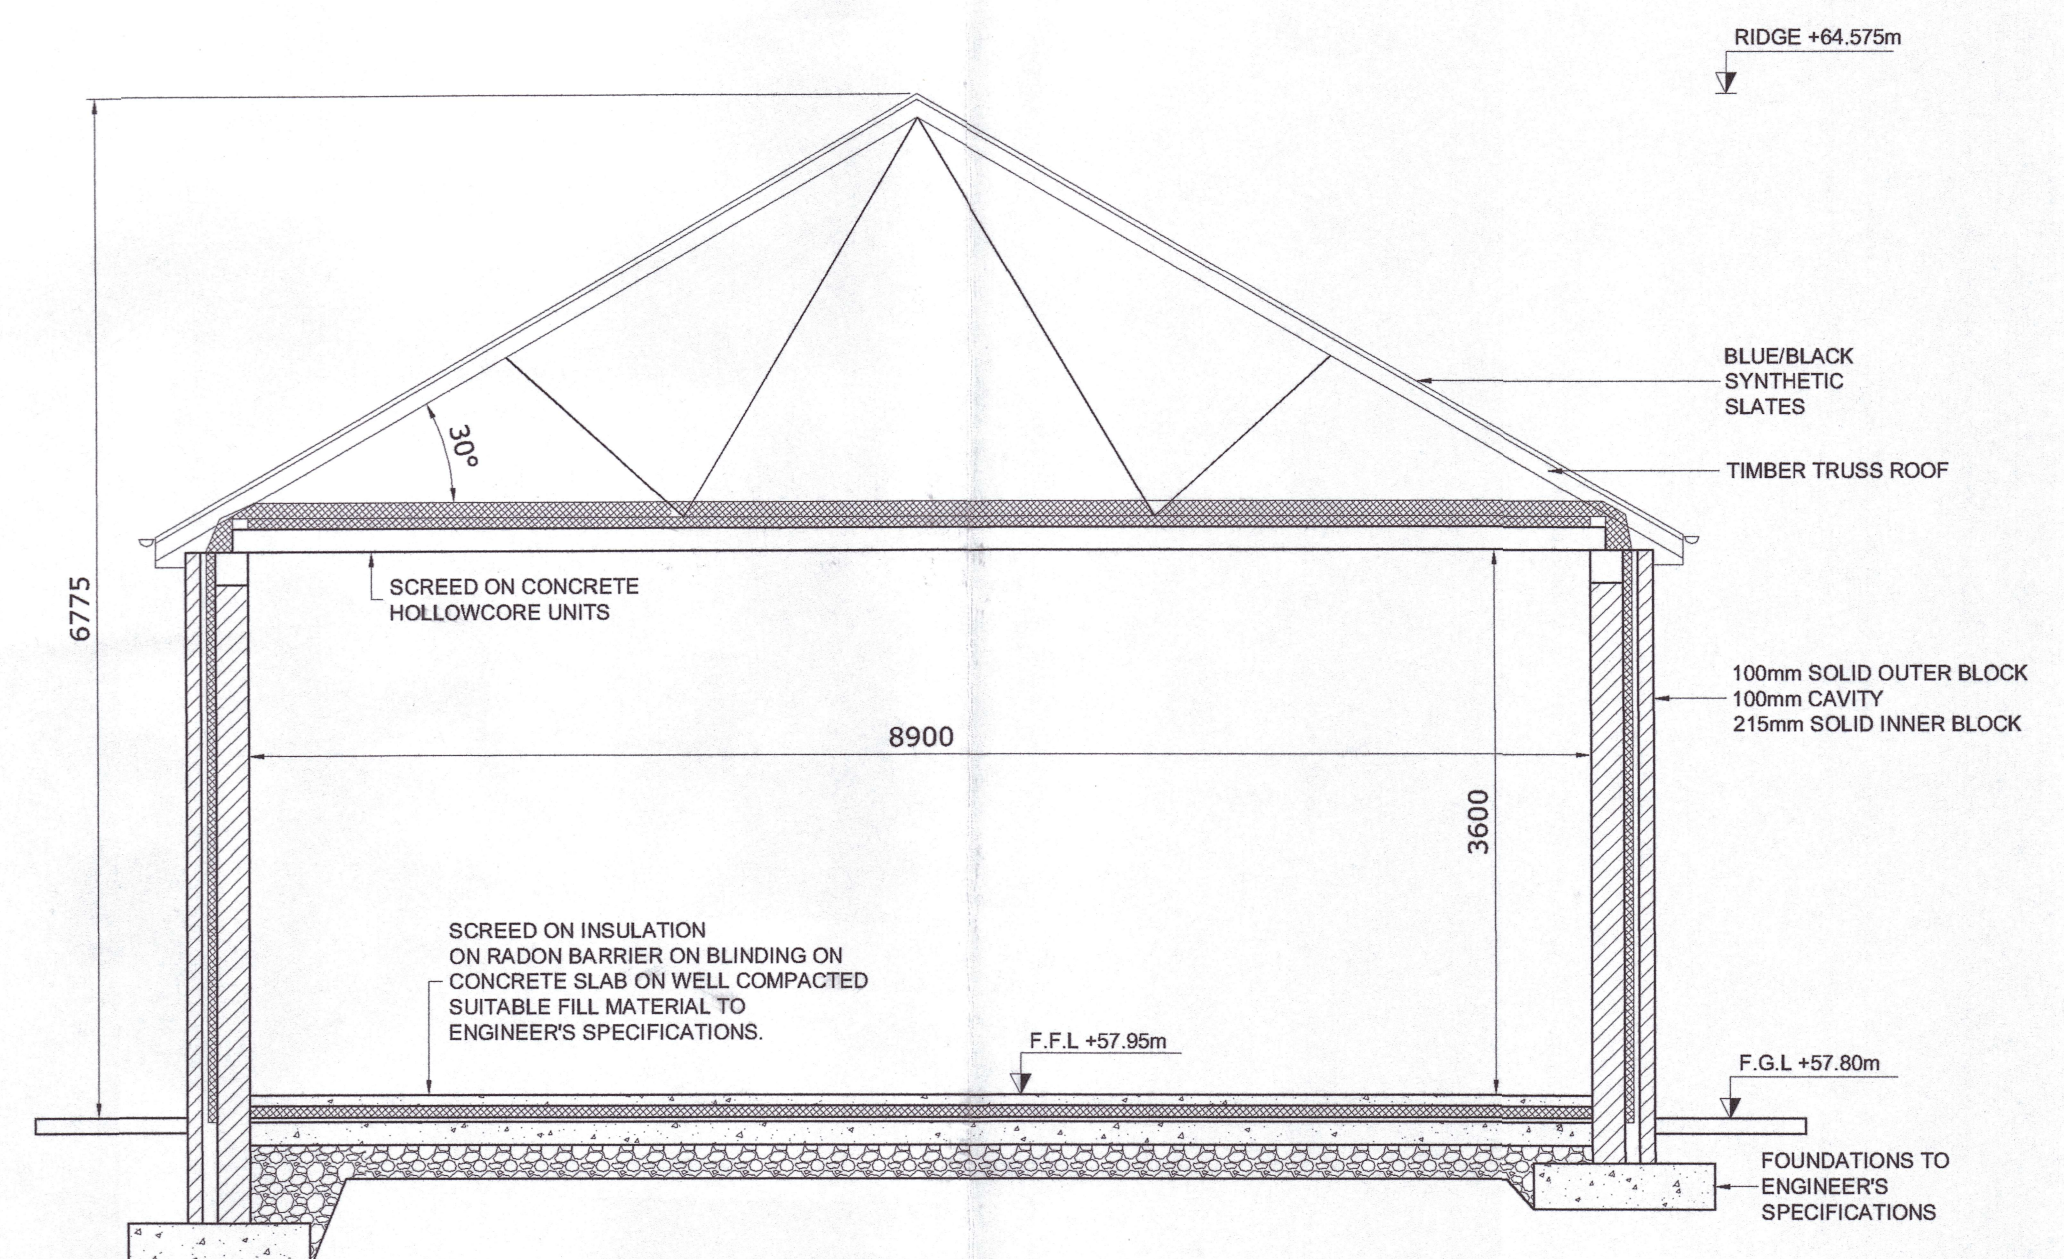


IPP BUILDING FLOOR LAYOUT
SCALE 1:100

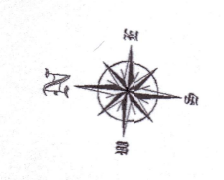


SECTION 1-1
SCALE 1:50

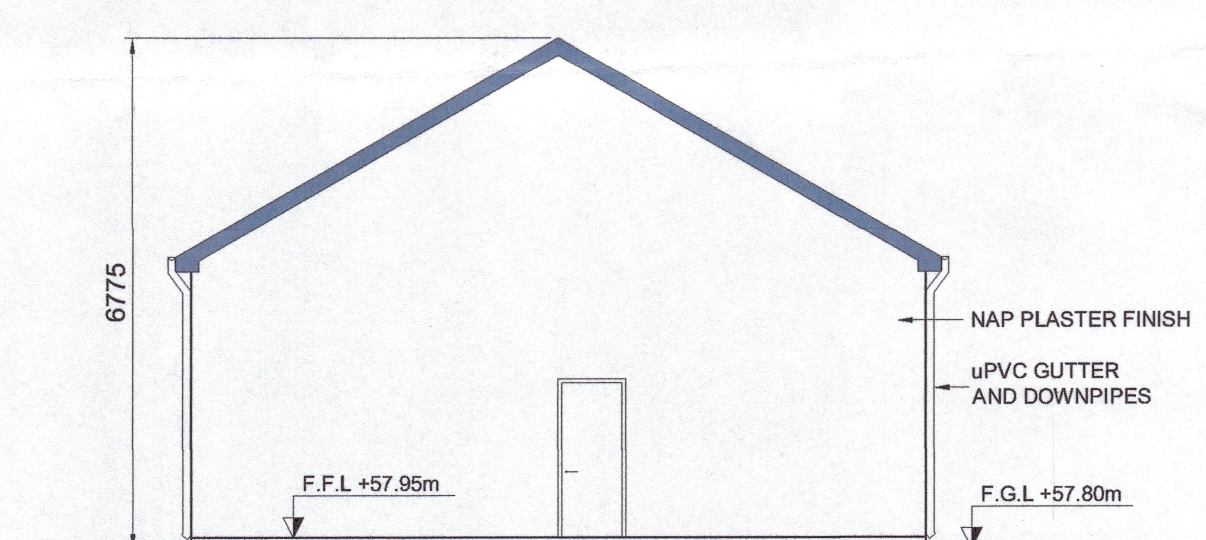


SOUTH ELEVATION
SCALE 1:100

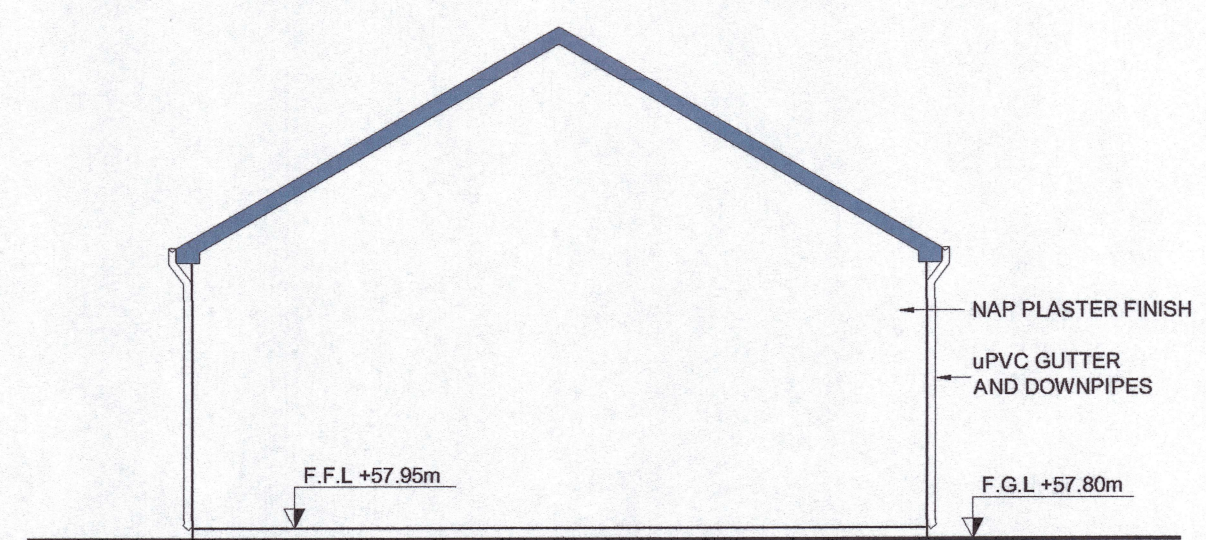


NORTH ELEVATION
SCALE 1:100

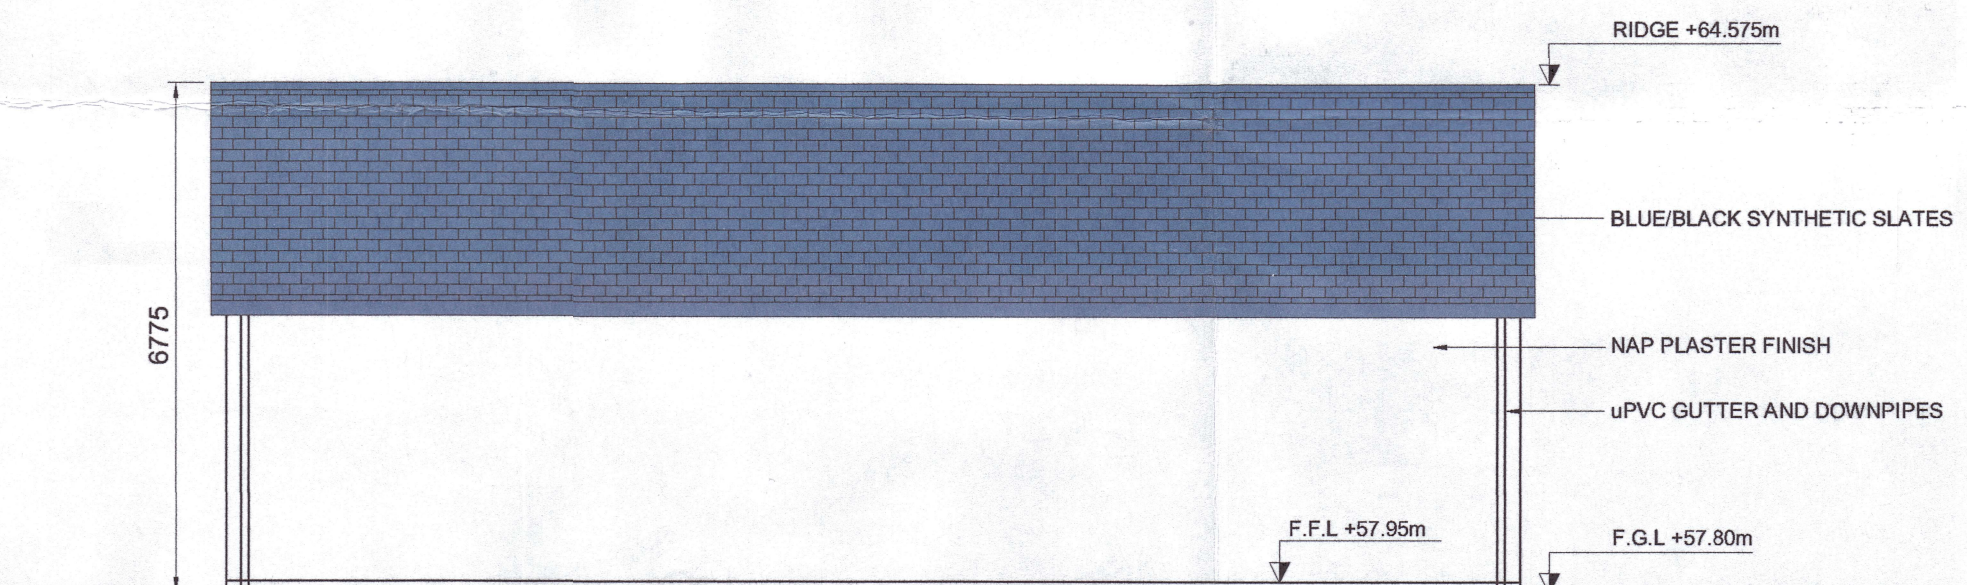


WEST ELEVATION
SCALE 1:100

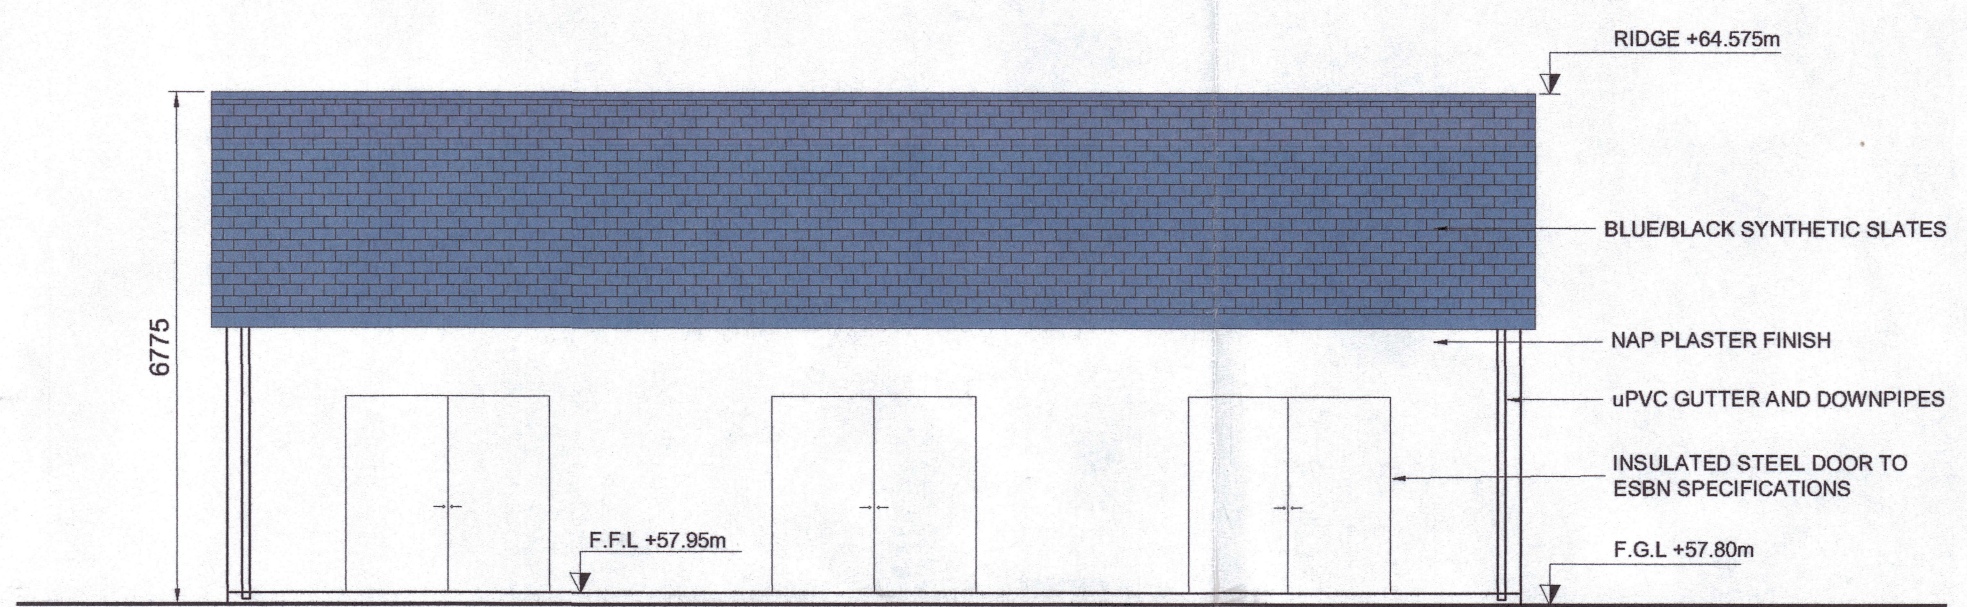


EAST ELEVATION
SCALE 1:100

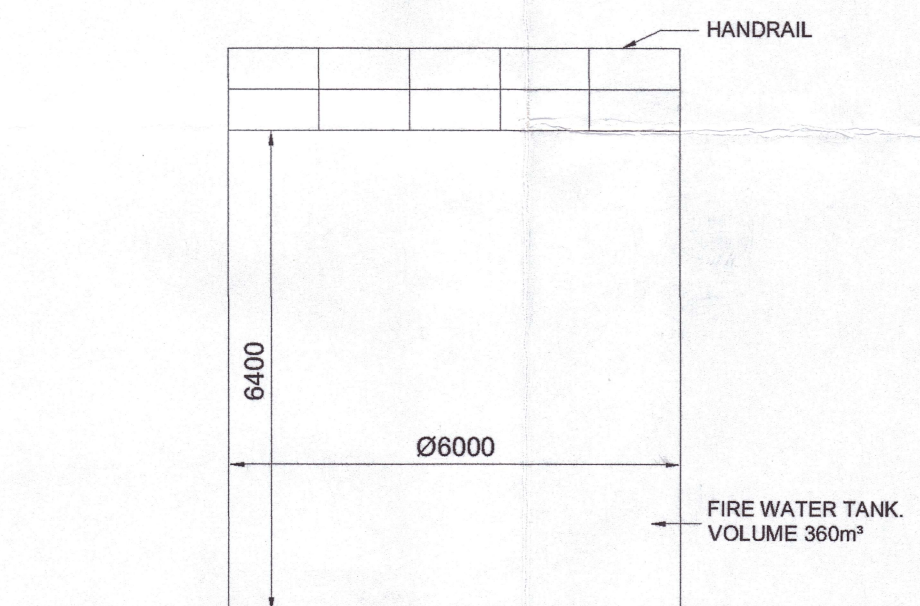


FIRE WATER TANK - EAST ELEVATION
SCALE 1:100

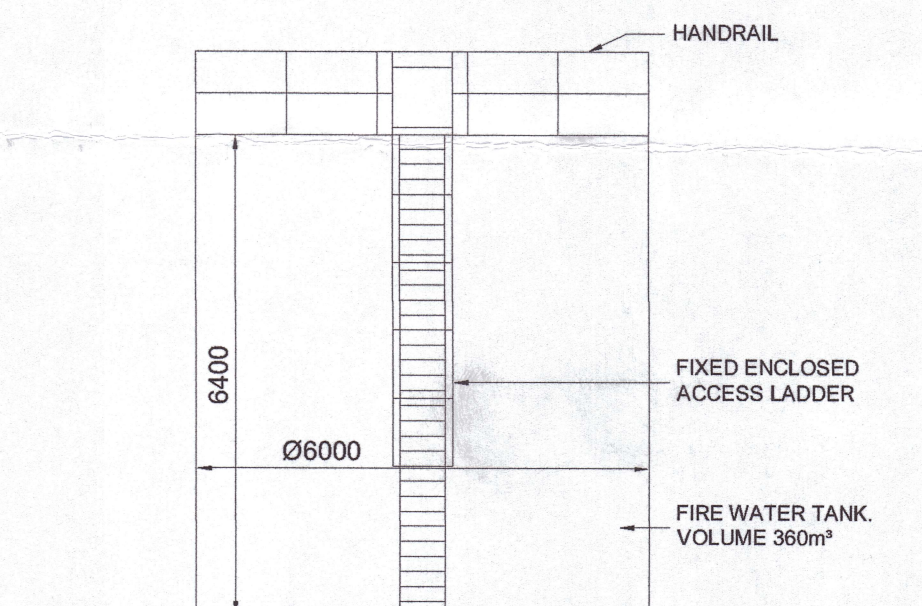

FIRE WATER TANK - EAST ELEVATION
SCALE 1:100

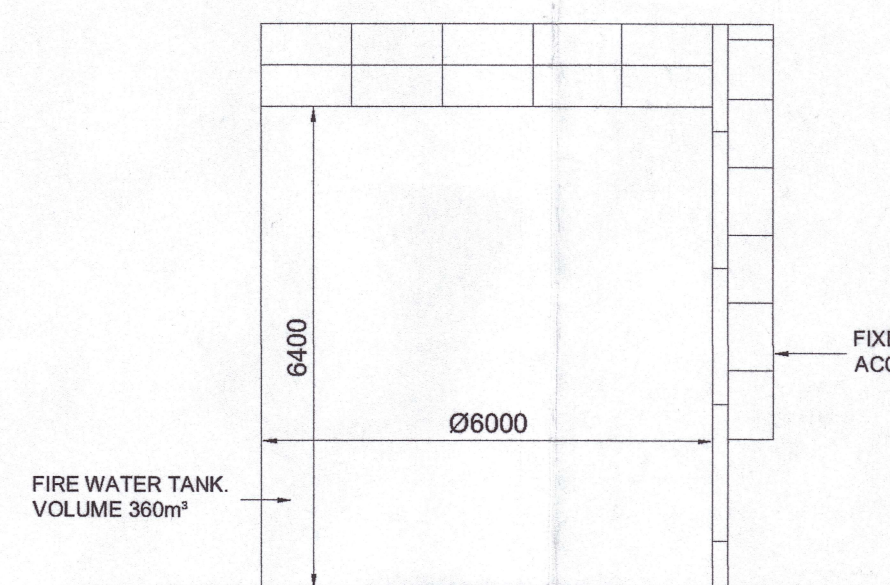

FIRE WATER TANK - SOUTH ELEVATION
SCALE 1:100

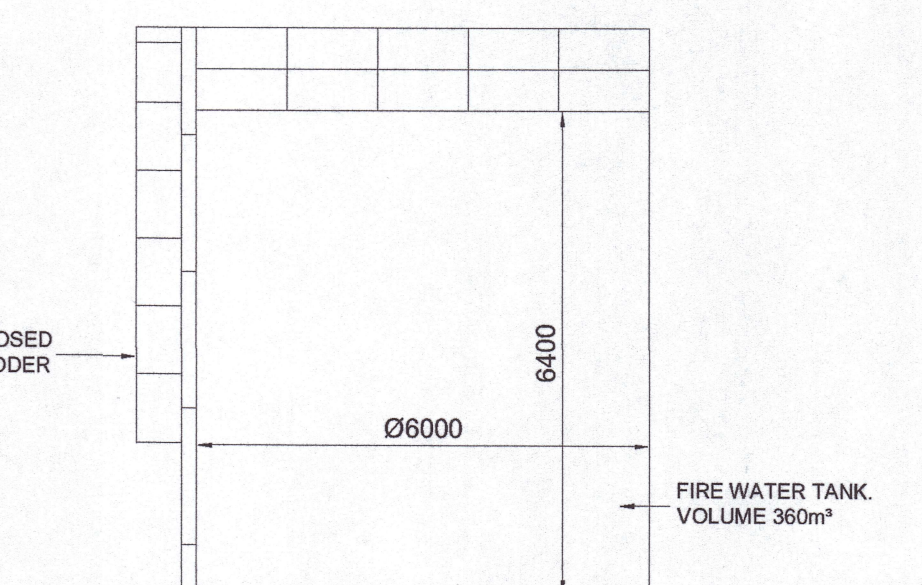


FIRE WATER TANK - NORTH ELEVATION
SCALE 1:100

NOTES:
1 FIGURED DIMENSIONS ONLY TO BE TAKEN FROM THIS DRAWING.
2 THIS DRAWING TO BE READ IN CONJUNCTION WITH ALL OTHER RELEVANT DRAWINGS AND SPECIFICATIONS.

Rev.	Modifications	By	Date
P1	PLANNING ISSUE	SK	12.12.23
P2	PLANNING FI	SK	Aug 25

© COPYRIGHT OF

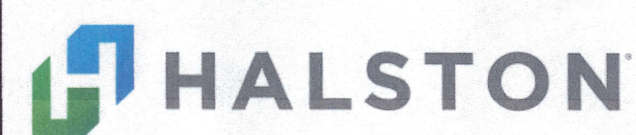

Email: info@halston.ie
Tel: 094 9010111

IHUB BUILDING
WESTPORT ROAD
CASTLEBAR
CO. MAYO.
F23 K162

Client	ARIGNA LDES LIMITED	Drawn	SK	Checked	WD	Approved	CS
Project	BATTERY ENERGY STORAGE SYSTEM (BESS) ARIGNA, Co. ROSCOMMON.	Date	SEP 2023	Scales	AS SHOWN (A1)	Sheet	1 of 1
Title	IPP BUILDING LAYOUT, ELEVATIONS & SECTION. FIRE WATER TANK DETAILS.	Job No.	SEP-0405	Rev	P2	Sheet Size	A1
Stage	PRELIMINARY	Dwg. No.	0405-P-1300				